 


SITE LOCATION




Reproduced by permission of Ordnance Survey on behalf of the Controller of Her Majesty's Stationery Office
All rights reserved. © Crown Copyright licence no. 100062043

SITE AREA PLAN




SITE PHOTOGRAPH

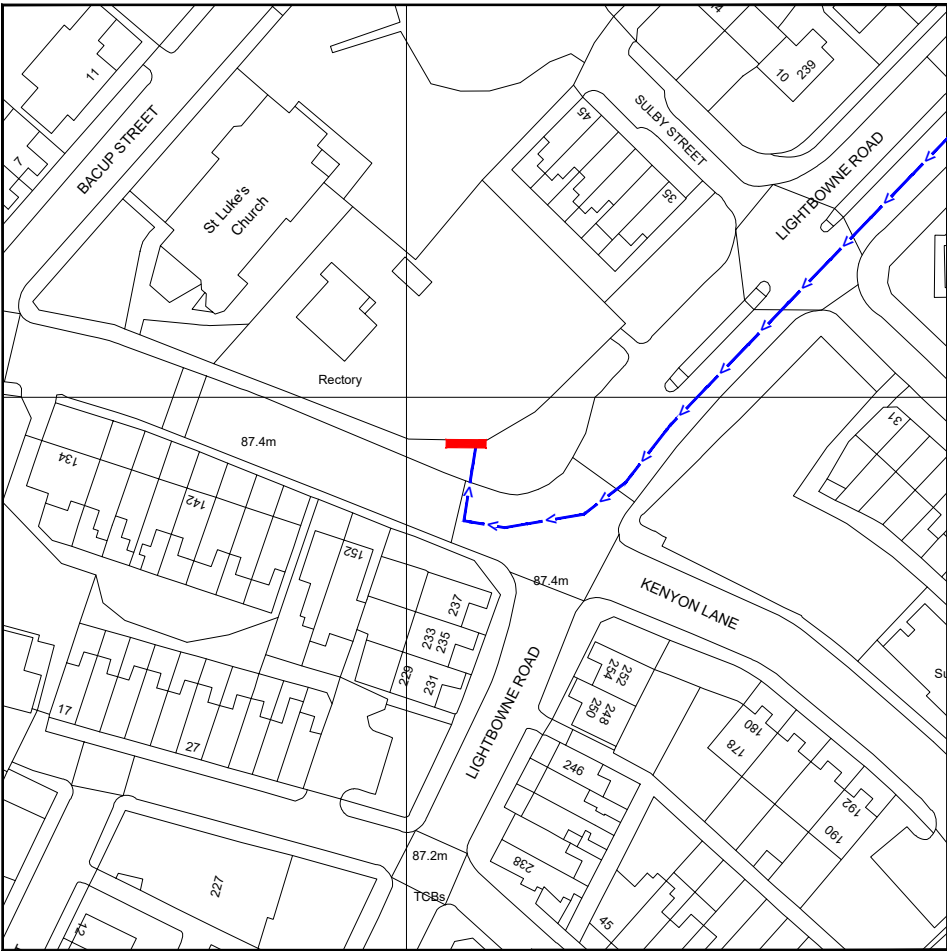

Reproduced by permission of Ordnance Survey on behalf of
the Controller of Her Majesty's Stationery Office
All rights reserved. © Crown Copyright licence no. 100062043

NGR E: 387414 N: 401494

 SITE LOCATION PLAN



GOOGLE MAPS QR CODE

GOOGLE MAPS - <https://goo.gl/maps/xnwBbz4c72eLw9sc6>

GOOGLE STREETVIEW - <https://goo.gl/maps/LefJRhyfgqXk12Wp6>

NOTES:

1. ALL DIMENSIONS IN MM UNLESS OTHERWISE NOTED.

DIRECTIONS TO SITE:

Head north on M60. At junction 21, exit towards A663/Rochdale/A627(M)/Chadderton. Turn left onto the A6104 slip road to Hollinwood/Oldham/A62/Manchester/A663. Turn left onto Semple Wy/A6104. Use any lane to turn right onto Hollinwood Ave/A6104. At the roundabout, take the 1st exit onto Lightbourne Rd/B6393. Turn right onto Kenyon Ln and site location is on the right hand side.

Site Provider's
Property Boundary:



Access Route To Site:



Access Route:



Master:	MBNL / EE:	Project:	Purpose of Issue:	Issue:
M001	MBNL	3UK DNSW	Planning	A
Date:	03/08/2022	Revision / Upgrade Description:		
Drawn:	CDN	First Issue - Site nomination dated: TBC		
Checked:	DH			
Approved:	SD			

CK Hutchison
Networks (UK)
Limited

Great Brighams Mead,
Vastern Road, Reading,
Berkshire, England,
RG1 8DJ

Design Consultant & Principal Contractor:



WHP Telecoms

Unit 1 Maple Park,
Low Fields Avenue, Leeds
LS12 6HH

Tel: 01133023550
e-mail: info@whptelecoms.com

Site Name:

KENYON LANE STREETWORKS

Site ID:

MAN23646

Address:

KENYON LANE, MOSTON,
MANCHESTER,
GREATER MANCHESTER,
ENGLAND,
M40 9DF

Title:

002 SITE LOCATION PLAN


Project:

3UK DNSW

Purpose of Issue:

PLANNING

EE Cell ID:	MBNL Cell ID:	Cell ID:
87384	MAN615	M1458
Master Drawing No:		Issue:
MAN23646_M001		A

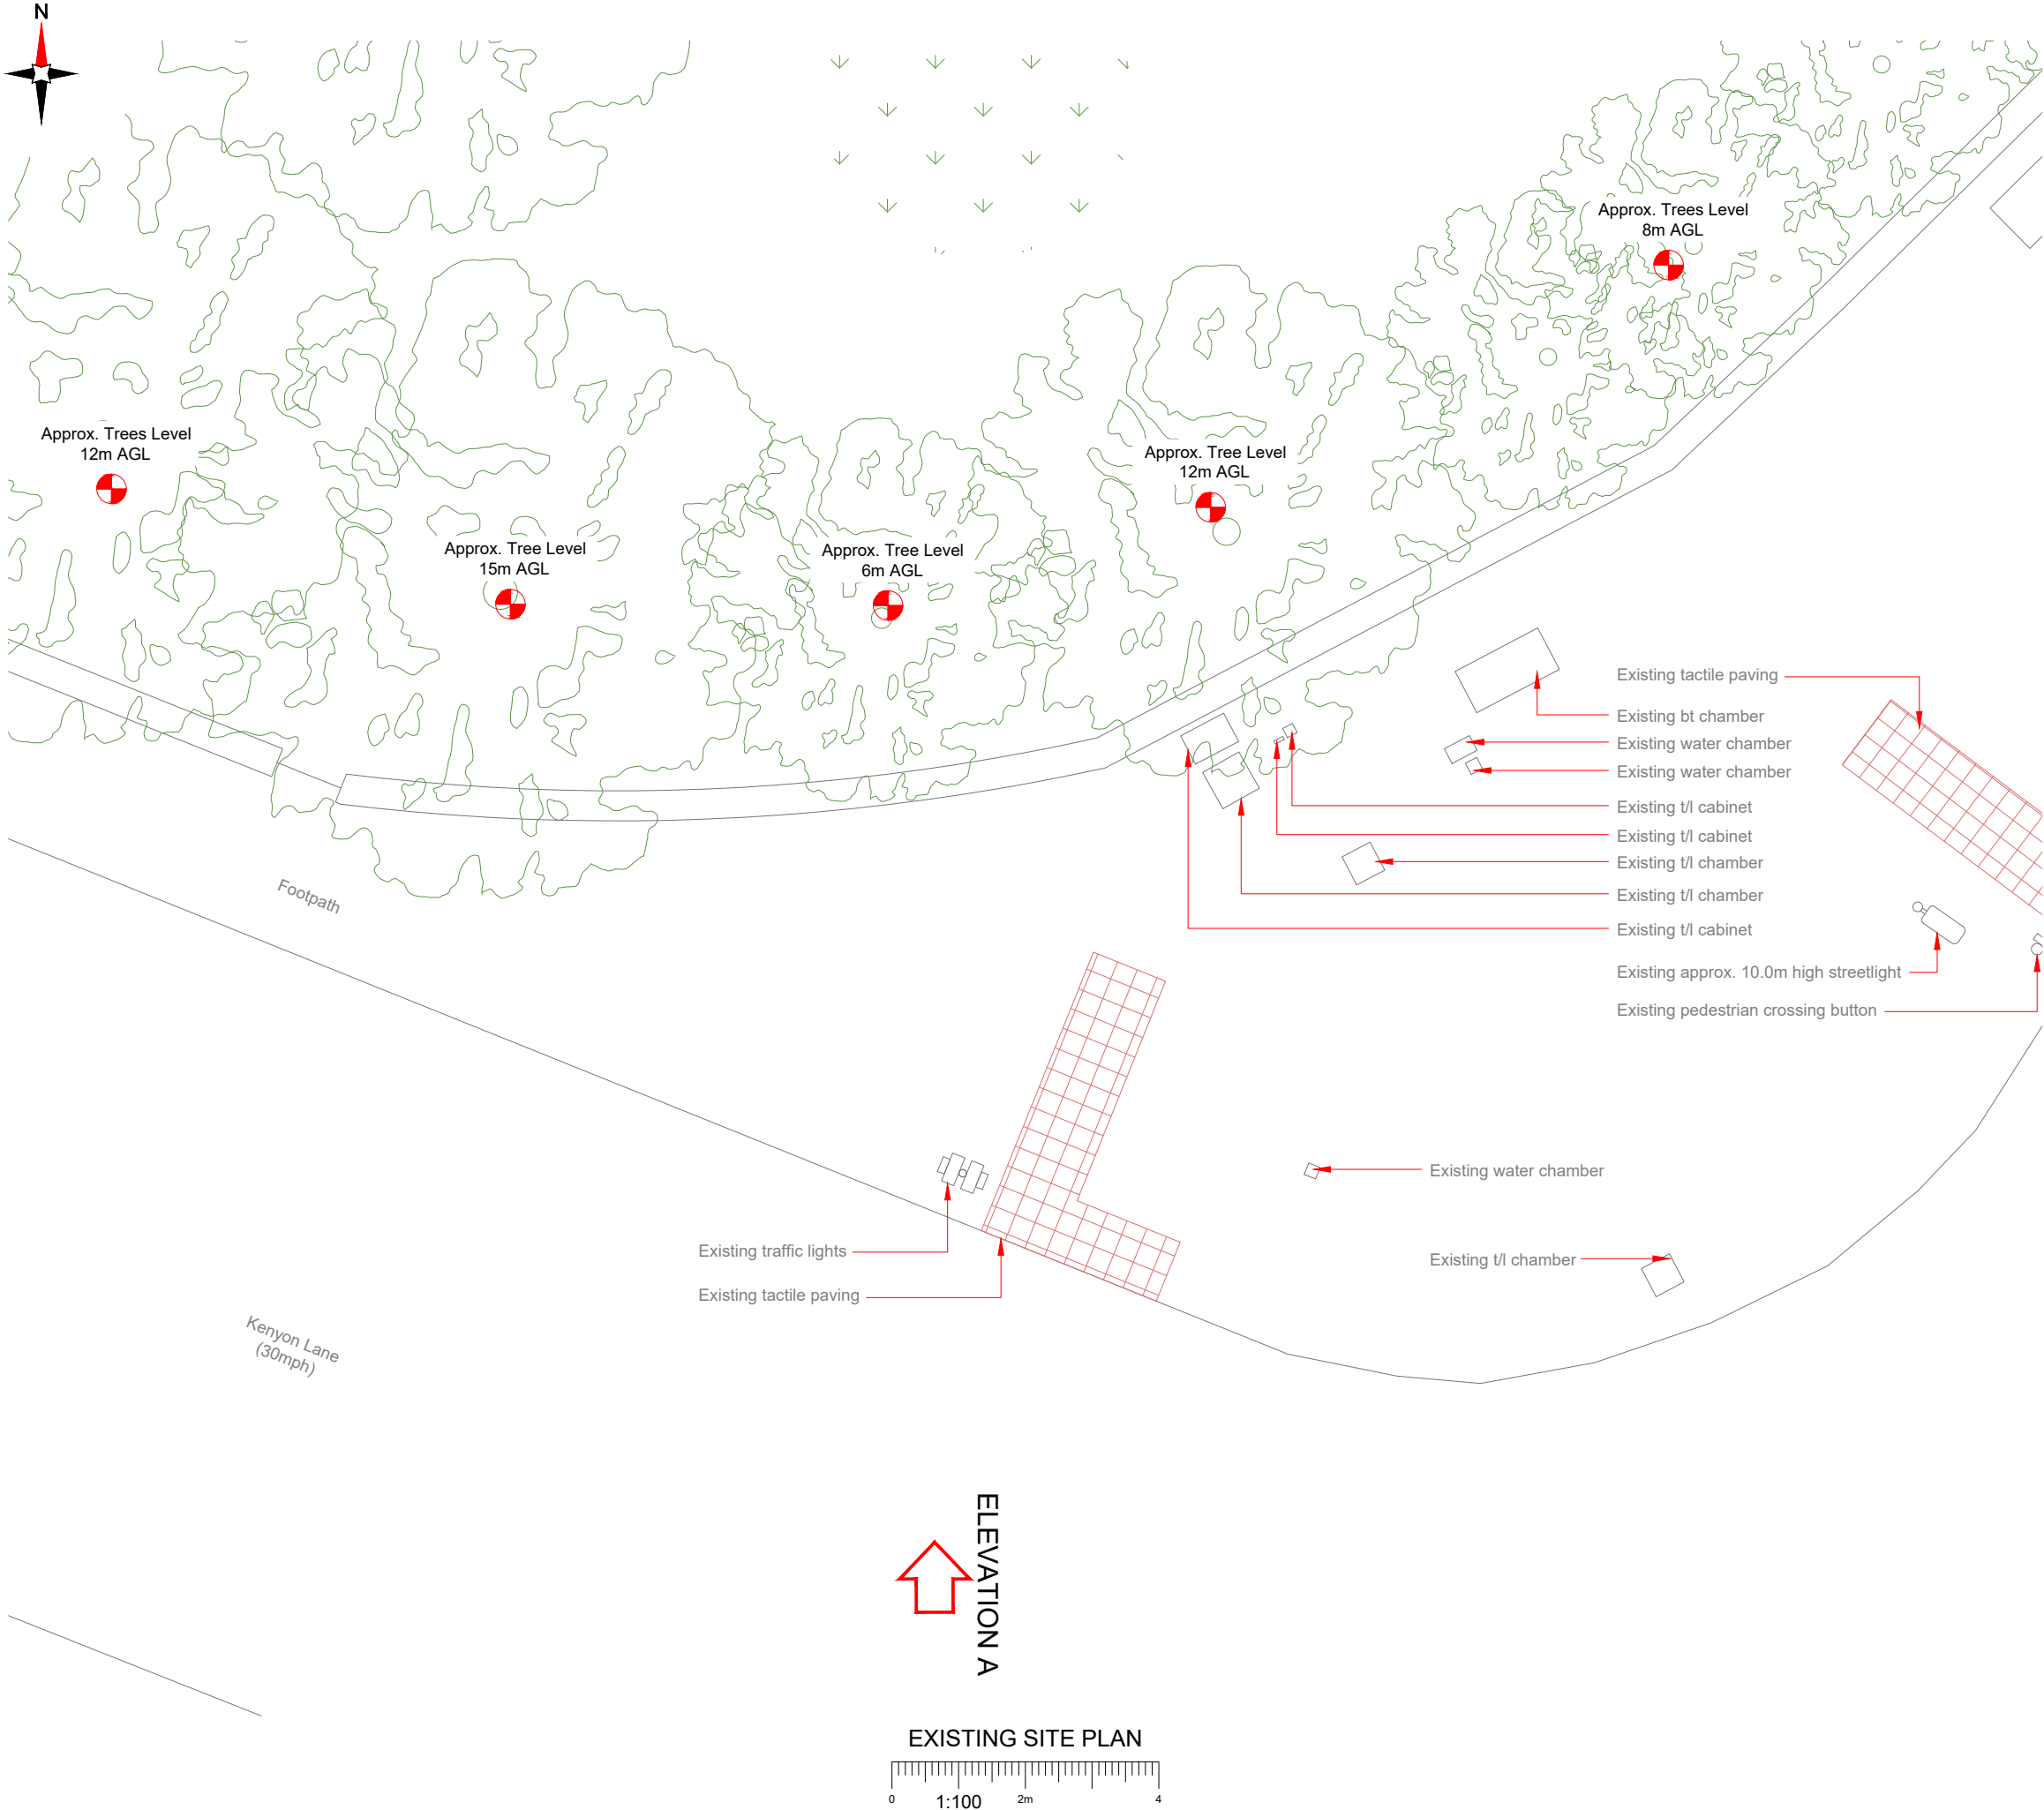

- NOTES:
- ALL DIMENSIONS IN MM UNLESS OTHERWISE NOTED.

Master:	MBNL / EE:	Project:	Purpose of Issue:	Issue:
M001	MBNL	3UK DNSW	Planning	A
Date:	03/08/2022	Revision / Upgrade Description:		
Drawn:	CDN	First Issue - Site nomination dated: TBC		
Checked:	DH			
Approved:	SD			

CK Hutchison
Networks (UK)
Limited

Great Brighams Mead,
Vastern Road, Reading,
Berkshire, England,
RG1 8DJ

Design Consultant & Principal Contractor:



WHP Telecoms

Unit 1 Maple Park,
Low Fields Avenue, Leeds
LS12 6HH

Tel: 01133023550
e-mail: info@whptelecoms.com

Site Name:
KENYON LANE STREETWORKS

Site ID:
MAN23646

Address:
KENYON LANE, MOSTON,
MANCHESTER,
GREATER MANCHESTER,
ENGLAND,
M40 9DF

Title:
100 EXISTING SITE PLAN

Project:
3UK DNSW

Purpose of Issue:
PLANNING

EE Cell ID: 87384	MBNL Cell ID: MAN615	Cell ID: M1458
----------------------	-------------------------	-------------------

Master Drawing No: MAN23646_M001	Issue: A
-------------------------------------	-------------

 
100mm

50mm

10mm



EXISTING ELEVATION A



- NOTES:
1. ALL DIMENSIONS IN MM UNLESS OTHERWISE NOTED.

Master:	MBNL / EE:	Project:	Purpose of Issue:	Issue:
M001	MBNL	3UK DNSW	Planning	A
Date:	03/08/2022	Revision / Upgrade Description:		
Drawn:	CDN	First Issue - Site nomination dated: TBC		
Checked:	DH			
Approved:	SD			

**CK Hutchison
Networks (UK)
Limited**

Great Brighams Mead,
Vastern Road, Reading,
Berkshire, England,
RG1 8DJ

Design Consultant & Principal Contractor:



WHP Telecoms

Unit 1 Maple Park,
Low Fields Avenue, Leeds
LS12 6HH

Tel: 01133023550
e-mail: info@whptelecoms.com

Site Name:
KENYON LANE STREETWORKS

Site ID:
MAN23646

Address:
**KENYON LANE, MOSTON,
MANCHESTER,
GREATER MANCHESTER,
ENGLAND,
M40 9DF**


Title:
150 EXISTING ELEVATION A

Project:
3UK DNSW

Purpose of Issue:
PLANNING

EE Cell ID: 87384	MBNL Cell ID: MAN615	Cell ID: M1458
-----------------------------	--------------------------------	--------------------------

Master Drawing No: MAN23646_M001	Issue: A
--	--------------------

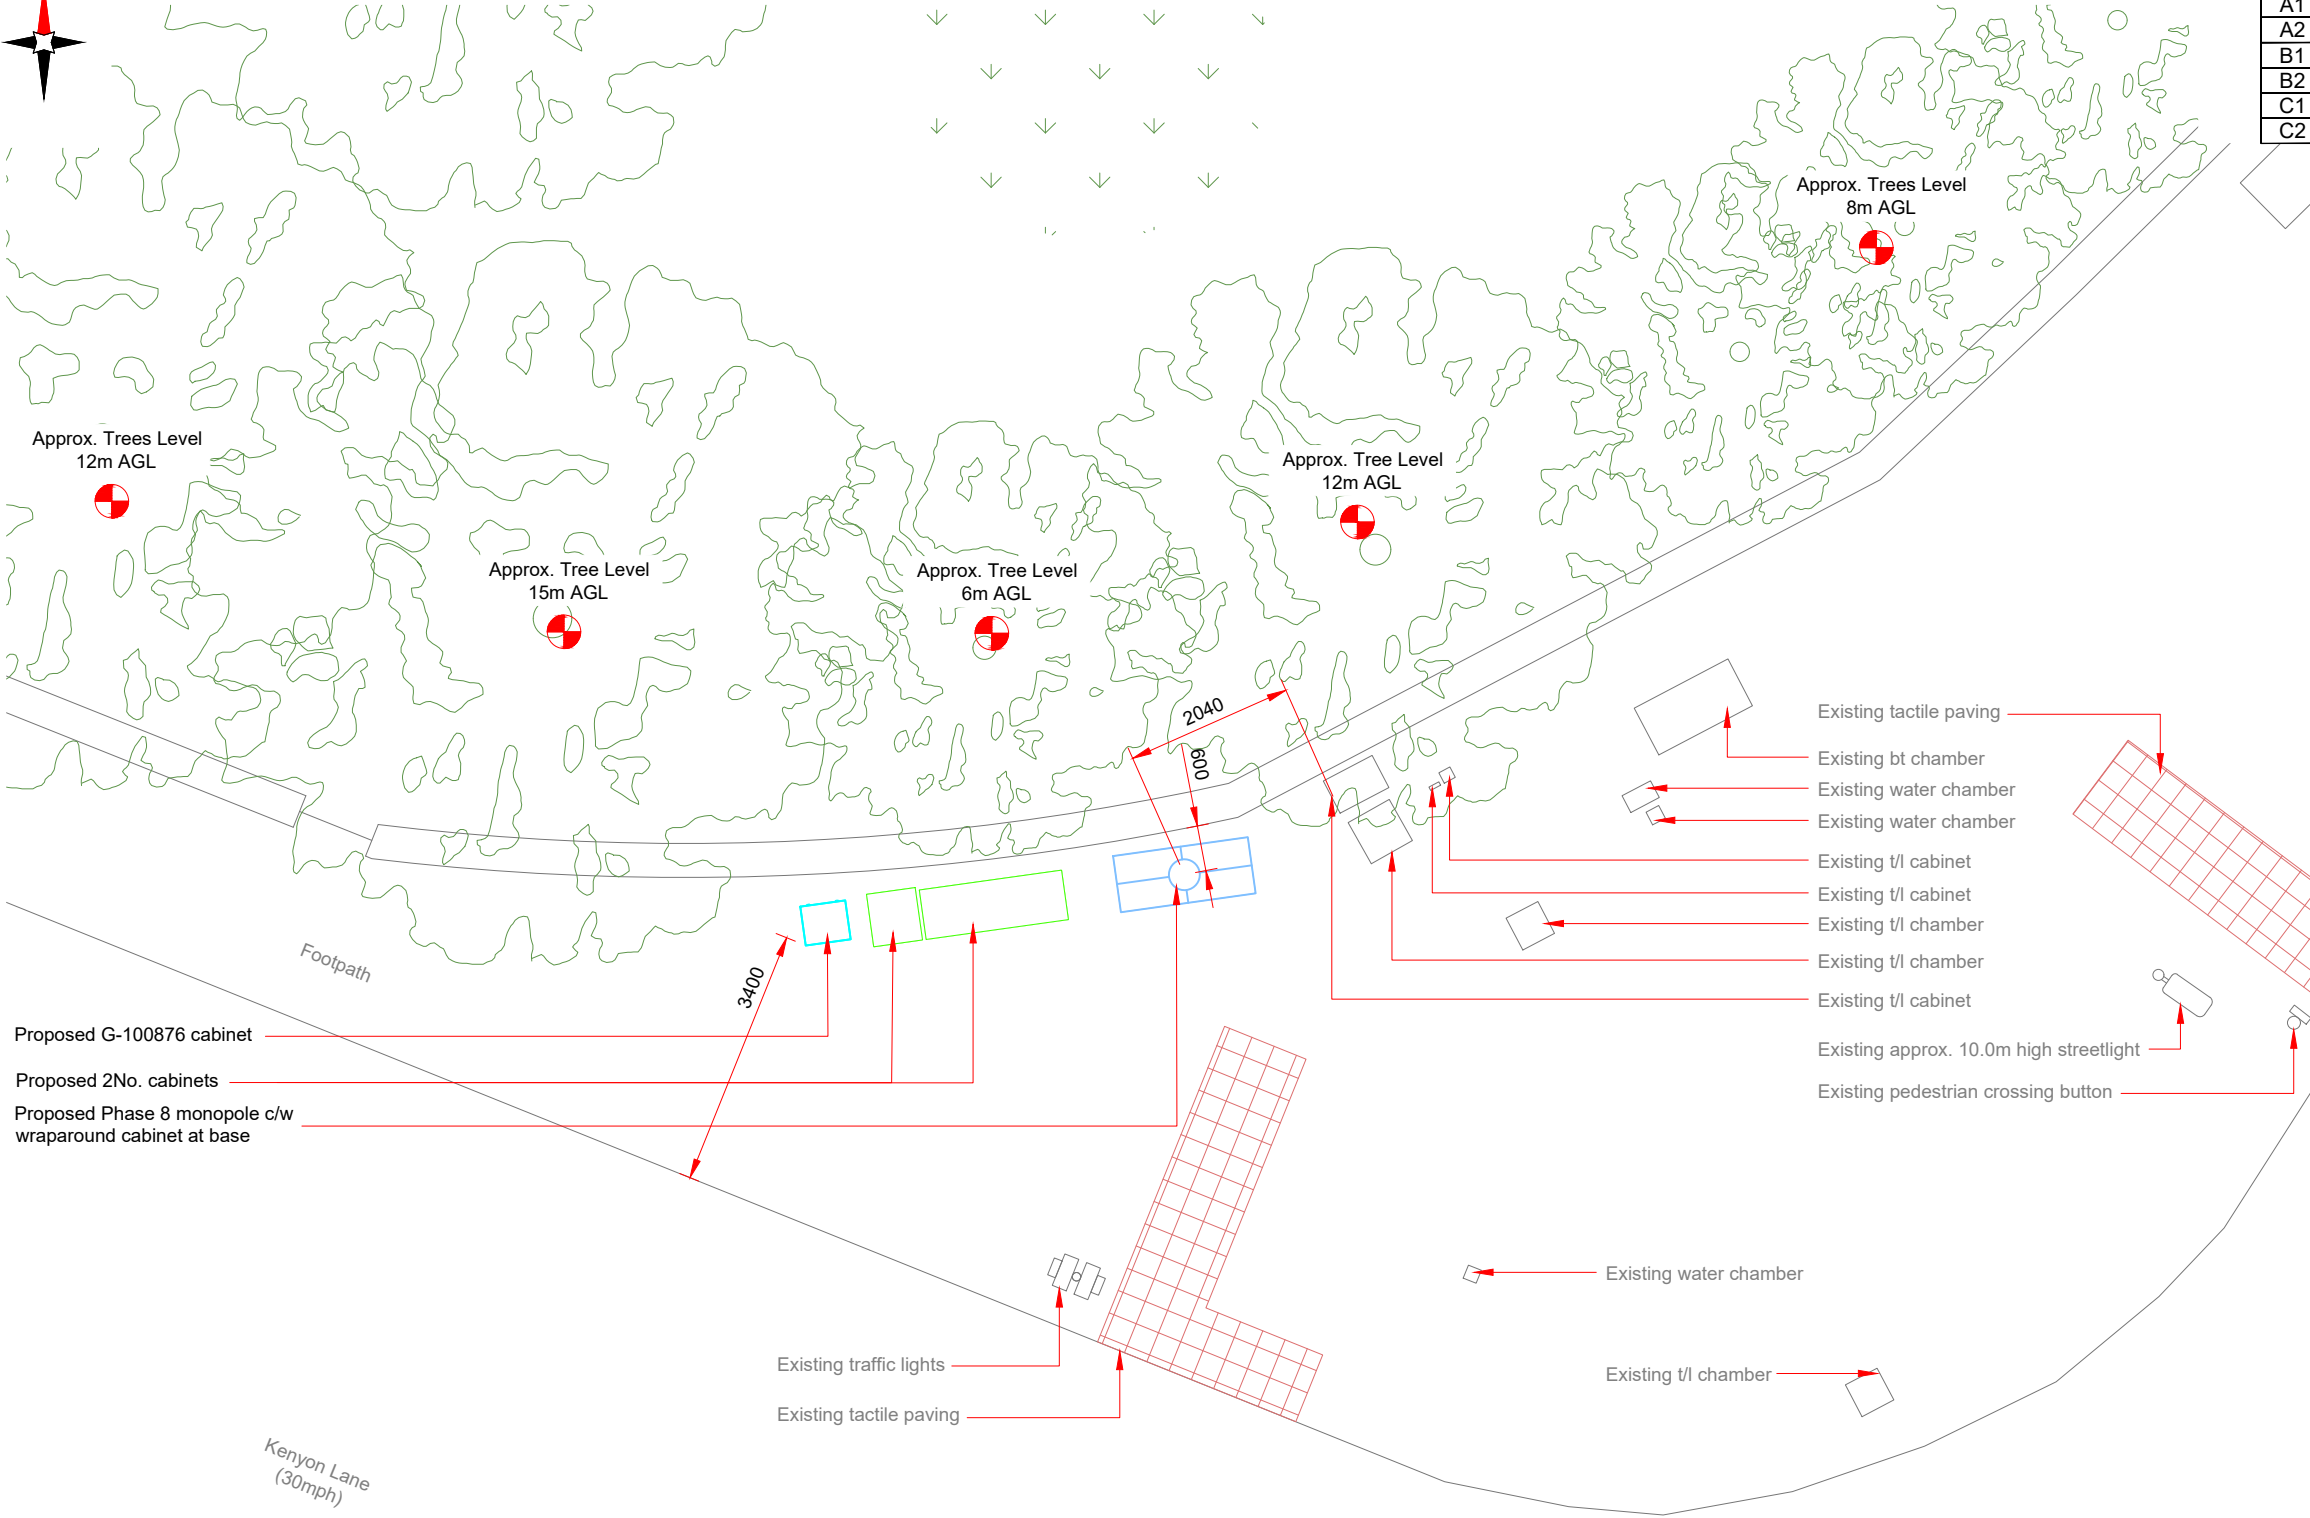

Antenna Aperture ID	Proposed 4G/5G Bearing
A1	0°
A2	0°
B1	120°
B2	120°
C1	240°
C2	240°

NOTES:

1. ALL DIMENSIONS IN MM UNLESS OTHERWISE NOTED.

Master:	MBNL / EE:	Project:	Purpose of Issue:	Issue:
M001	MBNL	3UK DNSW	Planning	A
Date:	03/08/2022	Revision / Upgrade Description:		
Drawn:	CDN	First Issue - Site nomination dated: TBC		
Checked:	DH			
Approved:	SD			

CK Hutchison Networks (UK) Limited

Great Brighams Mead,
Vastern Road, Reading,
Berkshire, England,
RG1 8DJ

Design Consultant & Principal Contractor:



WHP Telecoms
Unit 1 Maple Park,
Low Fields Avenue, Leeds
LS12 6HH

Tel: 01133023550
e-mail: info@whptelecoms.com

Site Name:
KENYON LANE STREETWORKS

Site ID:
MAN23646

Address:
**KENYON LANE, MOSTON,
MANCHESTER,
GREATER MANCHESTER,
ENGLAND,
M40 9DF**

Title:
210 PROPOSED SITE PLAN

Project:
3UK DNSW

Purpose of Issue:
PLANNING


EE Cell ID: 87384	MBNL Cell ID: MAN615	Cell ID: M1458
-----------------------------	--------------------------------	--------------------------

Master Drawing No: MAN23646_M001	Issue: A
--	--------------------

Antenna Aperture ID	Proposed 4G/5G Bearing
A1	0°
A2	0°
B1	120°
B2	120°
C1	240°
C2	240°

NOTES:

1. ALL DIMENSIONS IN MM UNLESS OTHERWISE NOTED.

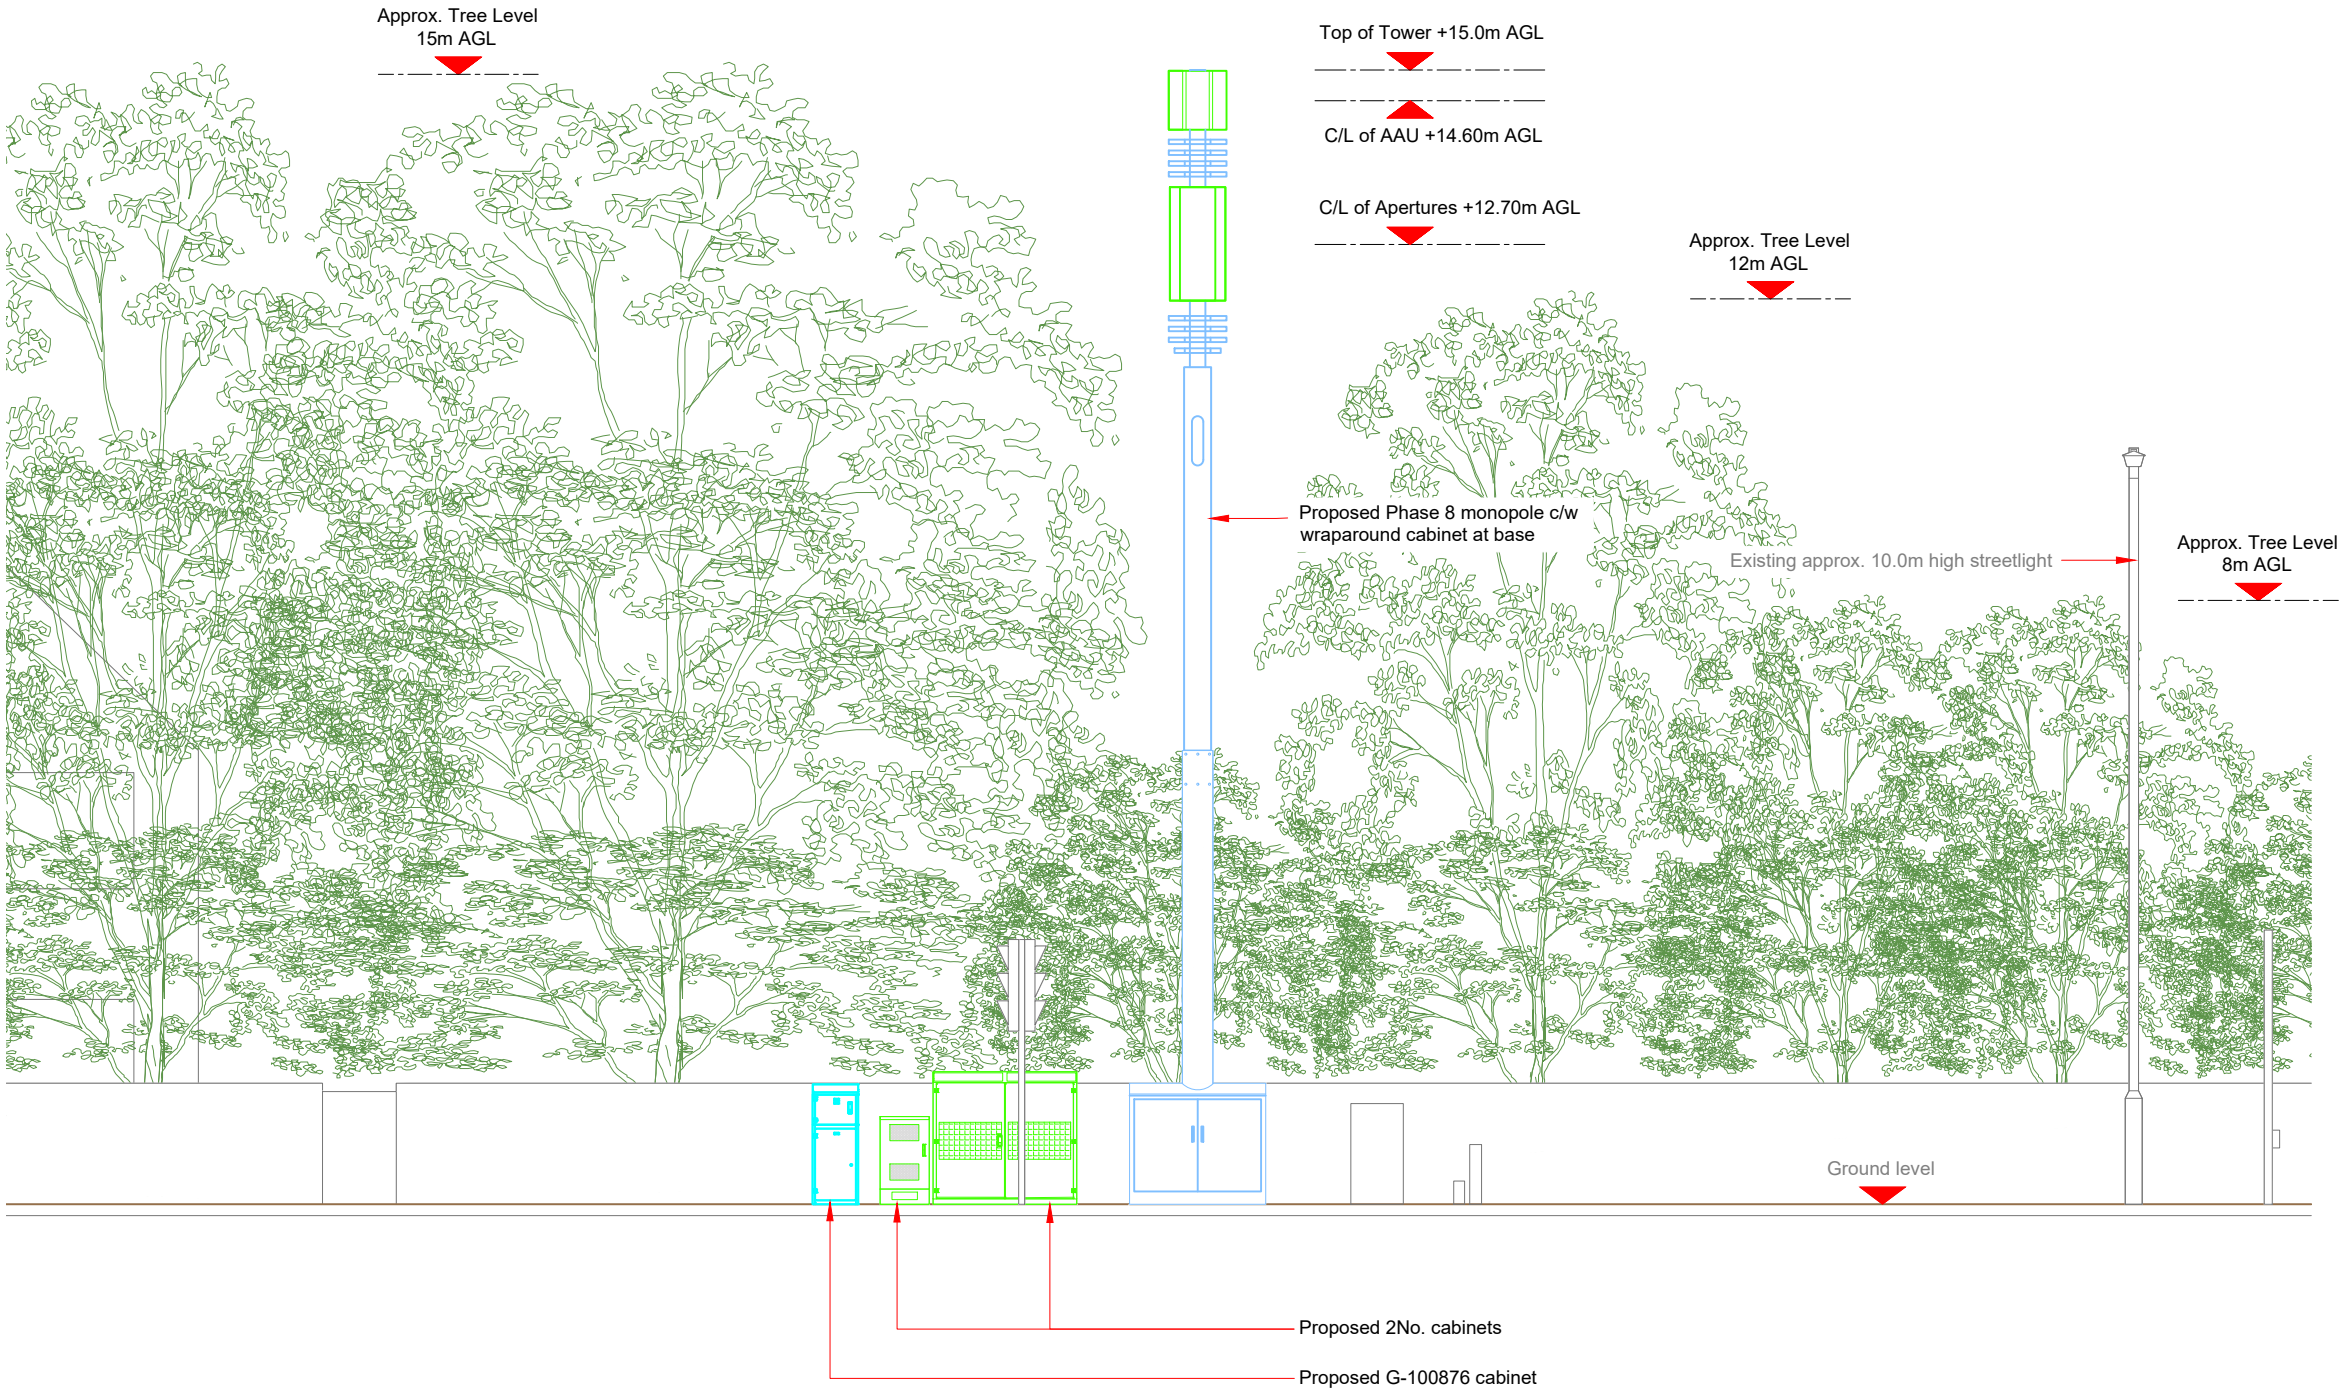

Master:	MBNL / EE:	Project:	Purpose of Issue:	Issue:
M001	MBNL	3UK DNSW	Planning	A
Date:	03/08/2022	Revision / Upgrade Description:		
Drawn:	CDN	First Issue - Site nomination dated: TBC		
Checked:	DH			
Approved:	SD			

**CK Hutchison
Networks (UK)
Limited**

Great Brighams Mead,
Vastern Road, Reading,
Berkshire, England,
RG1 8DJ

Design Consultant & Principal Contractor:



WHP Telecoms
Unit 1 Maple Park,
Low Fields Avenue, Leeds
LS12 6HH

Tel: 01133023550
e-mail: info@whptelecoms.com

Site Name:
KENYON LANE STREETWORKS

Site ID:
MAN23646

Address:
**KENYON LANE, MOSTON,
MANCHESTER,
GREATER MANCHESTER,
ENGLAND,
M40 9DF**

Title:
260 PROPOSED ELEVATION

Project:
3UK DNSW

Purpose of Issue:
PLANNING

EE Cell ID: 87384	MBNL Cell ID: MAN615	Cell ID: M1458
-----------------------------	--------------------------------	--------------------------

Master Drawing No: MAN23646_M001	Issue: A
--	--------------------