


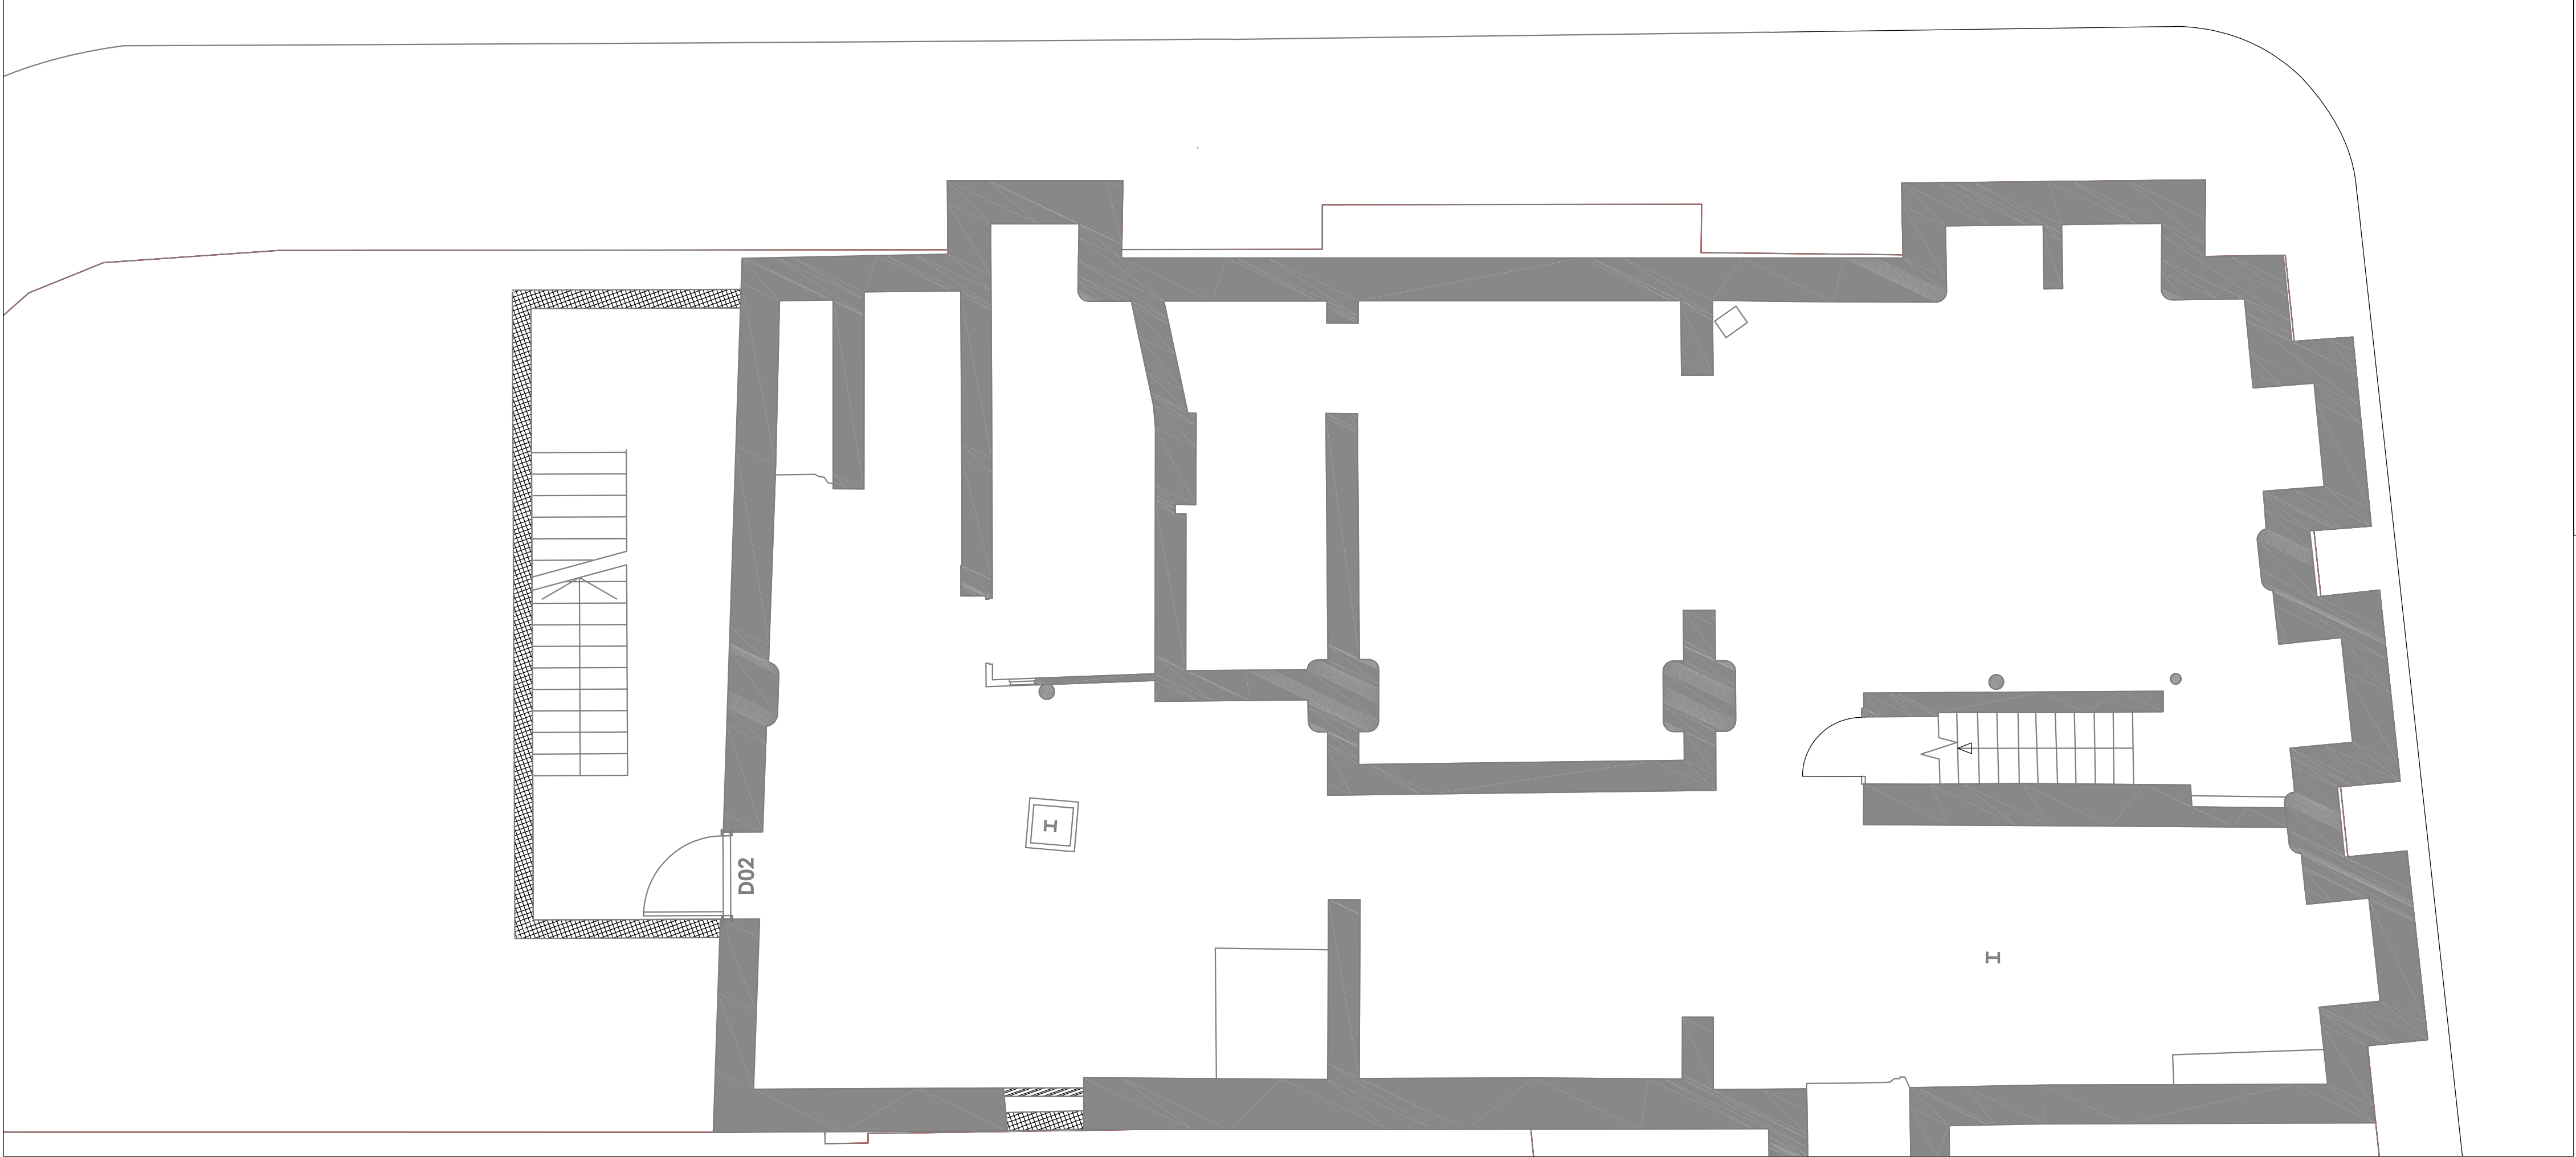


BASEMENT

LEGEND:

- EMERGENCY GREEN BREAK GLASS DOOR RELEASE
- DOOR CONTROLLER (BATTERY BACKED)
- DOOR MAGLOCK
- ACCESS CONTROL PROXIMITY CARD READER
- EMERGENCY PULL CORD
- TOILET ALARM RESET BUTTON
- OVER DOOR ALARM WITH SOUNDER
- FIXED CCTV CAMERA POE TYPE (PAN, TILT, ZOOM)

- Notes :**
- THIS DRAWING SHALL BE READ IN CONJUNCTION WITH ALL OTHER PROJECT DOCUMENTATION.
 - ALL ELECTRICAL INSTALLATION WORKS INSTALLED IN ACCORDANCE WITH BS7671 INCORPORATING ALL CURRENT AMENDMENTS.
 - THIS LAYOUT IS A TECHNICAL DESIGN TO STAGE 4 (4A) FEASIBLE GENERIC DESIGN. THE CONTRACTOR SHALL DEVELOP THE DESIGN THROUGH STAGE 4 (4B & 4C) THE PRODUCTION OF COORDINATED WORKING DRAWINGS AND STAGE 5 INSTALLATION AND AS FITTED DRAWINGS INCLUDING DETAILED DESIGN SIZES FOR FINALLY PROCURED EQUIPMENT SELECTIONS, SECONDARY CONTAINMENT, CDP ELEMENTS etc.
 - ALL FINAL COORDINATION OF SERVICES SHOWN ON THIS DRAWING INCLUDING SUPPORT BRACKETS & SUPPLEMENTARY STEELWORK SHALL BE DESIGNED AND INSTALLED BY THE CONTRACTOR.
 - FOR PLANT AND EQUIPMENT DETAILS REFER TO SCOPE OF WORKS AND SCHEDULES.
 - THE ELECTRICAL INSTALLATION SHALL BE UNDERTAKEN IN ACCORDANCE WITH HTM 06-01, BS 7671:2018, GUIDANCE NOTE 7 AND CURRENT SITE WIDE STANDARDS.
 - ALL ELECTRICAL EQUIPMENT SHALL BE SUPPLIED AND INSTALLED TO MATCH EXISTING SITE WIDE STANDARDS.
 - THE CONTRACTOR SHALL PROVIDE ALL NEW 230V SUPPLIES TO THE DOORS FOR ACCESS CONTROL OR AUTO POWER OPENED VIA FUSED CONNECTION UNIT WITHIN THE CEILING VOID ADJACENT TO THE DOOR CONTROLLER.
 - THE CONTRACTOR MUST OBTAIN THE FULL OPERATIONAL REQUIREMENTS FROM THE SPECIALIST PRIOR TO INSTALLATION.

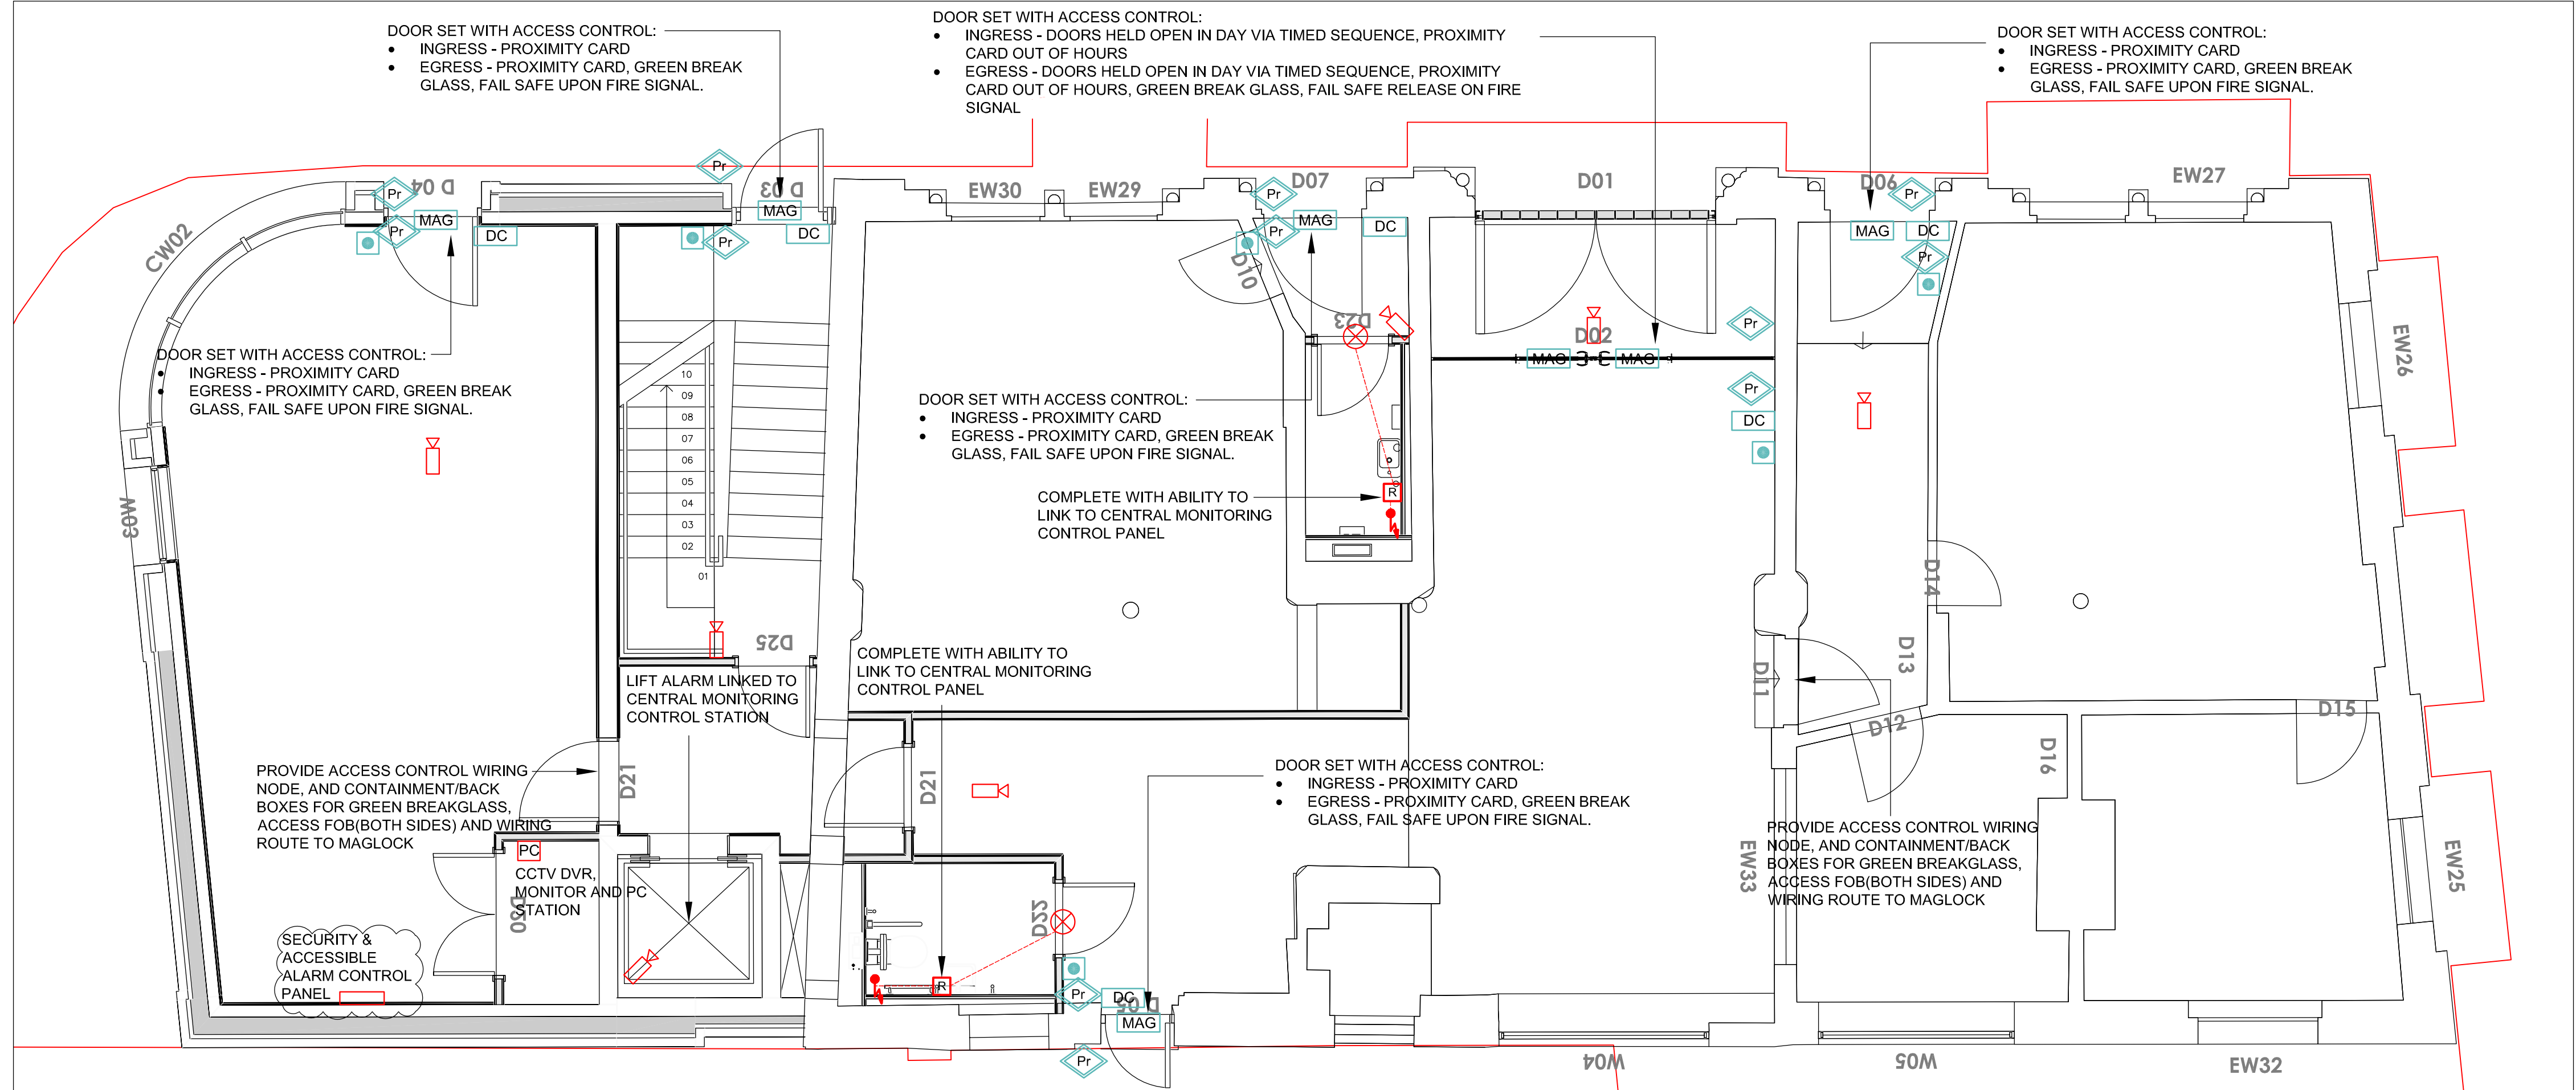

GROUND FLOOR

T4	17/08/22	TENDER ISSUE	JL	RW	RW
T3	05/08/22	TENDER ISSUE	JL	RW	RW
T2	28/07/22	TENDER ISSUE	JL	RW	RW
T1	04/07/22	TENDER ISSUE	JL	RW	RW
Rev	Date	Description	By	Check	App.

COPYRIGHT: THE COPYRIGHT OF THIS DRAWING IS VESTED IN CLANCY CONSULTING. IT SHALL NOT BE USED WITHOUT PERMISSION BY ANYONE FOR ANY PURPOSE. DO NOT SCALE THIS DRAWING ELECTRONICALLY OR MANUALLY. WORK TO FIGURED DIMENSIONS ONLY. ALL DIMENSIONS ARE IN MILLIMETRES UNLESS STATED OTHERWISE. DO NOT TURN ON LAYERS THAT HAVE BEEN TURNED OFF. DO NOT TWEAK LAYERS THAT HAVE BEEN FROZEN. DRAWING MUST BE PRINTED IN BLACK AND WHITE ONLY.

Client	McCauls
Project	Laystall Street Office Refurbishment
Office	Altrincham
Discipline	Electrical
Title	Basement and Ground Floor Security Layout
Scale @ A1	1:50
Status	Tender



www.clancy.co.uk

Project No.	Originator	Building/Zone	Level
7/9936	CCL	XX	B,00
Type	Discipline	Drawing No.	Revision
DR	E	6801	T3