
 


SITE LOCATION

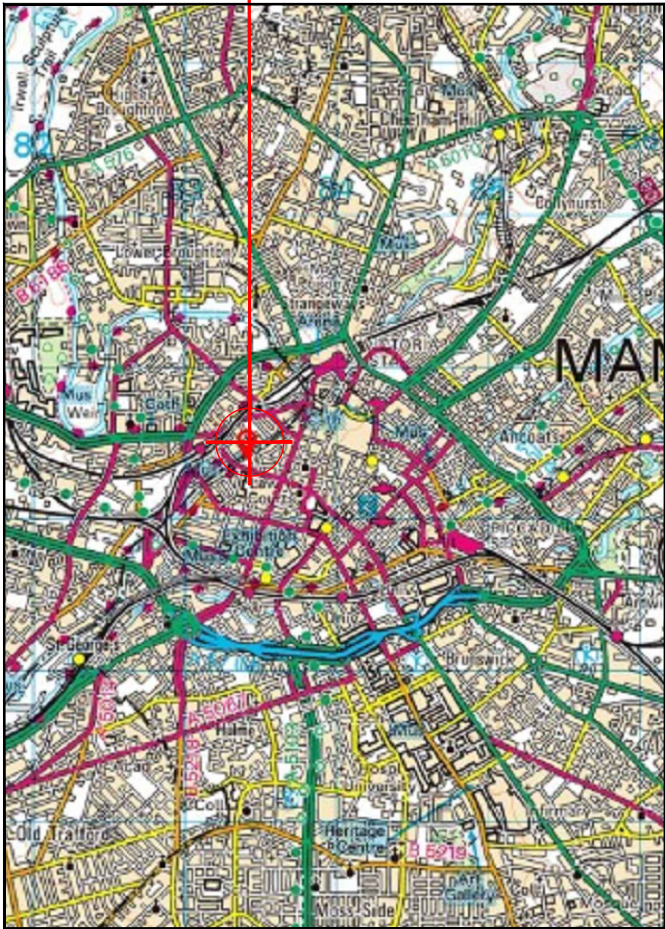

Reproduced by permission of Ordnance Survey on behalf of the Controller of Her Majesty's Stationery Office
All rights reserved. © Crown Copyright licence no. 100022432

SITE AREA PLAN



 
SITE PHOTOGRAPH



Reproduced by permission of Ordnance Survey on behalf
of the Controller of Her Majesty's Stationery Office
All rights reserved. © Crown Copyright licence no. 100022432

NGR E: 383408 N: 398340

SITE LOCATION PLAN



GOOGLE MAPS QR CODE

GOOGLE MAPS - <https://goo.gl/maps/m3SMhJBhA9cRZspZ7>

GOOGLE STREETVIEW - <https://goo.gl/maps/J7km2PD5UDpfYQr7A>

NOTES:

1. ALL DIMENSIONS IN MM UNLESS OTHERWISE NOTED.

DIRECTIONS TO SITE:

Head South-East on M60 , At junction 19 use the left 2 lanes to take the A576 exit to M'or City centre/Middleton.At the Rhodes interchange take the third exit onto Middleton Road/A576 and continue for 2.6miles towards Old Hall lane . Turn right onto Cheetham Street /A576 . After 0.4miles turn left onto Great Clowes Street/A5066.Continue straight onto Blackfriars Road/A6041.Turn right onto Mount Street and then turn Left onto Stephen Street.After 0.4 miles turn left onto Chapel Street and then turn right onto New Bailey Street , site will be on left hand side after 0.2miles.

Access Route To Site:



Master:	MBNL / EE / H3G:	Project:	Purpose of Issue:	Issue:
M001	H3G	DENSIFICATION SW	Planning	A
Date:	09/08/2022	Revision / Upgrade Description:		
Drawn:	S.Booth	First Issue - Site nomination dated: TBC		
Checked:	G.Thomas			
Approved:	G.Thomas			



Hutchison 3G UK Limited
Green Park, 450 Longwater Avenue
Reading, RG30 3UR
Tel: 01628 765 000
Fax: 01628 765 001


H3G Base Station Information line:
0845 6043000
Available 8am-8pm Monday to Friday

Design Consultant & Principal Contractor:



Unit E, Madison Place, Northampton Road,
Manchester, M40 5AG
Tel: 0161 785 4500 Fax: 0161 785 4501
Web: www.clarke-telecom.com

Site Name:	BRIDGE STREET		
Site ID:	MAN24538		
Address:	BRIDGE STREET ST JOHN'S MANCHESTER M3 5AH		
Title:	002 SITE LOCATION PLAN		
Project:	H3G DENSIFICATION STREETWORKS		
Purpose of Issue:	PLANNING		
EE Cell ID:	MBNL Cell ID:	3UK Cell ID:	
-	-	MAN24538	
Master Drawing No:			Issue:
MAN24583_B35_GA_A			A

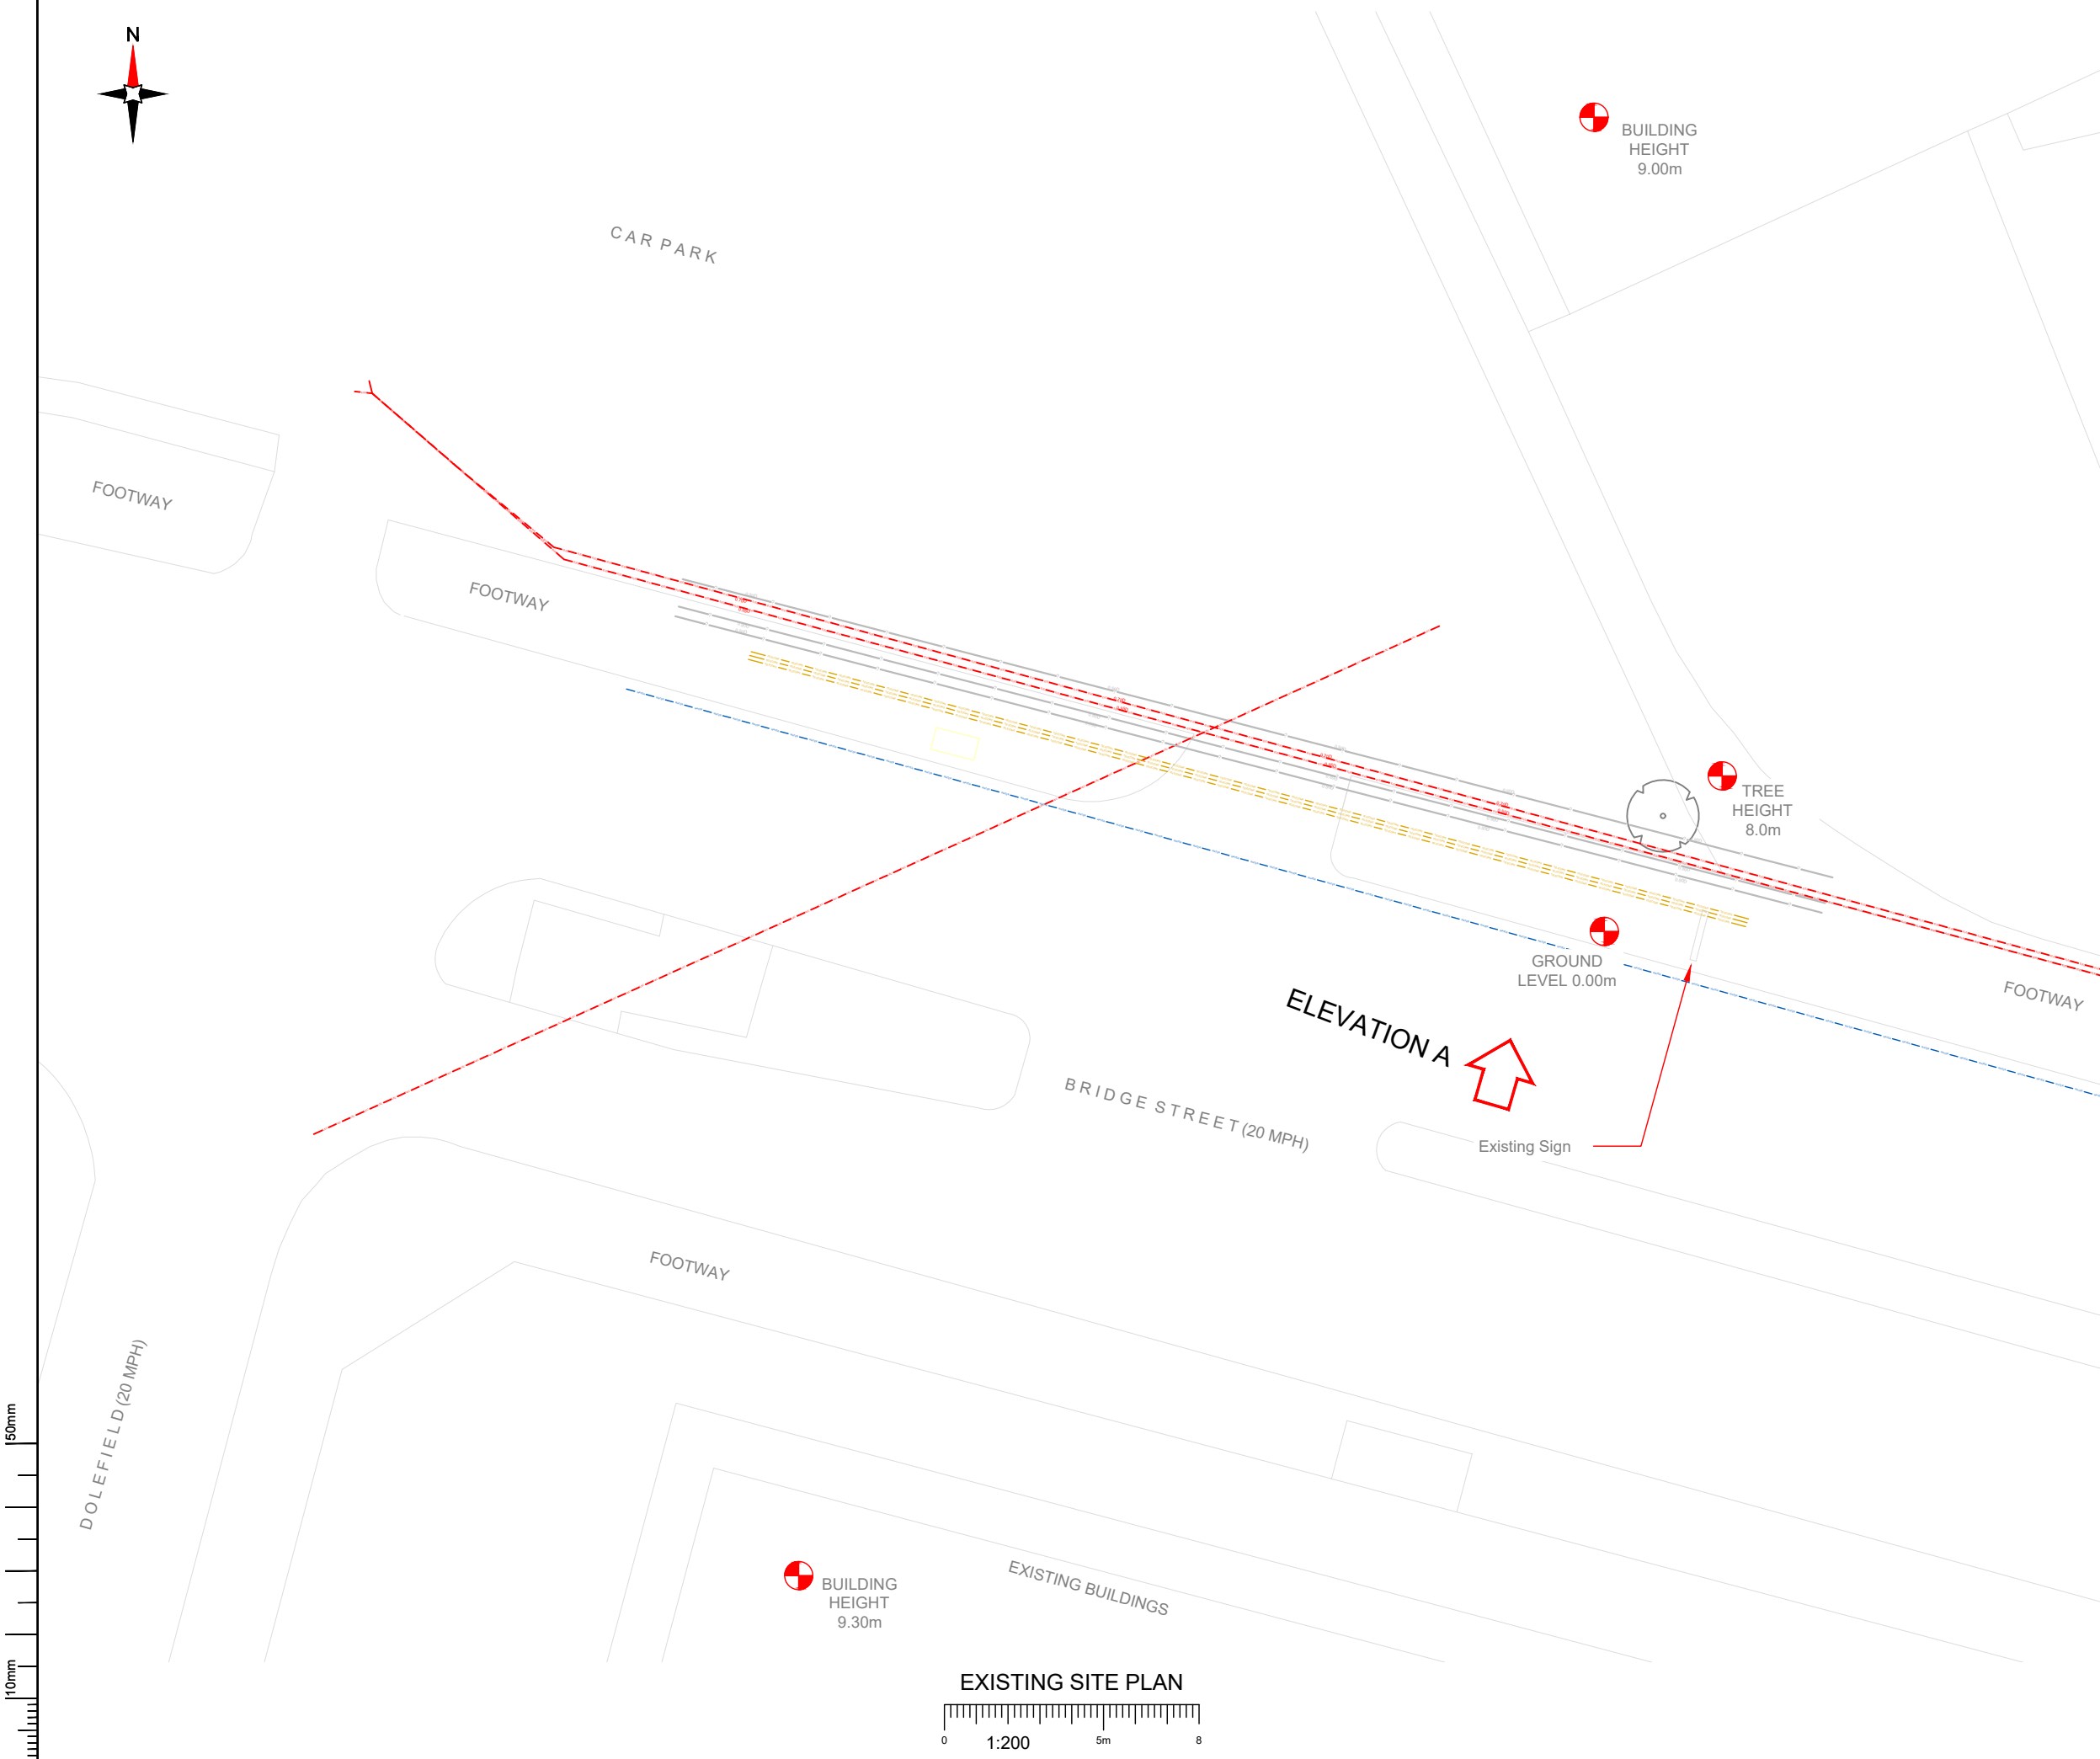

EXISTING SITE PLAN



NOTES:

1. ALL DIMENSIONS IN MM UNLESS OTHERWISE NOTED.

SERVICES:

— WATER — WATER — WATER —

— HV — HV — HV — HV —

— GAS — GAS — GAS —

— TELECOMS — TELECOMS —

— ? — ? —

— ELEC — ELEC — ELEC — ELEC —

NOTES:
Radar Scan and Stats to be reviewed prior to any build works commencing.

Master:	MBNL / EE / H3G:	Project:	Purpose of Issue:	Issue:
M001	H3G	DENSIFICATION SW	Planning	A
Date:	09/08/2022	Revision / Upgrade Description:		
Drawn:	S.Booth	First Issue - Site nomination dated: TBC		
Checked:	G.Thomas			
Approved:	G.Thomas			



Hutchison 3G UK Limited
Green Park, 450 Longwater Avenue
Reading, RG30 3UR
Tel: 01628 765 000
Fax: 01628 765 001

H3G Base Station Information line:
0845 6043000
Available 8am-8pm Monday to Friday

Design Consultant & Principal Contractor:

CLARKE telecom


Unit E, Madison Place, Northampton Road,
Manchester, M40 5AG
Tel: 0161 785 4500 Fax: 0161 785 4501
Web: www.clarke-telecom.com

Site Name:	BRIDGE STREET		
Site ID:	MAN24538		
Address:	BRIDGE STREET ST JOHN'S MANCHESTER M3 5AH		
Title:	100 EXISTING H3G SITE PLAN		
Project:	H3G DENSIFICATION STREETWORKS		
Purpose of Issue:	PLANNING		
EE Cell ID:	-	MBNL Cell ID:	-
		3UK Cell ID:	MAN24538
Master Drawing No:	MAN24583_B35_GA_A		Issue:
			A

100mm

50mm

10mm

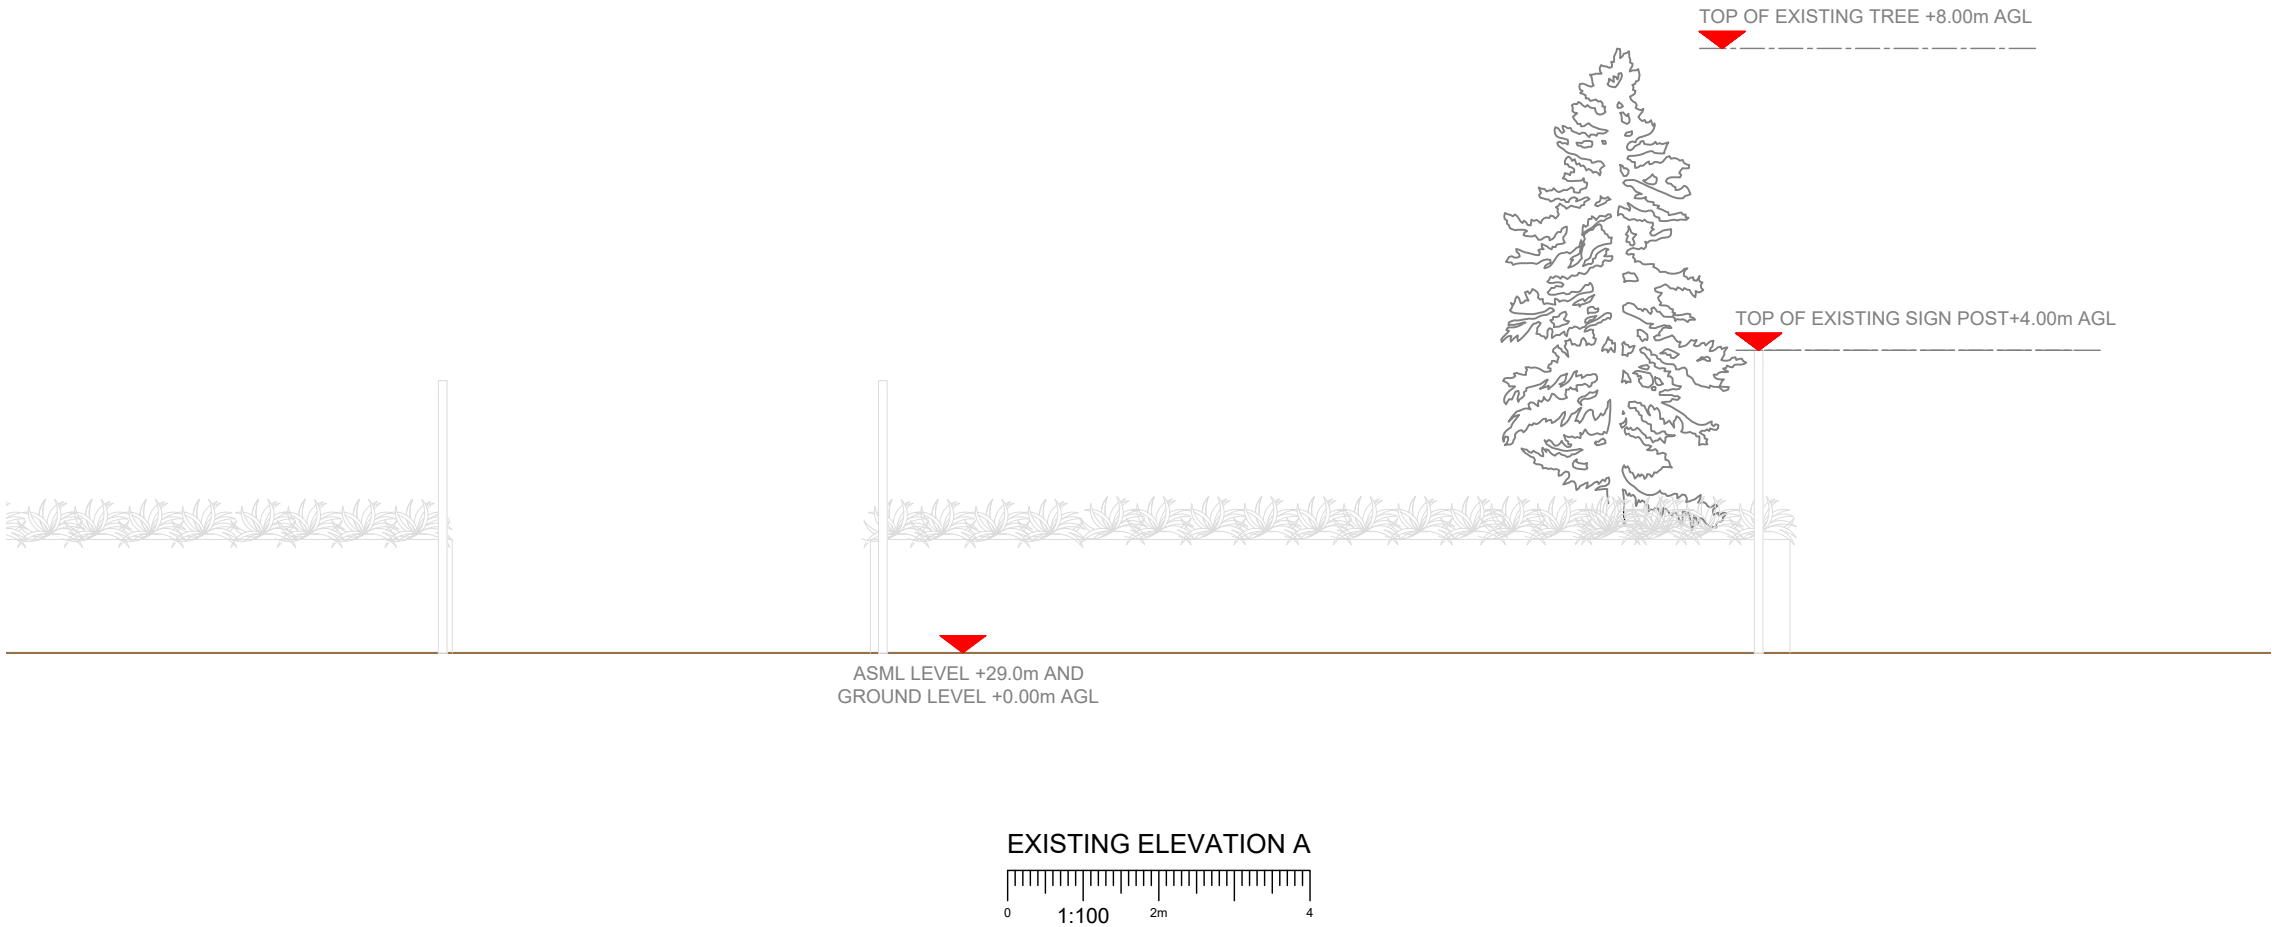

NOTES:

1. ALL DIMENSIONS IN MM UNLESS OTHERWISE NOTED.

Master:	MBNL / EE / H3G:	Project:	Purpose of Issue:	Issue:
M001	H3G	DENSIFICATION SW	Planning	A
Date:	09/08/2022	Revision / Upgrade Description:		
Drawn:	S.Booth	First Issue - Site nomination dated: TBC		
Checked:	G.Thomas			
Approved:	G.Thomas			



Hutchison 3G UK Limited
Green Park, 450 Longwater Avenue
Reading, RG30 3UR
Tel: 01628 765 000
Fax: 01628 765 001

H3G Base Station Information line:
0845 6043000
Available 8am-8pm Monday to Friday

Design Consultant & Principal Contractor:



Unit E, Madison Place, Northampton Road,
Manchester, M40 5AG
Tel: 0161 785 4500 Fax: 0161 785 4501
Web: www.clarke-telecom.com

Site Name:

BRIDGE STREET

Site ID:

MAN24538

Address:

BRIDGE STREET
ST JOHN'S
MANCHESTER
M3 5AH

Title:

150 EXISTING H3G SITE ELEVATION

Project:


H3G DENSIFICATION STREETWORKS

Purpose of Issue:

PLANNING

EE Cell ID:	MBNL Cell ID:	3UK Cell ID:
-	-	MAN24538

Master Drawing No:	Issue:
MAN24583_B35_GA_A	A

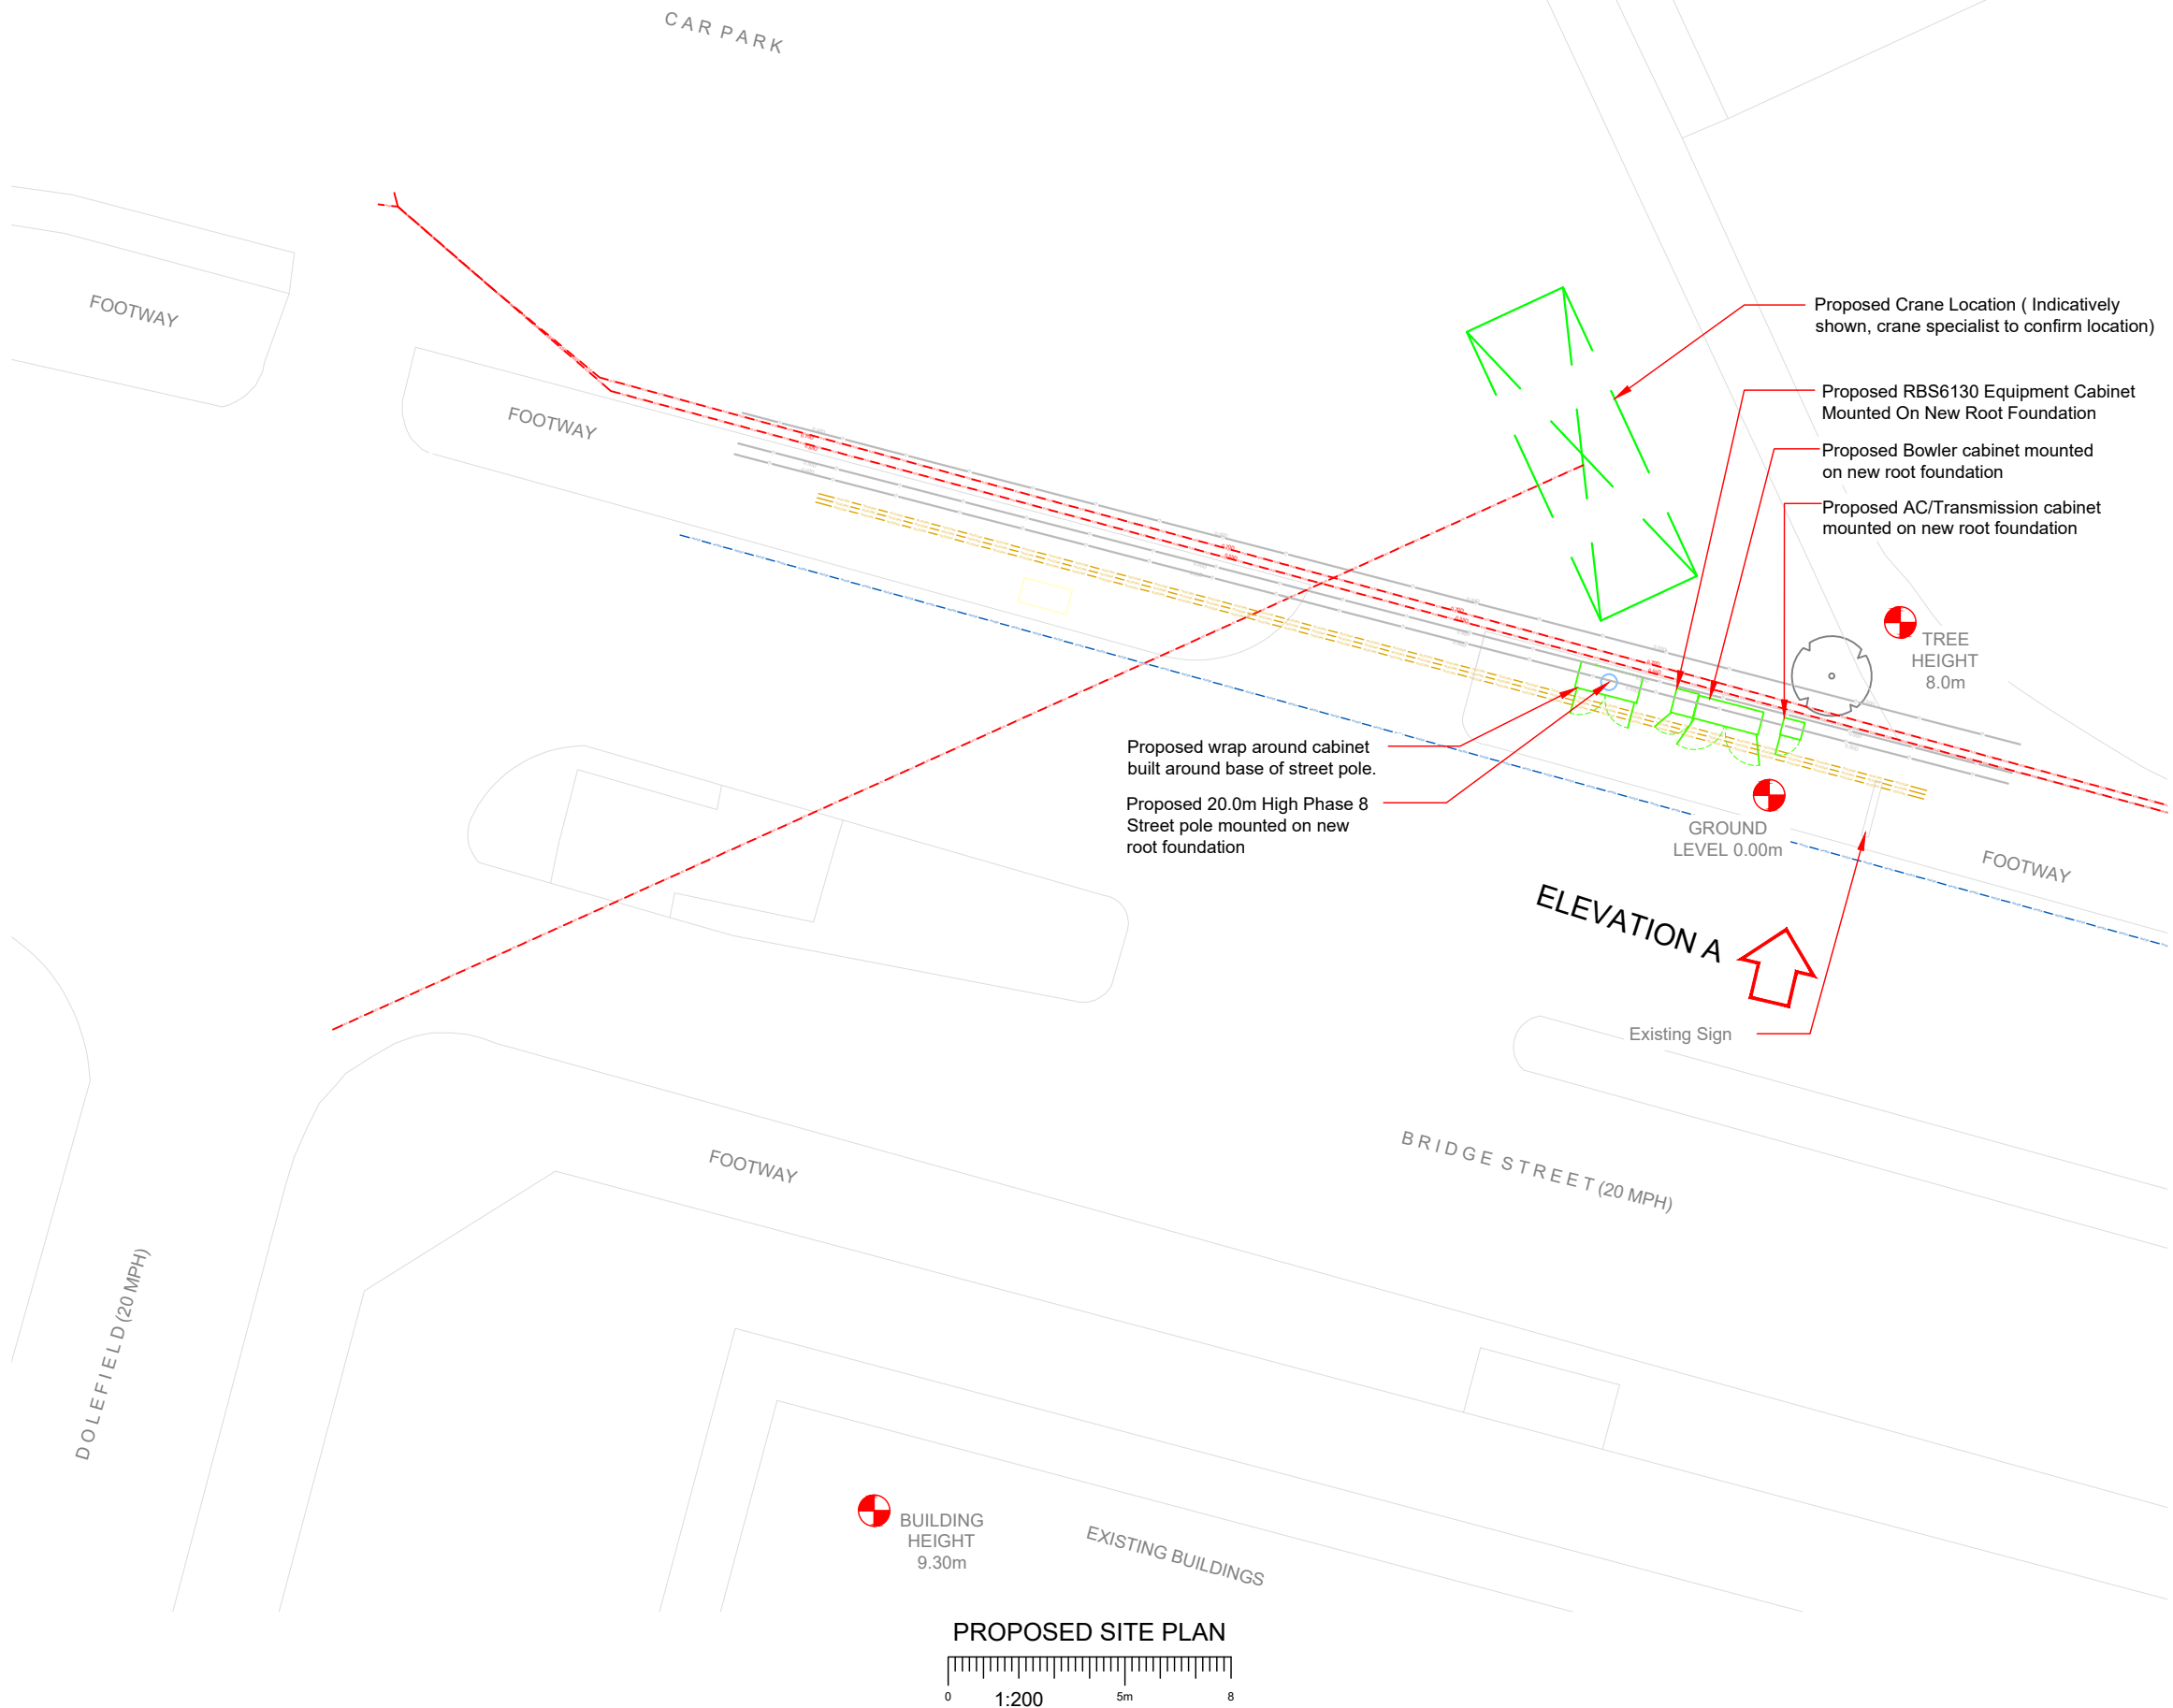

The diagram illustrates the layout of service lines for five different utilities across four columns. Each utility is represented by a distinct color and label:

- Water:** Represented by blue lines. Labels "WATER" are placed above the lines in the first, second, and third columns.
- HV (High Voltage):** Represented by yellow lines. Labels "HV" are placed above the lines in the first, second, and third columns.
- Gas:** Represented by grey lines. Labels "GAS" are placed above the lines in the first, second, and third columns.
- Telecoms:** Represented by orange lines. Labels "TELECOMS" are placed above the lines in the first, second, and third columns.
- ELEC (Electricity):** Represented by red lines. Labels "ELEC" are placed above the lines in the first, second, third, and fourth columns.

Each line is terminated at the ends with a small circle. In the fourth column, the lines for Water, HV, Gas, and Telecoms end with a question mark, while the ELEC line ends with a solid circle.

NOTES:
Radar Scan and Stats to be reviewed prior to any
build works commencing.

Master: MBNL / EE / H3G		Project:	Purpose of Issue:	Issue:
M001	H3G	DENSIFICATION SW	Planning	A
Date: 09/08/2022		Revision / Upgrade Description:		
Drawn: S.Booth		First Issue - Site nomination dated: TBC		
Checked: G.Thomas				
Approved: G.Thomas				



Hutchison 3G UK Limited
 Green Park, 450 Longwater Avenue
 Reading, RG30 3UR
 Tel: 01628 765 000
 Fax: 01628 765 001

H3G Base Station Information line:
 0845 6043000
 Available 8am-8pm Monday to Friday

Design Consultant & Principal Contractor:


Unit E, Madison Place, Northampton Road,
Manchester, M40 5AG
Tel: 0161 785 4500 Fax: 0161 785 4501
Web: www.clarke-telecom.com

Site Name: BRIDGE STREET

Site ID: MAN24538

Address:

BRIDGE STREET
ST JOHN'S
MANCHESTER
M3 5AH

Title: 210 PROPOSED H3G SITE PLAN


Project:	H3G DENSIFICATION STREETWORKS
----------	-------------------------------

Purpose of Issue:	PLANNING
-------------------	----------

EE Cell ID: -	MBNL Cell ID: -	3UK Cell ID: MAN24538
------------------	--------------------	---------------------------------

Master Drawing No:	MAN24583_B35_GA_A	Issue:	A
--------------------	-------------------	--------	---

100mm
50mm
10mm

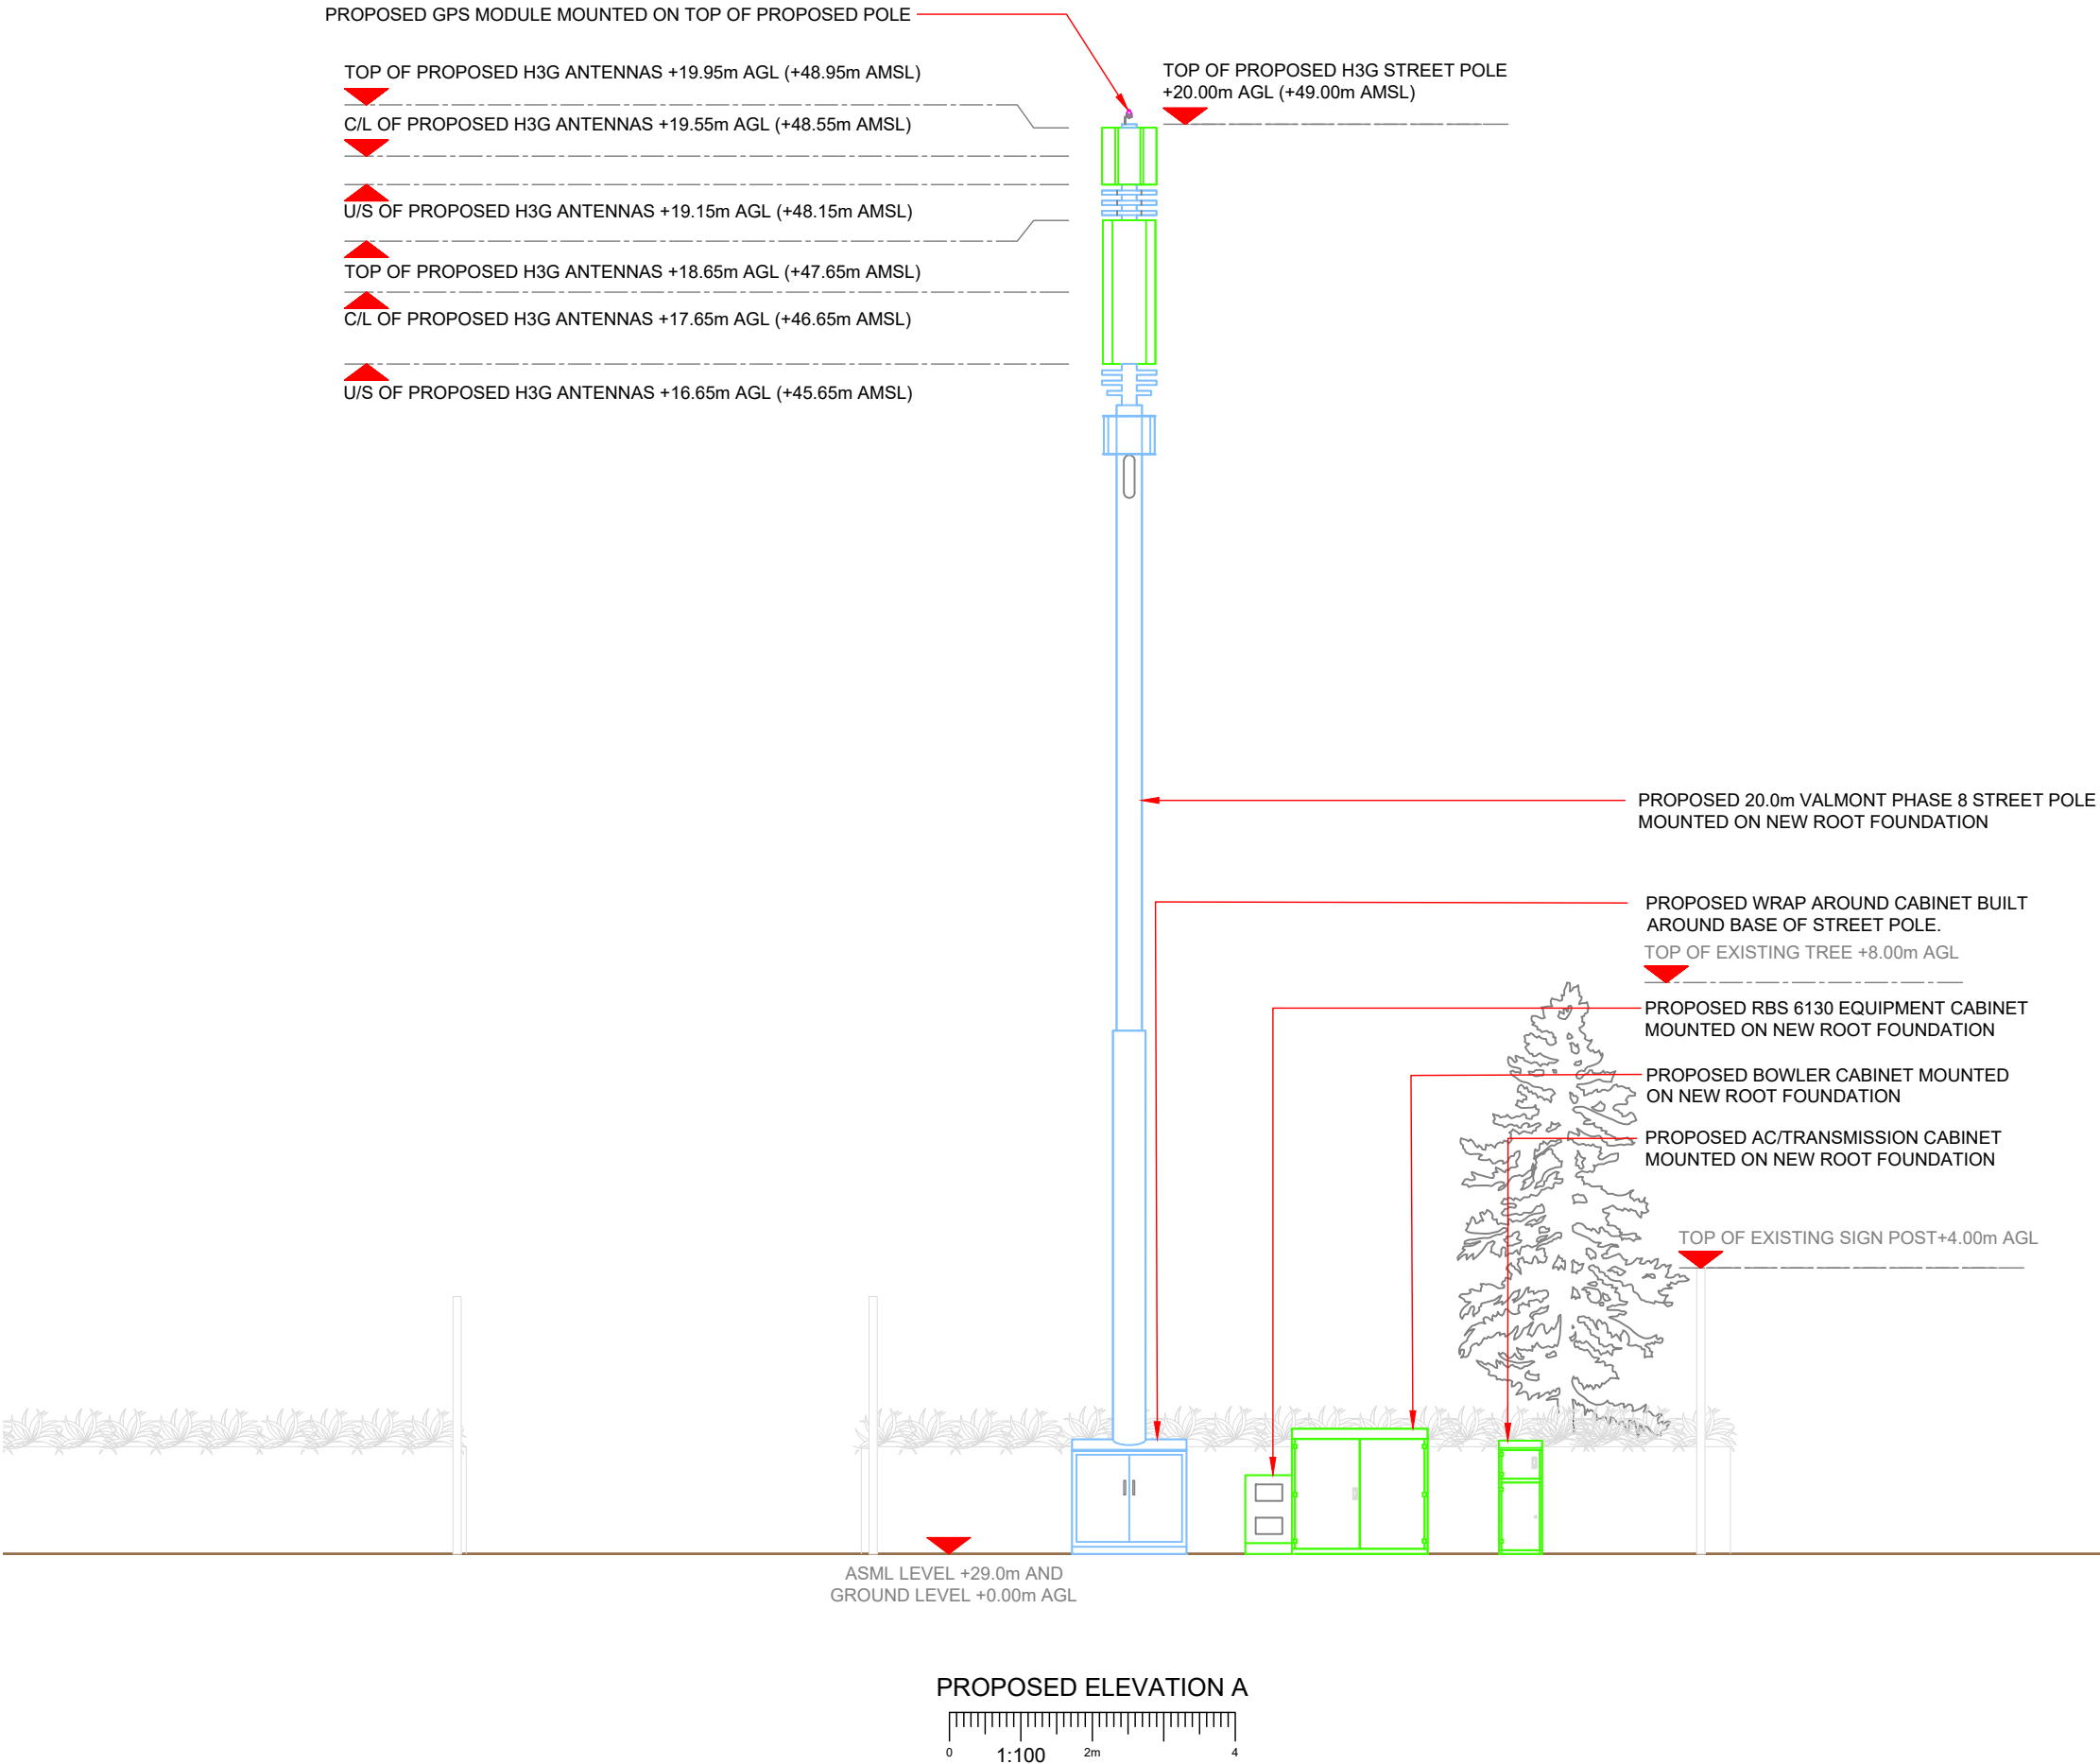

NOTES:
1. ALL DIMENSIONS IN MM UNLESS OTHERWISE NOTED.

Master:	MBNL / EE / H3G:	Project:	Purpose of Issue:	Issue:
M001	H3G	DENSIFICATION SW	Planning	A
Date:	09/08/2022	Revision / Upgrade Description:		
Drawn:	S.Booth	First Issue - Site nomination dated: TBC		
Checked:	G.Thomas			
Approved:	G.Thomas			

Hutchison 3G UK Limited
Green Park, 450 Longwater Avenue
Reading, RG30 3UR
Tel: 01628 765 000
Fax: 01628 765 001

H3G Base Station Information line:
0845 6043000
Available 8am-8pm Monday to Friday

Design Consultant & Principal Contractor:

Unit E, Madison Place, Northampton Road,
Manchester, M40 5AG
Tel: 0161 785 4500 Fax: 0161 785 4501
Web: www.clarke-telecom.com

Site Name:

BRIDGE STREET

Site ID:

MAN24538

Address:

BRIDGE STREET
ST JOHN'S
MANCHESTER
M3 5AH

Title:

260 PROPOSED H3G SITE ELEVATION

Project:

H3G DENSIFICATION STREETWORKS

Purpose of Issue:

PLANNING

EE Cell ID:	MBNL Cell ID:	3UK Cell ID:
-	-	MAN24538

Master Drawing No:	Issue:
MAN24583_B35_GA_A	A