


Proposed works
Mechanical Services_

1. Heating & Cooling
High level hidden-concealed wall mounted air conditioning unit,
complete with brass effect grill on front face of partition.

Notes:
No pipework or mechanical heating and cooling units to be on show in the restaurant. Architect and mechanical engineer to agree routes and final positions before (final) costs and specification are produced.

NEW AIR CONDITIONING

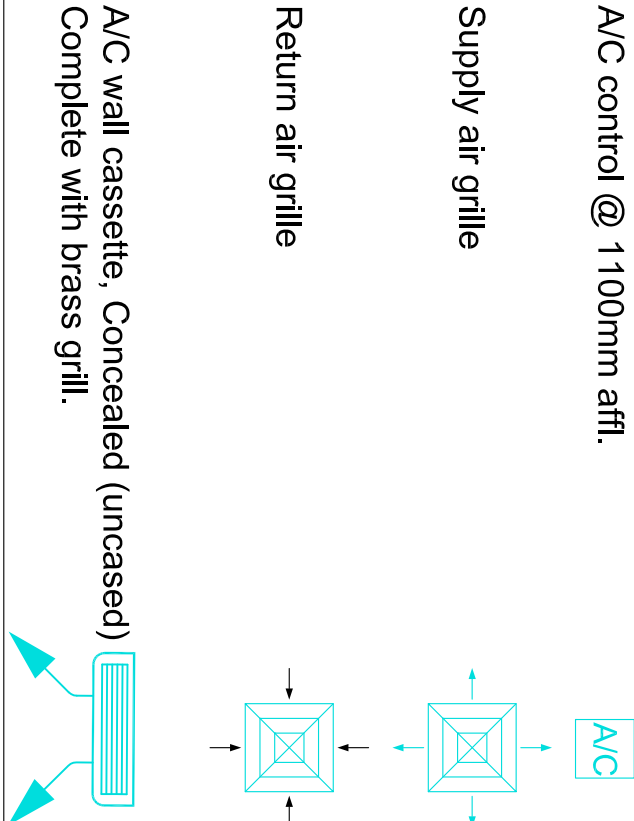


READ DRAWING IN CONJUNCTION WITH THE ARCHITECTS CONCEPT DESIGN WORKBOOK 01
MECHANICAL ENGINEER TO PRODUCE FINAL LAYOUT AND DETAILS, DRAWING IS ONLY FOR REFERENCE.



Mechanical Services

First Floor
scale A1@1:25

CUBE8 STUDIO	CLIENT:	BUILDING:	DRAWING TITLE:				DRAWN BY:	DATE:	SIZE:	REV:
	Armenian Experience	Victoria Building Albert Square Manchester	Mechanical Services 1st Floor Plan	DWG No.: C8S_10186.1.15		SCALE: 1:25	DOC FOR: Information	A1		
COPYRIGHT: The copyright in this drawing is vested in Cube8 Studio Ltd and no licence or assignment of any kind has been, or is, granted to any third party whether by provision of copies or originals of the drawings or otherwise unless otherwise agreed in writing. DO NOT SCALE FROM THIS DRAWING.										
BUILDING APPRAISAL HUMAN-CENTERED DESIGN SPACE PLANNING INTERIOR DESIGN & ARCHITECTURE BRAND & IDENTITY FURNITURE & ACCESSORIES 3D VISUALISATION PROJECT MANAGEMENT										

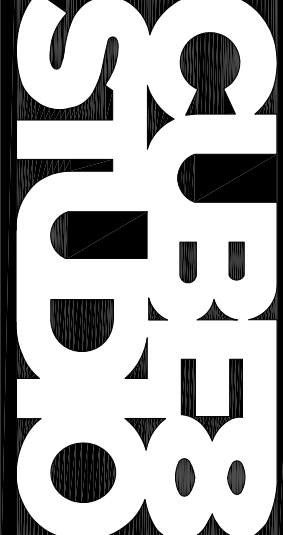

0161 849239
info@cube8studio.com
studio 427, The Mews, Mcr
Black & White Bld, London
www.cube8studio.com

