


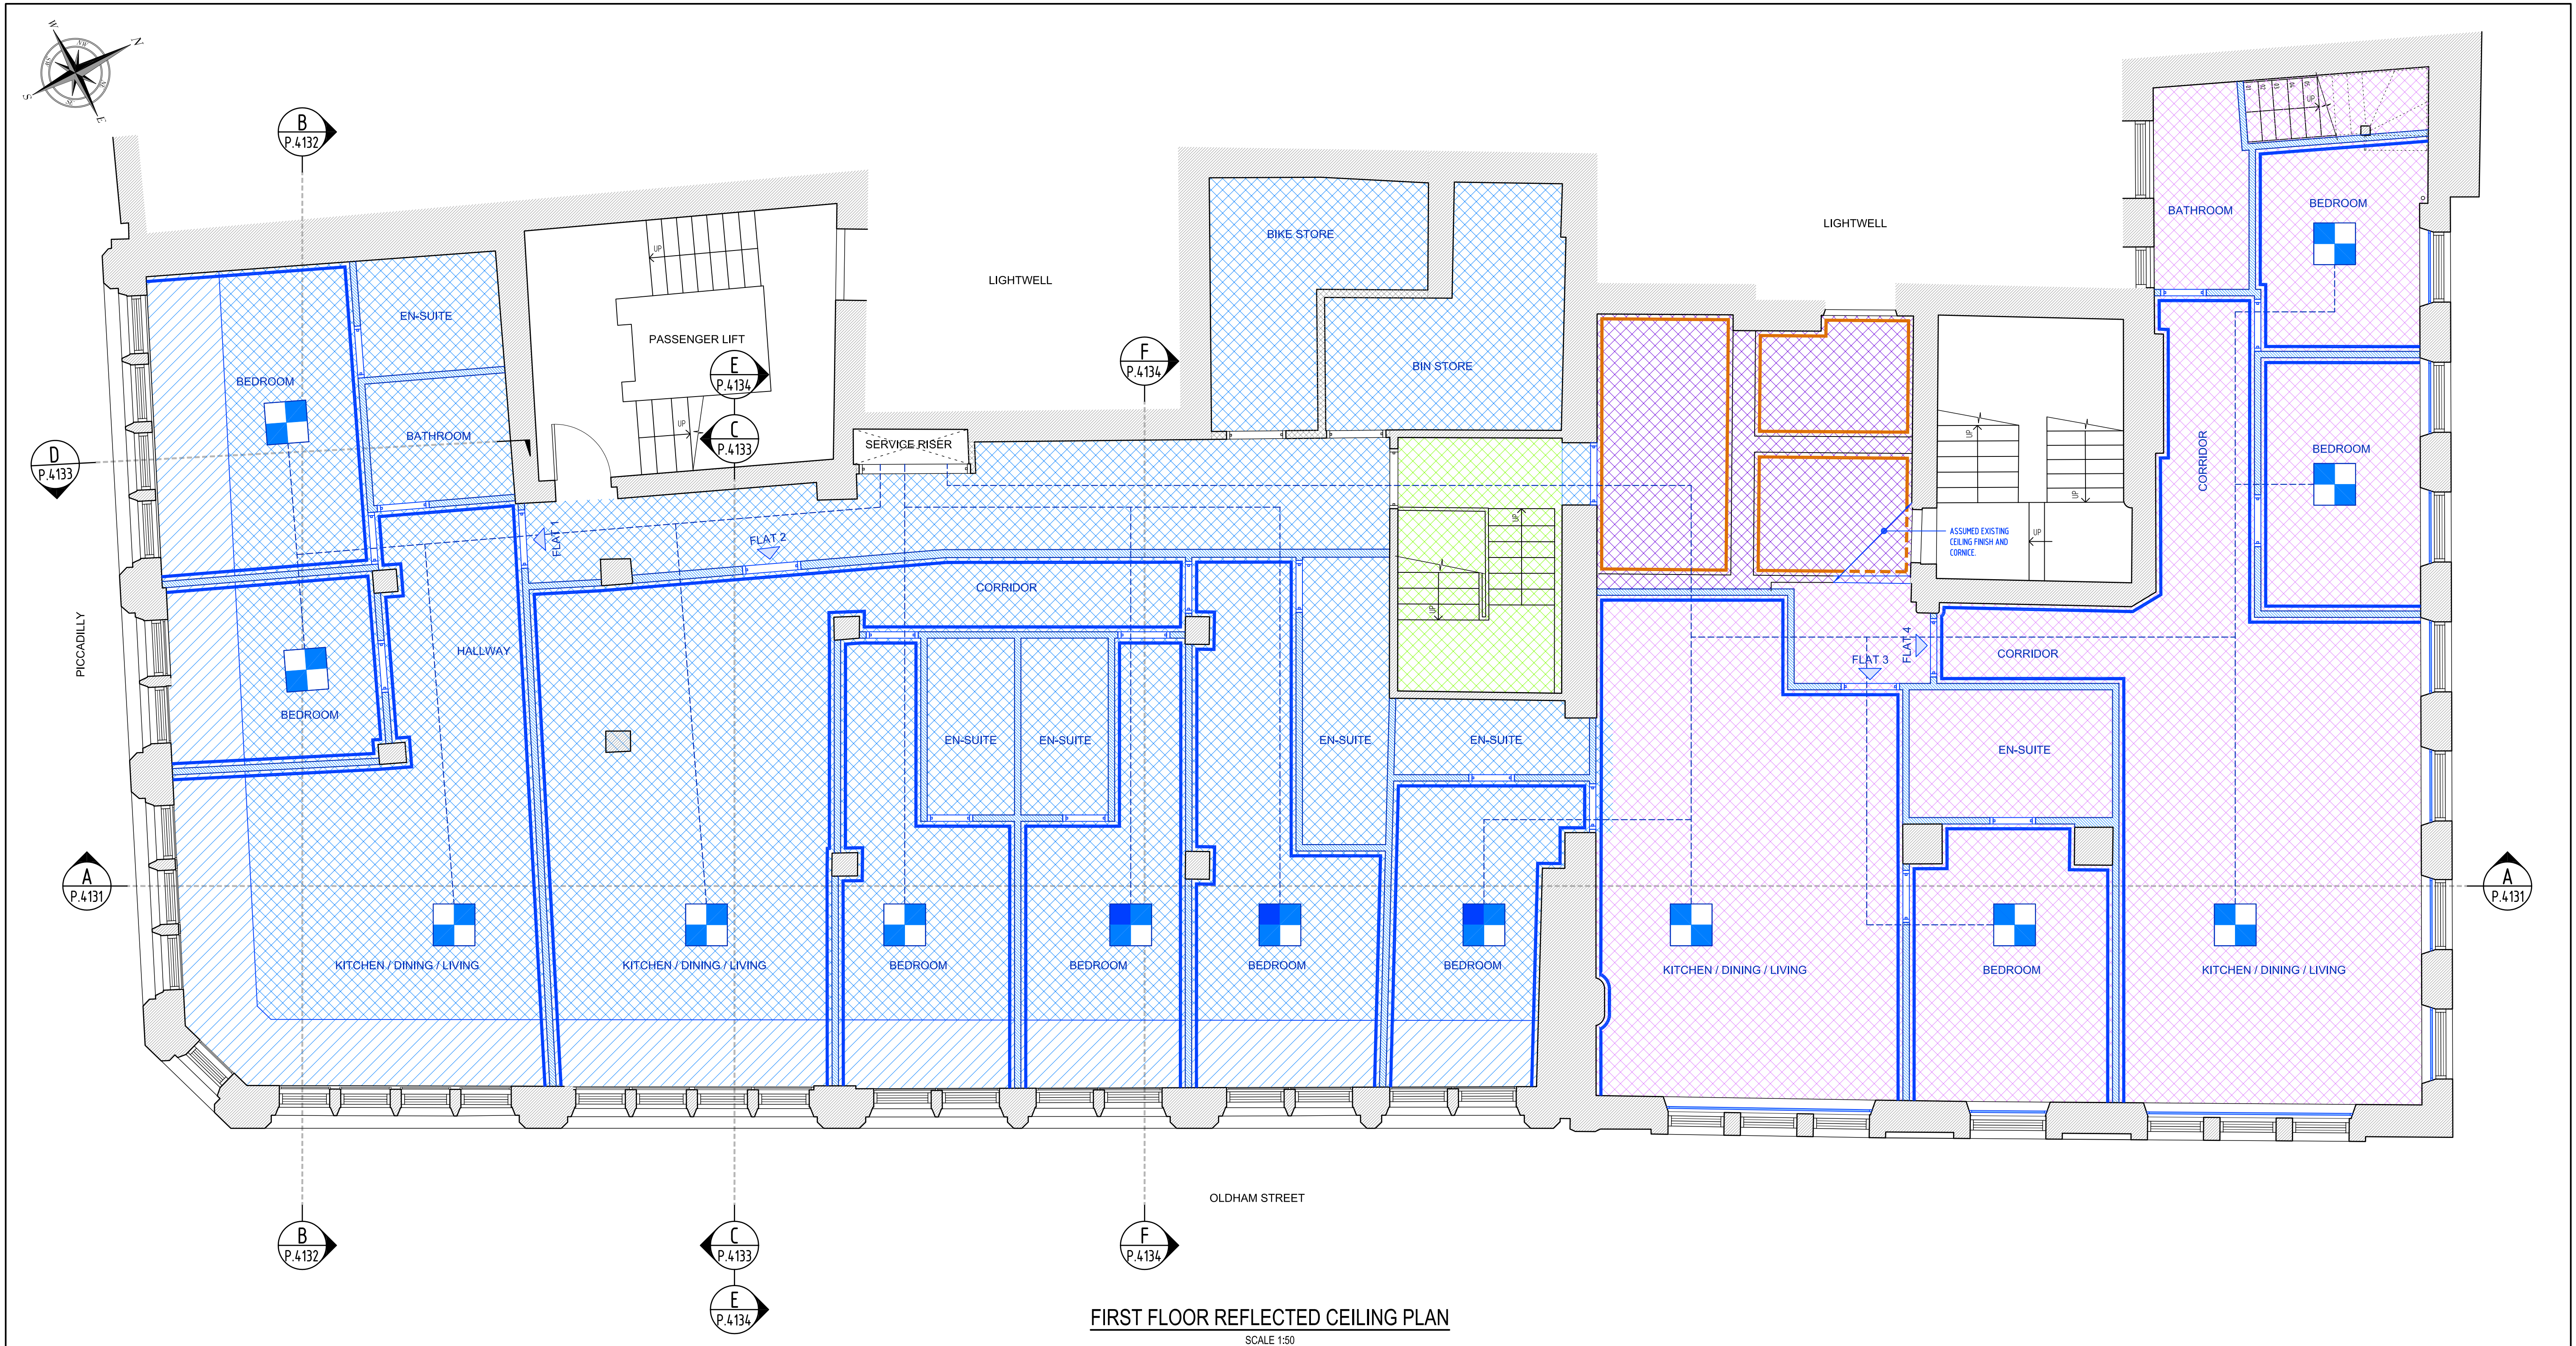

NOTES

1. **GENERAL:**

11. DO NOT SCALE FROM THIS DRAWING. CHECK ALL DIMENSIONS AND CONDITIONS ON SITE.

12. ALL WORKS TO BE CARRIED OUT IN ACCORDANCE WITH CURRENT HEALTH & SAFETY INCLUDING COMI REGULATIONS. ALL WORKS TO COMPLY WITH CURRENT BRITISH STANDARDS, CODES OF PRACTICE, BUILDING REGULATIONS AND APPROPRIATE EUROPEAN STANDARDS.


13. ALL STRUCTURAL WORK IS TO BE CARRIED OUT IN ACCORDANCE WITH THE STRUCTURAL ENGINEER'S DETAILS AND CALCULATIONS.

14. PRECISE POSITIONS OF ALL FIXTURES AND FITTINGS IS SUBJECT TO CONFIRMATION ON SITE.

15. THIS DRAWING IS PRODUCED FOR PLANNING APPLICATION ONLY AND SHOULD NOT BE USED FOR ANY OTHER PURPOSES.

16. ALL INFORMATION SHOWN ON THIS EXISTING DRAWING IS BASED ON SURVEY DRAWING NUMBER EAST7-20-01 PRODUCED BY 'EA LONDON SURVEY COMPANY'.

LEGEND:	
	DENOTES ORIGINAL EXISTING WALL
	DENOTES NON-ORIGINAL EXISTING WALL
	DENOTES PROPOSED WORKS
	DENOTES EXPOSED MECHANICAL VENTILATION INCLUDING COOLING. EXPOSED PIPE RUNS SHOWN INDICATIVELY.
NOTE: ALL CEILINGS AND WALLS HAVE BEEN DETERMINED BY NON-INTRUSIVE VISUAL INSPECTION.	
	DENOTES PROPOSED FIRE RESISTANT PLASTERBOARD CEILING FIXED TO EXISTING.
	DENOTES PROPOSED RECESSED PLASTERBOARD CEILING FIXED TO EXISTING.
	DENOTES EXISTING SUSPENDED CEILING (600x600 GRID SYSTEM)
	DENOTES RECENTLY INSTALLED FIRE RESISTANT PLASTERBOARD CEILING
	DENOTES EXISTING TIGHTLY-ATTACHED CEILING
	DENOTES EXISTING CORNICE
	DENOTES PROPOSED CORNICE

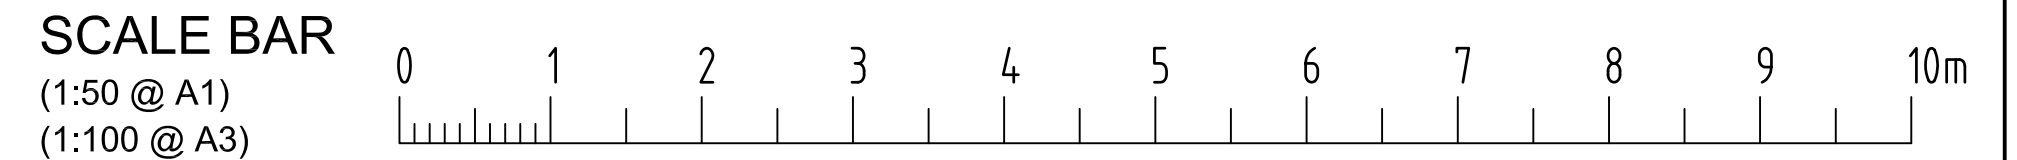

JOB NO. 1192				JOB TITLE YORKSHIRE BUILDING SOCIETY 17 PICCADILLY, MANCHESTER				ISP DRAWING SOLUTIONS 21 MONKS CLOSE MIDDLESEX, HA4 9HX TEL: 0044 7886116912 EMAIL: info@ispdrawingsolutions.co.uk www.ispdrawingsolutions.co.uk			
DRG TITLE SCHEME D - PROPOSED FIRST FLOOR REFLECTED CEILING PLAN				DRG NO. P.4201				SCALE 1:50 @ A1 1:100 @ A3			
REV /				DATE				IP 06/2022			