



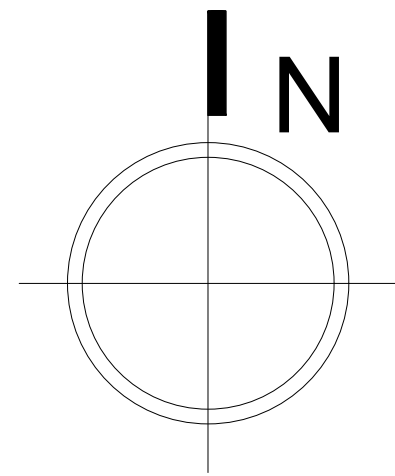


- DO NOT SCALE FROM THIS DRAWING - USE FIGURED DIMENSIONS ONLY.
- READ IN CONJUNCTION WITH ALL OTHER CONSULTANTS / SPECIALISTS DRAWINGS, REPORT ANY DISCREPANCIES BEFORE AFFECTED WORK COMMENCES.
- ALL SETTING OUT DIMENSIONS TO BE CHECKED ON SITE BY CONTRACTOR BEFORE WORK COMMENCES.
- THIS DRAWING REMAINS COPYRIGHT OF KEPCZYK PEARCE SANDERSON LTD. COPY / DISTRIBUTE ONLY WITH CONSENT OF THE AUTHOR.

KEY	
	CAT. B
	CAT. C
	CAT. D
	CAT. E
	CAT. F
	CAT. G
	CAT. H

(SEE FR 011 FOR KEY TO MASONRY REPAIRS)

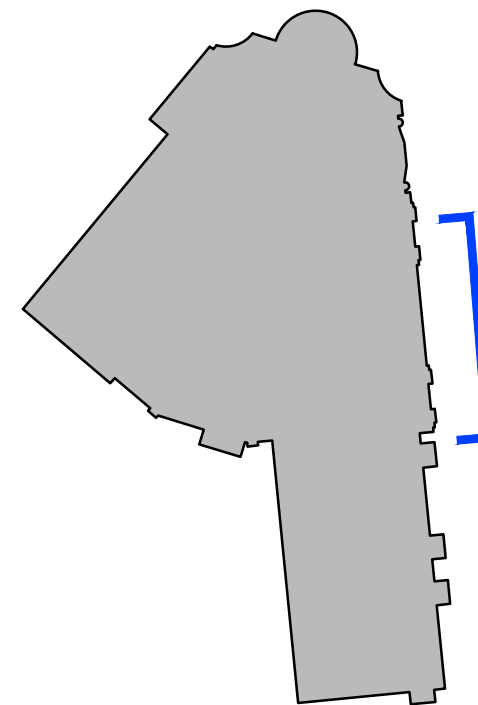

Key Plan
Scale 1:500

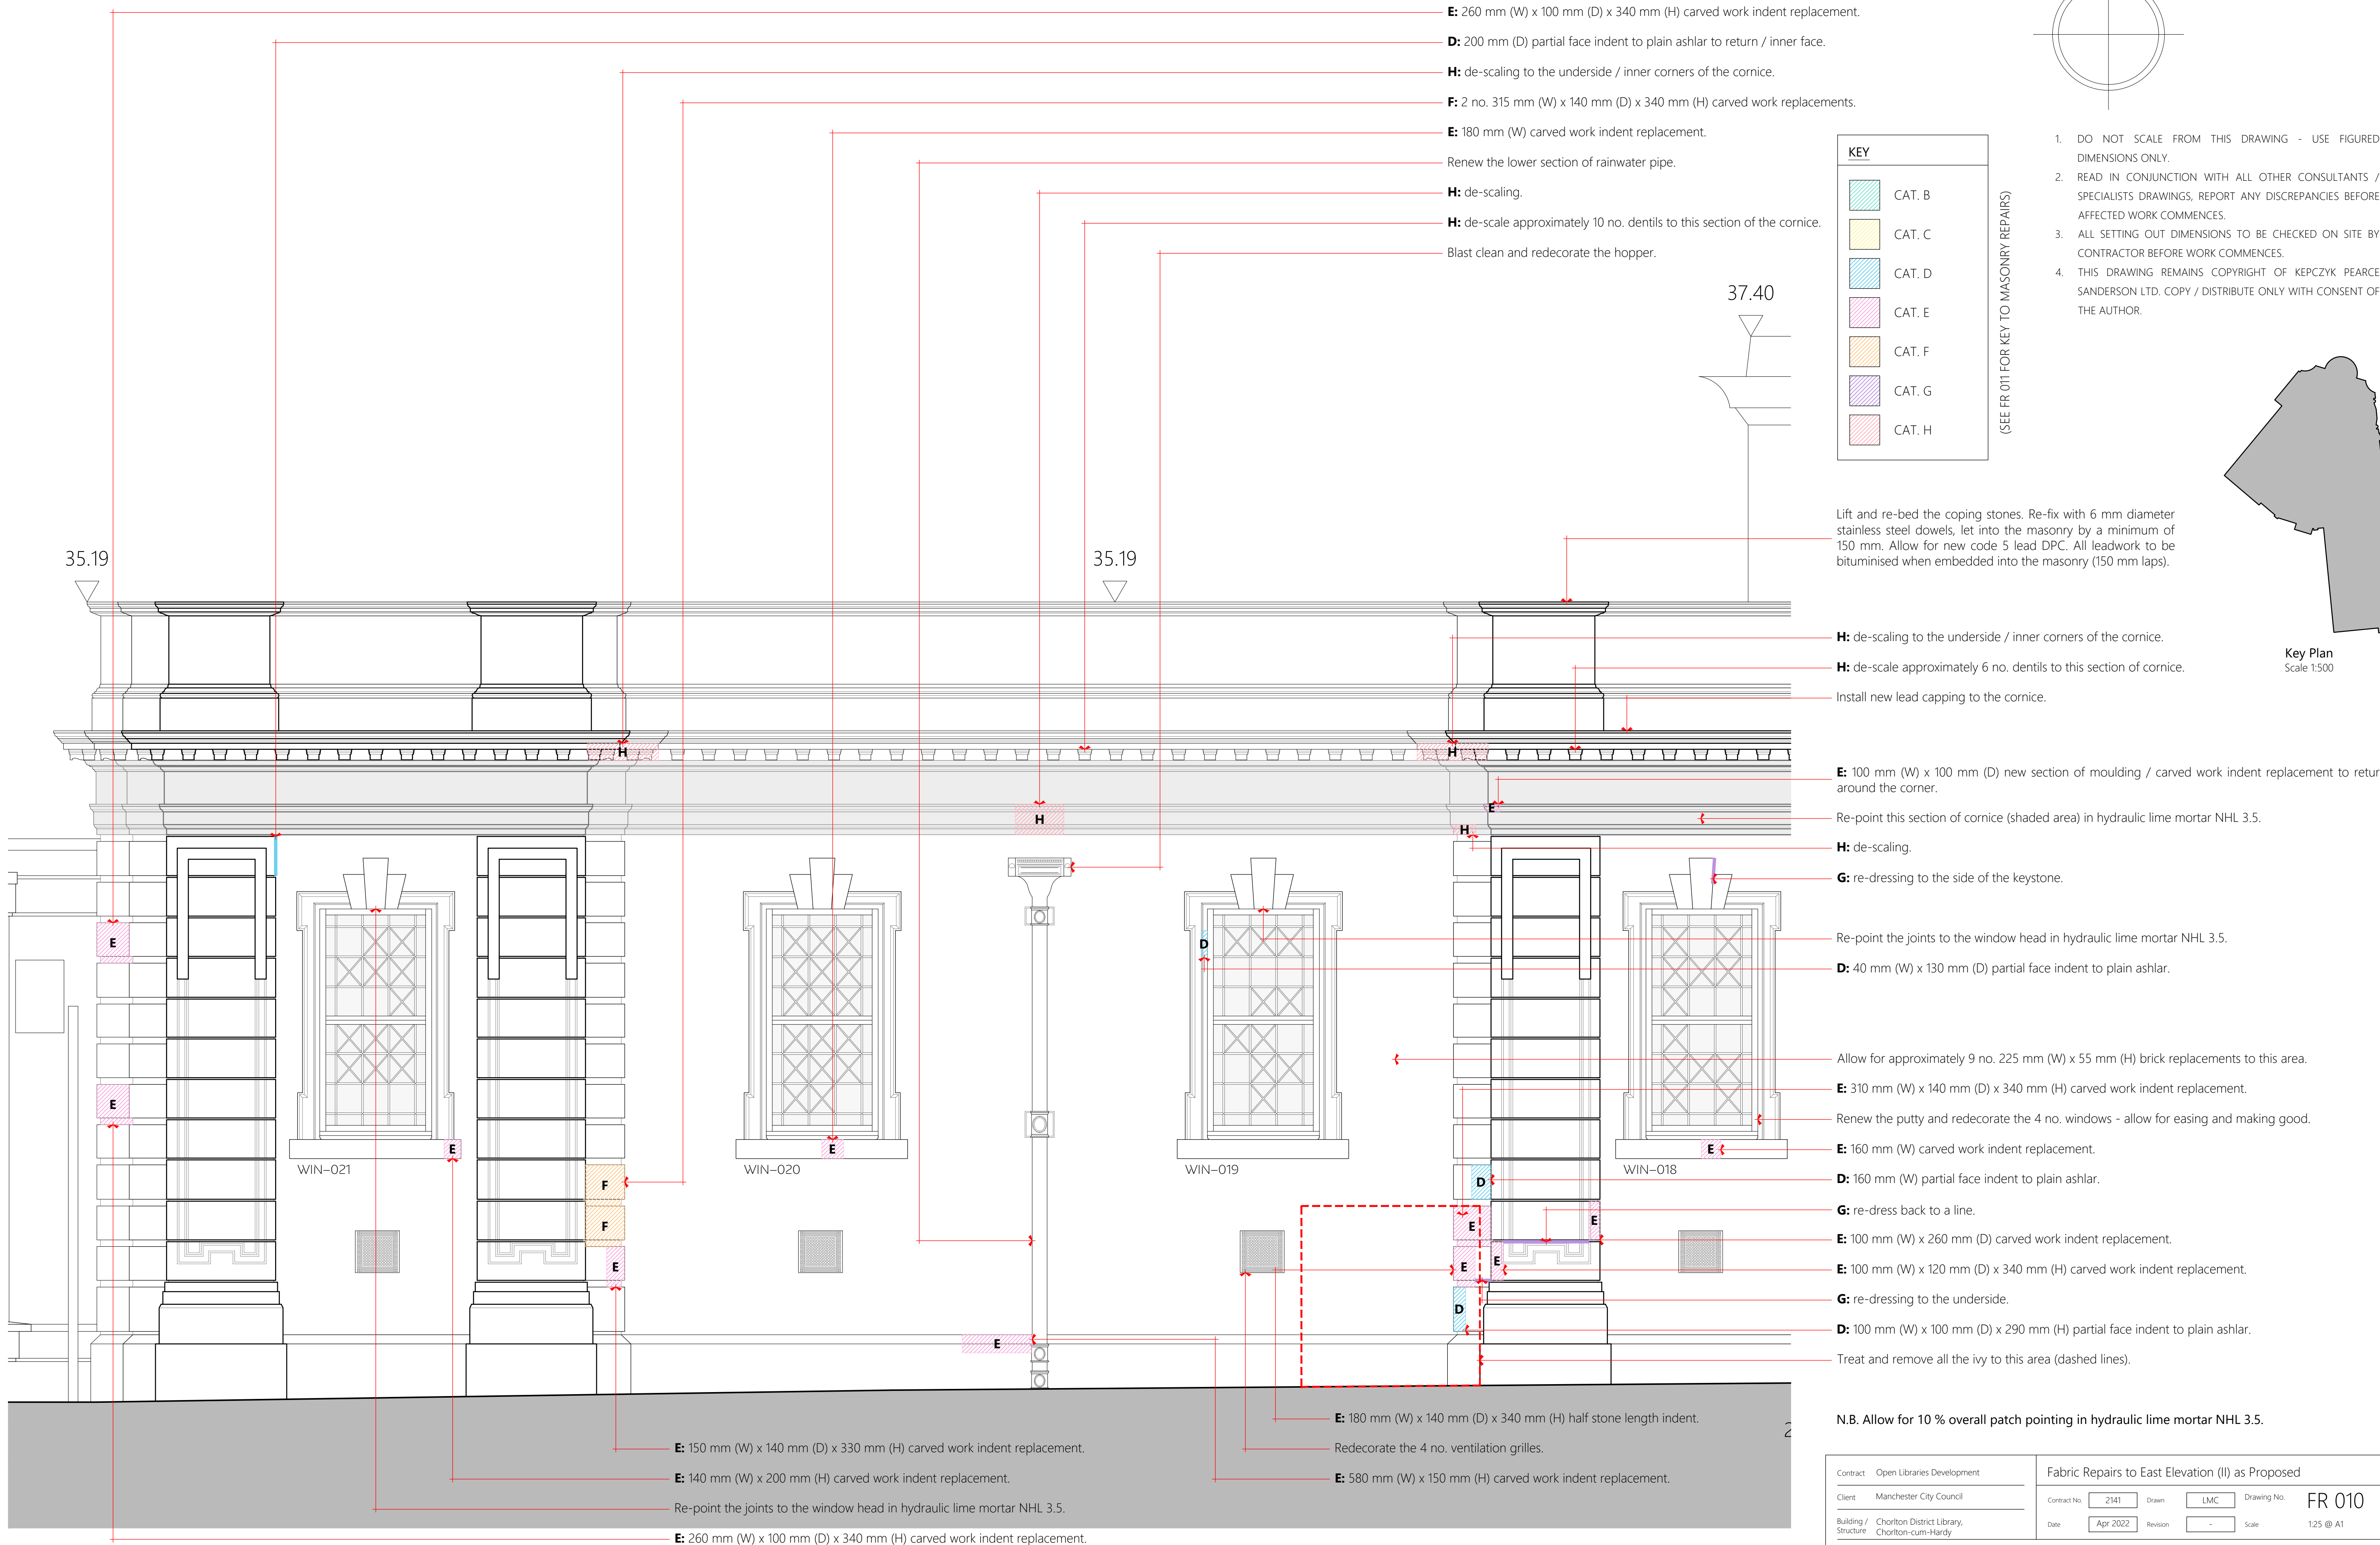

N.B. Allow for 10 % overall patch pointing in hydraulic lime mortar NHL 3.5.

Contract Open Libraries Development		Fabric Repairs to East Elevation (II) as Proposed			
Client Manchester City Council	Contract No. 2141 Drawn LMC Drawing No. FR 010				
Building / Structure Chorlton District Library, Chorlton-cum-Hardy	Date Apr 2022 Revision - Scale 1:25 @ A1				
KEPCZYK PEARCE SANDERSON ARCHITECTS, SURVEYORS, & HISTORIC BUILDING CONSULTANTS		Address: 75 Wilmslow Road, Handforth, Cheshire SK9 3EN 01625 400103			