


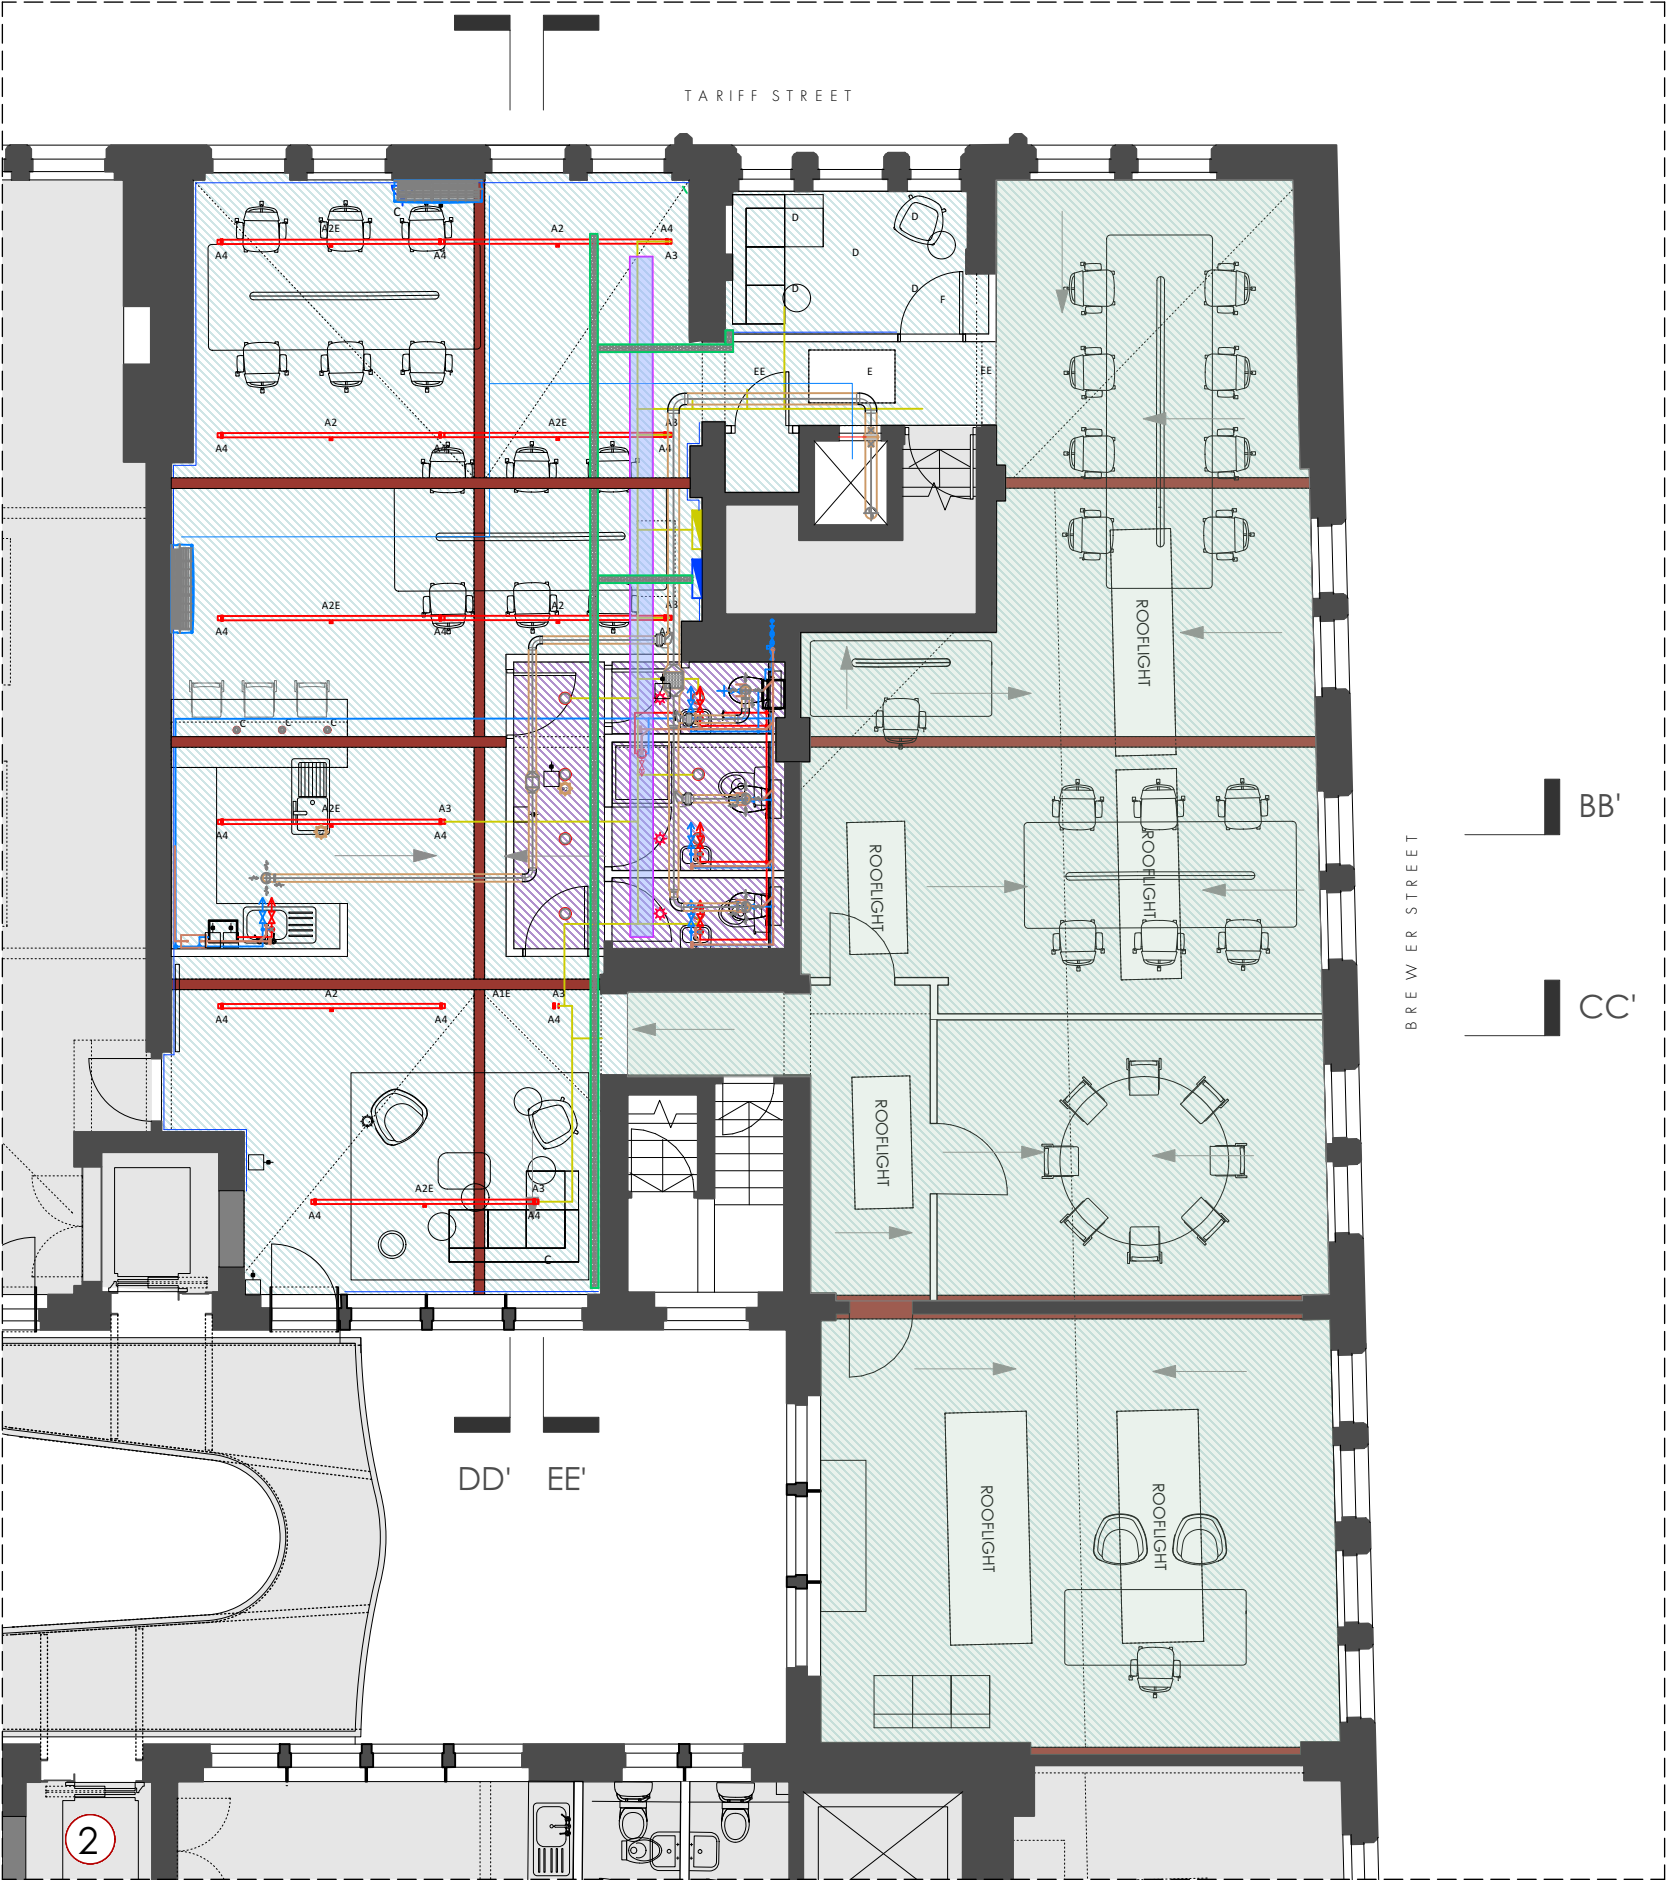

FOURWAYS HOUSE, FIFTH FLOOR
PROPOSED REFLECTED CEILINGS PLAN
1:100 @ A3

REVISION	DATE	DESCRIPTION
P01	05.04.22	FOR COMMENT
P02	03.08.22	PLANNING ISSUE

REFLECTED CEILINGS KEY

EXISTING PLASTERED CEILING (TO UNDERSIDE OF ROOF)

EXISTING PLASTERED SUSPENDED CEILING

ORIGINAL TIMBER TRUSSES EXPOSED

ALL LIGHTING, HEATING AND VENTILATION EQUIPMENT IN THIS AREA TO REMAIN AS EXISTING

MECHANICAL AND ELECTRICAL KEY

ELECTRICAL SYMBOL LEGEND:

A1

Thorlux 30/45w LED 1500mm Hi-Bar Suspended Continuous Luminaire - Smart Scan (Colour TBC)

A1E

Thorlux 30/45w LED 1500mm Hi-Bar Suspended Continuous Luminaire - Smart Scan Emergency (Colour TBC)

A2

Thorlux 60/90w LED 3000mm Hi-Bar Suspended Continuous Luminaire - Smart Scan (Colour TBC)

A2E

Thorlux 60/90w LED 3000mm Hi-Bar Suspended Continuous Luminaire - Smart Scan Emergency (Colour TBC)

A3

Thorlux Hi-Bar Suspended End Kit

A4

Thorlux Hi-Bar Suspension Kit

VENTILATION LEGEND:

Extract Fan

Extract Grille

Volume Control Damper

Smoke & Fire Damper

Access Panel

300mm x 25mm Galvanised Cable Tray


Mitsubishi PEFY Series Fan Coil Unit (Or Equal & Approved)

Supply Circular Swirl c/w Coanda Plate (Gilberts Or Equal & Approved)

Volume Control Damper

Supply Air Ductwork

Refrigerant Pipework (High Level)

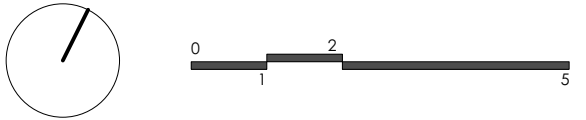

PLANNING

OMIArchitects

31 Blackfriars Road, Salford, Manchester, M3 7AQ
+44(0)161 832 3242 / info@omiarchitects.com / www.omiarchitects.com

PROJECT	FOURWAYS - F2U2 & F5U4 + F5U5					
DRAWING	FIFTH FLOOR - PROPOSED CEILINGS PLAN					
DATE	AUG '22	DRAWN BY	KT	SCALE	1:100	@A3
JOB NO.	1420	DWG.NO.	L 2259			