



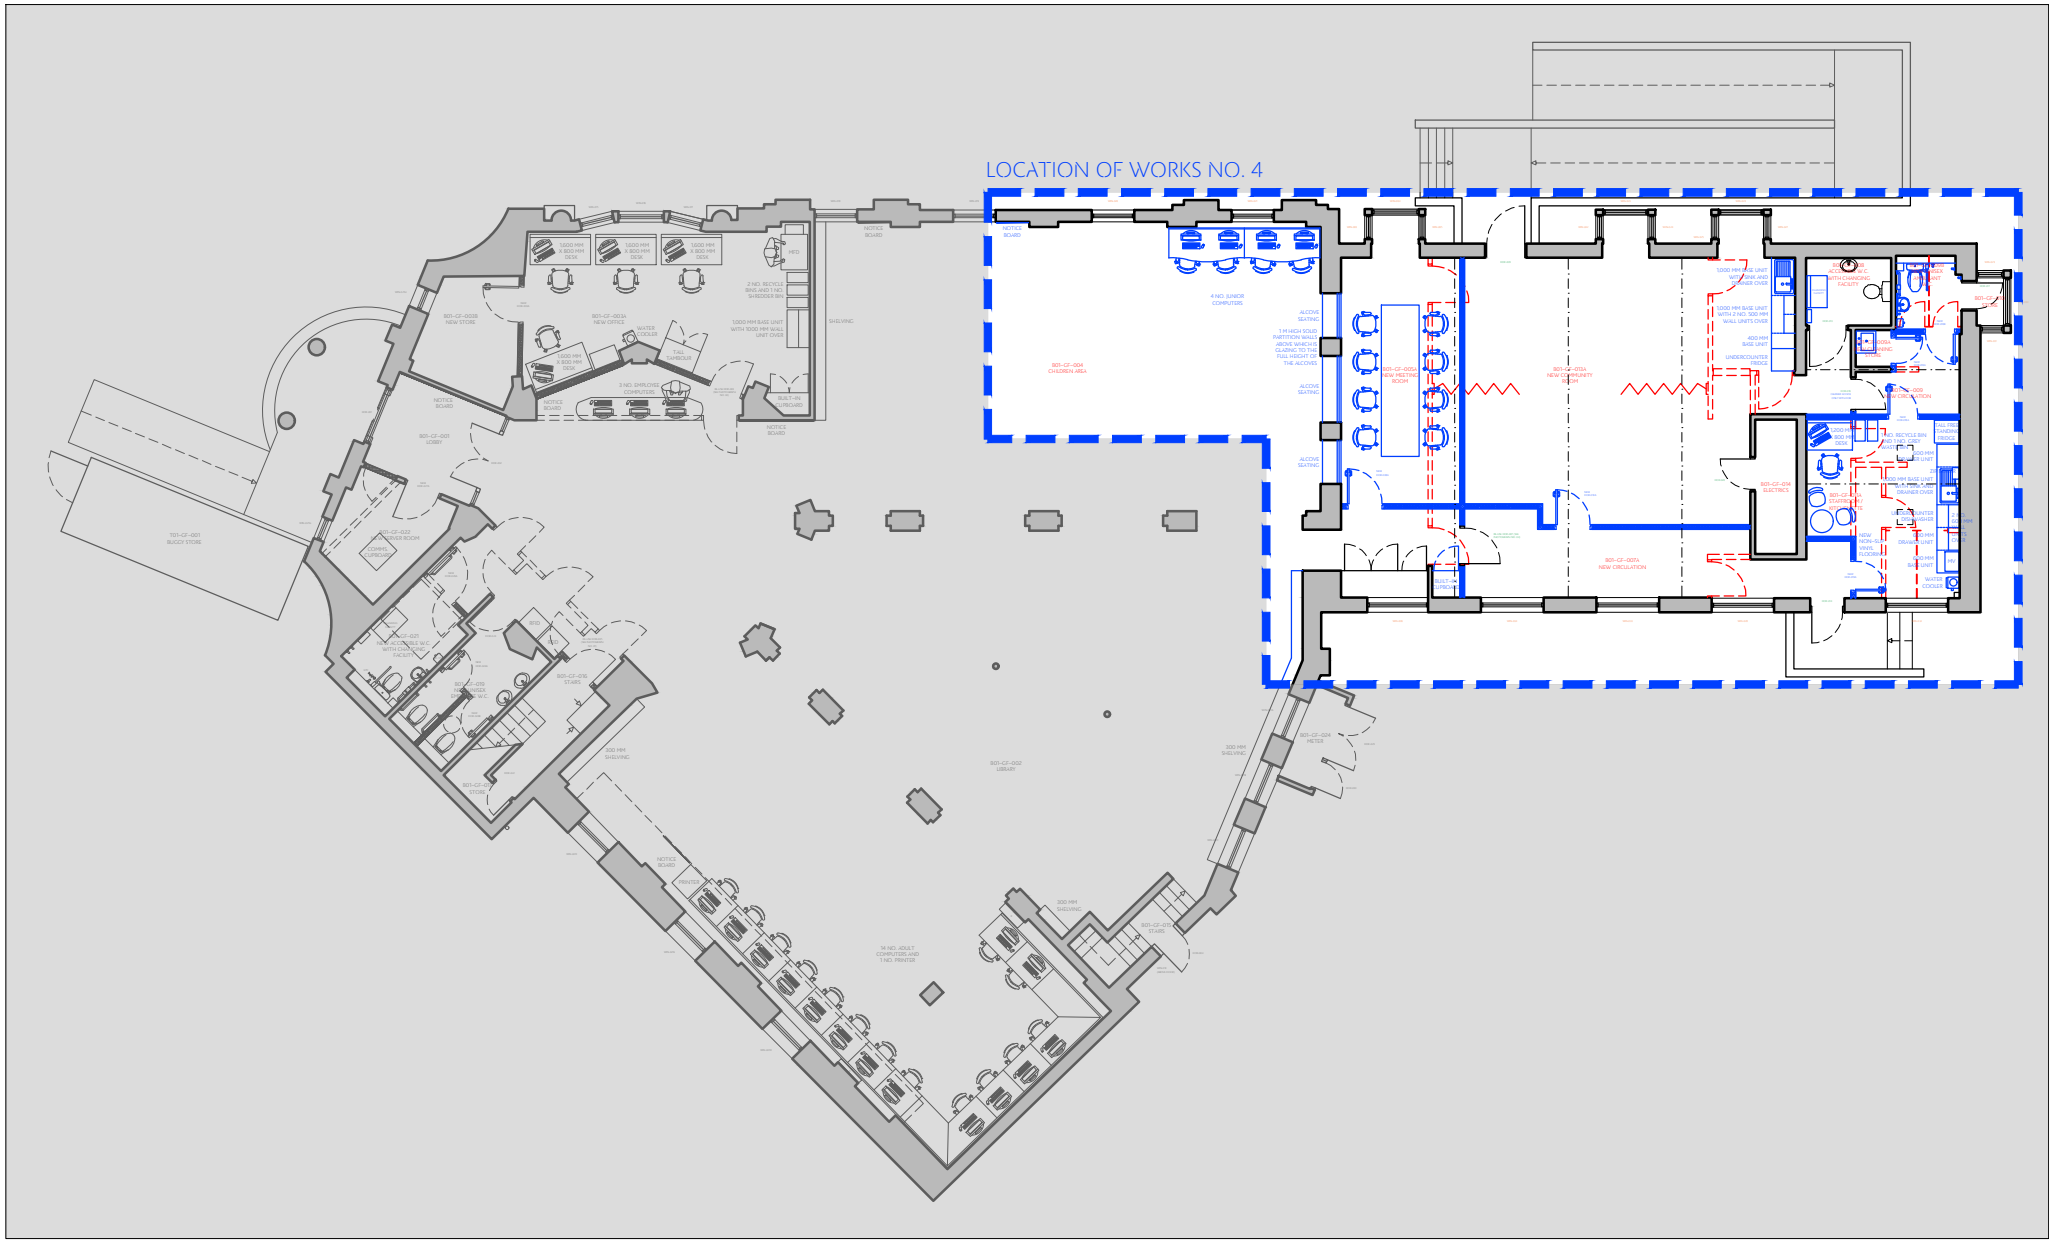

Key Plan
Scale 1:200

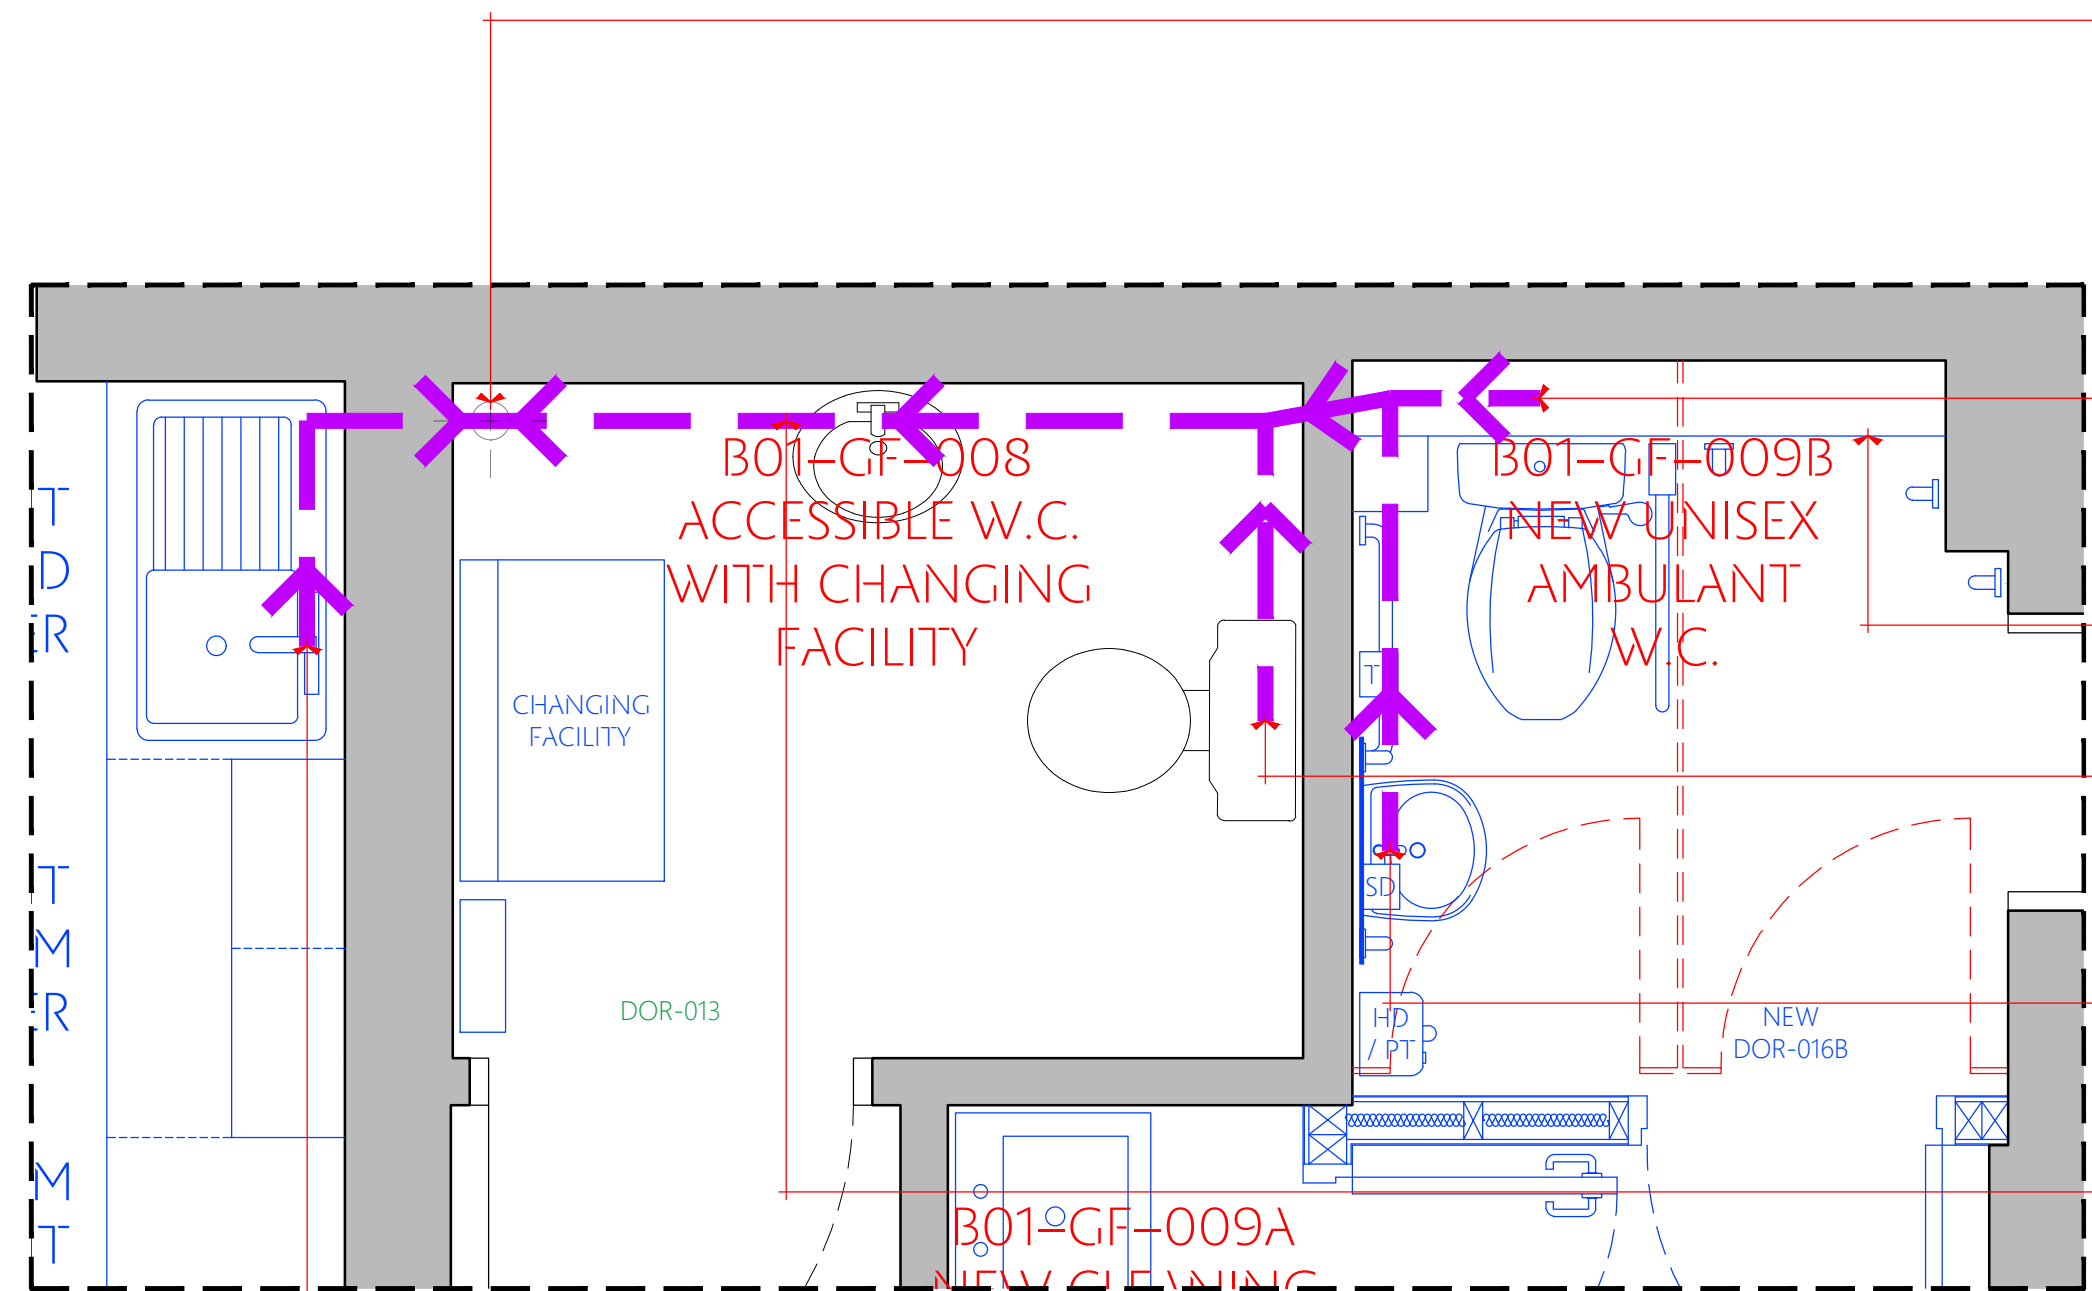

LOCATION OF WORKS NO. 4(i)
Waste Pipe Runs as Proposed
Scale 1:20

Existing soil stack (approximate location). Minimum dimension of 100 mm shown from centre of soil pipe to adjacent walls. Contractor to ensure that there is adequate space to make the necessary connections.

Existing Connection
Existing 110 mm low level waste pipe run for W.C. / connection to underground sewage system.


Boxing Behind W.C.
18 mm thick plywood to conceal existing stub stack.

Existing Connection
Existing 110 mm low level waste pipe run for W.C. / connection to underground sewage system.

New Connection
New 32 mm waste pipe run for handwash basin with trap and rodding eye.


Existing Connection
Existing 110 mm low level waste pipe run for W.C. / connection to underground sewage system, picking up existing 32 mm waste pipe run for handwash basin with trap and rodding eye.

Existing Connection
Existing 40 mm waste pipe run for kitchen sink with trap and rodding eye

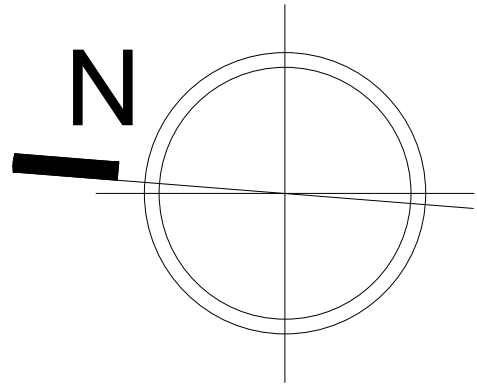


- DO NOT SCALE FROM THIS DRAWING - USE FIGURED DIMENSIONS ONLY.
- READ IN CONJUNCTION WITH ALL OTHER CONSULTANTS / SPECIALISTS DRAWINGS, REPORT ANY DISCREPANCIES BEFORE AFFECTED WORK COMMENCES.
- ALL SETTING OUT DIMENSIONS TO BE CHECKED ON SITE BY CONTRACTOR BEFORE WORK COMMENCES.
- THIS DRAWING REMAINS COPYRIGHT OF KEP CZYK PEARCE SANDERSON LTD. COPY / DISTRIBUTE ONLY WITH CONSENT OF THE AUTHOR.

KEY	
	WASTE RUNS (SCHEMATIC)
	ROOM REFERENCES
	DOOR REFERENCES
	WINDOW REFERENCES
	RADIATOR
	REMOVALS AS PROPOSED
	NEW WORKS AS PROPOSED

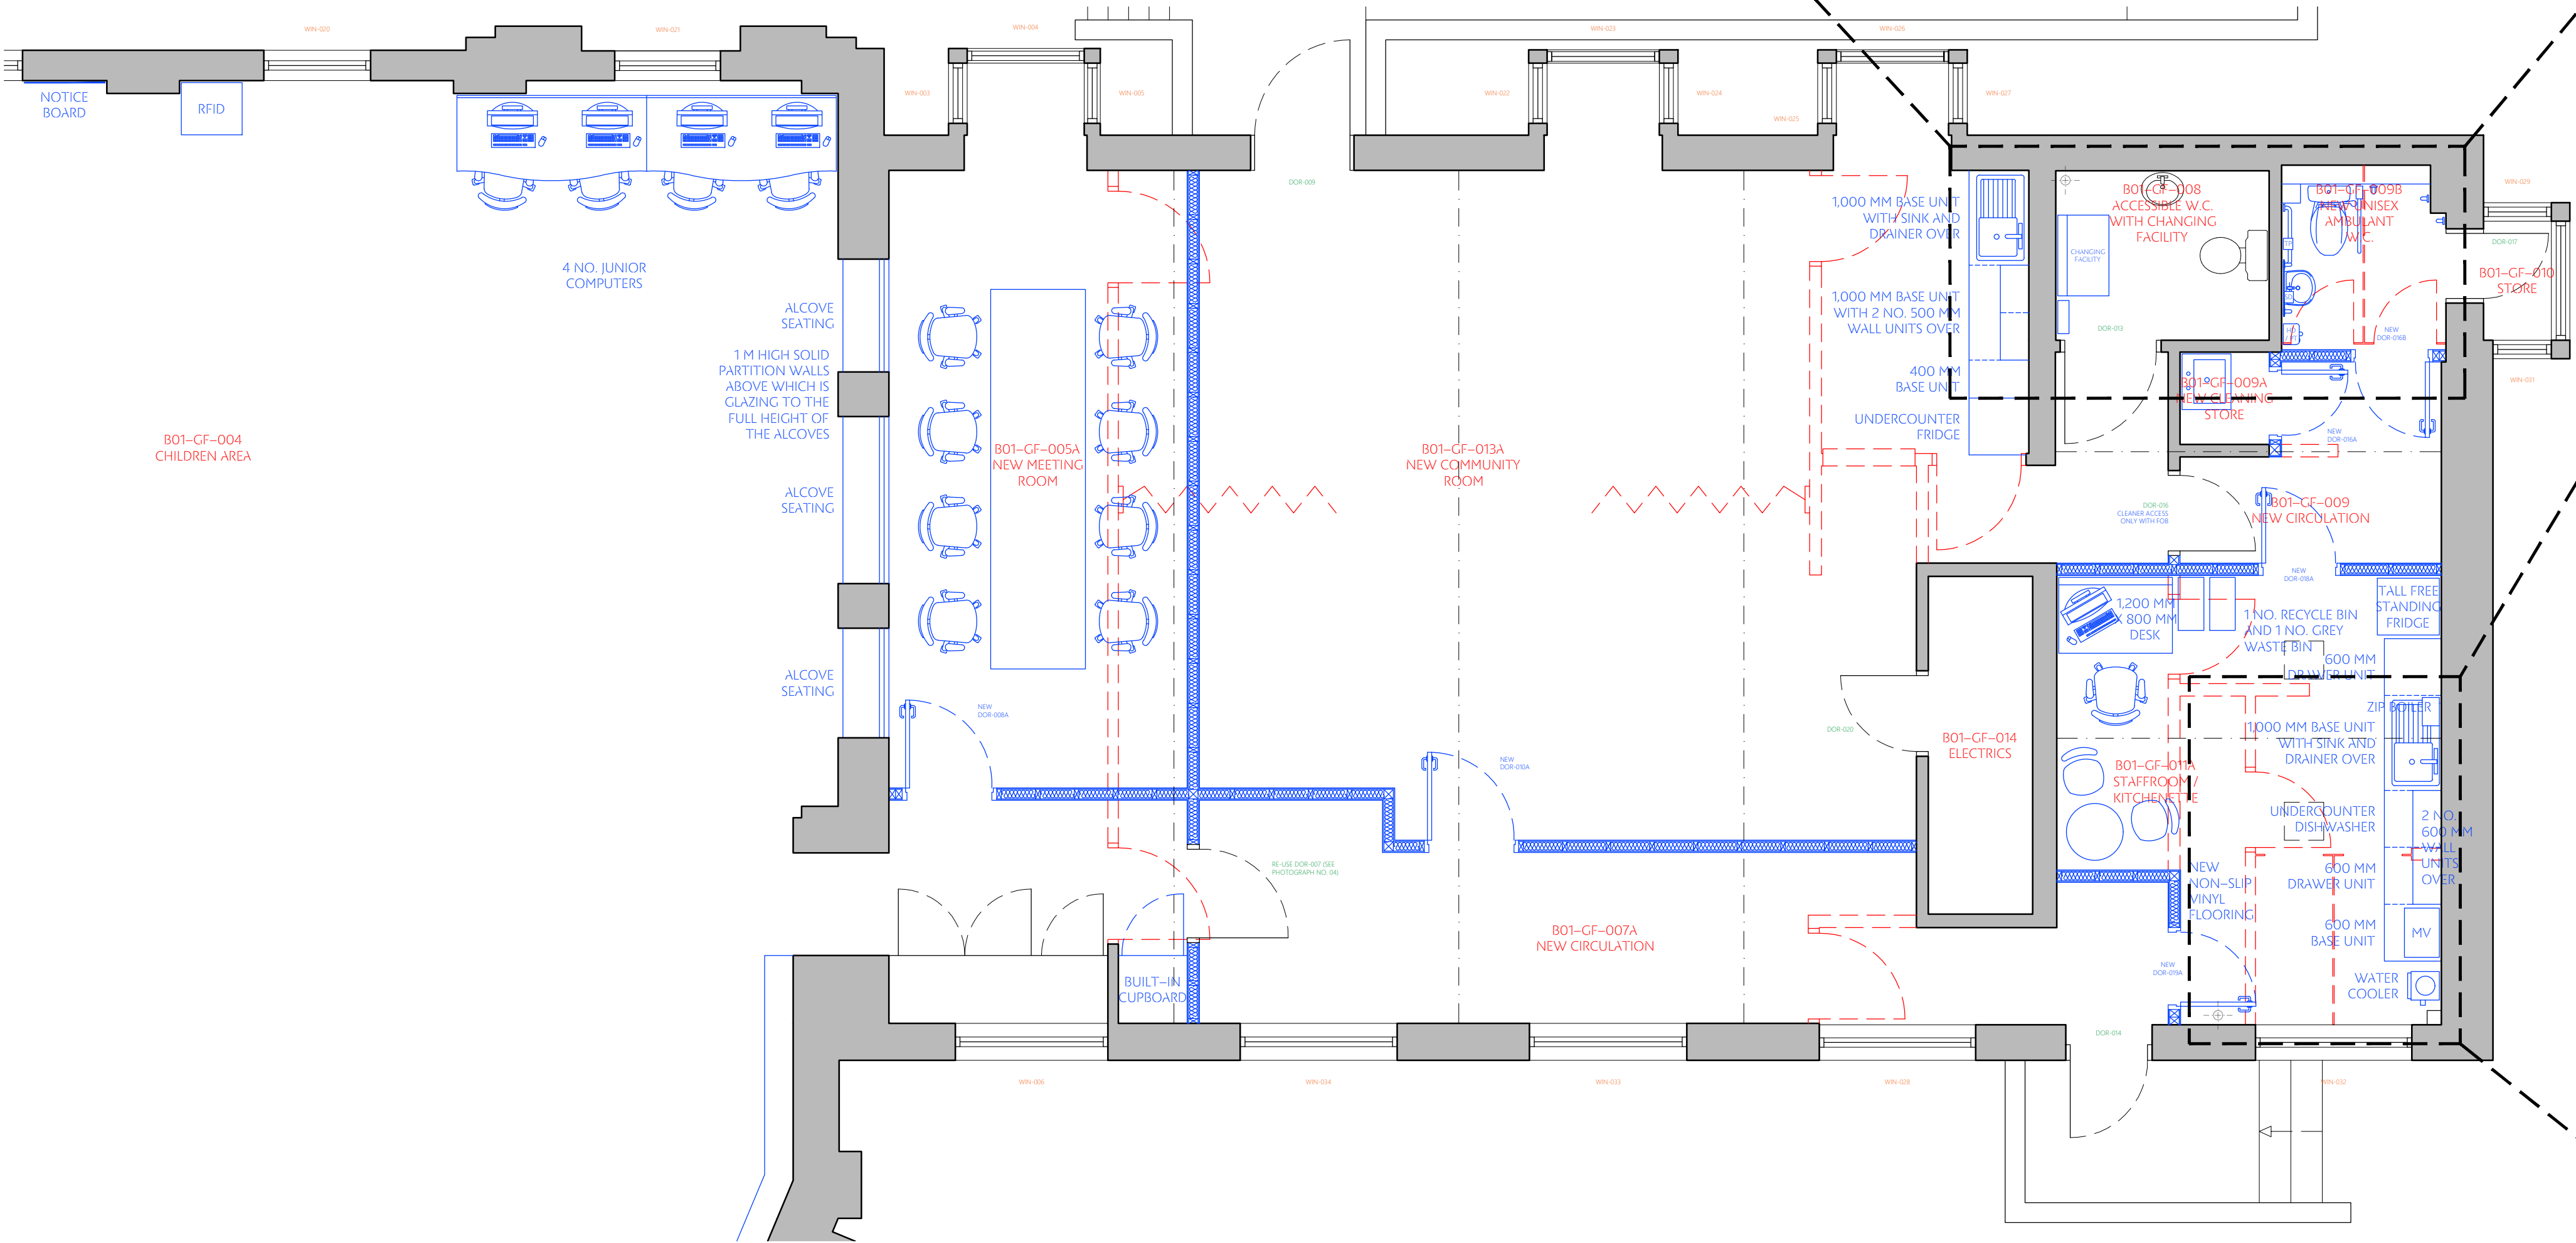

LOCATION OF WORKS NO. 4
Ground Floor Plan as Proposed
Scale 1:50

LOCATION OF WORKS NO. 4(ii)
Waste Pipe Runs as Proposed
Scale 1:20

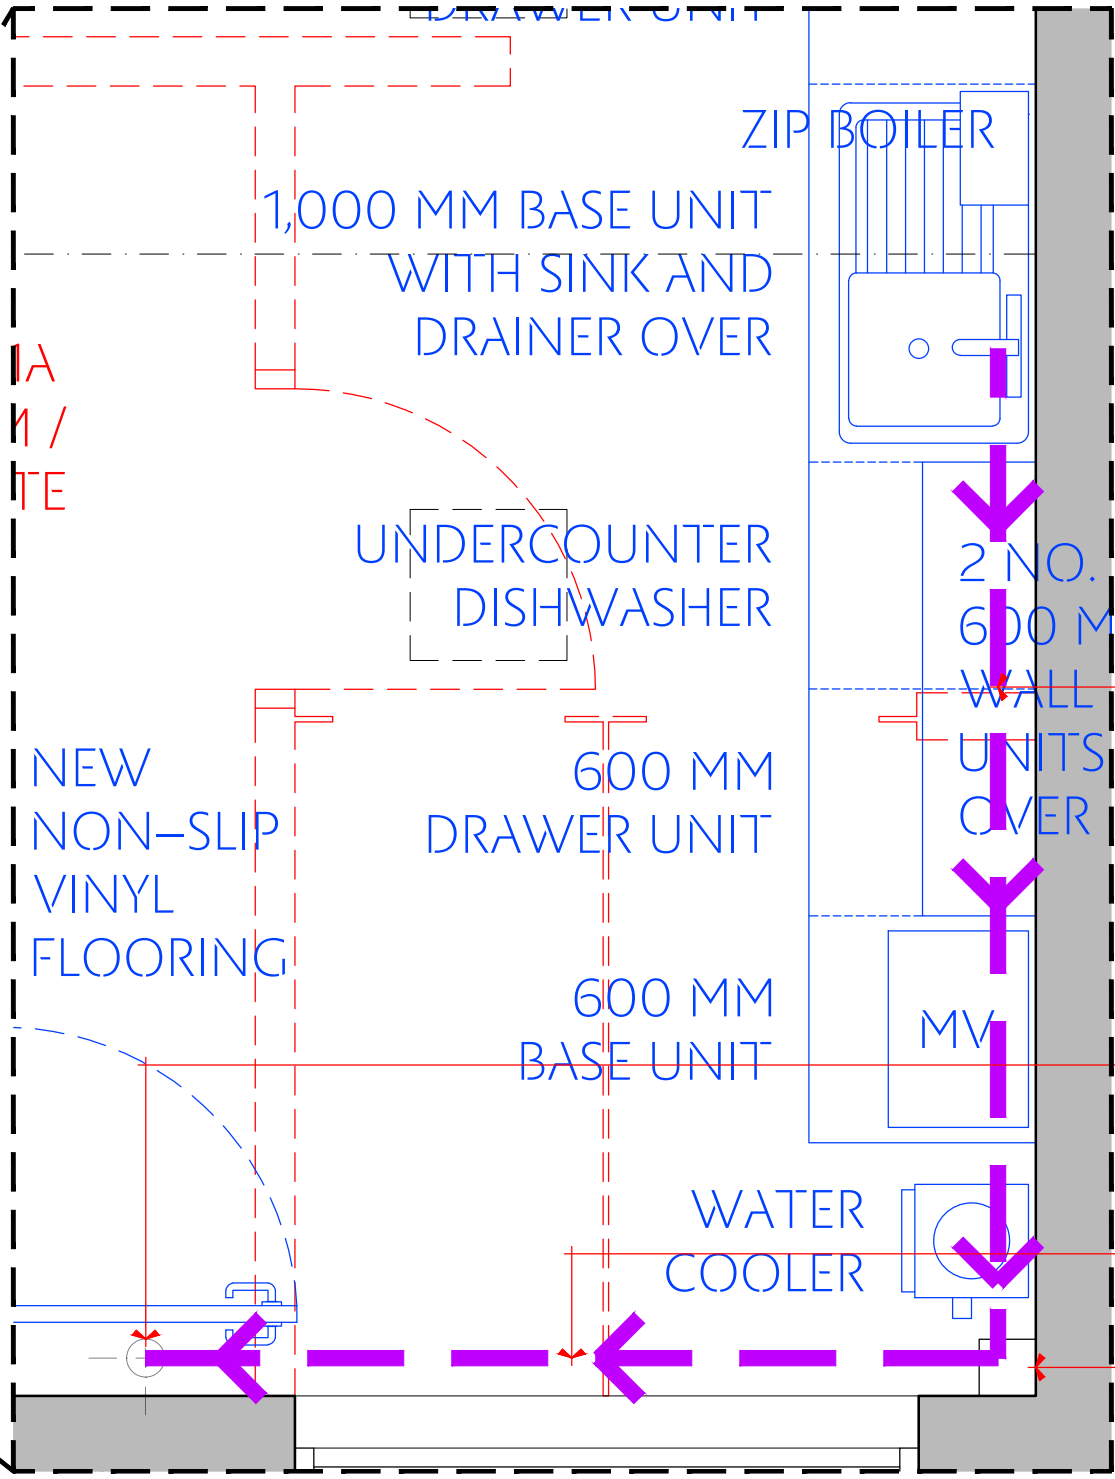

New Connection
New 40 mm waste pipe run for kitchen sink with trap and rodding eye.

Existing soil stack (approximate location). Minimum dimension of 100 mm shown from centre of soil pipe to adjacent walls. Contractor to ensure that there is adequate space to make the necessary connections.

New Connection
New 40 mm waste pipe run for kitchen sink with rodding eye.

Existing internal rainwater pipe.

Contract	Open Libraries Development	Location of Works No. 4: Waste Pipe Runs as Proposed			
Client	Manchester City Council	Contract No.	2141	Drawn	LMC
Building / Structure	Chorlton District Library, Chorlton-cum-Hardy	Date	Jul 2022	Revision	-
KEPCZYK PEARCE SANDERSON ARCHITECTS, SURVEYORS & HISTORIC BUILDING CONSULTANTS		Address	75 Wilmslow Road, Handforth, Cheshire SK9 3EN	Drawing No.	FR 025
		Tel:	01625 400103	Scale	Various @ A1