

NOTES:
All dimensions must be checked on site and not scaled from this drawing.

Ref.	Date	Revisions	By
P01	09.08.21	PRELIMINARY ISSUE	B.C.
C01	20.09.21	CONSTRUCTION ISSUE	C.P.
C02	19.11.21	EVC SUPPLIES ADDED	B.C.
C03	04.01.22	REVISED TO MS COMMENTS	B.C.

NOTES:

- ALL DIMENSIONS ARE IN MILLIMETRES UNLESS OTHERWISE STATED.
- DRAWING SYMBOLS ARE NOT TO SCALE.
- REFER TO THE DISTRIBUTION BOARD SCHEDULES FOR CIRCUIT DETAILS.
- FINAL POSITION OF ALL ACCESSORIES ARE TO BE CONFIRMED DURING THE COMMENTS PERIOD.
- FOR TYPICAL MOUNTING HEIGHTS, REFER TO DRAWING No. IW4-AME-XX-XX-DR-E-62-0006
- REFER TO THE FOLLOWING RISER LAYOUTS FOR SMALL POWER & DATA REQUIREMENTS:
 - IW4-AME-00-ZZ-DR-E-61-0007 - TELECOMS RISER LAYOUT - T2
 - IW4-AME-00-ZZ-DR-E-61-0008 - ELEC RISER LAYOUT - E4 & E8
 - IW4-AME-00-ZZ-DR-E-61-0009 - ESSENTIAL RISER LAYOUT - E5
- CLEANERS SOCKETS TO BE KEYSWITCH OPERATED ADJACENT DB WITHIN RISER.


SMALL POWER & DATA LEGEND:

- TWIN SWITCHED SOCKET (* DENOTES GANG No.)
- UNSWITCHED SOCKET OUTLET
- SINGLE SWITCHED CLEANERS SOCKET OUTLET
- SWITCHED FUSED SPUR
- UNSWITCHED FUSED SPUR
- DOUBLE POLE RED KEYSWITCH
- R45 DATA OUTLET (* DENOTES GANG No.)
- ISOLATOR
- AUTOMATIC CHANGE-OVER DEVICE
- FREEVIEW TV OUTLET
- CAT5 WIFI DATA OUTLET
- SINGLE COMPARTMENT DADO TRUNKING
- TWIN COMPARTMENT DADO TRUNKING
- TRI - COMPARTMENT DADO TRUNKING
- CIRCUIT LINE
- CIRCUIT REFERENCE

ABBREVIATION LEGEND

- AB - ACCESS BARRIER
- AD - AUTOMATIC DOOR
- AHU - AIR HANDLING UNIT
- AOV - AUTOMATIC OPENING VENT
- ASP - ASPRATING FIRE ALARM SYSTEM
- BMS - BUILDING MANAGEMENT SYSTEM
- CAT5 - CAT 5 BOOSTER SET
- CCP - CAR CHARGING POINT
- CWBS - COLD WATER BOOSTER SET
- C/O - AUTOMATIC CHANGE-OVER DEVICE
- CS - CLEANERS SOCKET
- DAC - ACCESS CONTROL
- DAP - DISABLED ALARM PANEL
- DB - DISTRIBUTION BOARD
- DCU - DUALCOM UNIT
- DW - DISH WASHER
- EF - EXTRACT FAN
- FAP - FIRE ALARM PANEL
- FARP - FIRE ALARM REPEATER PANEL
- FAN - FAN
- FCU - FAN COIL UNIT
- FF - FRIDGE/FREEZER
- GCP - GENERATOR CONTROL PANEL
- HD - HAND DRYER
- HDC - HEAT DETECTION CABLING
- HL - HIGH LEVEL
- HO - HYPEROPTIC
- HRU - HEAT RECOVERY UNIT
- IAP - INTRUDER ALARM PANEL
- INT - INTERCOM PANEL
- LDS - LEAK DETECTION SYSTEM
- LKR - ELECTRONIC LOCKER
- MSD - MOTORISED FIRE DAMPER
- PDV - PRIORITY DEMAND VALVE
- PH - PANEL HEATER
- ODH - OVER DOOR HEATER
- RC - RED CARE
- Re - RADIO RECEIVER
- RH - RADIANT PANEL HEATER
- WH - WATER HEATER
- SDP - SMOKE DAMPER PANEL
- SPN - SINGLE PHASE & NEUTRA
- TB - TUBULAR HEATER
- TH - TRENCH HEATER
- TPN - THREE PHASE & NEUTRAL
- TRA - TRACE HEATING
- WG - WATER GUARD
- ZE - INTRUDER ALARM ZONE EXPANDER

1 Level 00 - SP&D Layout
1 : 100

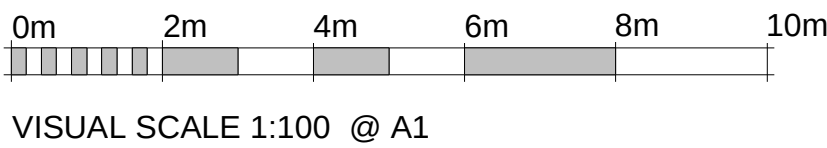

VISUAL SCALE 1:100 @ A1

ameon
Building Services Engineering
Unit 9-10 Olympic Court, Boardmans Way,
Whitehills Business Park, Blackpool, FY4 5GU
Tel: 01253 760160
E-mail: info@ameon.co.uk

Client	Job Title	Drawing Title	Date	Drawn by	Check by
MORGAN SINDALL	Islington Wharf, Phase 4	Ground Floor Small Power & Data Layout	August 2021	B.C.	B.C.
			Scale @ A1 As indicated	Status S4	Revision C03
			Drawing Number IW4-AME-00-GF-DR-E-62-0001		