


NOTICE

THIS DRAWING INCLUDING THE PRINCIPLES OF DESIGN, REMAINS THE PROPERTY OF HAYVERN ELECTRICAL LTD. AND IS ISSUED ON THE UNDERSTANDING THAT IT IS NOT REPRODUCED OR LOANED IN PART OR WHOLE EXCEPT WITH THE OWNERS WRITTEN CONSENT. IT IS NOT TO BE USED IN ANY MANNER THAT MAY BE DETRIMENTAL TO HAYVERN ELECTRICAL LTD. ACCEPTANCE OF THIS DRAWING WILL BE CONSIDERED AS AN AGREEMENT OF THE ABOVE.

G R A P E S T R E E T

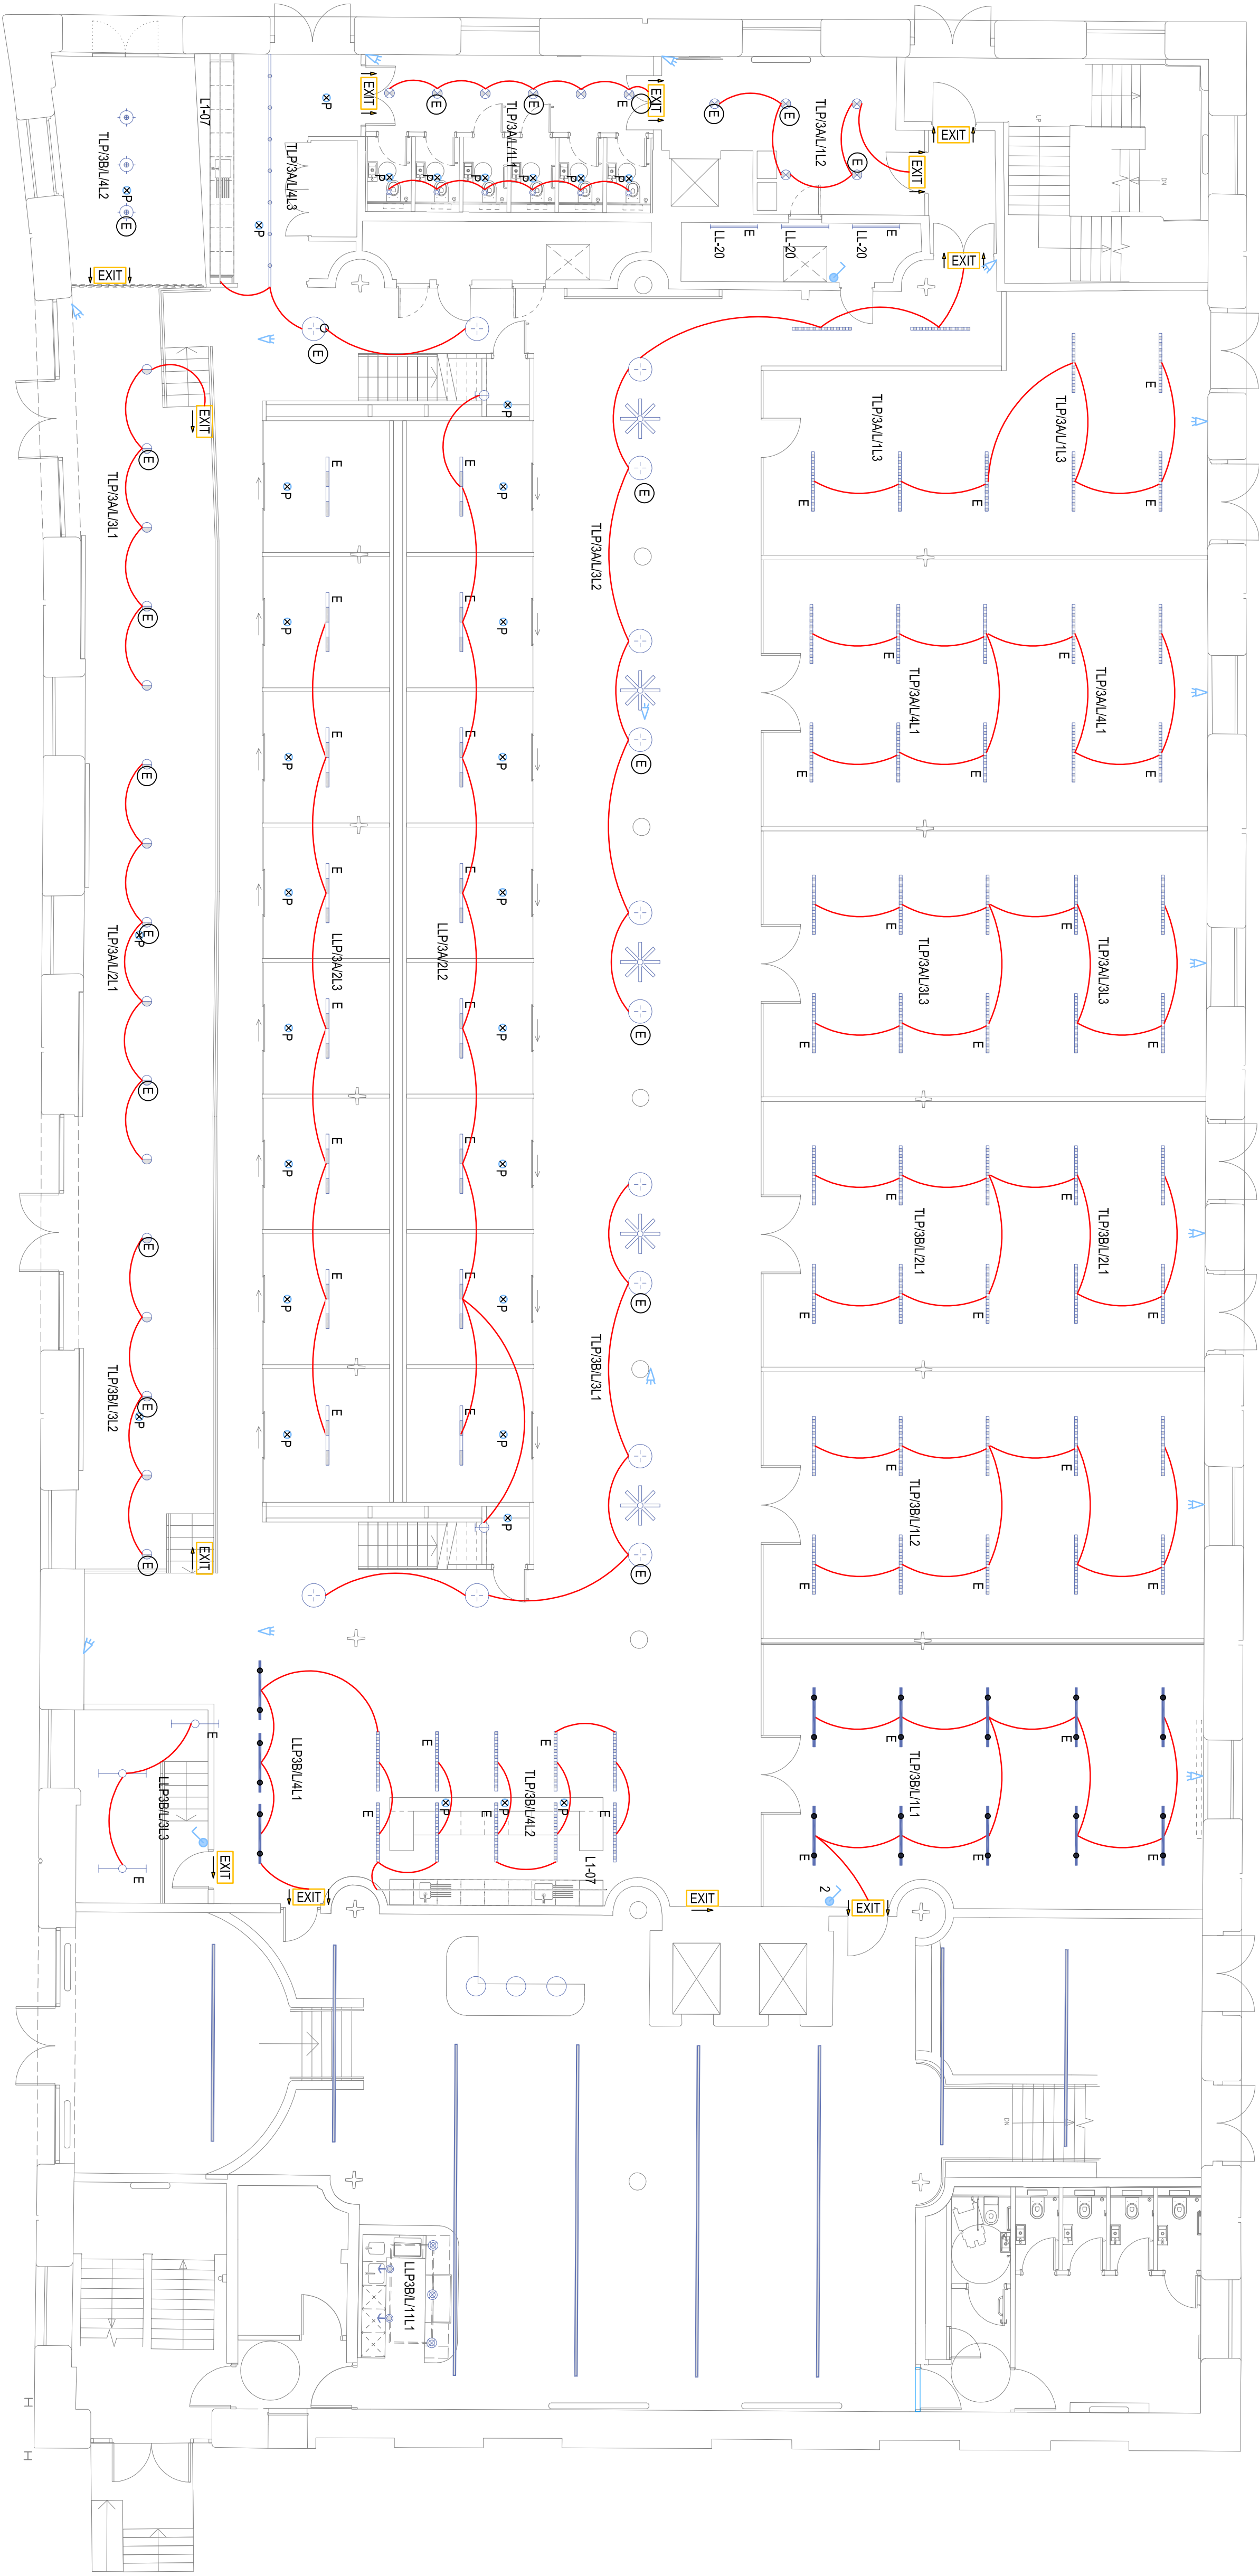

Drawing Key Refer to Lighting Schedule contained within DPL JIFE document issued by Julebo Osborne	
LIGHT FITTINGS	U-08 Industrial style pendant light 03 - WC lobby
E	U-09 Recessed downlight 01 - WC Corridor
U-10	U-10 Pendant light 04 - Meeting Room
U-11	U-11 Wall light 01 - Reception WC
U-12	U-12 Large pendant 05 - Work table and Club House
U-13	U-13 Large pendant 05 - Work table and Club House
U-14	U-14 Large light hanging vertically - Work table and Club House
U-15	U-15 Track lighting - Reception and Club House
U-16	U-16 Track lighting - Reception and Club House
U-17	U-17 Wall light 03 - CP Reception
U-18	U-18 Wall light 03 - CP Reception
U-20	U-20 Back of house suspended linear light
U-22	U-22 Table lamp - Club House
U-23	U-23 Globe pendant light - Club House
U-24	U-24 Wall light 05 - Club House
U-25	U-25 Suspended over-table light - Club House
U-26	U-26 Suspended 3 tube pendant light - CP Reception
U-27	U-27 Wall light - Work table and Reception
U-28	U-28 Floor lamp - Meeting Room 03
U-29	U-29 Bespoke neon ceiling light - CP Reception WC
U-30	U-30 LED light panel - CP Reception
U-31	U-31 Light Room Centre fixed LED 25W surface mounted fitting 50 / 100mm
U-32	U-32 REAR 7015 ASSEMBLY/PRESENCE
U-33	U-33 REAR 7015 ASSEMBLY/PRESENCE
U-34	U-34 REAR 7015 ASSEMBLY/PRESENCE
U-100	U-100 REAR 7015 ASSEMBLY/PRESENCE

AS FITTED DRAWING

Revisions	Description	Ref	Eng	Date
-----------	-------------	-----	-----	------



56 QUEEN STREET, FARNWORTH, BOLTON, 01204 579975

Client MANCHESTER QUAYS LTD

Project Title THE BONDED WAREHOUSE, PHASE 2

Drawing Title LEVEL 3 LIGHTING/EMERGENCY LIGHTING LAYOUT

In Association with

Drawn by	HR	Scales	1:100@A1
Checked by	JM		
Date	JUNE 19	(work to figured dimensions)	
DRG No.	1799-03-6301		Rev. A/F1