


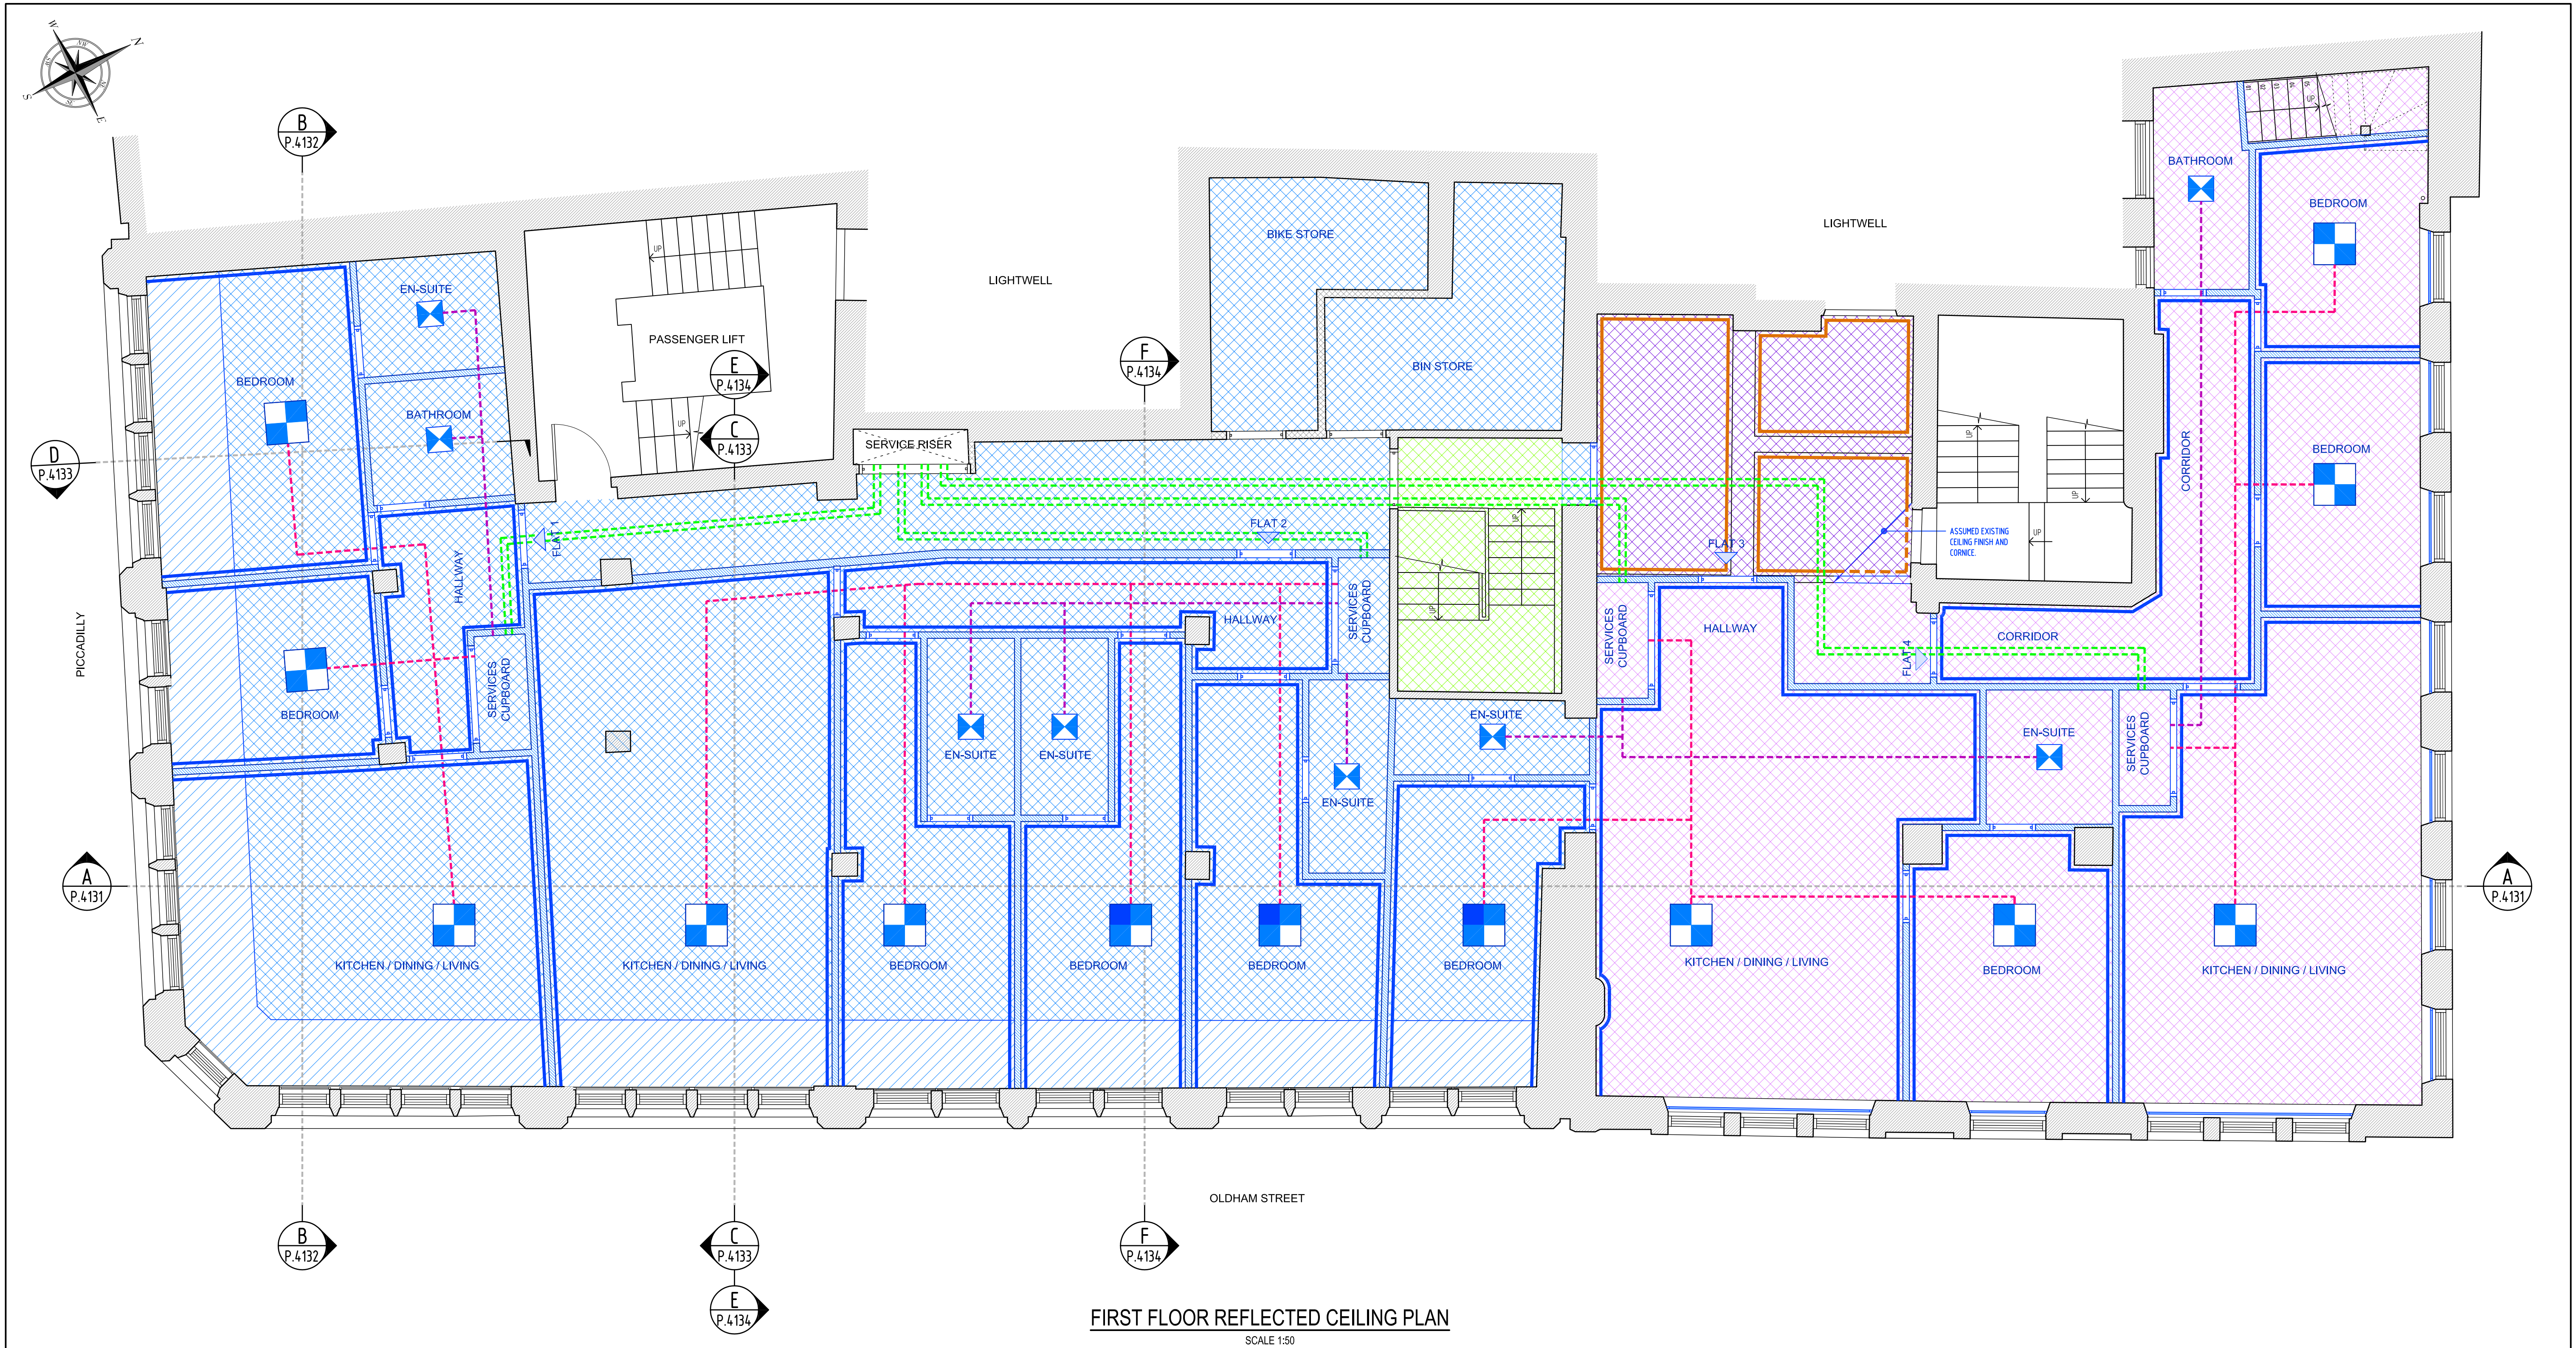

- NOTES**
1. GENERAL:
11. DO NOT SCALE FROM THIS DRAWING. CHECK ALL DIMENSIONS AND CONDITIONS ON SITE.
12. ALL WORKS TO BE CARRIED OUT IN ACCORDANCE WITH CURRENT HEALTH & SAFETY (INCLUDING CDM) REGULATIONS. ALL WORKS TO COMPLY WITH CURRENT BRITISH STANDARDS, CODES OF PRACTICE, BUILDING REGULATIONS AND APPROPRIATE EUROPEAN STANDARDS.
13. ALL STRUCTURAL WORK IS TO BE CARRIED OUT IN ACCORDANCE WITH THE STRUCTURAL ENGINEER'S DETAILS AND CALCULATIONS.
14. PRECISE POSITIONS OF ALL FIXTURES AND FITTINGS IS SUBJECT TO CONFIRMATION ON SITE.
15. THIS DRAWING IS PRODUCED FOR PLANNING APPLICATION ONLY AND SHOULD NOT BE USED FOR ANY OTHER PURPOSES.
16. ALL INFORMATION SHOWN ON THIS EXISTING DRAWING IS BASED ON SURVEY DRAWING NUMBER EAST-20-01 PRODUCED BY 'EA LONDON SURVEY COMPANY'.


LEGEND:

	DENOTES ORIGINAL EXISTING WALL		DENOTES PROPOSED FIRE RESISTANT PLASTERBOARD CEILING FIXED TO EXISTING
	DENOTES NON-ORIGINAL EXISTING WALL		DENOTES PROPOSED RECESSED PLASTERBOARD CEILING FIXED TO EXISTING
	DENOTES PROPOSED WORKS		DENOTES EXISTING SUSPENDED CEILING (600x600 GRID SYSTEM)
	DENOTES EXPOSED MECHANICAL VENTILATION INCLUDING COOLING EXPOSED SUPPLY DUCT PIPE RUNS TO FLATS SHOWN INDICATIVELY.		DENOTES RECENTLY INSTALLED FIRE RESISTANT PLASTERBOARD CEILING
	DENOTES EXPOSED MECHANICAL VENTILATION EXPOSED EXTRACT DUCT PIPE RUNS TO FLATS SHOWN INDICATIVELY.		DENOTES EXISTING TIGHTLY-ATTACHED CEILING
	DENOTES COMBINED INTAKE AND EXHAUST DUCT TO EXISTING ROOF LEVEL PLANT.		DENOTES EXISTING CORNICE
			DENOTES PROPOSED CORNICE

NOTE: ALL CEILINGS AND WALLS HAVE BEEN DETERMINED BY NON-INTRUSIVE VISUAL INSPECTION.

WORK IN PROGRESS

 SCALE BAR
(1:50 @ A1)
(1:100 @ A3)



REV	DATE	DESCRIPTION	BY
1	11/01/2022	PLANNING	ISP DRAWING SOLUTIONS

JOB TITLE	YORKSHIRE BUILDING SOCIETY 17 PICCADILLY, MANCHESTER
DRG TITLE	SCHEME D - PROPOSED FIRST FLOOR REFLECTED CEILING PLAN

ISP Drawing Solutions	ISP DRAWING SOLUTIONS 21 MONKS CLOSE MIDDLESEX, HA4 9HX TEL: 0044 7886116912 EMAIL: info@ispdrawingsolutions.co.uk www.ispdrawingsolutions.co.uk
JOB NO	1192
DRG NO	P.4201
REV	/
SCALE	1:50 @ A1 1:100 @ A3
DATE	06/2022