
 


SITE LOCATION

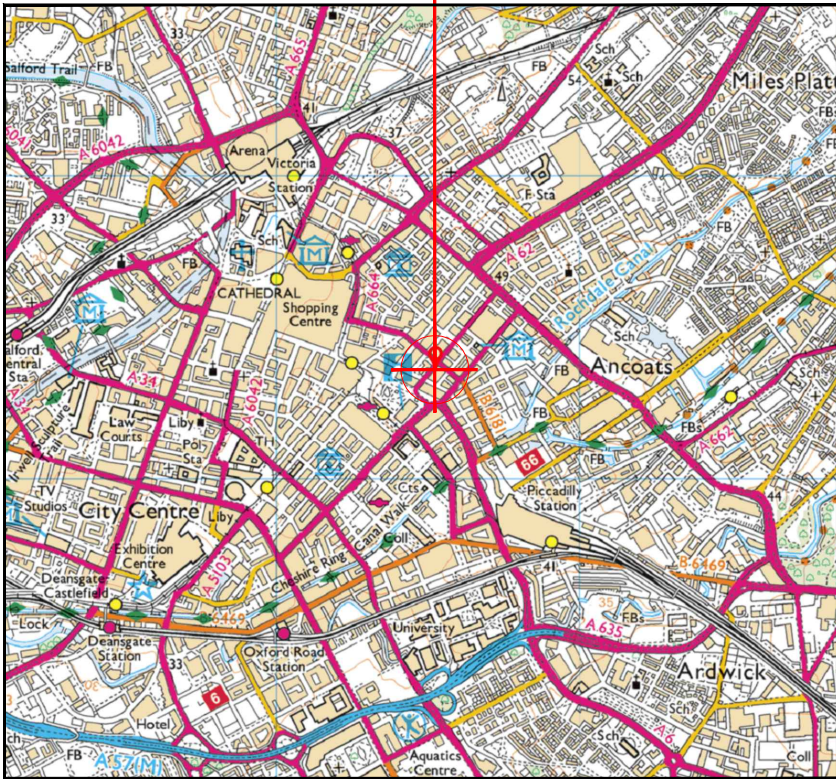


Reproduced by permission of Ordnance Survey on behalf of the Controller of Her Majesty's Stationery Office
All rights reserved. © Crown Copyright. Licence number 100022432

SITE AREA PLAN




SITE PHOTOGRAPH

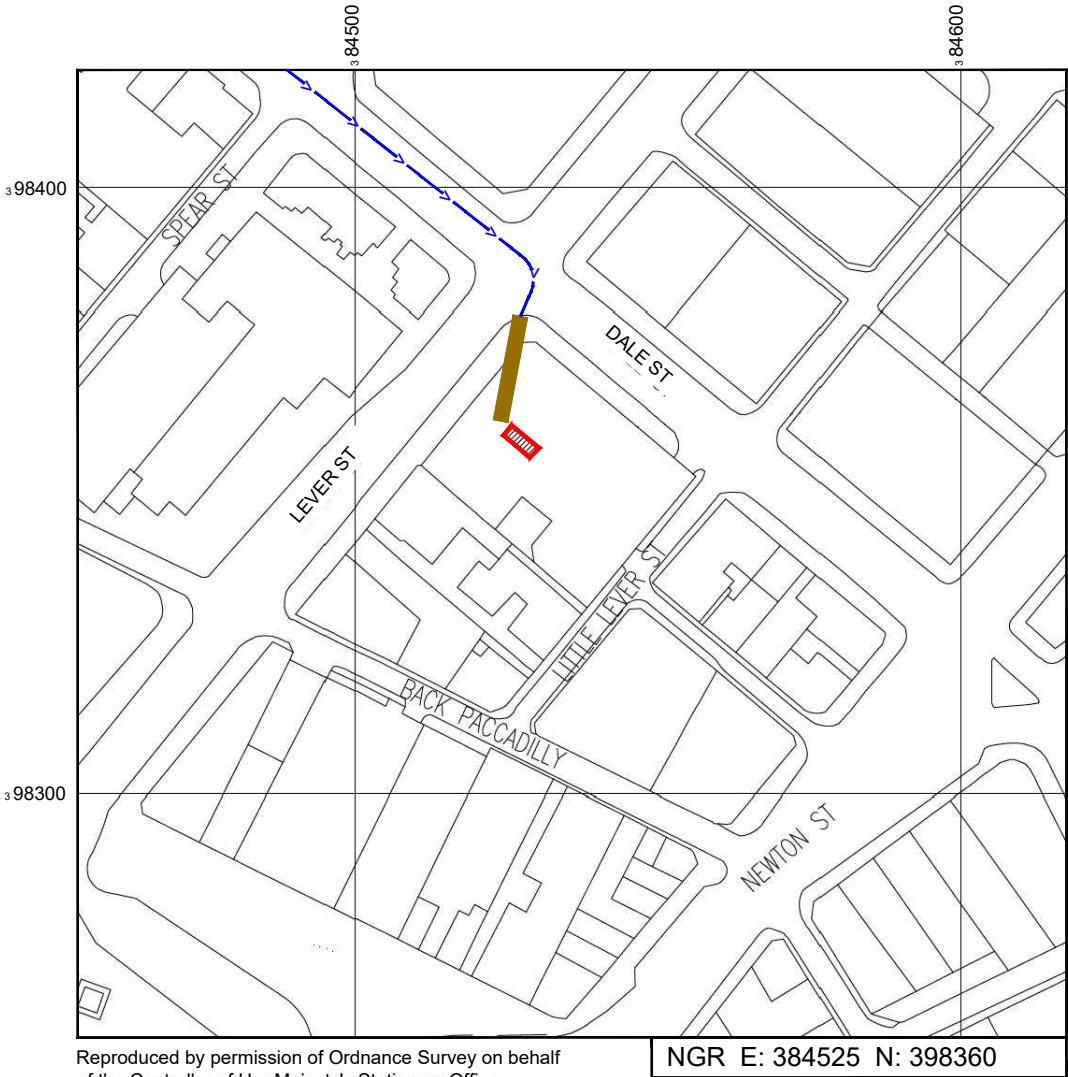

Reproduced by permission of Ordnance Survey on behalf of the Controller of Her Majesty's Stationery Office
All rights reserved. © Crown Copyright. Licence number 100022432

NGR E: 384525 N: 398360

 SITE LOCATION PLAN



GOOGLE MAPS QR CODE

GOOGLE MAPS - <https://goo.gl/maps/aeYLhEFG8LiaZq5N7>
GOOGLE STREET VIEW - <https://goo.gl/maps/w86PE3TBuNJDGMUM6>

NOTES:

1. ALL DIMENSIONS IN MM UNLESS OTHERWISE NOTED.

DIRECTIONS TO SITE:

A57 Mancunian Way turn onto A665 after approx 1 mile turn left Tib St and 3rd left onto Dale St. Site on right at junction with Lever St.

Demise:



Access Route To Site:



Access Route:



Master:	MBNL / EE / H3G:	Project:	Purpose of Issue:	Issue:
M006	MBNL	Vendor Swap	Detailed Design	B4
Date:	01.07.22	Revision / Upgrade Description:		
Drawn:	T. Dociu	Minor amend		
Checked:	S. Dafinoliu			
Approved:	F. Carminho			
Master:	MBNL / EE / H3G:	Project:	Purpose of Issue:	Issue:
M005	MBNL	Vendor Swap	Detailed Design	B3
Date:	23.06.22	Revision / Upgrade Description:		
Drawn:	T. Dociu	Keep existing antennas		
Checked:	S. Dafinoliu			
Approved:	F. Carminho			
Master:	MBNL / EE / H3G:	Project:	Purpose of Issue:	Issue:
M003	MBNL	Vendor Swap	Detailed Design	B1
Date:	05.12.21	Revision / Upgrade Description:		
Drawn:	T. Dociu	First Issue		
Checked:	S. Dafinoliu			
Approved:	F. Carminho			
Master:	MBNL / EE / H3G:	Project:	Purpose of Issue:	Issue:
M002	MBNL	Vendor Swap	Planning	B
Date:	19.11.21	Revision / Upgrade Description:		
Drawn:	T. Dociu	Minor amend		
Checked:	S. Dafinoliu			
Approved:	F. Carminho			
Master:	MBNL / EE / H3G:	Project:	Purpose of Issue:	Issue:
M001	MBNL	Vendor Swap	Planning	A
Date:	17.11.21	Revision / Upgrade Description:		
Drawn:	T. Dociu	First Issue		
Checked:	S. Dafinoliu			
Approved:	F. Carminho			



Hatfield Business Park
Hatfield
Hertfordshire
AL10 9BW

Tel: 01707 315000
Fax: 01707 319001



ERICSSON



Telelink Infra Services
Address: Station Road,
Woolhampton, Reading,
RG7 5SE, UK
email: office-uk@telelink.com

Site Name:	20 DALE STREET		
Site ID:	920100		
Address:	20 DALE STREET, GREATER MANCHESTER, MANCHESTER, M1 1EZ		
Title:	002 SITE LOCATION PLAN		
Project:	VENDOR SWAP		
Purpose of Issue:	DETAILED DESIGN		
EE Cell ID:	MBNL Cell ID:	3UK Cell ID:	
56016	MAN041	M0297	
Master Drawing No:		Issue:	
920100_MAN041_56016_M0297_M006		B4	



Ground level
+0.0m AGL

Roof level
+21.0m AGL

Ridge level
+23.55m AGL

DALE ST

LEVER ST

ACCESS PLAN



Asset Reference	Asset Description:	Asset Status:	Access Description:	Asset Reference	Asset Description:	Asset Status:	Access Description:
EA1	Antenna	Remain	Rooftop Worker Access	CAB1-2	Cabinet	Proposed	Unrestricted Access
EB1	Antenna	Remain	Rooftop Worker Access	CAB3	BTS 3900L Cabinet	Remove	Unrestricted Access
EC1	Antenna	Remain	Rooftop Worker Access	CAB4-7	Cabinet	Installed	Unrestricted Access
GPS1	GPS	Proposed	Rooftop Worker Access	RRU1-3	Cabinet	Installed	Unrestricted Access
				ERS1-3	ERS	Proposed	Unrestricted Access
				ERS4-6	ERS	Proposed	Unrestricted Access

NOTES:

1. ALL DIMENSIONS IN MM UNLESS OTHERWISE NOTED.

DEFINED ACCESS ROUTE DESCRIPTION FROM SITE ENTRANCE TO THE EQUIPMENT:

Master:	MBNL / EE / H3G:	Project:	Purpose of Issue:	Issue:
M006	MBNL	Vendor Swap	Detailed Design	B4
Date:	01.07.22	Revision / Upgrade Description:		
Drawn:	T. Dociu	Minor amend		
Checked:	S. Dafinoiu			
Approved:	F. Carminho			
Master:	MBNL / EE / H3G:	Project:	Purpose of Issue:	Issue:
M005	MBNL	Vendor Swap	Detailed Design	B3
Date:	23.06.22	Revision / Upgrade Description:		
Drawn:	T. Dociu	Keep existing antennas		
Checked:	S. Dafinoiu			
Approved:	F. Carminho			
Master:	MBNL / EE / H3G:	Project:	Purpose of Issue:	Issue:
M003	MBNL	Vendor Swap	Detailed Design	B1
Date:	05.12.21	Revision / Upgrade Description:		
Drawn:	T. Dociu	First Issue		
Checked:	S. Dafinoiu			
Approved:	F. Carminho			
Master:	MBNL / EE / H3G:	Project:	Purpose of Issue:	Issue:
M002	MBNL	Vendor Swap	Planning	B
Date:	19.11.21	Revision / Upgrade Description:		
Drawn:	T. Dociu	Minor amend		
Checked:	S. Dafinoiu			
Approved:	F. Carminho			
Master:	MBNL / EE / H3G:	Project:	Purpose of Issue:	Issue:
M001	MBNL	Vendor Swap	Planning	A
Date:	17.11.21	Revision / Upgrade Description:		
Drawn:	T. Dociu	First Issue		
Checked:	S. Dafinoiu			
Approved:	F. Carminho			



Hatfield Business Park
Hatfield
Hertfordshire
AL10 9BW

Tel: 01707 315000
Fax: 01707 319001




ERICSSON



Telelink Infra Services
Address: Station Road,
Woolhampton, Reading,
RG7 5SE, UK
email: office-uk@telelink.com

Site Name:	20 DALE STREET		
Site ID:	920100		
Address:	20 DALE STREET, GREATER MANCHESTER, MANCHESTER, M1 1EZ		
Title:	003 ACCESS PLAN		
Project:	VENDOR SWAP		
Purpose of Issue:	DETAILED DESIGN		
EE Cell ID:	56016	MBNL Cell ID:	MAN041
3UK Cell ID:	M0297		
Master Drawing No:	920100_MAN041_56016_M0297_M006		Issue:
			B4

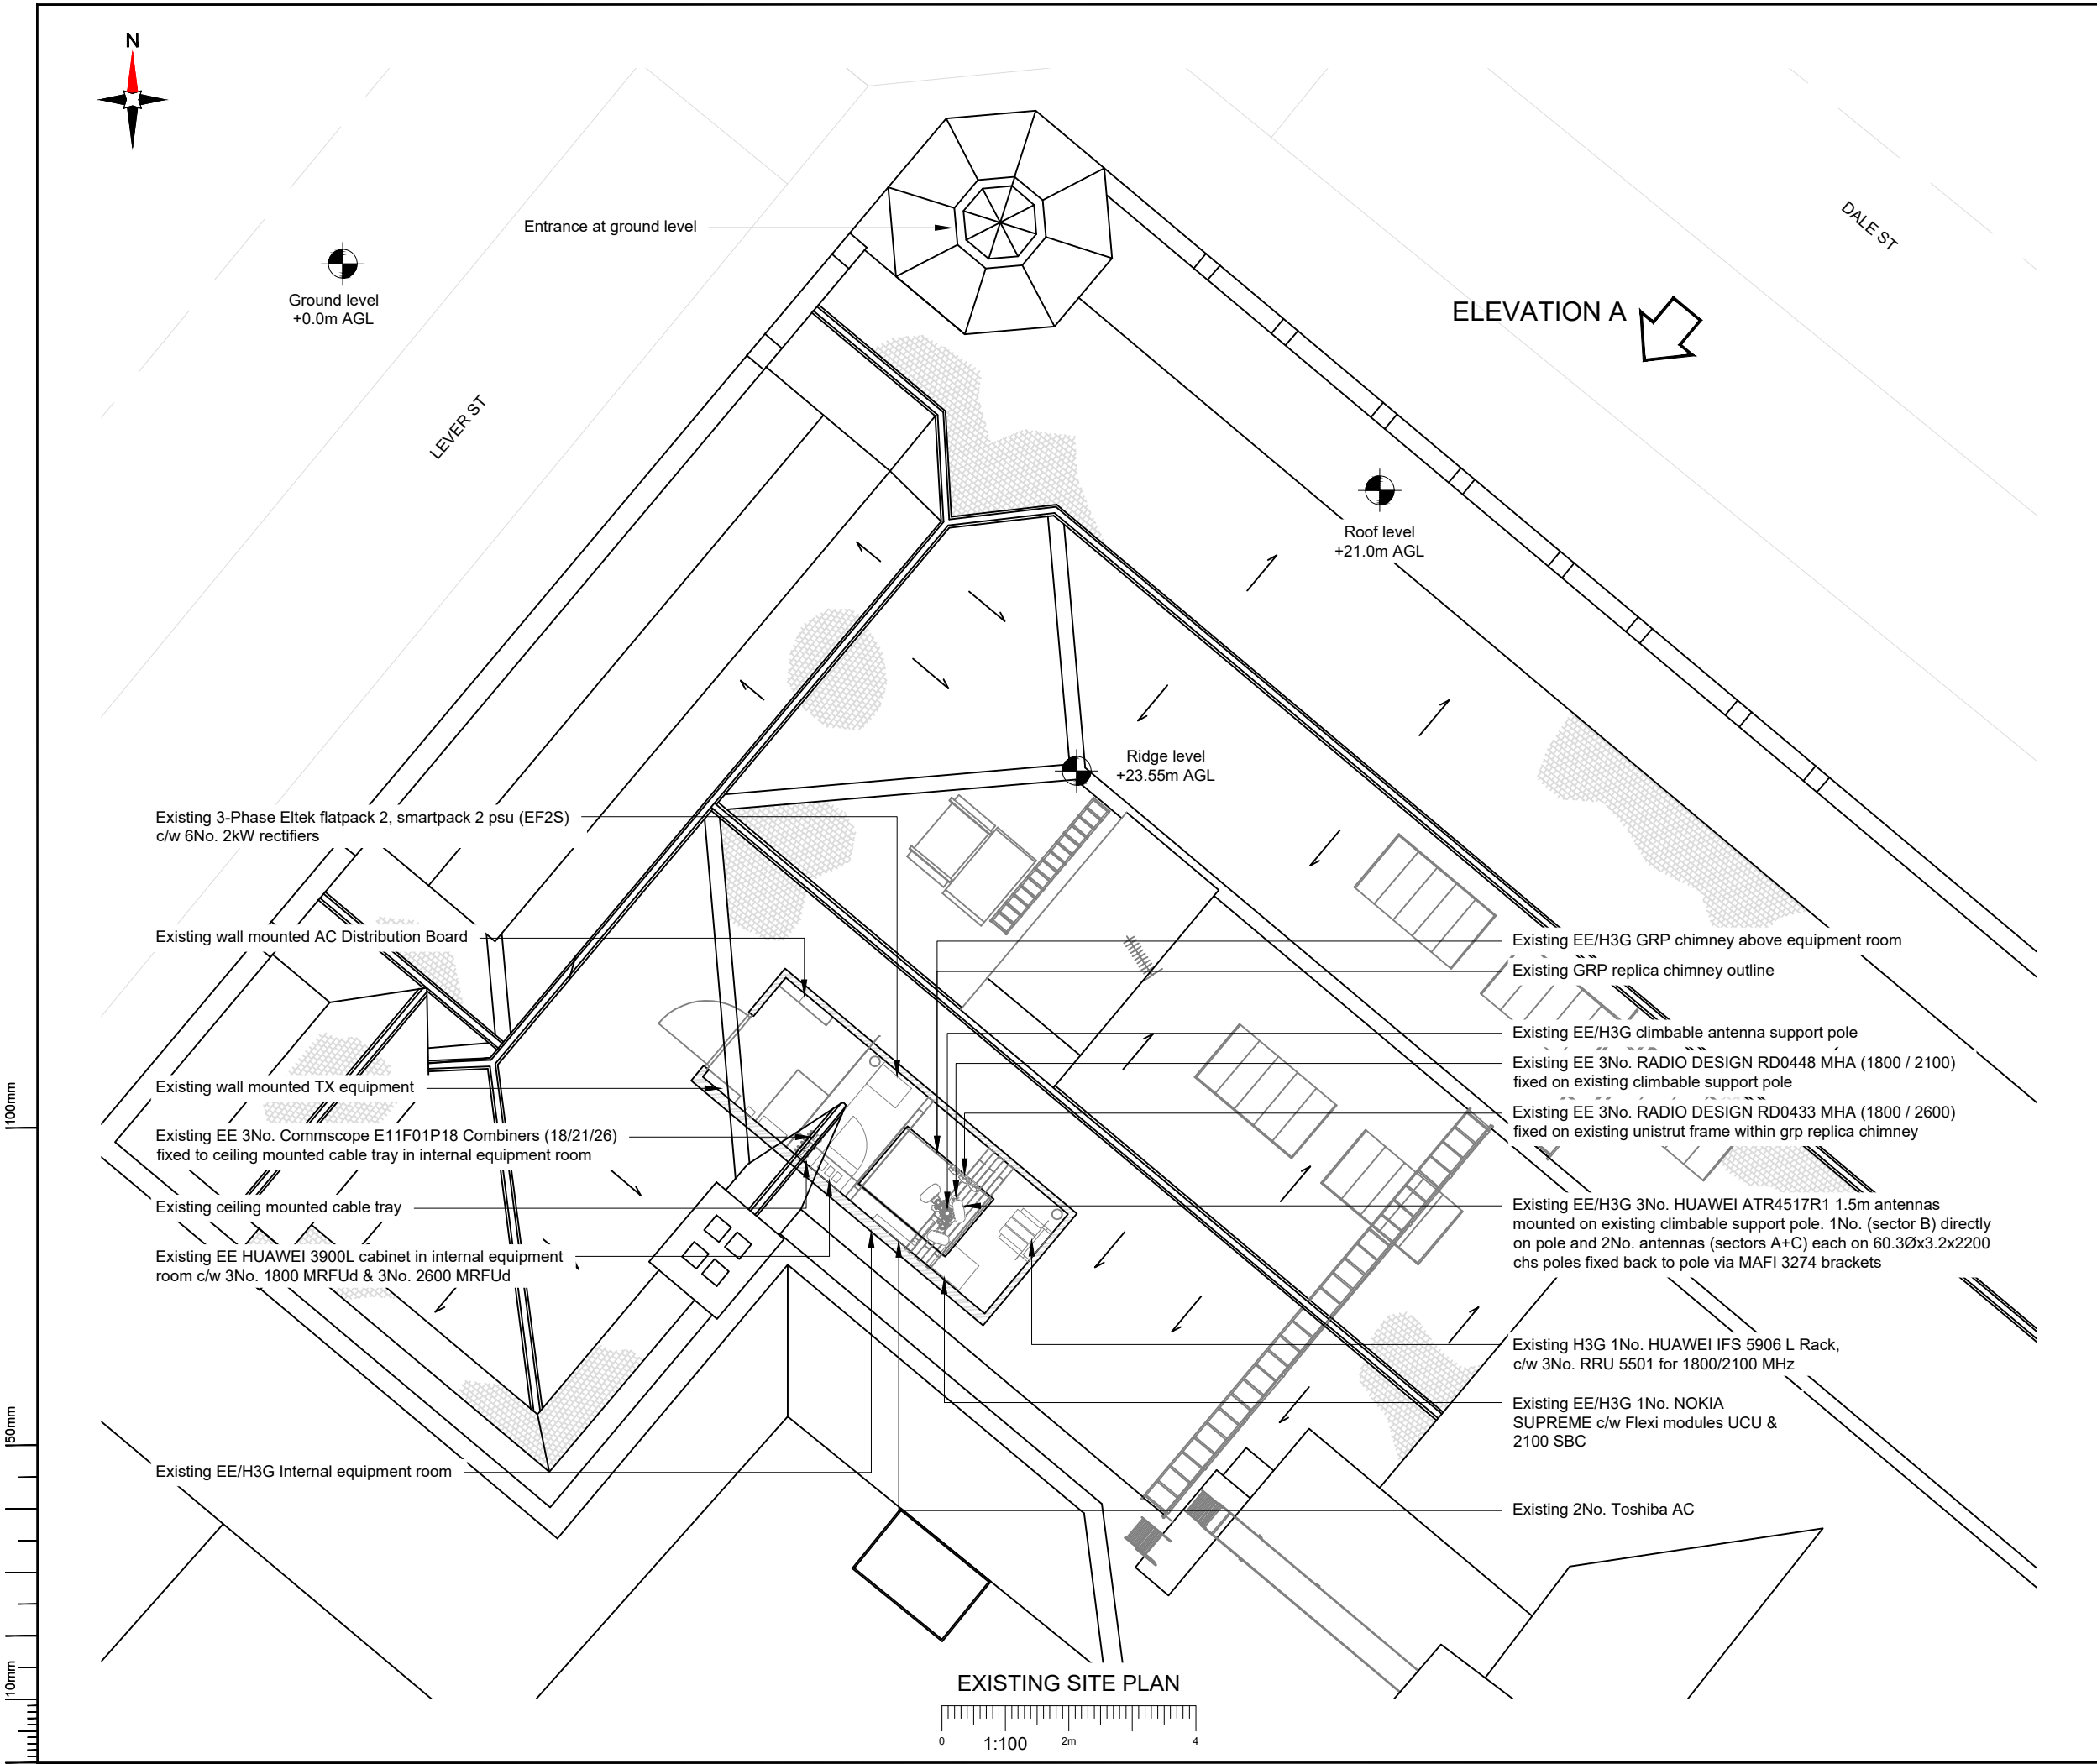

- NOTES:
- ALL DIMENSIONS IN MM UNLESS OTHERWISE NOTED.

Master:	MBNL / EE / H3G:	Project:	Purpose of Issue:	Issue:
M006	MBNL	Vendor Swap	Detailed Design	B4
Date:	01.07.22	Revision / Upgrade Description:		
Drawn:	T. Dociu	Minor amend		
Checked:	S. Dafinoiu			
Approved:	F. Carminho			
Master:	MBNL / EE / H3G:	Project:	Purpose of Issue:	Issue:
M005	MBNL	Vendor Swap	Detailed Design	B3
Date:	23.06.22	Revision / Upgrade Description:		
Drawn:	T. Dociu	Keep existing antennas		
Checked:	S. Dafinoiu			
Approved:	F. Carminho			
Master:	MBNL / EE / H3G:	Project:	Purpose of Issue:	Issue:
M003	MBNL	Vendor Swap	Detailed Design	B1
Date:	05.12.21	Revision / Upgrade Description:		
Drawn:	T. Dociu	First Issue		
Checked:	S. Dafinoiu			
Approved:	F. Carminho			
Master:	MBNL / EE / H3G:	Project:	Purpose of Issue:	Issue:
M002	MBNL	Vendor Swap	Planning	B
Date:	19.11.21	Revision / Upgrade Description:		
Drawn:	T. Dociu	Minor amend		
Checked:	S. Dafinoiu			
Approved:	F. Carminho			
Master:	MBNL / EE / H3G:	Project:	Purpose of Issue:	Issue:
M001	MBNL	Vendor Swap	Planning	A
Date:	17.11.21	Revision / Upgrade Description:		
Drawn:	T. Dociu	First Issue		
Checked:	S. Dafinoiu			
Approved:	F. Carminho			



Hatfield Business Park
Hatfield
Hertfordshire
AL10 9BW

Tel: 01707 315000
Fax: 01707 319001



ERICSSON



Telelink Infra Services
Address: Station Road,
Woolhampton, Reading,
RG7 5SE, UK
email: office-uk@telelink.com

Site Name: 20 DALE STREET

Site ID: 920100

Address: 20 DALE STREET,
GREATER MANCHESTER,
MANCHESTER,
M1 1EZ


Title: 100 EXISTING SITE PLAN

Project: VENDOR SWAP

Purpose of Issue: DETAILED DESIGN

EE Cell ID:	MBNL Cell ID:	3UK Cell ID:
56016	MAN041	M0297

Master Drawing No:	Issue:
920100_MAN041_56016_M0297_M006	B4

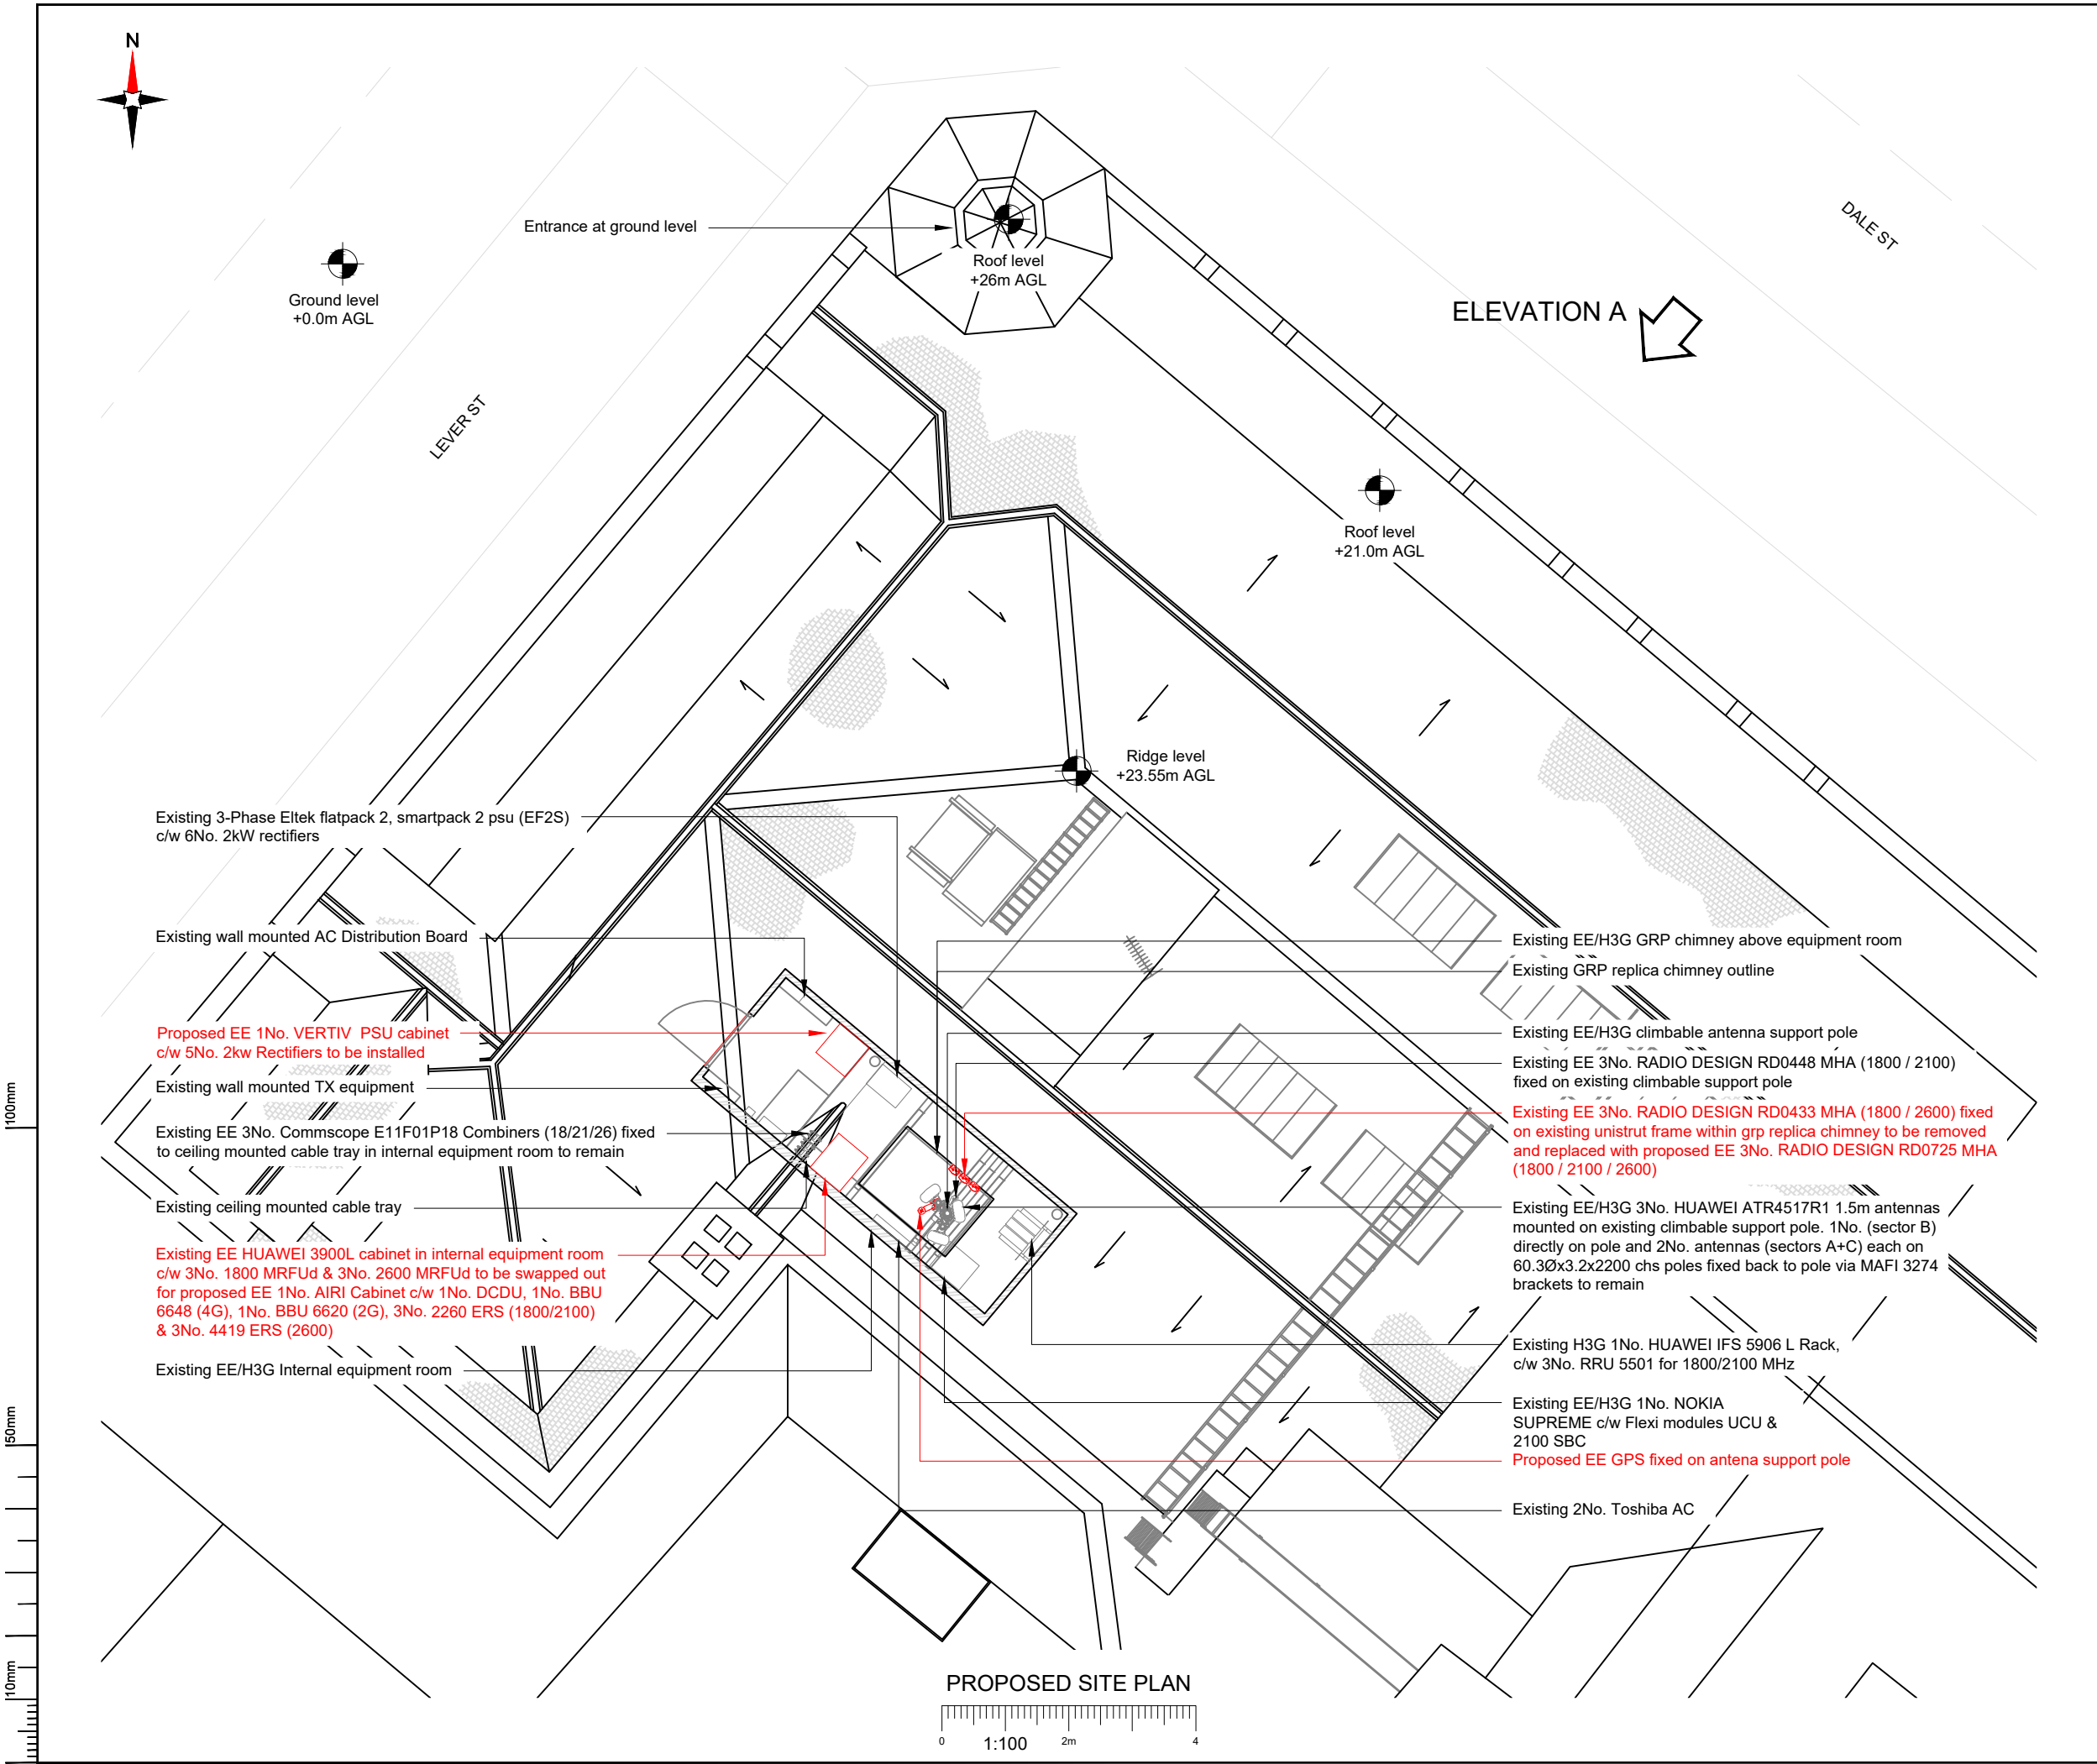

NOTES:


1. ALL DIMENSIONS IN MM UNLESS OTHERWISE NOTED.

Note:


Proposed cabinets to be bonded to the existing LP system.

All existing fibre / feeder cables to be re-used. Subject to testing. Un-used feeder cables to remain and be capped

Master:	MBNL / EE / H3G:	Project:	Purpose of Issue:	Issue:
M006	MBNL	Vendor Swap	Detailed Design	B4
Date:	01.07.22	Revision / Upgrade Description:		
Drawn:	T. Dociu	Minor amend		
Checked:	S. Dafinoiu			
Approved:	F. Carminho			
Master:	MBNL / EE / H3G:	Project:	Purpose of Issue:	Issue:
M005	MBNL	Vendor Swap	Detailed Design	B3
Date:	23.06.22	Revision / Upgrade Description:		
Drawn:	T. Dociu	Keep existing antennas		
Checked:	S. Dafinoiu			
Approved:	F. Carminho			
Master:	MBNL / EE / H3G:	Project:	Purpose of Issue:	Issue:
M003	MBNL	Vendor Swap	Detailed Design	B1
Date:	05.12.21	Revision / Upgrade Description:		
Drawn:	T. Dociu	First Issue		
Checked:	S. Dafinoiu			
Approved:	F. Carminho			
Master:	MBNL / EE / H3G:	Project:	Purpose of Issue:	Issue:
M002	MBNL	Vendor Swap	Planning	B
Date:	19.11.21	Revision / Upgrade Description:		
Drawn:	T. Dociu	Minor amend		
Checked:	S. Dafinoiu			
Approved:	F. Carminho			
Master:	MBNL / EE / H3G:	Project:	Purpose of Issue:	Issue:
M001	MBNL	Vendor Swap	Planning	A
Date:	17.11.21	Revision / Upgrade Description:		
Drawn:	T. Dociu	First Issue		
Checked:	S. Dafinoiu			
Approved:	F. Carminho			
 Hatfield Business Park Hatfield Hertfordshire AL10 9BW Tel: 01707 315000 Fax: 01707 319001  Ericsson Telelink Infra Services Address: Station Road, Woolhampton, Reading, RG7 5SE, UK email: office-uk@telelink.com				
Site Name:		20 DALE STREET		
Site ID:		920100		
Address:		20 DALE STREET, GREATER MANCHESTER, MANCHESTER, M1 1EZ		
Title:		150 PROPOSED SITE PLAN		
Project:		VENDOR SWAP		
Purpose of Issue:		DETAILED DESIGN		
EE Cell ID:	MBNL Cell ID:	3UK Cell ID:		
56016	MAN041	M0297		
Master Drawing No:				Issue:
920100_MAN041_56016_M0297_M006				B4

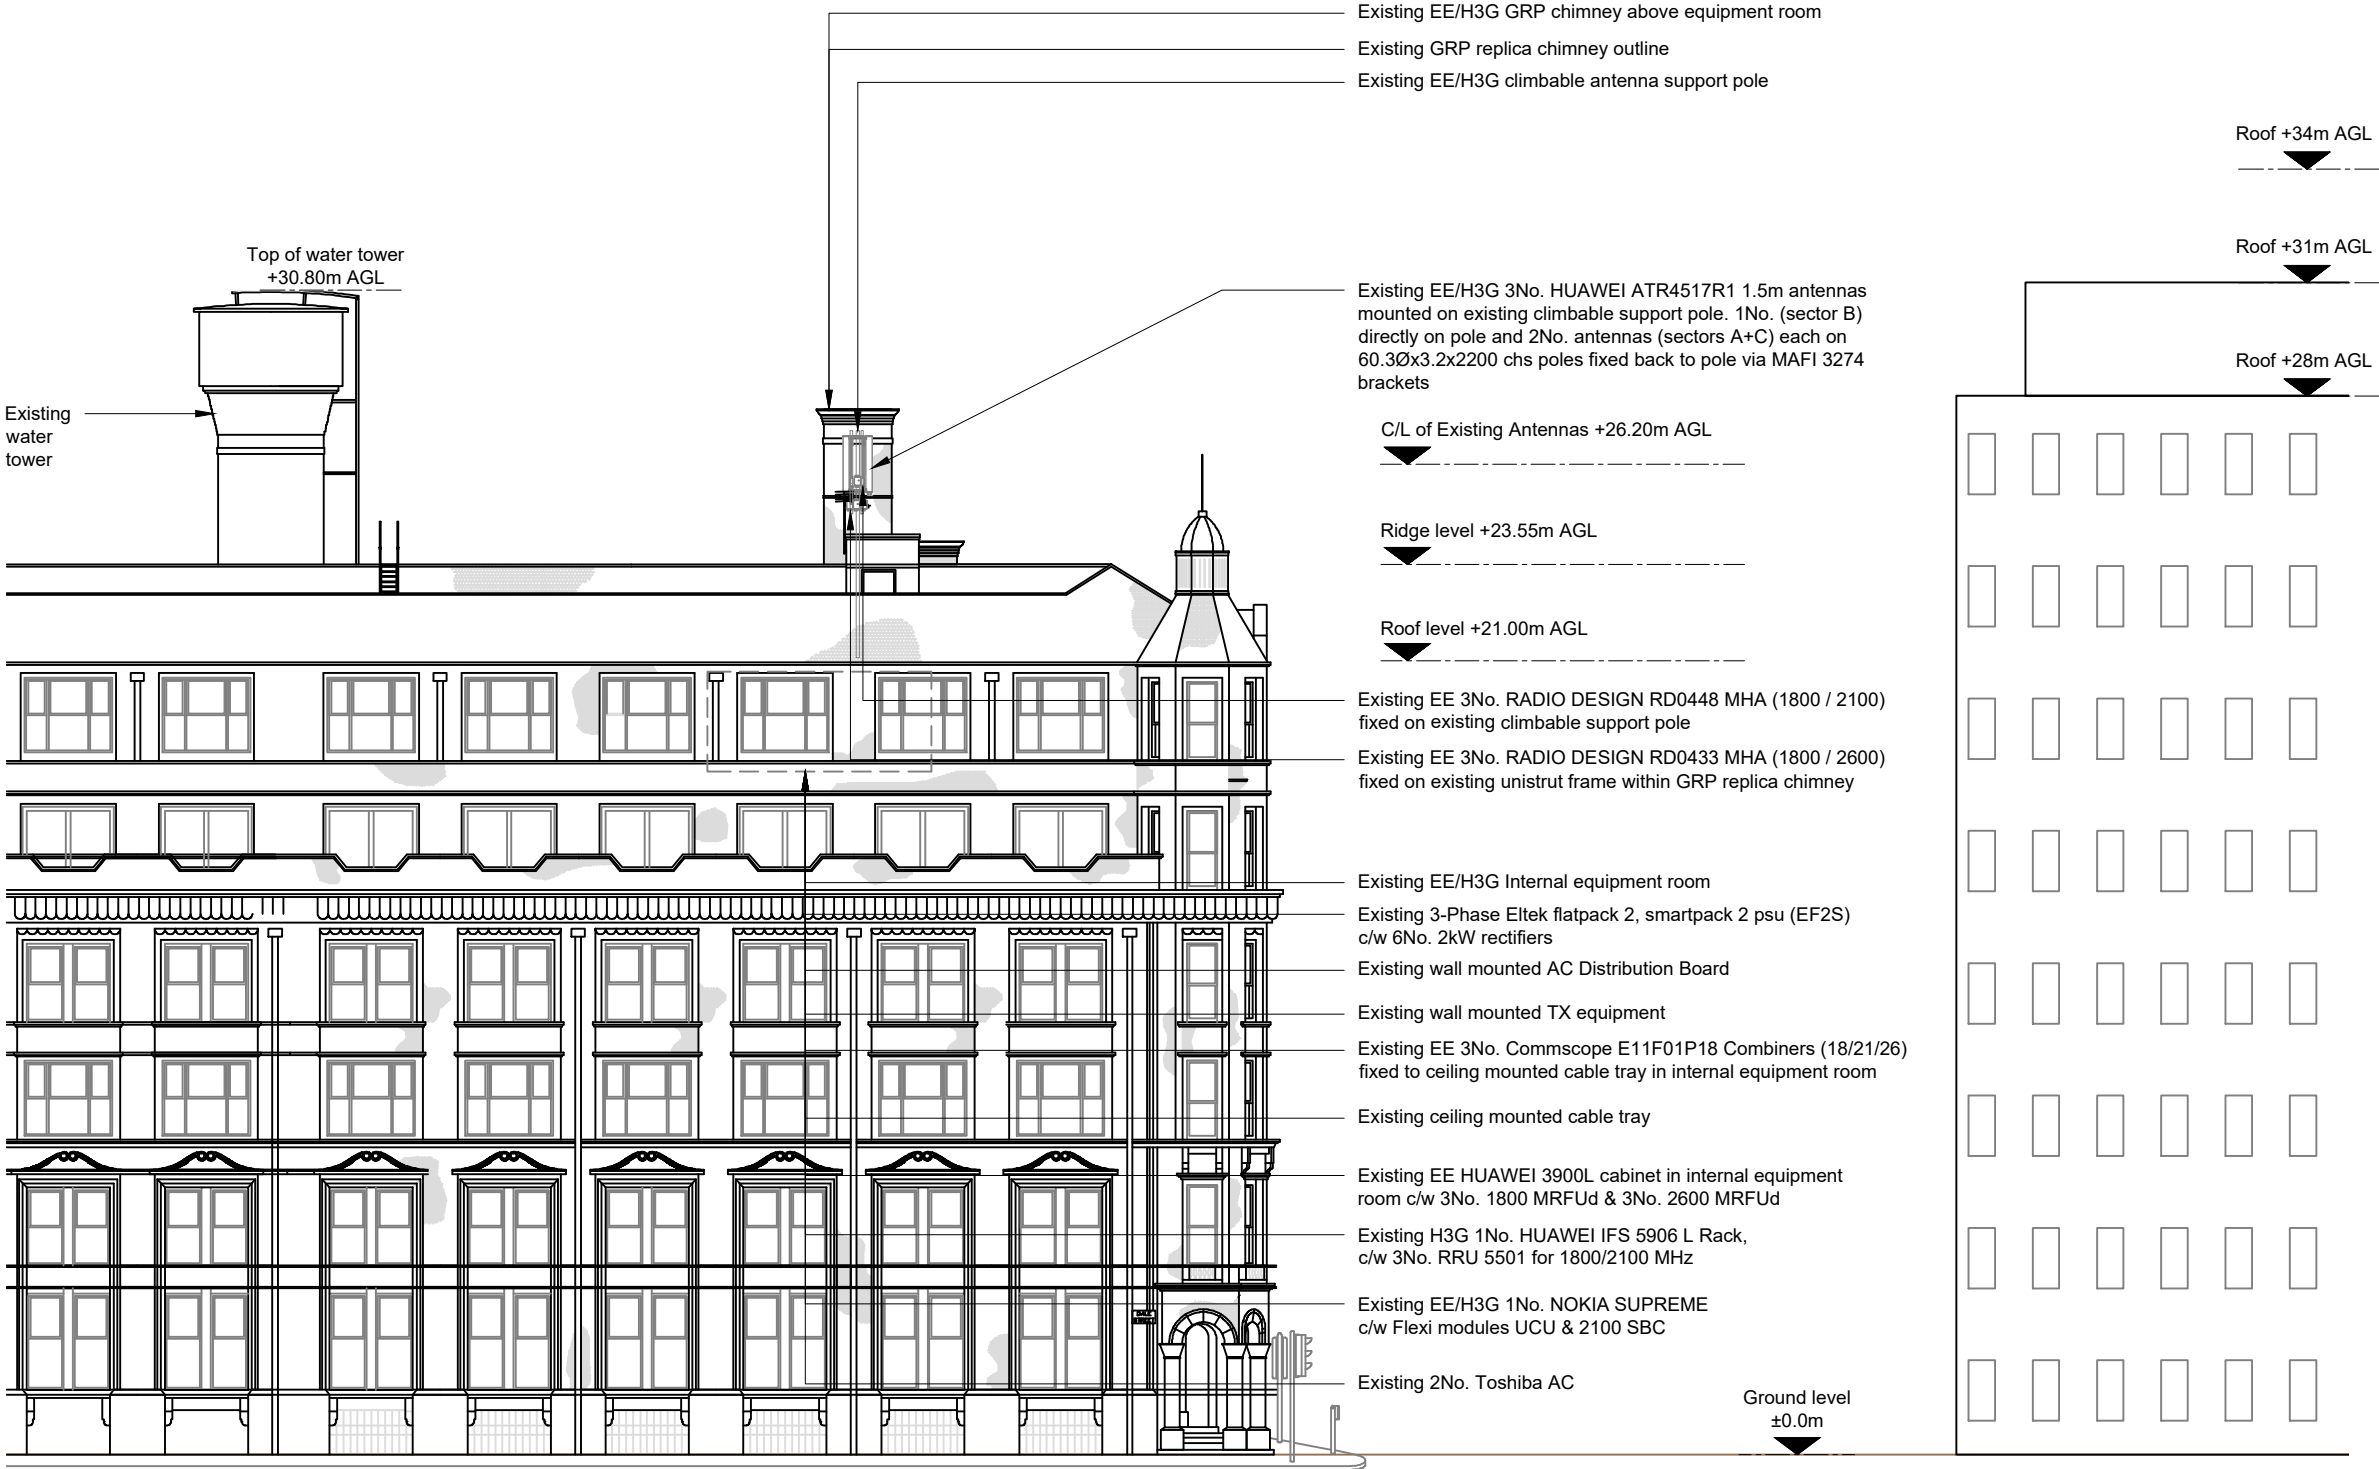

EXISTING SITE ELEVATION A

 

- NOTES:
- ALL DIMENSIONS IN MM UNLESS OTHERWISE NOTED.

Master:	MBNL / EE / H3G:	Project:	Purpose of Issue:	Issue:
M006	MBNL	Vendor Swap	Detailed Design	B4
Date:	01.07.22	Revision / Upgrade Description:		
Drawn:	T. Dociu	Minor amend		
Checked:	S. Dafinoiu			
Approved:	F. Carminho			
Master:	MBNL / EE / H3G:	Project:	Purpose of Issue:	Issue:
M005	MBNL	Vendor Swap	Detailed Design	B3
Date:	23.06.22	Revision / Upgrade Description:		
Drawn:	T. Dociu	Keep existing antennas		
Checked:	S. Dafinoiu			
Approved:	F. Carminho			
Master:	MBNL / EE / H3G:	Project:	Purpose of Issue:	Issue:
M003	MBNL	Vendor Swap	Detailed Design	B1
Date:	05.12.21	Revision / Upgrade Description:		
Drawn:	T. Dociu	First Issue		
Checked:	S. Dafinoiu			
Approved:	F. Carminho			
Master:	MBNL / EE / H3G:	Project:	Purpose of Issue:	Issue:
M002	MBNL	Vendor Swap	Planning	B
Date:	19.11.21	Revision / Upgrade Description:		
Drawn:	T. Dociu	Minor amend		
Checked:	S. Dafinoiu			
Approved:	F. Carminho			
Master:	MBNL / EE / H3G:	Project:	Purpose of Issue:	Issue:
M001	MBNL	Vendor Swap	Planning	A
Date:	17.11.21	Revision / Upgrade Description:		
Drawn:	T. Dociu	First Issue		
Checked:	S. Dafinoiu			
Approved:	F. Carminho			



Hatfield Business Park
Hatfield
Hertfordshire
AL10 9BW

Tel: 01707 315000
Fax: 01707 319001



ERICSSON



Telelink Infra Services
Address: Station Road,
Woolhampton, Reading,
RG7 5SE, UK
email: office-uk@telelink.com

Site Name:
20 DALE STREET

Site ID:
920100

Address:
20 DALE STREET,
GREATER MANCHESTER,
MANCHESTER,
M1 1EZ

Title:
200 EXISTING SITE ELEVATION A

Project:
VENDOR SWAP

Purpose of Issue:
DETAILED DESIGN


EE Cell ID: 56016	MBNL Cell ID: MAN041	3UK Cell ID: M0297
----------------------	-------------------------	-----------------------

Master Drawing No: 920100_MAN041_56016_M0297_M006	Issue: B4
--	--------------


100mm

150mm

10mm

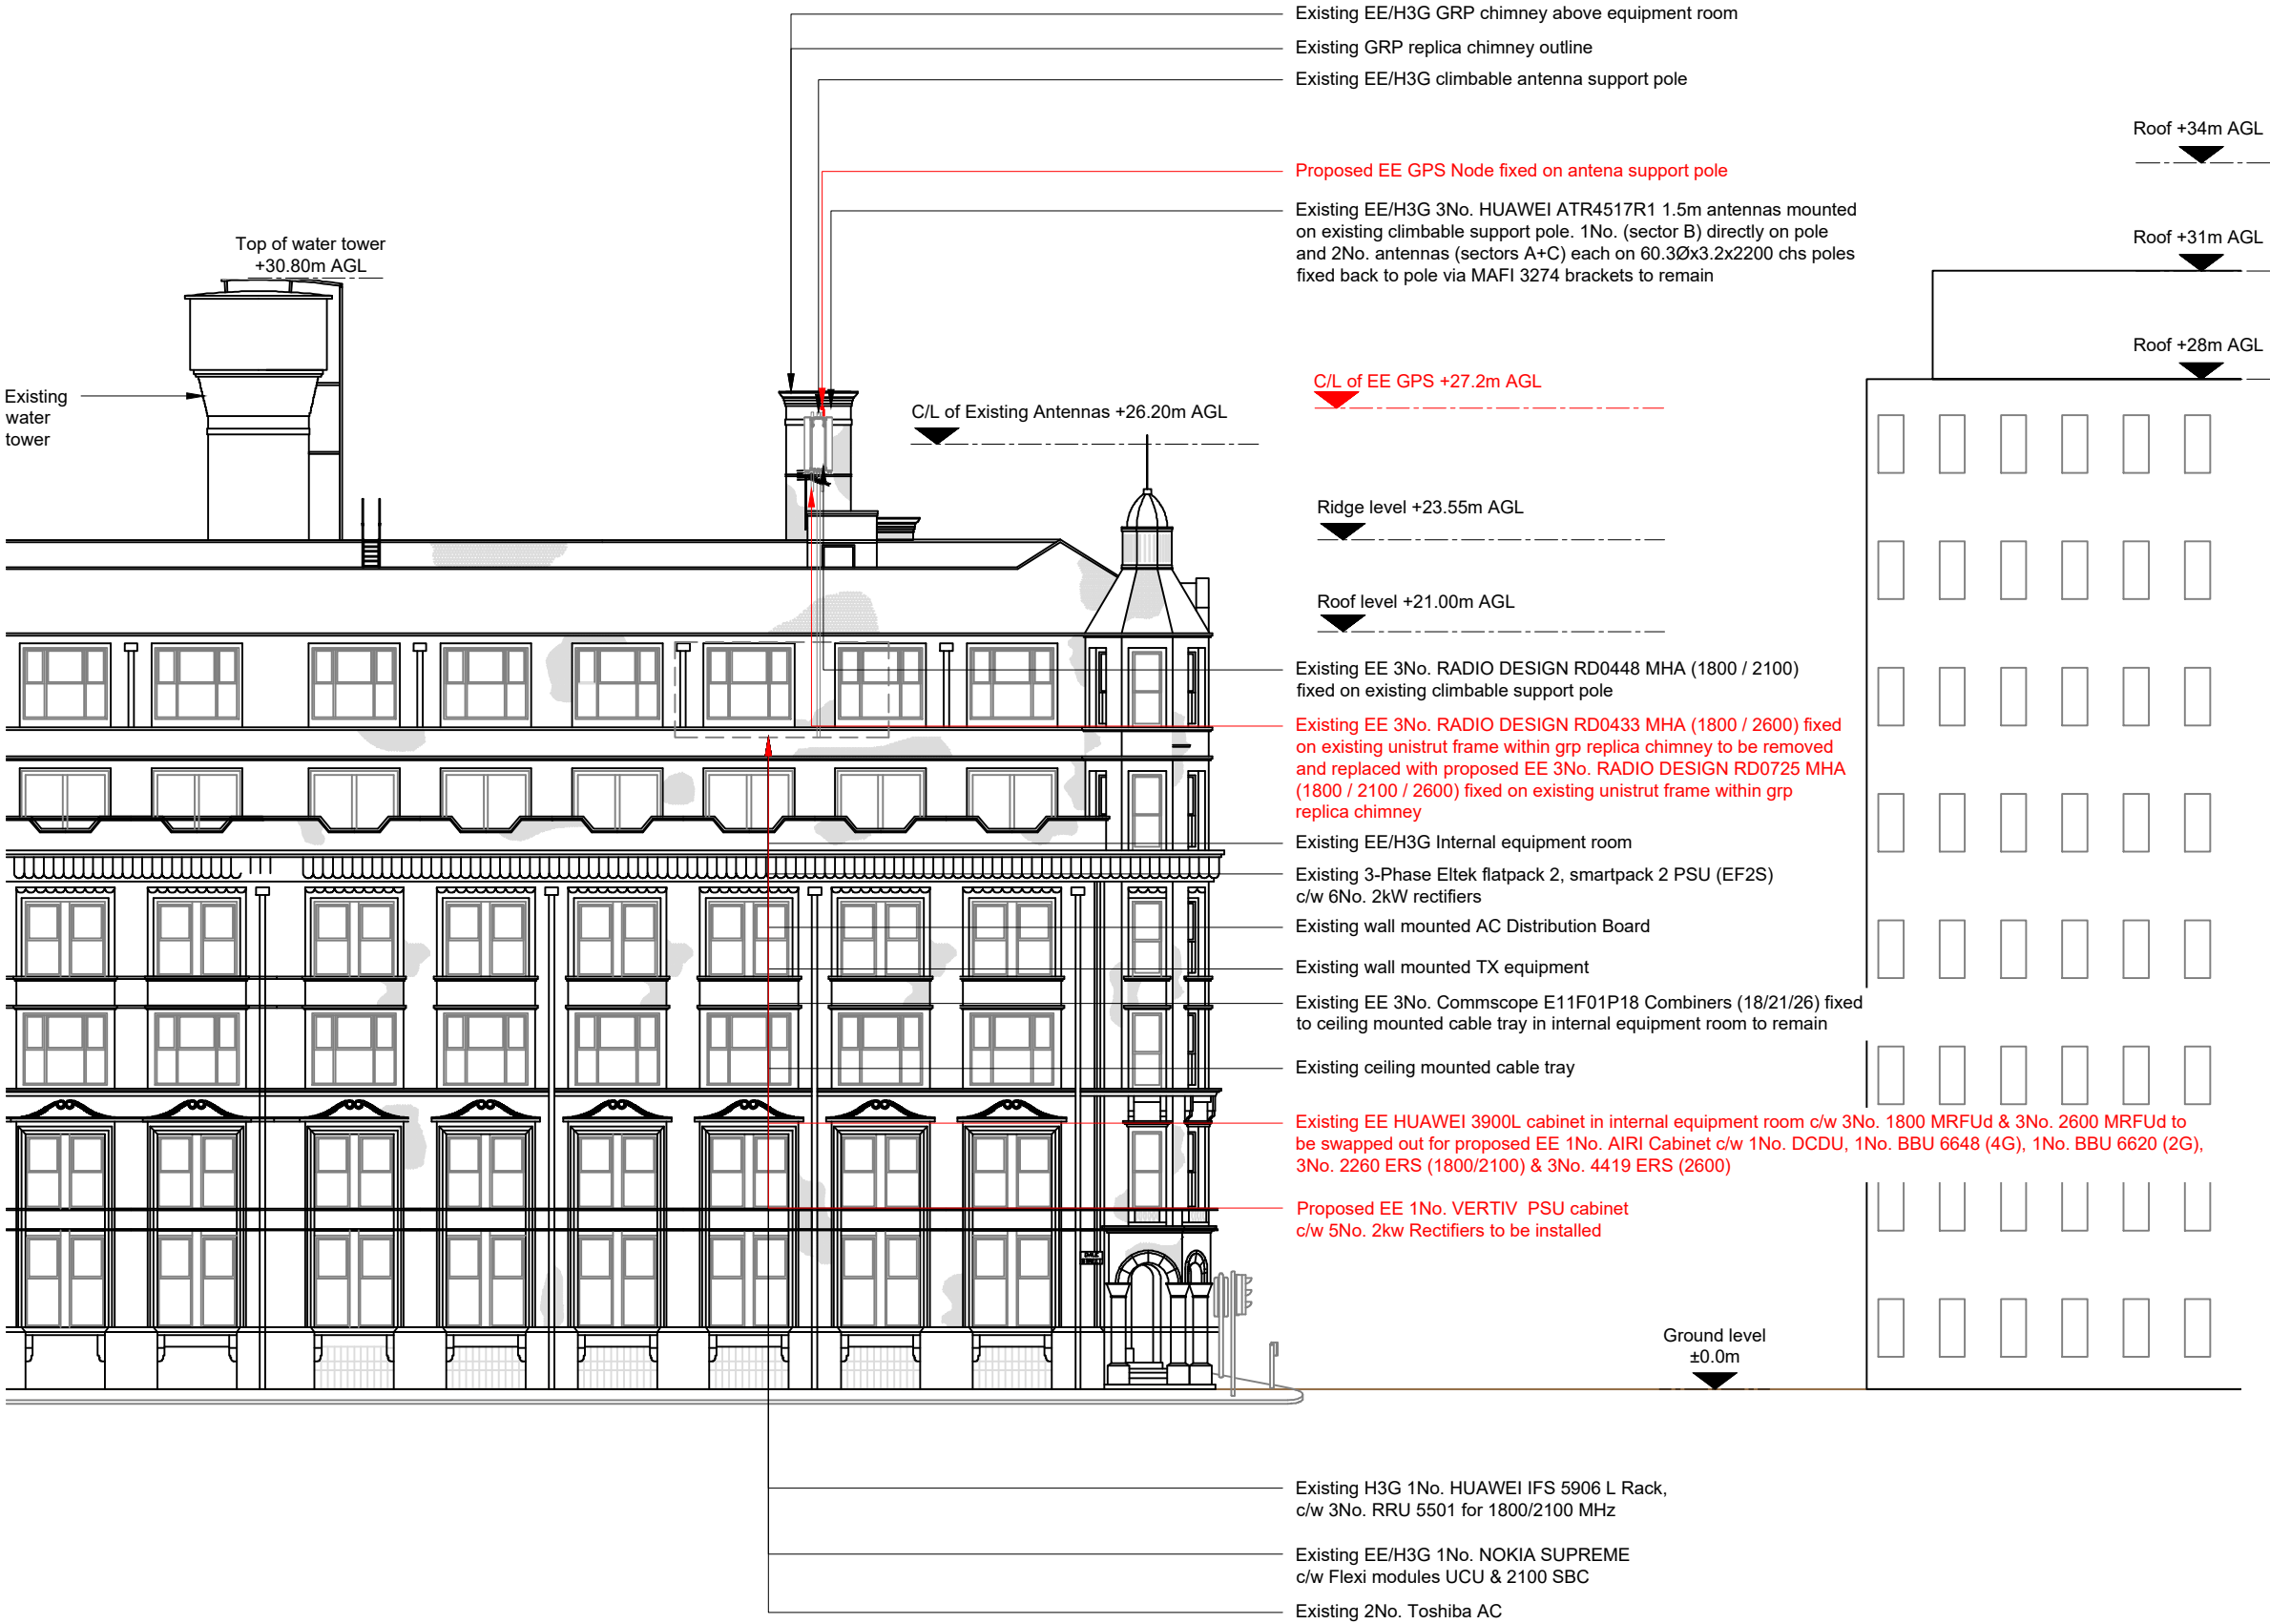

PROPOSED SITE ELEVATION A

 

- NOTES:
- ALL DIMENSIONS IN MM UNLESS OTHERWISE NOTED.

Note:

Proposed cabinets to be bonded to the existing LP system.

All existing fibre / feeder cables to be re-used. Subject to testing. Un-used feeder cables to remain and be capped

Master:	MBNL / EE / H3G:	Project:	Purpose of Issue:	Issue:
M006	MBNL	Vendor Swap	Detailed Design	B4
Date:	01.07.22	Revision / Upgrade Description:		
Drawn:	T. Dociu	Minor amend		
Checked:	S. Dafinoiu			
Approved:	F. Carminho			
Master:	MBNL / EE / H3G:	Project:	Purpose of Issue:	Issue:
M005	MBNL	Vendor Swap	Detailed Design	B3
Date:	23.06.22	Revision / Upgrade Description:		
Drawn:	T. Dociu	Keep existing antennas		
Checked:	S. Dafinoiu			
Approved:	F. Carminho			
Master:	MBNL / EE / H3G:	Project:	Purpose of Issue:	Issue:
M003	MBNL	Vendor Swap	Detailed Design	B1
Date:	05.12.21	Revision / Upgrade Description:		
Drawn:	T. Dociu	First Issue		
Checked:	S. Dafinoiu			
Approved:	F. Carminho			
Master:	MBNL / EE / H3G:	Project:	Purpose of Issue:	Issue:
M002	MBNL	Vendor Swap	Planning	B
Date:	19.11.21	Revision / Upgrade Description:		
Drawn:	T. Dociu	Minor amend		
Checked:	S. Dafinoiu			
Approved:	F. Carminho			
Master:	MBNL / EE / H3G:	Project:	Purpose of Issue:	Issue:
M001	MBNL	Vendor Swap	Planning	A
Date:	17.11.21	Revision / Upgrade Description:		
Drawn:	T. Dociu	First Issue		
Checked:	S. Dafinoiu			
Approved:	F. Carminho			



Hatfield Business Park
Hatfield
Hertfordshire
AL10 9BW

Tel: 01707 315000
Fax: 01707 319001



ERICSSON



Telelink Infra Services
Address: Station Road,
Woolhampton, Reading,
RG7 5SE, UK
email: office-uk@telelink.com

Site Name:
20 DALE STREET

Site ID:
920100

Address:
20 DALE STREET,
GREATER MANCHESTER,
MANCHESTER,
M1 1EZ

Title:
250 PROPOSED SITE ELEVATION A

Project:
VENDOR SWAP

Purpose of Issue:
DETAILED DESIGN

EE Cell ID: 56016	MBNL Cell ID: MAN041	3UK Cell ID: M0297
----------------------	-------------------------	-----------------------

Master Drawing No: 920100_MAN041_56016_M0297_M006	Issue: B4
--	--------------



Existing 3-Phase Eltek flatpack 2, smartpack 2 psu (EF2S)
c/w 6No. 2kW rectifiers

Existing wall mounted AC Distribution Board

Existing 2mx5.8m equipment room

2040

5800

Existing EE/H3G GRP chimney
above equipment room

Existing H3G 1No. HUAWEI IFS 5906 L Rack,
c/w 3No. RRU 5501 for 1800/2100 MHz

Existing EE/H3G climbable
antenna support pole

Existing EE/H3G 1No. NOKIA SUPREME
c/w Flexi modules UCU & 2100 SBC

Existing wall mounted TX equipment

 
Existing EE 3No. Commscope E11F01P18 Combiners (18/21/26)
fixed to ceiling mounted cable tray in internal equipment room

Existing ceiling mounted cable tray

Existing EE HUAWEI 3900L cabinet in internal equipment
room c/w 3No. 1800 MRFUd & 3No. 2600 MRFUd

Existing 2No. Toshiba AC

EXISTING CABIN LAYOUT



Note: Existing cabinets to be retained in same location (or within 300mm) where possible but must be within the 600mm standard grid. Tx with Fibre must be retained in same location. Preferred access to front of all equipment is 800mm. Minimum front access is 600mm



Existing 3-Phase Eltek flatpack 2, smartpack 2 psu (EF2S)
c/w 6No. 2kW rectifiers

Existing wall mounted AC Distribution Board

Existing 2mx5.8m equipment room

2040

5800

Existing EE/H3G GRP chimney
above equipment room

Existing H3G 1No. HUAWEI IFS 5906 L Rack,
c/w 3No. RRU 5501 for 1800/2100 MHz

Existing EE/H3G climbable
antenna support pole

Existing EE/H3G 1No. NOKIA SUPREME
c/w Flexi modules UCU & 2100 SBC

Existing wall mounted TX equipment

 
Existing EE 3No. Commscope E11F01P18 Combiners (18/21/26) fixed
to ceiling mounted cable tray in internal equipment room to remain

Existing ceiling mounted cable tray

Existing EE HUAWEI 3900L cabinet in internal equipment room c/w 3No. 1800 MRFUd & 3No. 2600 MRFUd
to be swapped out for proposed EE 1No. AIRI Cabinet c/w 1No. DCUD, 1No. BBU 6648 (4G), 1No. BBU
6620 (2G), 3No. 2260 ERS (1800/2100) & 3No. 4419 ERS (2600)

Existing 2No. Toshiba AC

PROPOSED CABIN LAYOUT



NOTES:

1. ALL DIMENSIONS IN MM UNLESS OTHERWISE NOTED.

Master:	MBNL / EE / H3G:	Project:	Purpose of Issue:	Issue:
M006	MBNL	Vendor Swap	Detailed Design	B4
Date:	01.07.22	Revision / Upgrade Description:		
Drawn:	T. Dociu	Minor amend		
Checked:	S. Dafinoiu			
Approved:	F. Carminho			
Master:	MBNL / EE / H3G:	Project:	Purpose of Issue:	Issue:
M005	MBNL	Vendor Swap	Detailed Design	B3
Date:	23.06.22	Revision / Upgrade Description:		
Drawn:	T. Dociu	Keep existing antennas		
Checked:	S. Dafinoiu			
Approved:	F. Carminho			
Master:	MBNL / EE / H3G:	Project:	Purpose of Issue:	Issue:
M003	MBNL	Vendor Swap	Detailed Design	B1
Date:	05.12.21	Revision / Upgrade Description:		
Drawn:	T. Dociu	First Issue		
Checked:	S. Dafinoiu			
Approved:	F. Carminho			
Master:	MBNL / EE / H3G:	Project:	Purpose of Issue:	Issue:
M002	MBNL	Vendor Swap	Planning	B
Date:	19.11.21	Revision / Upgrade Description:		
Drawn:	T. Dociu	Minor amend		
Checked:	S. Dafinoiu			
Approved:	F. Carminho			
Master:	MBNL / EE / H3G:	Project:	Purpose of Issue:	Issue:
M001	MBNL	Vendor Swap	Planning	A
Date:	17.11.21	Revision / Upgrade Description:		
Drawn:	T. Dociu	First Issue		
Checked:	S. Dafinoiu			
Approved:	F. Carminho			




Hatfield Business Park
Hatfield
Hertfordshire
AL10 9BW

Tel: 01707 315000
Fax: 01707 319001





Telelink Infra Services
Address: Station Road,
Woolhampton, Reading,
RG7 5SE, UK
email: office-uk@telelink.com

Site Name:	20 DALE STREET		
Site ID:	920100		
Address:	20 DALE STREET, GREATER MANCHESTER, MANCHESTER, M1 1EZ		
Title:	300 CABIN LAYOUT		
Project:	VENDOR SWAP		
Purpose of Issue:	DETAILED DESIGN		
EE Cell ID:	56016	MBNL Cell ID:	MAN041
3UK Cell ID:	M0297		
Master Drawing No:	920100_MAN041_56016_M0297_M006		
Issue:	B4		

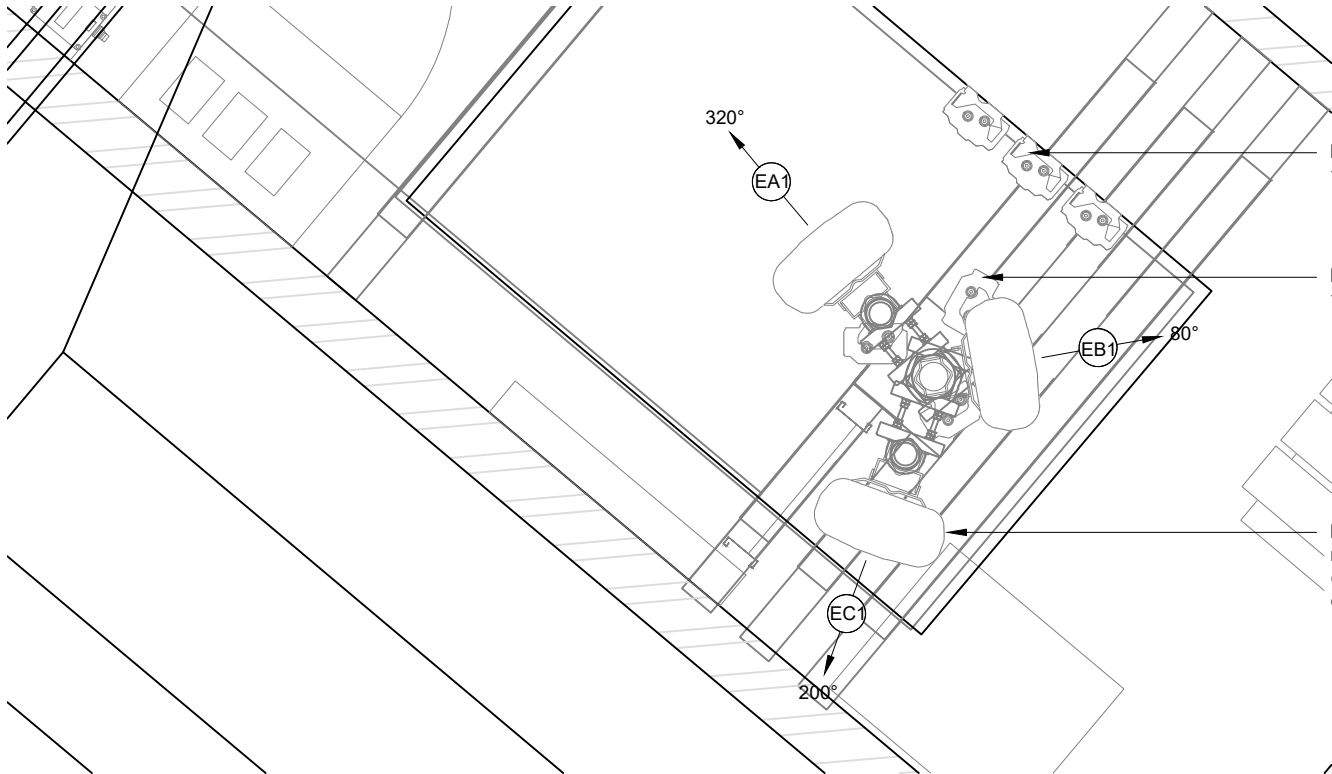

EXISTING ANTENNA PLAN

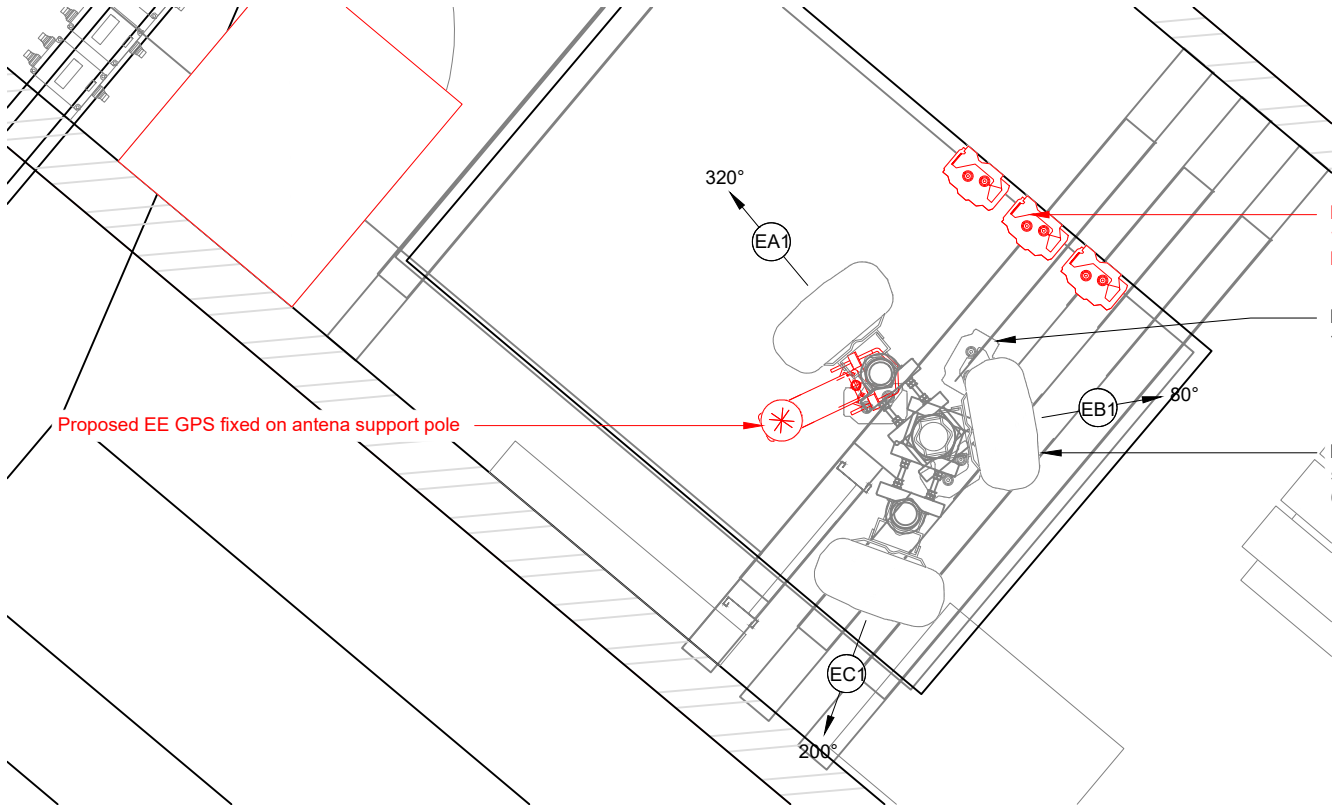 

PROPOSED ANTENNA PLAN



NOTES:

1. ALL DIMENSIONS IN MM UNLESS OTHERWISE NOTED.

Master:	MBNL / EE / H3G:	Project:	Purpose of Issue:	Issue:
M006	MBNL	Vendor Swap	Detailed Design	B4
Date:	01.07.22	Revision / Upgrade Description:		
Drawn:	T. Dociu	Minor amend		
Checked:	S. Dafinoiu			
Approved:	F. Carminho			
Master:	MBNL / EE / H3G:	Project:	Purpose of Issue:	Issue:
M005	MBNL	Vendor Swap	Detailed Design	B3
Date:	23.06.22	Revision / Upgrade Description:		
Drawn:	T. Dociu	Keep existing antennas		
Checked:	S. Dafinoiu			
Approved:	F. Carminho			
Master:	MBNL / EE / H3G:	Project:	Purpose of Issue:	Issue:
M003	MBNL	Vendor Swap	Detailed Design	B1
Date:	05.12.21	Revision / Upgrade Description:		
Drawn:	T. Dociu	First Issue		
Checked:	S. Dafinoiu			
Approved:	F. Carminho			
Master:	MBNL / EE / H3G:	Project:	Purpose of Issue:	Issue:
M002	MBNL	Vendor Swap	Planning	B
Date:	19.11.21	Revision / Upgrade Description:		
Drawn:	T. Dociu	Minor amend		
Checked:	S. Dafinoiu			
Approved:	F. Carminho			
Master:	MBNL / EE / H3G:	Project:	Purpose of Issue:	Issue:
M001	MBNL	Vendor Swap	Planning	A
Date:	17.11.21	Revision / Upgrade Description:		
Drawn:	T. Dociu	First Issue		
Checked:	S. Dafinoiu			
Approved:	F. Carminho			





Hatfield Business Park
Hatfield
Hertfordshire
AL10 9BW

Tel: 01707 315000
Fax: 01707 319001




Telelink Infra Services
Address: Station Road,
Woolhampton, Reading,
RG7 5SE, UK
email: office-uk@telelink.com

Site Name:	20 DALE STREET		
Site ID:	920100		
Address:	20 DALE STREET, GREATER MANCHESTER, MANCHESTER, M1 1EZ		
Title:	310 ANTENNA HEADFRAME & SUPPORT STRUCTURE PLAN		
Project:	VENDOR SWAP		
Purpose of Issue:	DETAILED DESIGN		
EE Cell ID: 56016	MBNL Cell ID: MAN041	3UK Cell ID: M0297	
Master Drawing No: 920100_MAN041_56016_M0297_M006			Issue: B4

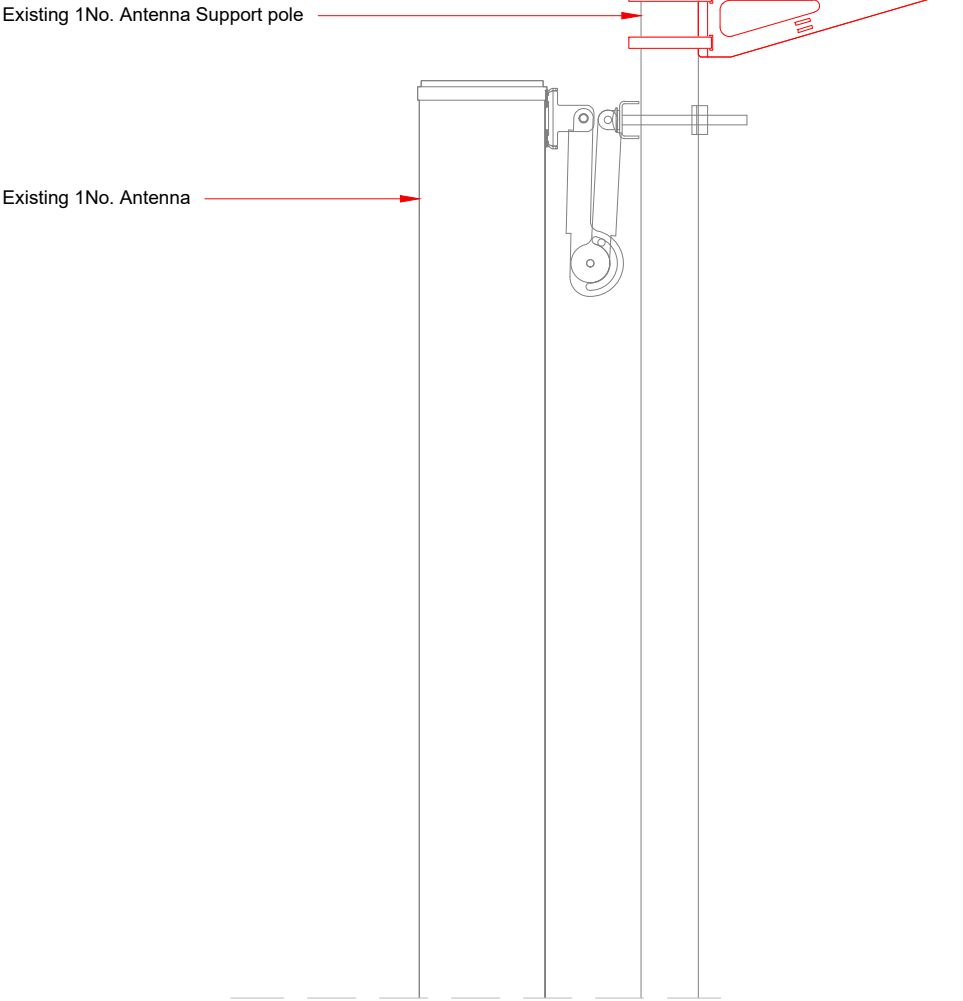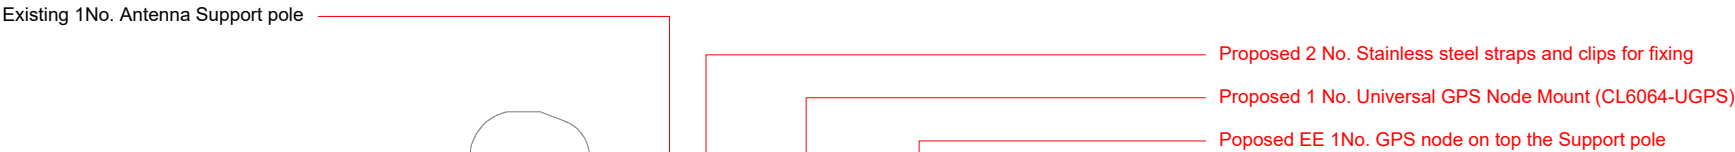

EXISTING & PROPOSED GPS MOUNT SYSTEMS

 

- NOTES:
- ALL DIMENSIONS IN MM UNLESS OTHERWISE NOTED.

Master:	MBNL / EE / H3G:	Project:	Purpose of Issue:	Issue:
M006	MBNL	Vendor Swap	Detailed Design	B4
Date:	01.07.22	Revision / Upgrade Description:		
Drawn:	T. Dociu	Minor amend		
Checked:	S. Dafinoiu			
Approved:	F. Carminho			
Master:	MBNL / EE / H3G:	Project:	Purpose of Issue:	Issue:
M005	MBNL	Vendor Swap	Detailed Design	B3
Date:	23.06.22	Revision / Upgrade Description:		
Drawn:	T. Dociu	Keep existing antennas		
Checked:	S. Dafinoiu			
Approved:	F. Carminho			
Master:	MBNL / EE / H3G:	Project:	Purpose of Issue:	Issue:
M003	MBNL	Vendor Swap	Detailed Design	B1
Date:	05.12.21	Revision / Upgrade Description:		
Drawn:	T. Dociu	First Issue		
Checked:	S. Dafinoiu			
Approved:	F. Carminho			
Master:	MBNL / EE / H3G:	Project:	Purpose of Issue:	Issue:
M002	MBNL	Vendor Swap	Planning	B
Date:	19.11.21	Revision / Upgrade Description:		
Drawn:	T. Dociu	Minor amend		
Checked:	S. Dafinoiu			
Approved:	F. Carminho			
Master:	MBNL / EE / H3G:	Project:	Purpose of Issue:	Issue:
M001	MBNL	Vendor Swap	Planning	A
Date:	17.11.21	Revision / Upgrade Description:		
Drawn:	T. Dociu	First Issue		
Checked:	S. Dafinoiu			
Approved:	F. Carminho			



Hatfield Business Park
Hatfield
Hertfordshire
AL10 9BW

Tel: 01707 315000
Fax: 01707 319001



ERICSSON



Telelink Infra Services
Address: Station Road,
Woolhampton, Reading,
RG7 5SE, UK
email: office-uk@telelink.com

Site Name:
20 DALE STREET

Site ID:
920100

Address:
20 DALE STREET,
GREATER MANCHESTER,
MANCHESTER,
M1 1EZ

Title:
600 DETAILED DESIGN

Project:
VENDOR SWAP

Purpose of Issue:
DETAILED DESIGN

EE Cell ID: 56016	MBNL Cell ID: MAN041	3UK Cell ID: M0297
----------------------	-------------------------	-----------------------

Master Drawing No: 920100_MAN041_56016_M0297_M006	Issue: B4
--	--------------