



SITE LOCATION

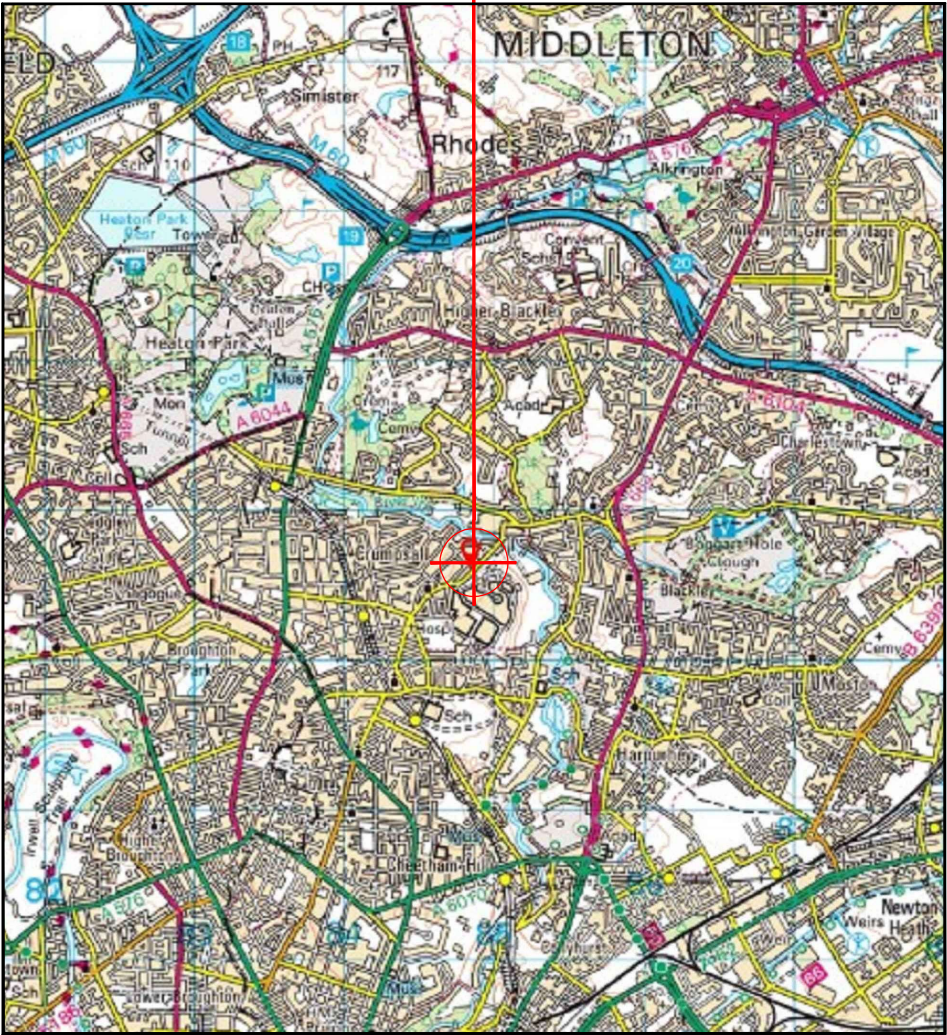


 
Reproduced by permission of Ordnance Survey on behalf of the Controller of Her Majesty's Stationery Office
All rights reserved. © Crown Copyright licence no. 100022432

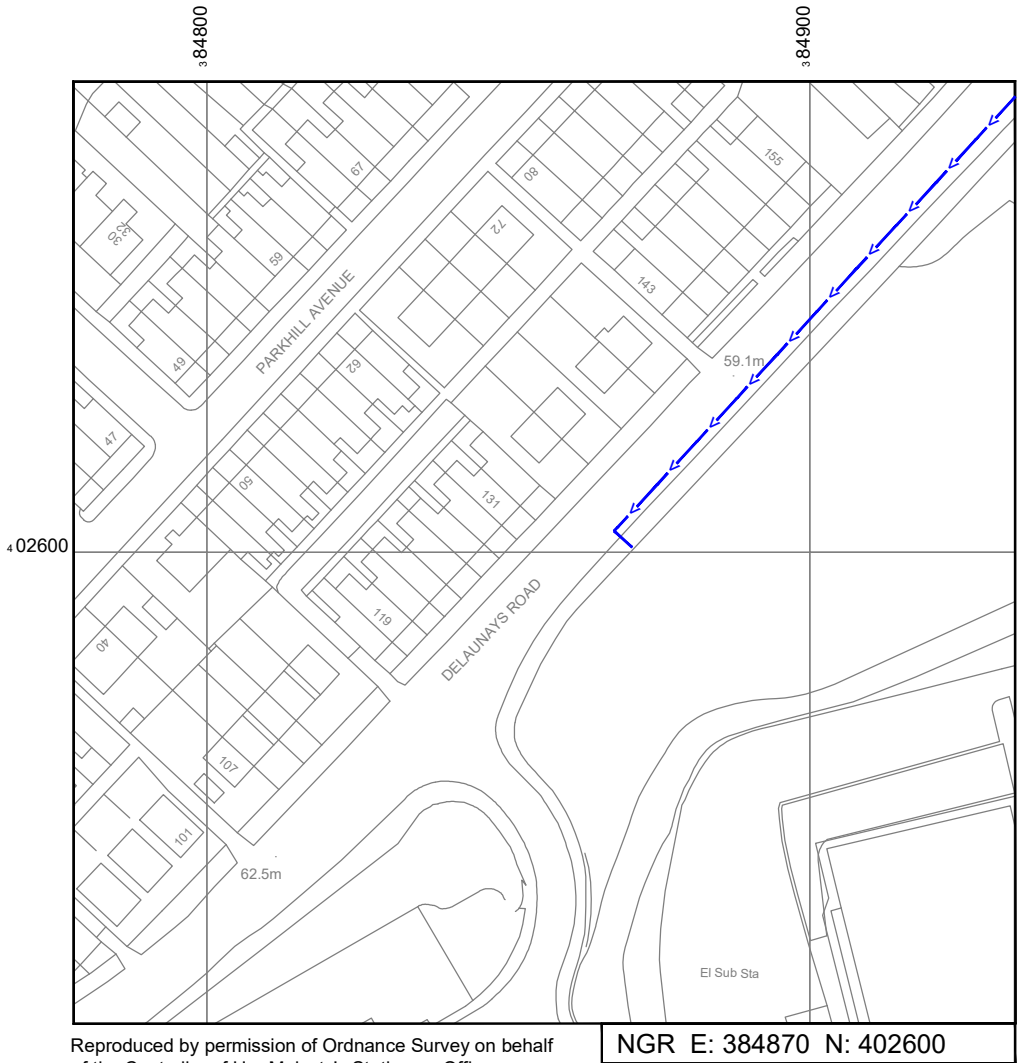

Reproduced by permission of Ordnance Survey on behalf of the Controller of Her Majesty's Stationery Office
All rights reserved. © Crown Copyright licence no. 100022432


NGR E: 384870 N: 402600

SITE AREA PLAN

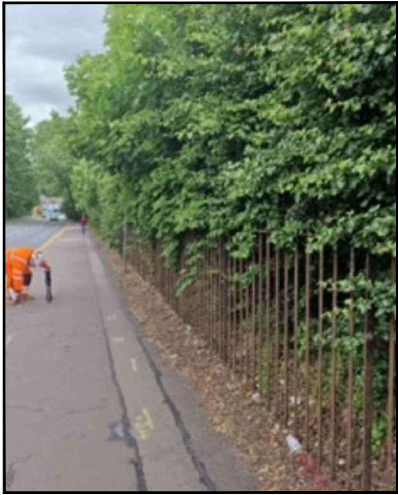

SITE PHOTOGRAPH

 SITE LOCATION PLAN



GOOGLE MAPS QR CODE

GOOGLE MAPS - <https://goo.gl/maps/LMYCvnZeZCHXb1dPA>

GOOGLE STREETVIEW - <https://goo.gl/maps/8LxPMymaBEKGUjKm7>

NOTES:

1. ALL DIMENSIONS IN MM UNLESS OTHERWISE NOTED.

DIRECTIONS TO SITE:
Head South- East on M60, at junction 19 use the left 2 lanes to take the A576 exit towards M/cr City Centre/Middleton. At Rhodes interchange take the third exit onto Middleton Road/A576. Travel one mile and then turn left onto Blackley New Road. After 300yards take a sharp right onto Mill Brow, which becomes Delaunys Road , site will be on left hand side.

Access Route To Site:

Master:	MBNL / EE / H3G:	Project:	Purpose of Issue:	Issue:
M001	H3G	DENSIFICATION SW	Planning	A
Date:	17/06/2022	Revision / Upgrade Description:		
Drawn:	S.Booth	First Issue - Site nomination dated: TBC		
Checked:	K.Winland			
Approved:	K.Winland			



Hutchison 3G UK Limited
Green Park, 450 Longwater Avenue
Reading, RG30 3UR
Tel: 01628 765 000
Fax: 01628 765 001

H3G Base Station Information line:
0845 6043000
Available 8am-8pm Monday to Friday

Design Consultant & Principal Contractor:



Unit E, Madison Place, Northampton Road,
Manchester, M40 5AG
Tel: 0161 785 4500 Fax: 0161 785 4501
Web: www.clarke-telecom.com

Site Name: DELAUNYS ROAD

Site ID: MAN24790_B35

Address: NORTH MANCHESTER GENERAL
HOSPITAL
131 DELAUNYS ROAD
MANCHESTER
M8 4RE


Title: 002 SITE LOCATION PLAN

Project: H3G DENSIFICATION STREETWORKS

Purpose of Issue: PLANNING

EE Cell ID:	MBNL Cell ID:	3UK Cell ID:
-	-	MAN24790_B35

Master Drawing No:	Issue:
MAN24790_B35_GA_A	A

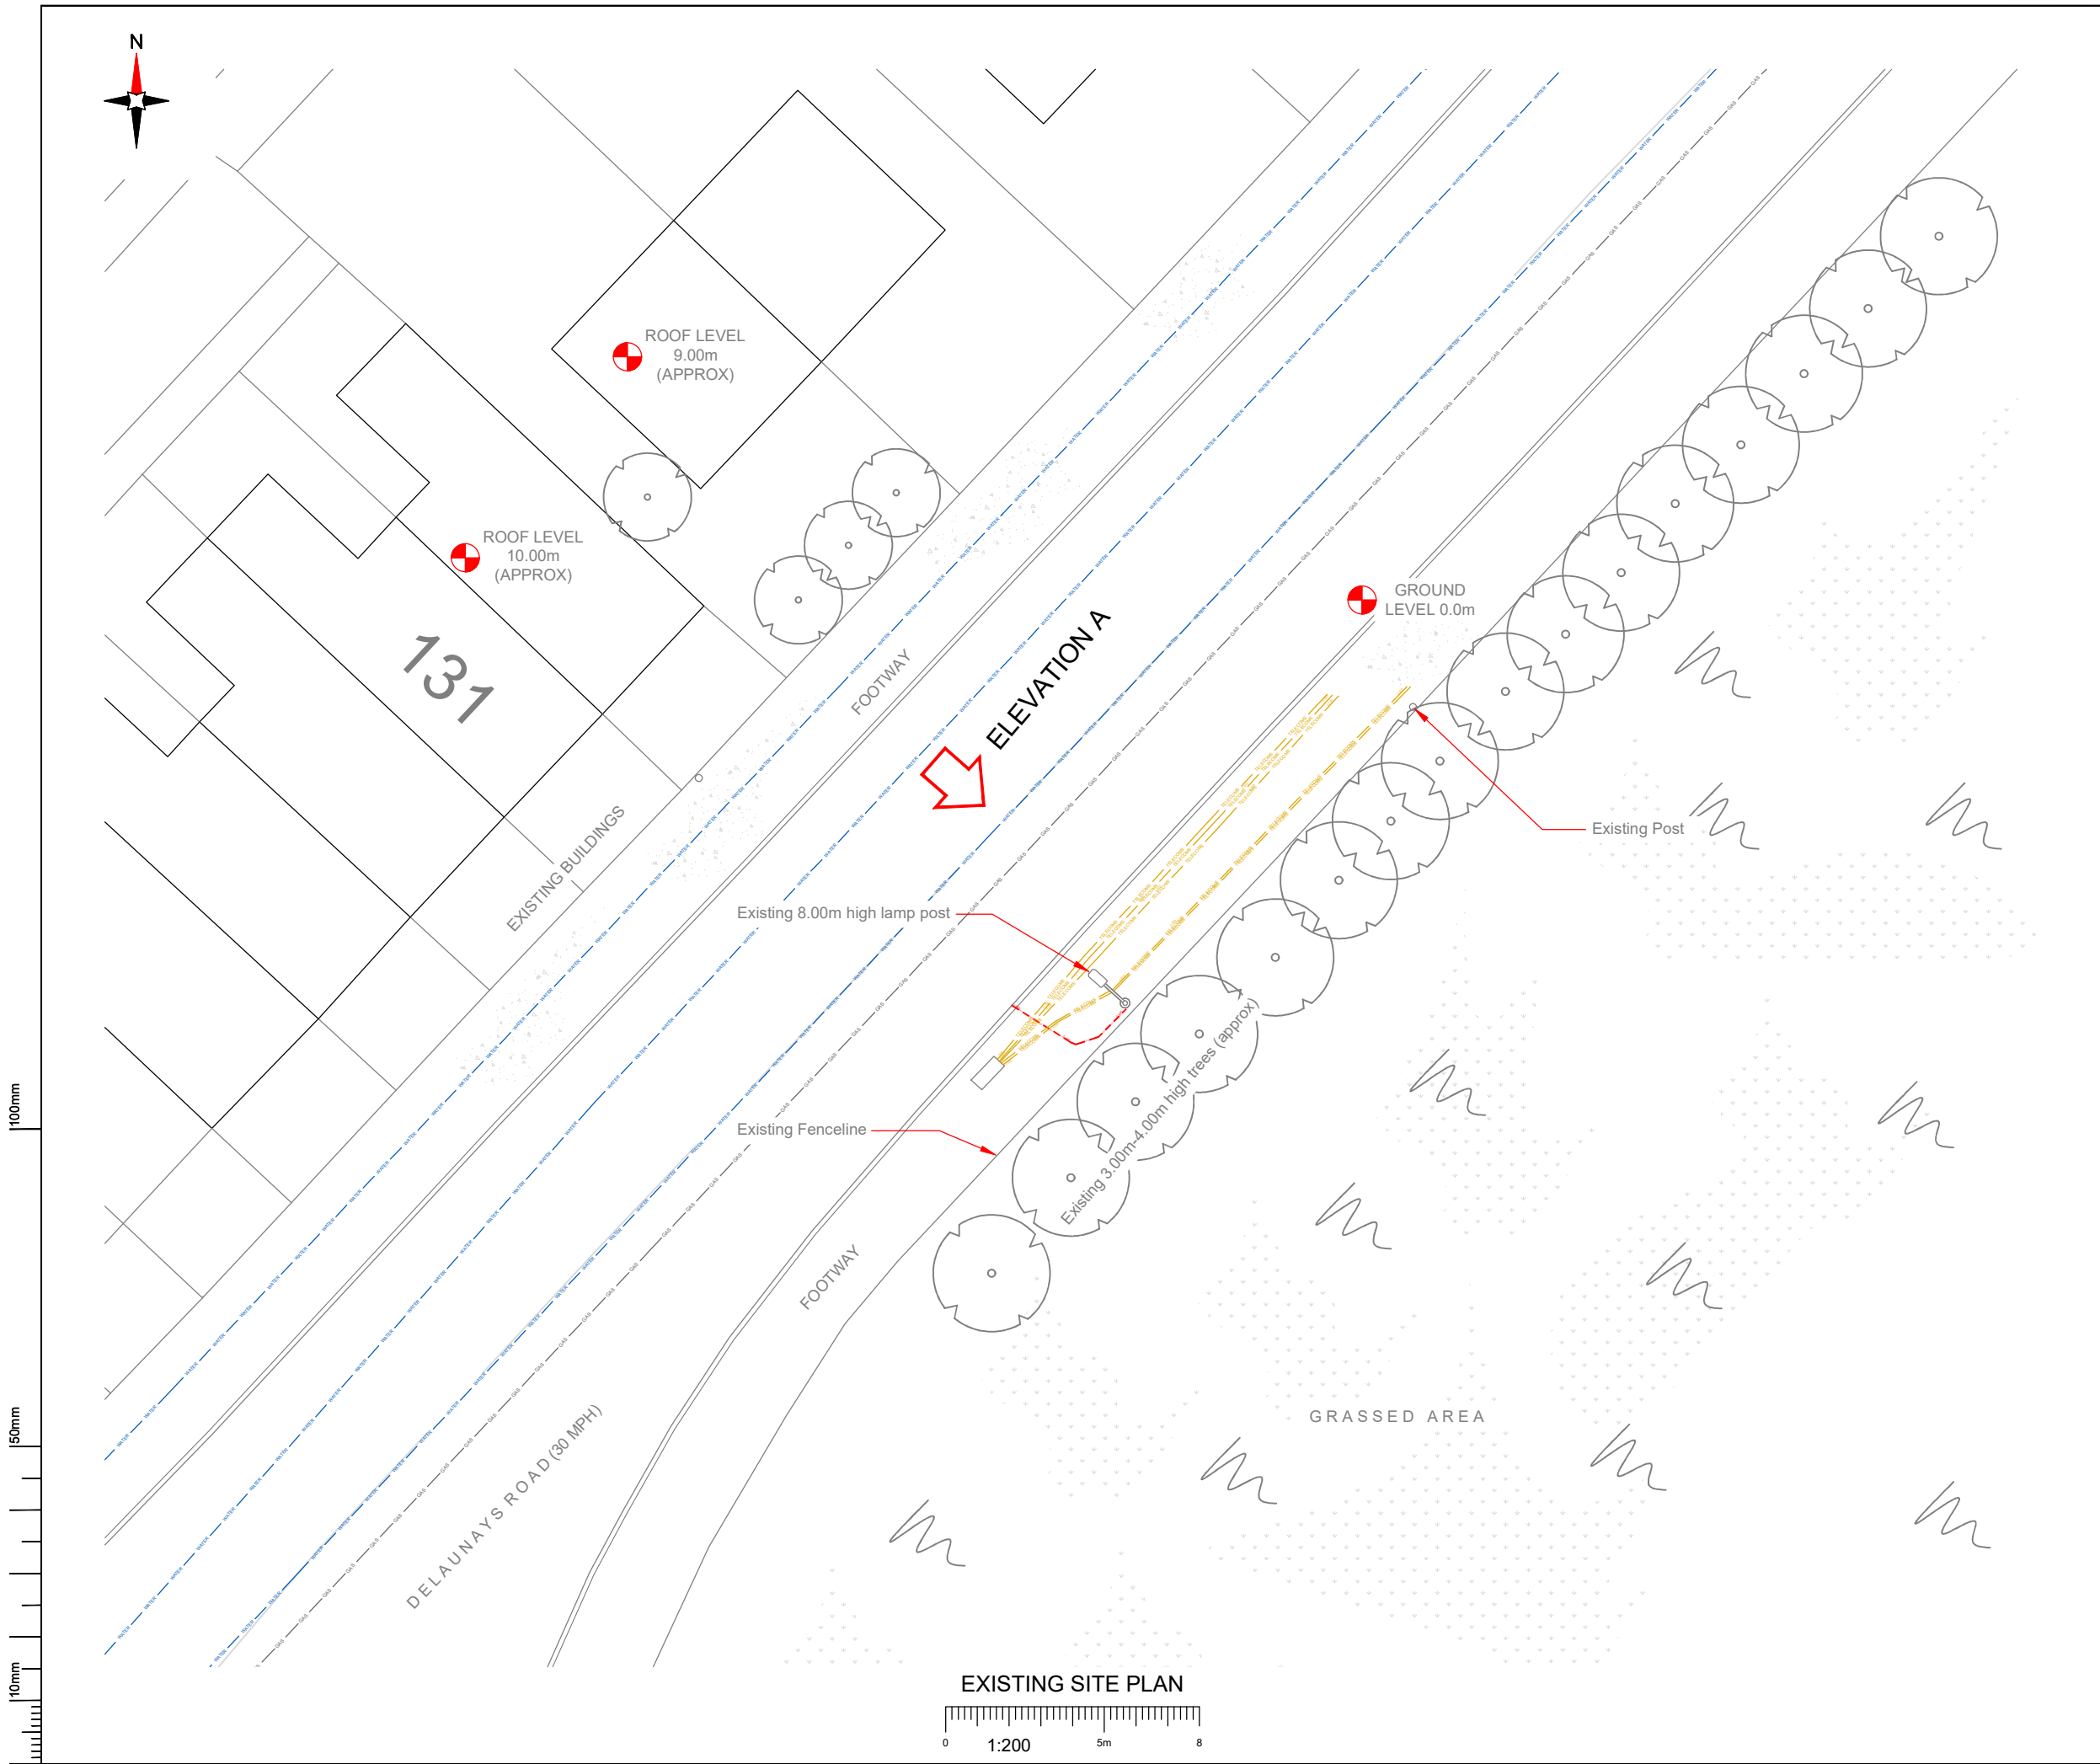

NOTES:
1. ALL DIMENSIONS IN MM UNLESS OTHERWISE NOTED.

SERVICES:

NOTES:
Radar Scan and Stats to be reviewed prior to any build works commencing

Master: M001	MBNL / EE / H3G: H3G	Project: DENSIFICATION SW	Purpose of Issue: Planning	Issue: A
Date: 17/06/2022	Revision / Upgrade Description: First Issue - Site nomination dated: TBC			
Drawn: S.Booth				
Checked: K.Winland				
Approved: K.Winland				

Hutchison 3G UK Limited
Green Park, 450 Longwater Avenue
Reading, RG30 3UR
Tel: 01628 765 000
Fax: 01628 765 001

H3G Base Station Information line:
0845 6043000
Available 8am-8pm Monday to Friday

Design Consultant & Principal Contractor:

Unit E, Madison Place, Northampton Road,
Manchester, M40 5AG
Tel: 0161 785 4500 Fax: 0161 785 4501
Web: www.clarke-telecom.com

Site Name:	DELAUNYS ROAD				
Site ID:	MAN24790_B35				
Address:	NORTH MANCHESTER GENERAL HOSPITAL 131 DELAUNYS ROAD MANCHESTER M8 4RE				
Title:	100 EXISTING H3G SITE PLAN				
Project:	H3G DENSIFICATION STREETWORKS				
Purpose of Issue:	PLANNING				
EE Cell ID:	-	MBNL Cell ID:	-	3UK Cell ID:	MAN24790_B35
Master Drawing No: MAN24790_B35_GA_A					Issue: A



NOTES:

1. ALL DIMENSIONS IN MM UNLESS OTHERWISE NOTED.

Master:	MBNL / EE / H3G:	Project:	Purpose of Issue:	Issue:
M001	H3G	DENSIFICATION SW	Planning	A
Date:	17/06/2022	Revision / Upgrade Description:		
Drawn:	S.Booth	First Issue - Site nomination dated: TBC		
Checked:	K.Winland			
Approved:	K.Winland			



Hutchison 3G UK Limited
Green Park, 450 Longwater Avenue
Reading, RG30 3UR
Tel: 01628 765 000
Fax: 01628 765 001

H3G Base Station Information line:
0845 6043000
Available 8am-8pm Monday to Friday

Design Consultant & Principal Contractor:



Unit E, Madison Place, Northampton Road,
Manchester, M40 5AG
Tel: 0161 785 4500 Fax: 0161 785 4501
Web: www.clarke-telecom.com

Site Name:

DELAUNYS ROAD

Site ID:

MAN24790_B35

Address:

SS: NORTH MANCHESTER GENERAL
HOSPITAL
131 DELAUNAYS ROAD
MANCHESTER
M8 4RE

Title:

150 EXISTING H3G SITE ELEVATION

Project:

H3G DENSIFICATION STREETWORKS

Purpose of Issue:	
-------------------	--


PLANNING

EE Cell ID:	MBNL Cell ID:	3UK Cell ID:
-	-	MAN24790_B35

Master Drawing No:

MAN24790 B35 GA A

sue:

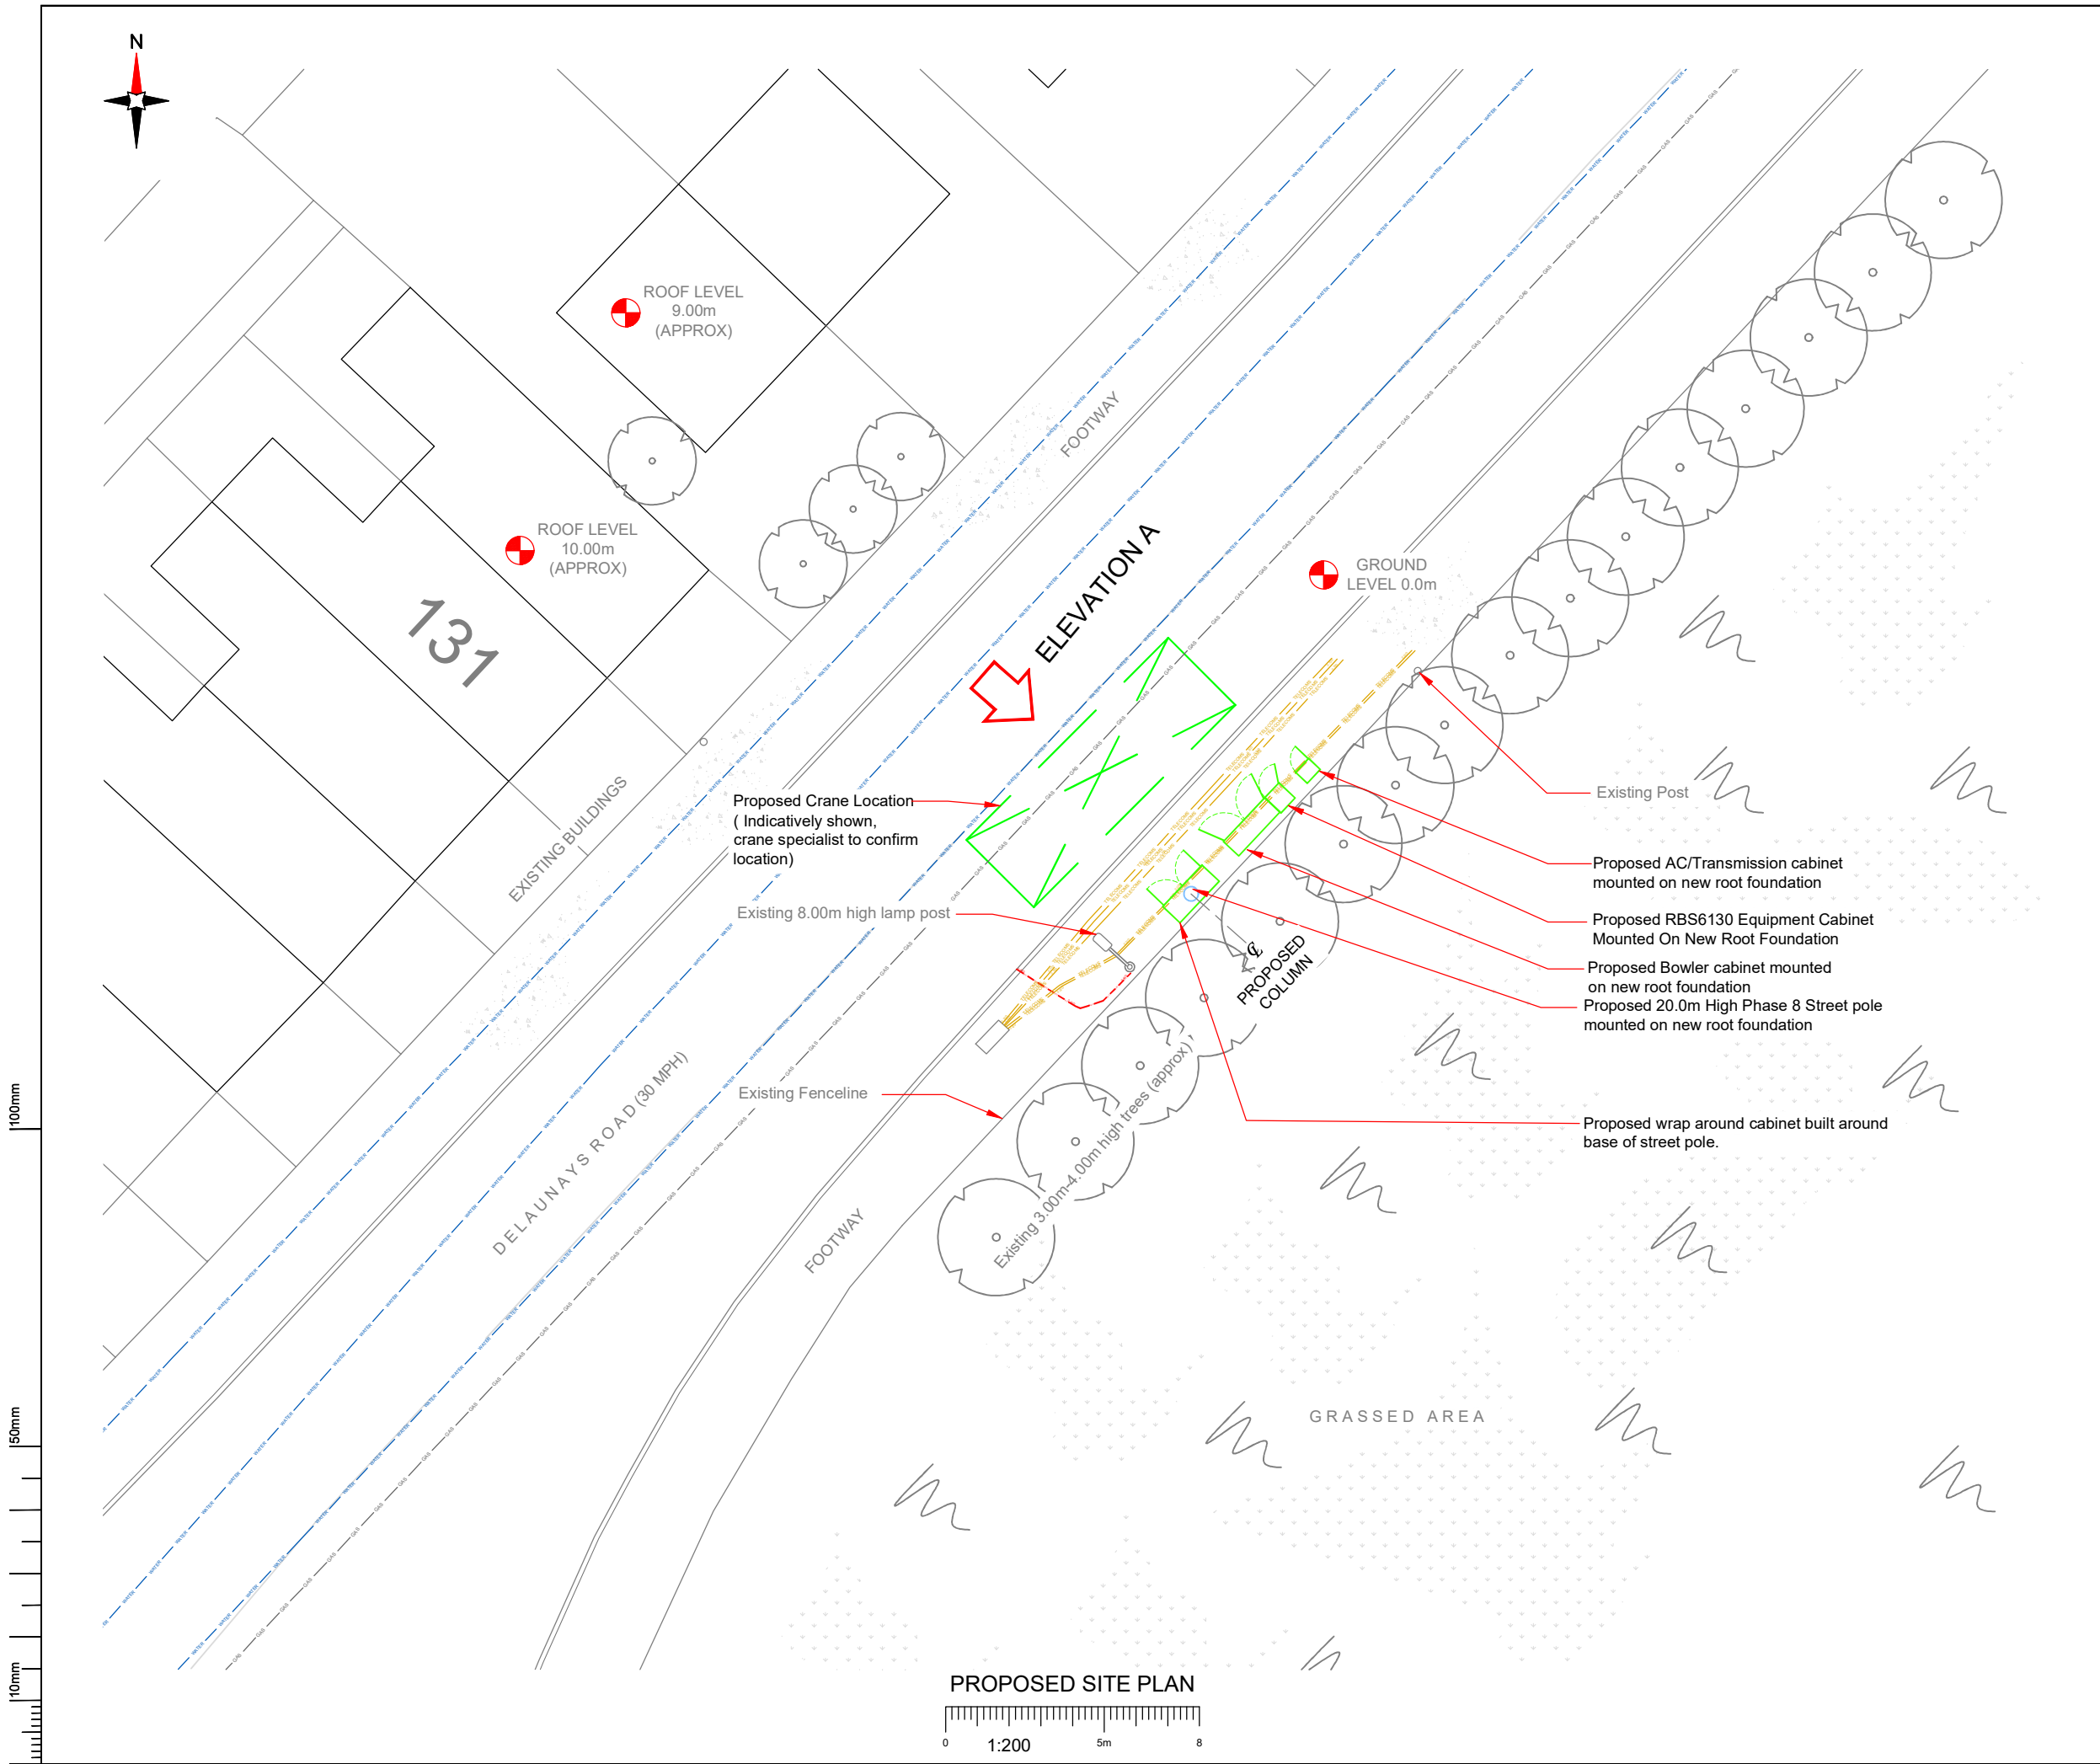

NOTES:
1. ALL DIMENSIONS IN MM UNLESS OTHERWISE NOTED.

SERVICES:

WATER

WATER

WATER

HV

HV

HV

HV

GAS

GAS

GAS

TELECOMS

TELECOMS

ELEC

ELEC

ELEC

ELEC

PROPOSED CRANE OR CHERRY PICKER LOCATION:

NOTES:
Radar Scan and Stats to be reviewed prior to any build works commencing

Master:	MBNL / EE / H3G:	Project:	Purpose of Issue:	Issue:
M001	H3G	DENSIFICATION SW	Planning	A
Date:	17/06/2022	Revision / Upgrade Description:		
Drawn:	S.Booth	First Issue - Site nomination dated: TBC		
Checked:	K.Winland			
Approved:	K.Winland			

Hutchison 3G UK Limited
Green Park, 450 Longwater Avenue
Reading, RG30 3UR
Tel: 01628 765 000
Fax: 01628 765 001

H3G Base Station Information line:
0845 6043000
Available 8am-8pm Monday to Friday

Design Consultant & Principal Contractor:

Unit E, Madison Place, Northampton Road,
Manchester, M40 5AG
Tel: 0161 785 4500 Fax: 0161 785 4501
Web: www.clarke-telecom.com

Site Name:
DELAUNYS ROAD

Site ID:
MAN24790_B35

Address:
NORTH MANCHESTER GENERAL HOSPITAL
131 DELAUNYS ROAD
MANCHESTER
M8 4RE

Title:
210 PROPOSED H3G SITE PLAN


Project:
H3G DENSIFICATION STREETWORKS

Purpose of Issue:
PLANNING

EE Cell ID:	MBNL Cell ID:	3UK Cell ID:
-	-	MAN24790_B35

Master Drawing No:
MAN24790_B35_GA_A

Issue:
A

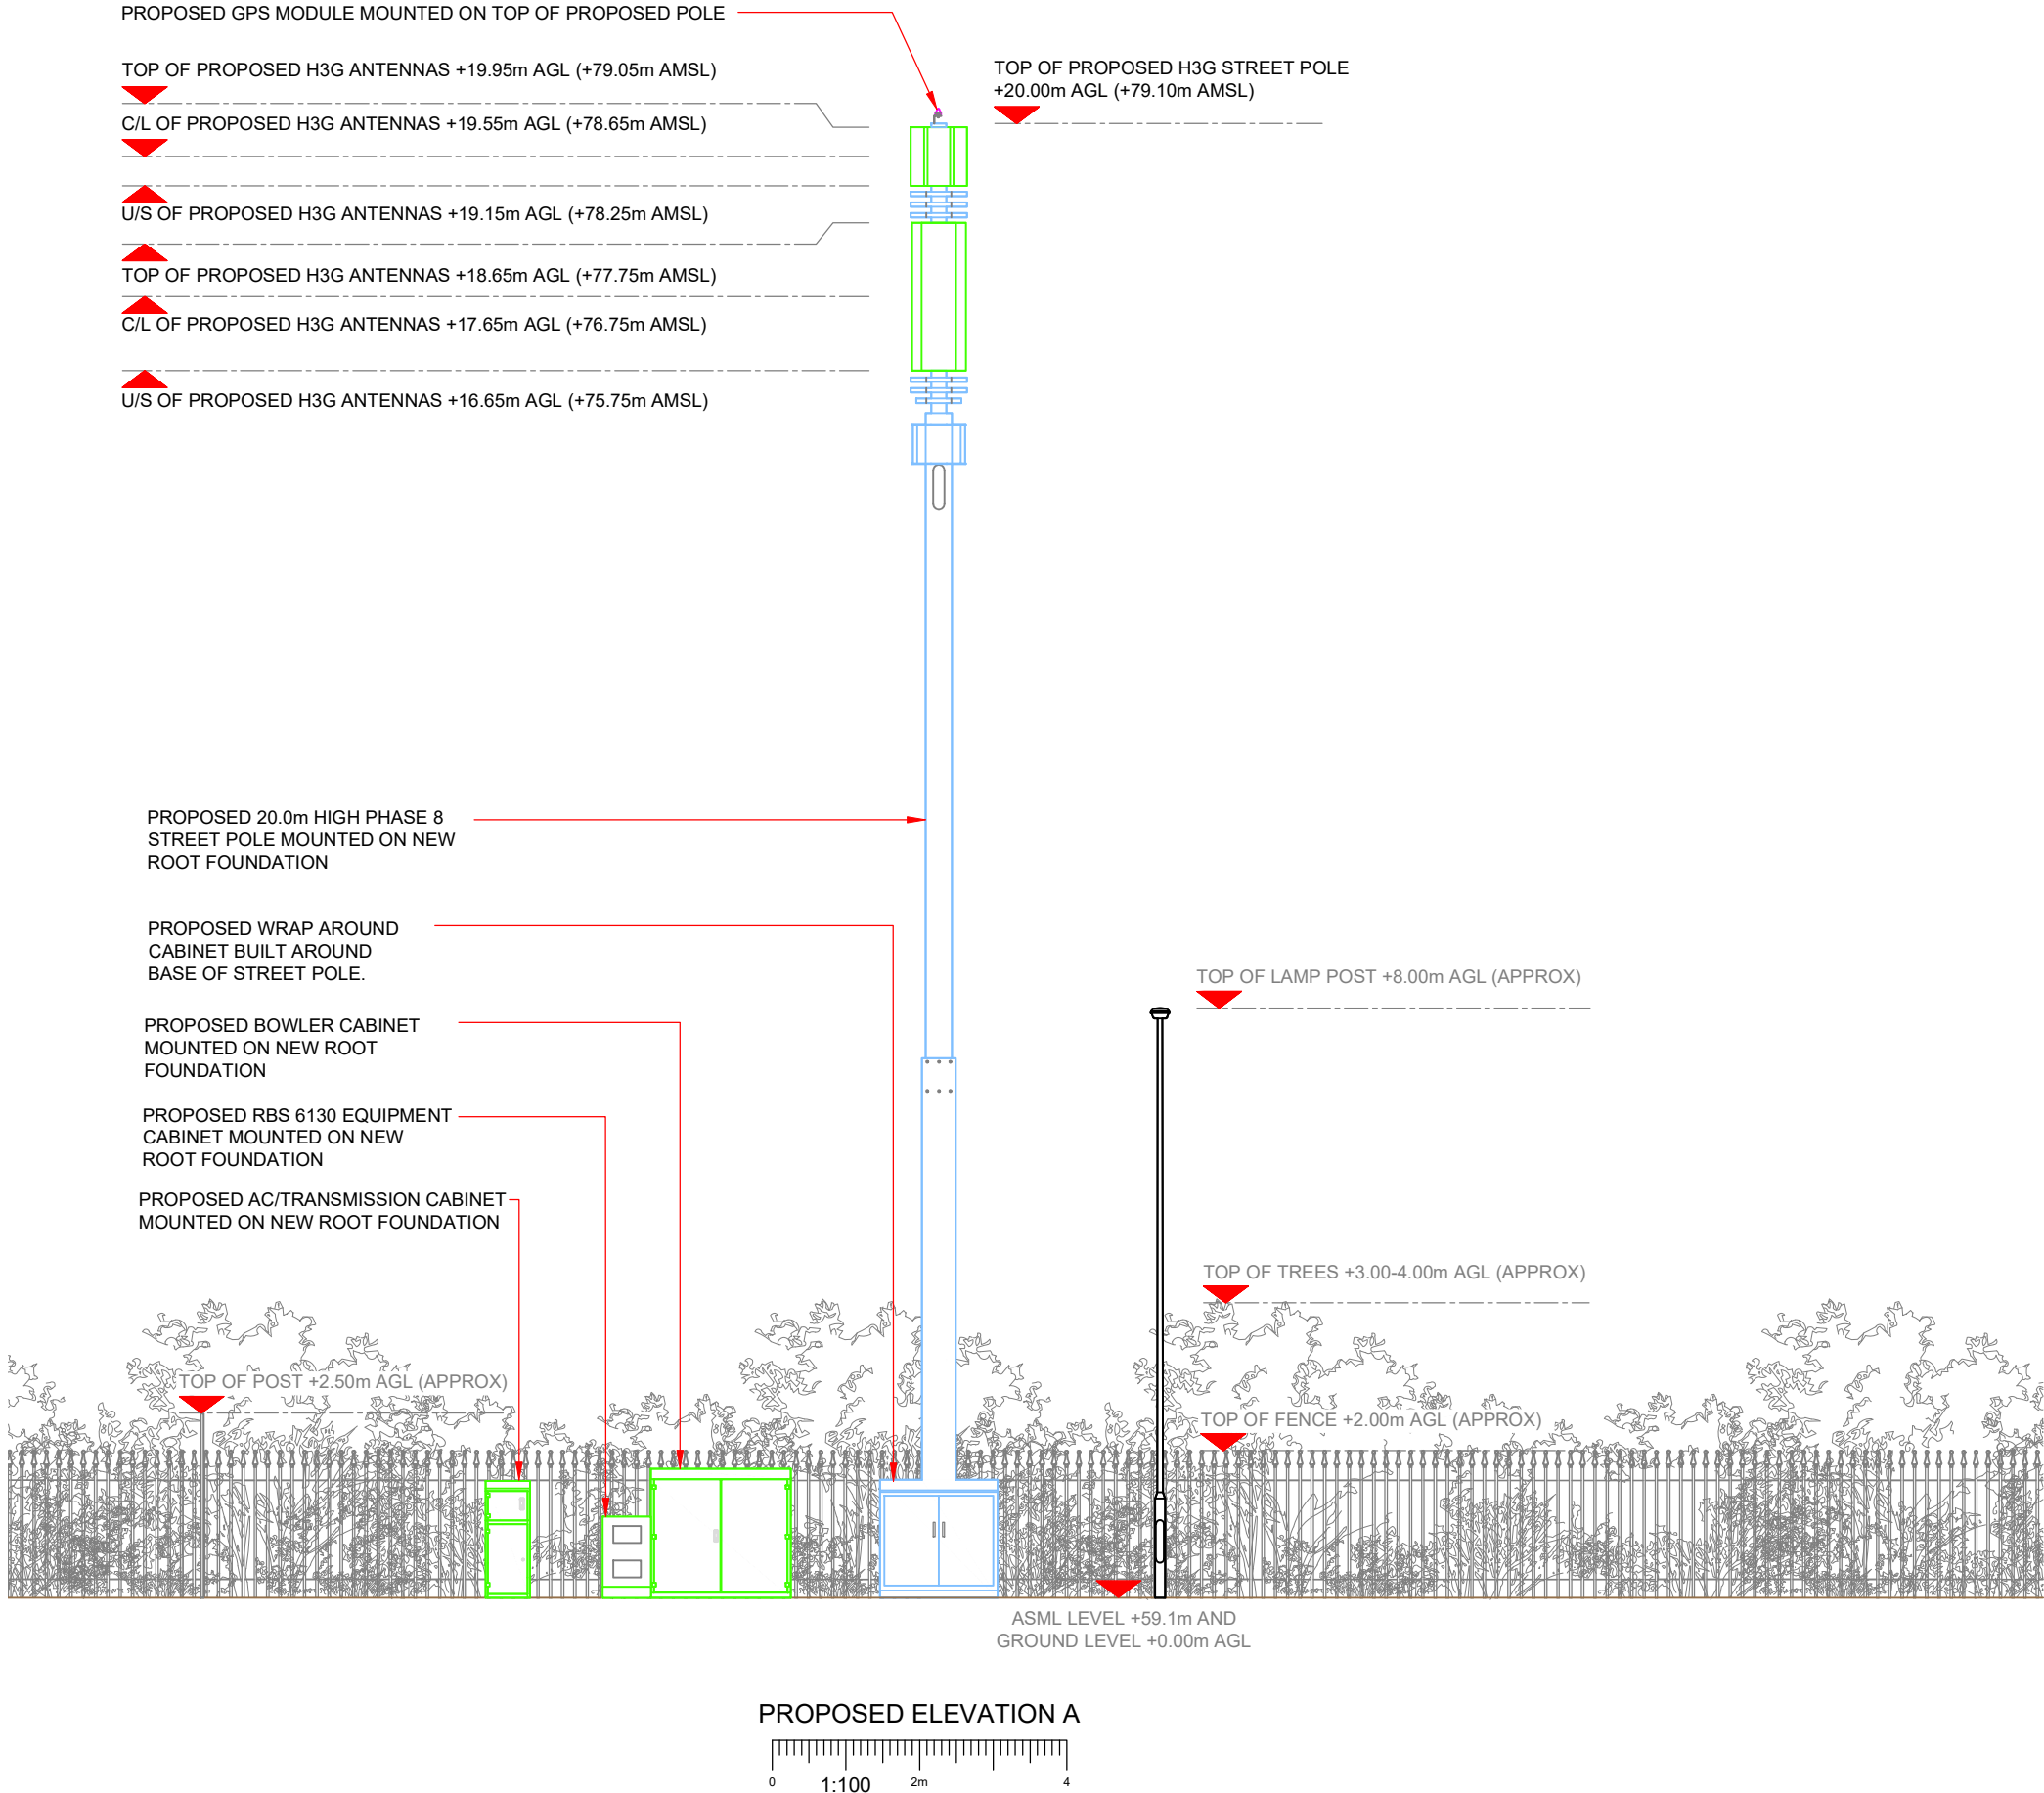

NOTES:
1. ALL DIMENSIONS IN MM UNLESS OTHERWISE NOTED.

Master:	MBNL / EE / H3G:	Project:	Purpose of Issue:	Issue:
M001	H3G	DENSIFICATION SW	Planning	A
Date:	17/06/2022	Revision / Upgrade Description:		
Drawn:	S.Booth	First Issue - Site nomination dated: TBC		
Checked:	K.Winland			
Approved:	K.Winland			



Hutchison 3G UK Limited
Green Park, 450 Longwater Avenue
Reading, RG30 3UR
Tel: 01628 765 000
Fax: 01628 765 001

H3G Base Station Information line:
0845 6043000
Available 8am-8pm Monday to Friday

Design Consultant & Principal Contractor:


Unit E, Madison Place, Northampton Road,
Manchester, M40 5AG
Tel: 0161 785 4500 Fax: 0161 785 4501
Web: www.clarke-telecom.com

Site Name:
DELAUNYS ROAD

Site ID:
MAN24790_B35

Address:
NORTH MANCHESTER GENERAL
HOSPITAL
131 DELAUNYS ROAD
MANCHESTER
M8 4RE

Title:
260 PROPOSED H3G SITE ELEVATION

Project:
H3G DENSIFICATION STREETWORKS

Purpose of Issue:
PLANNING

EE Cell ID:	MBNL Cell ID:	3UK Cell ID:
-	-	MAN24790_B35

Master Drawing No:
MAN24790_B35_GA_A

Issue:
A