

NOTICE

THIS DRAWING INCLUDING THE PRINCIPLES OF DESIGN, REMAINS THE PROPERTY OF HAYVERN ELECTRICAL LTD. AND IS ISSUED ON THE UNDERSTANDING THAT IT IS NOT REPRODUCED OR LOANED IN PART OR WHOLE EXCEPT WITH THE OWNERS WRITTEN CONSENT. IT IS NOT TO BE USED IN ANY MANNER THAT MAY BE DETRIMENTAL TO HAYVERN ELECTRICAL LTD. ACCEPTANCE OF THIS DRAWING WILL BE CONSIDERED AS AN AGREEMENT OF THE ABOVE.

- 

SMALL POWER KEY
- 

DISTRIBUTION BOARD
- 

SINGLE SWITCHED POWER SOCKET
- 

DOUBLE SWITCHED POWER SOCKET
- 

UNSWITCHED SPUR
- 

SWITCHED SPUR
- 


COMMANDO SOCKET
- 

FLOOR BOX
- 

LL CONNECTOR - 1 HDML 3 POWER & 8 DATA OUTLETS
- 

ML CONNECTOR - 1 HDML 2 POWER & 1 DATA OUTLETS
- 

HL CONNECTOR - 1 HDML 8 POWER & 8 DATA OUTLETS

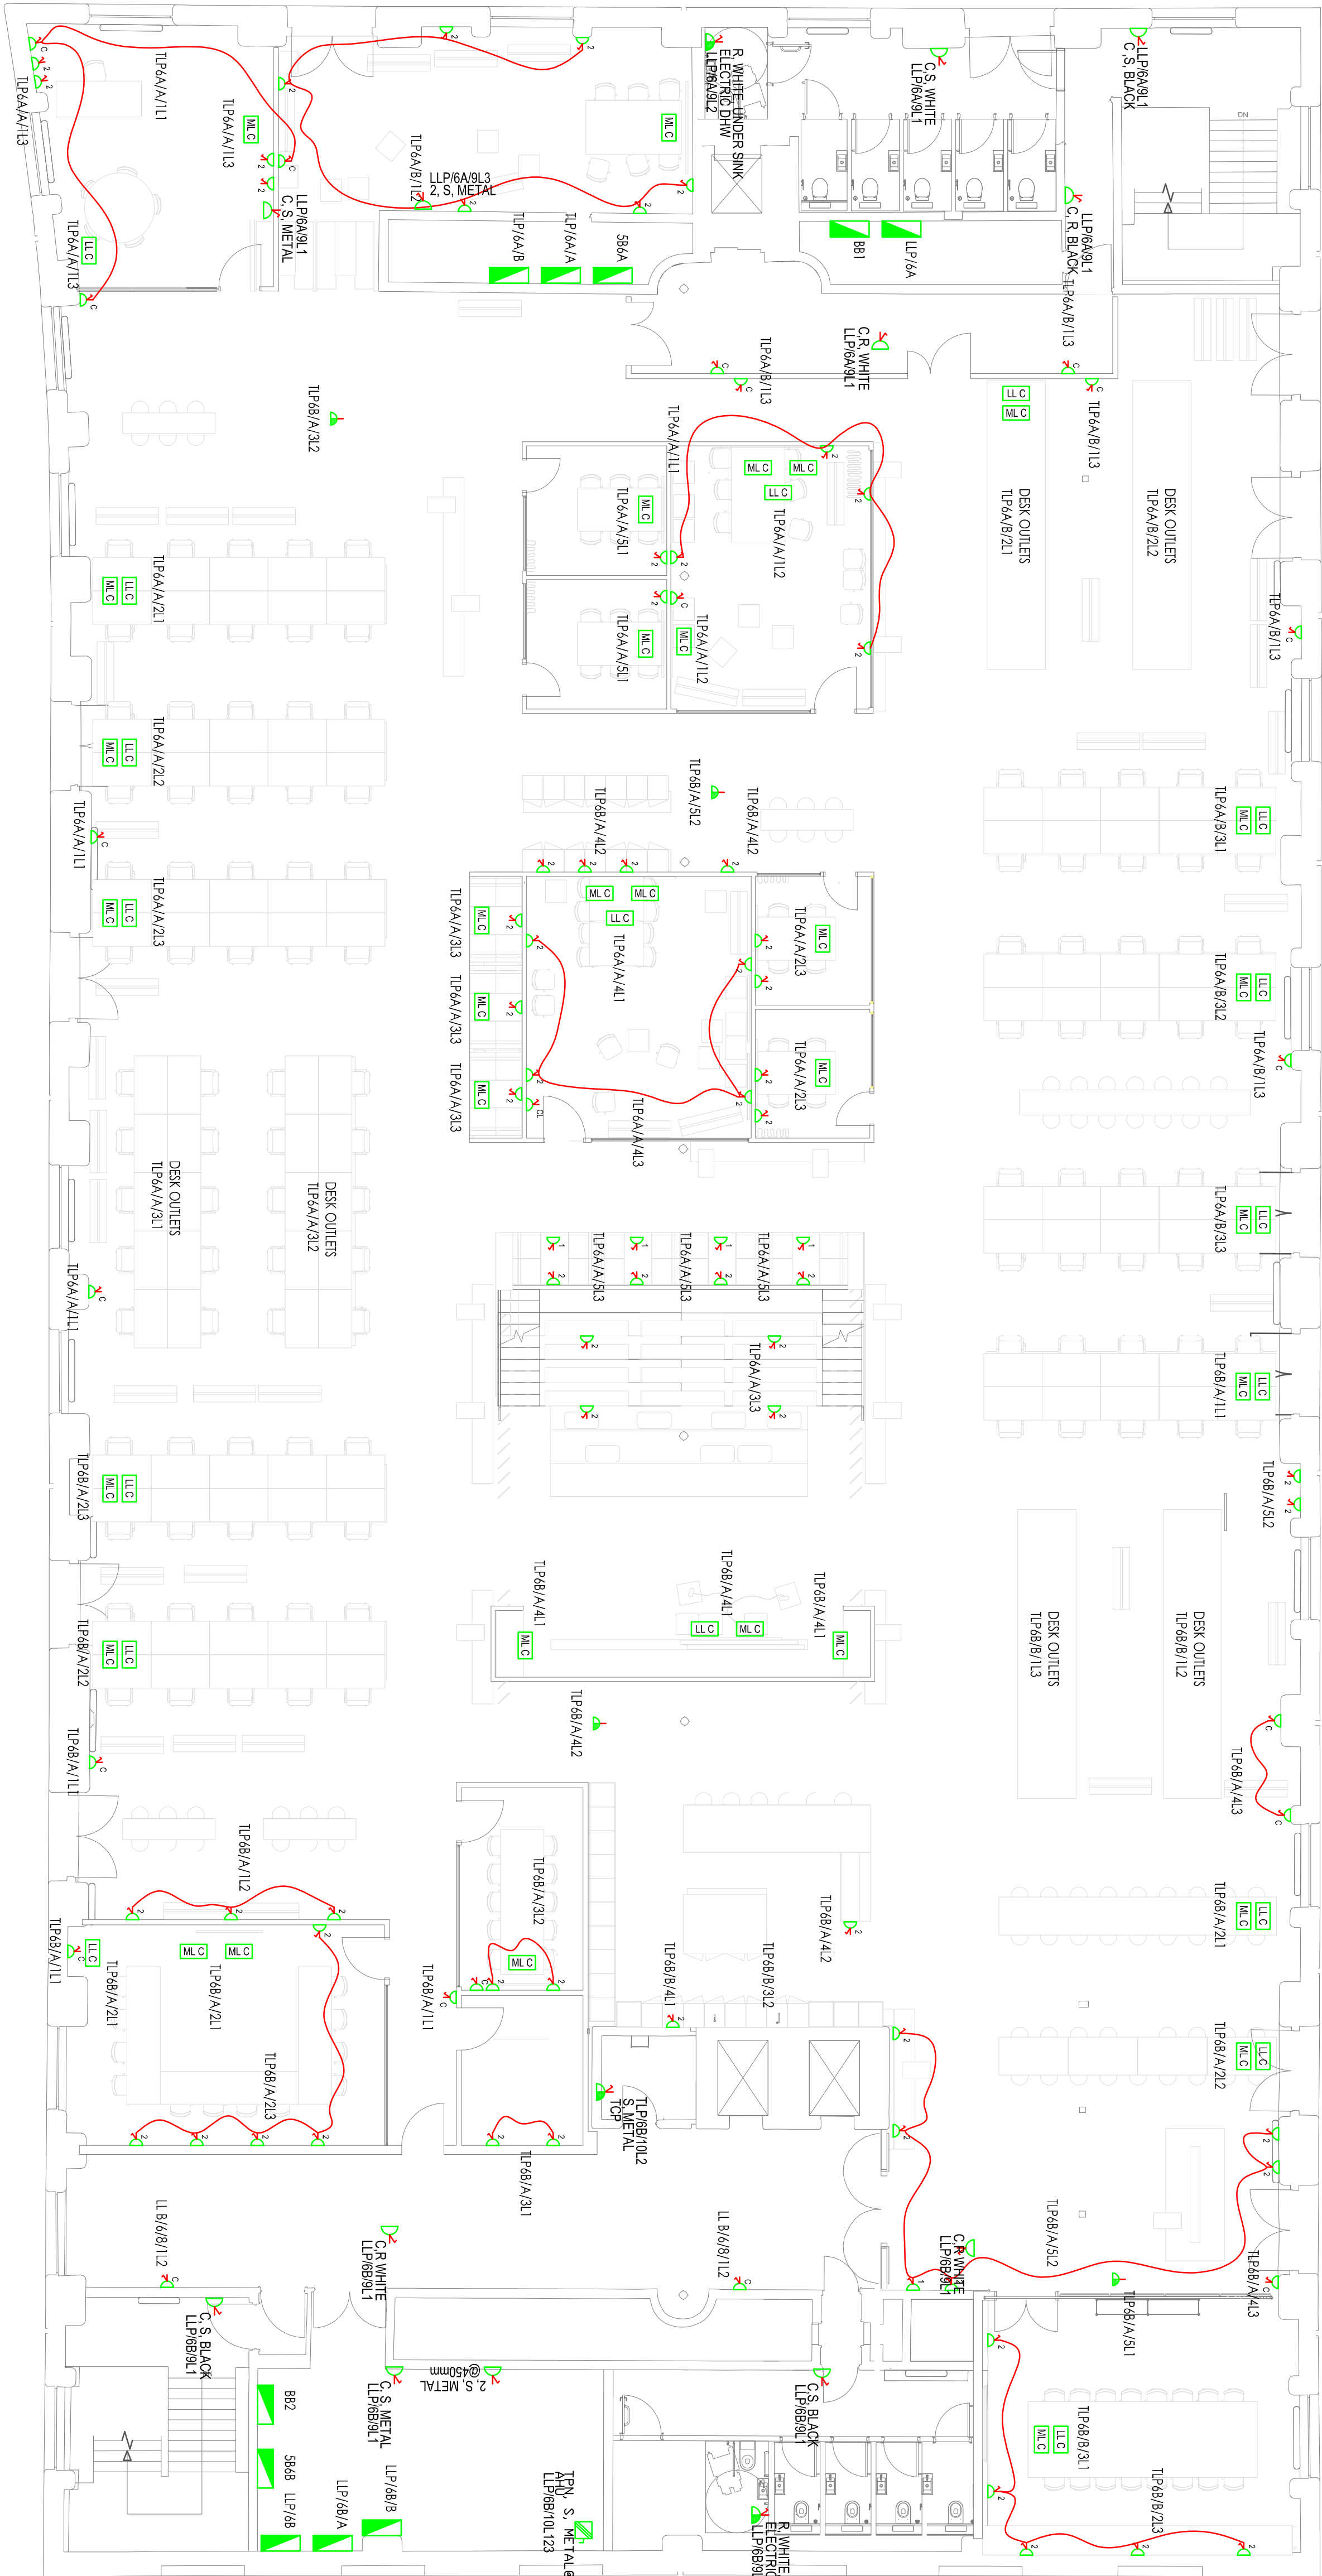

6TH FLOOR - DATA LAYOUT

DRAFT AS FITTED DRAWING

Revisions	Description	Ref	Eng	Date
 56 QUEEN STREET, FARNWORTH, BOLTON, 01204 579975				
ClientMANCHESTER QUAYS LTD				
Project TitleTHE BONDED WAREHOUSE, PHASE 2				
Drawing TitleLEVEL 6 SMALL POWER LAYOUT				
In Association with				
Drawn by	HR	Scales1:100@A1		
Checked by	JM	(work to figured dimensions)		
Date	SEPT 19			
DRG No.	E004	Rev. A/F1		