

© This drawing and its contents are strictly the copyright of GLD



Certificate Number 16602-Q15-001
ISO 9001

LEGEND



HRU Mitsubishi Lossnay LGH100RVX-E



HRU Mitsubishi Lossnay LGH65RVX-E



HRU Mitsubishi Lossnay LGH50RVX-E



Comfort conditioner 4 way blow recessed unit PLTY 100VEM-E



Extract grille



Supply grille



Extract valve



Supply valve



Extractor fan



Plenum box with louver

T3	27.01.2022	Add 3 x (600mm x 600mm) grilles Revised ductwork & Plenum box Amended Louvre size	BP	PC
T2	13.01.2022	Modified duct sizing to fit under beam	RW	PC
T1	11.05.2021	Grilles modified	RW	PC
P3	27.11.2020	Updated to suit co-ordinated drawing	VG	PC
P2	16.10.2020	Updated to suit new layout	VG	PC
P1	31.07.2020	Preliminary Issue	RW	PC
Rev:	Date:	Amendment:	Drawn:	Check:
Drwn:	VG	Date: 27.11.2020	Scale: 1:100 @ A3	
Chkd:	PC	Date: 27.11.2020	X Ref: 4050 - GA Club Base	

Client:



Project Title:
The Whitehouse Club

Drawing Title:
First Floor
HVAC Layout


Status:
TENDER



Damhouse, Astley Hall Drive
Astley, Manchester, M29 7TX
W: www.gldtechnicalconsulting.co.uk
T: 01942889535 / 01616417097

Drawing No:
J115-GLD-00-DR-M-5700-002

Rev:
T3

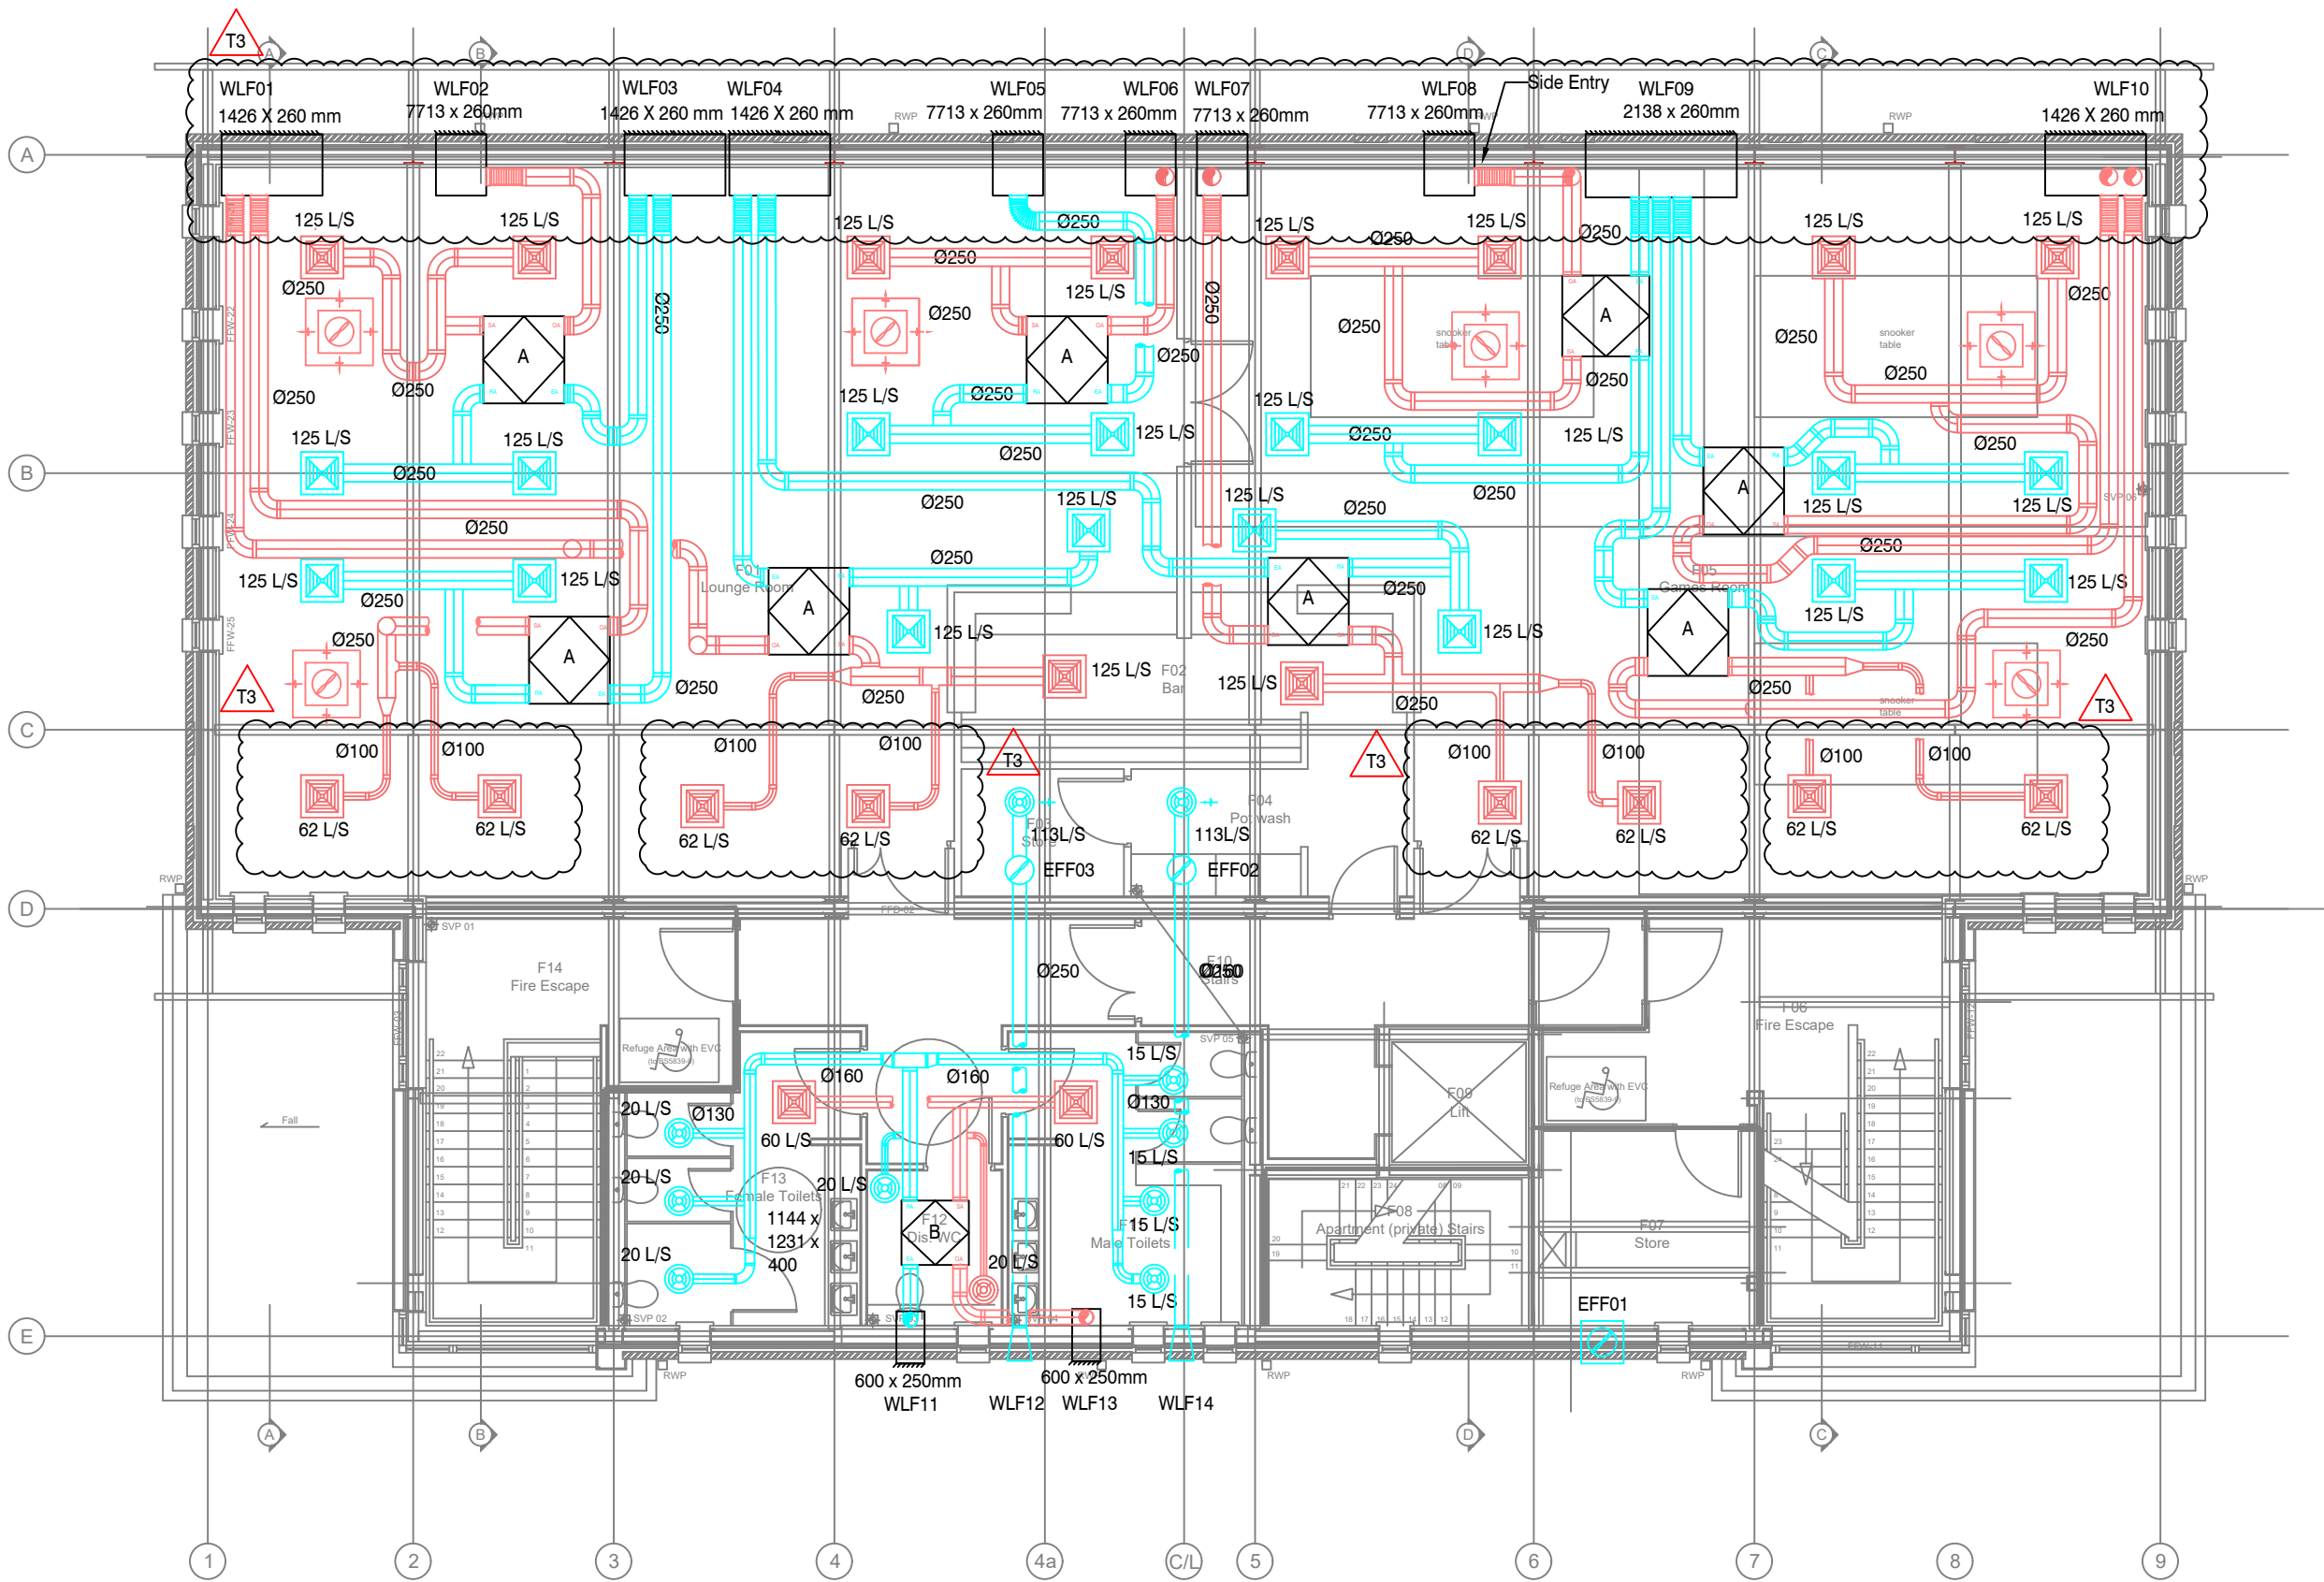

GENERAL NOTES

- Drawings are to be read in conjunction with all relevant specifications, engineers, architects & services drawings, including approved builders work drawings. Contractor to notify engineer of discrepancies between structural drawings & specifications or other drawings.
- All dimensions are in millimeters unless noted otherwise.
- Do not scale from the drawings or the computer digital data, only figured dimensions are to be used.