


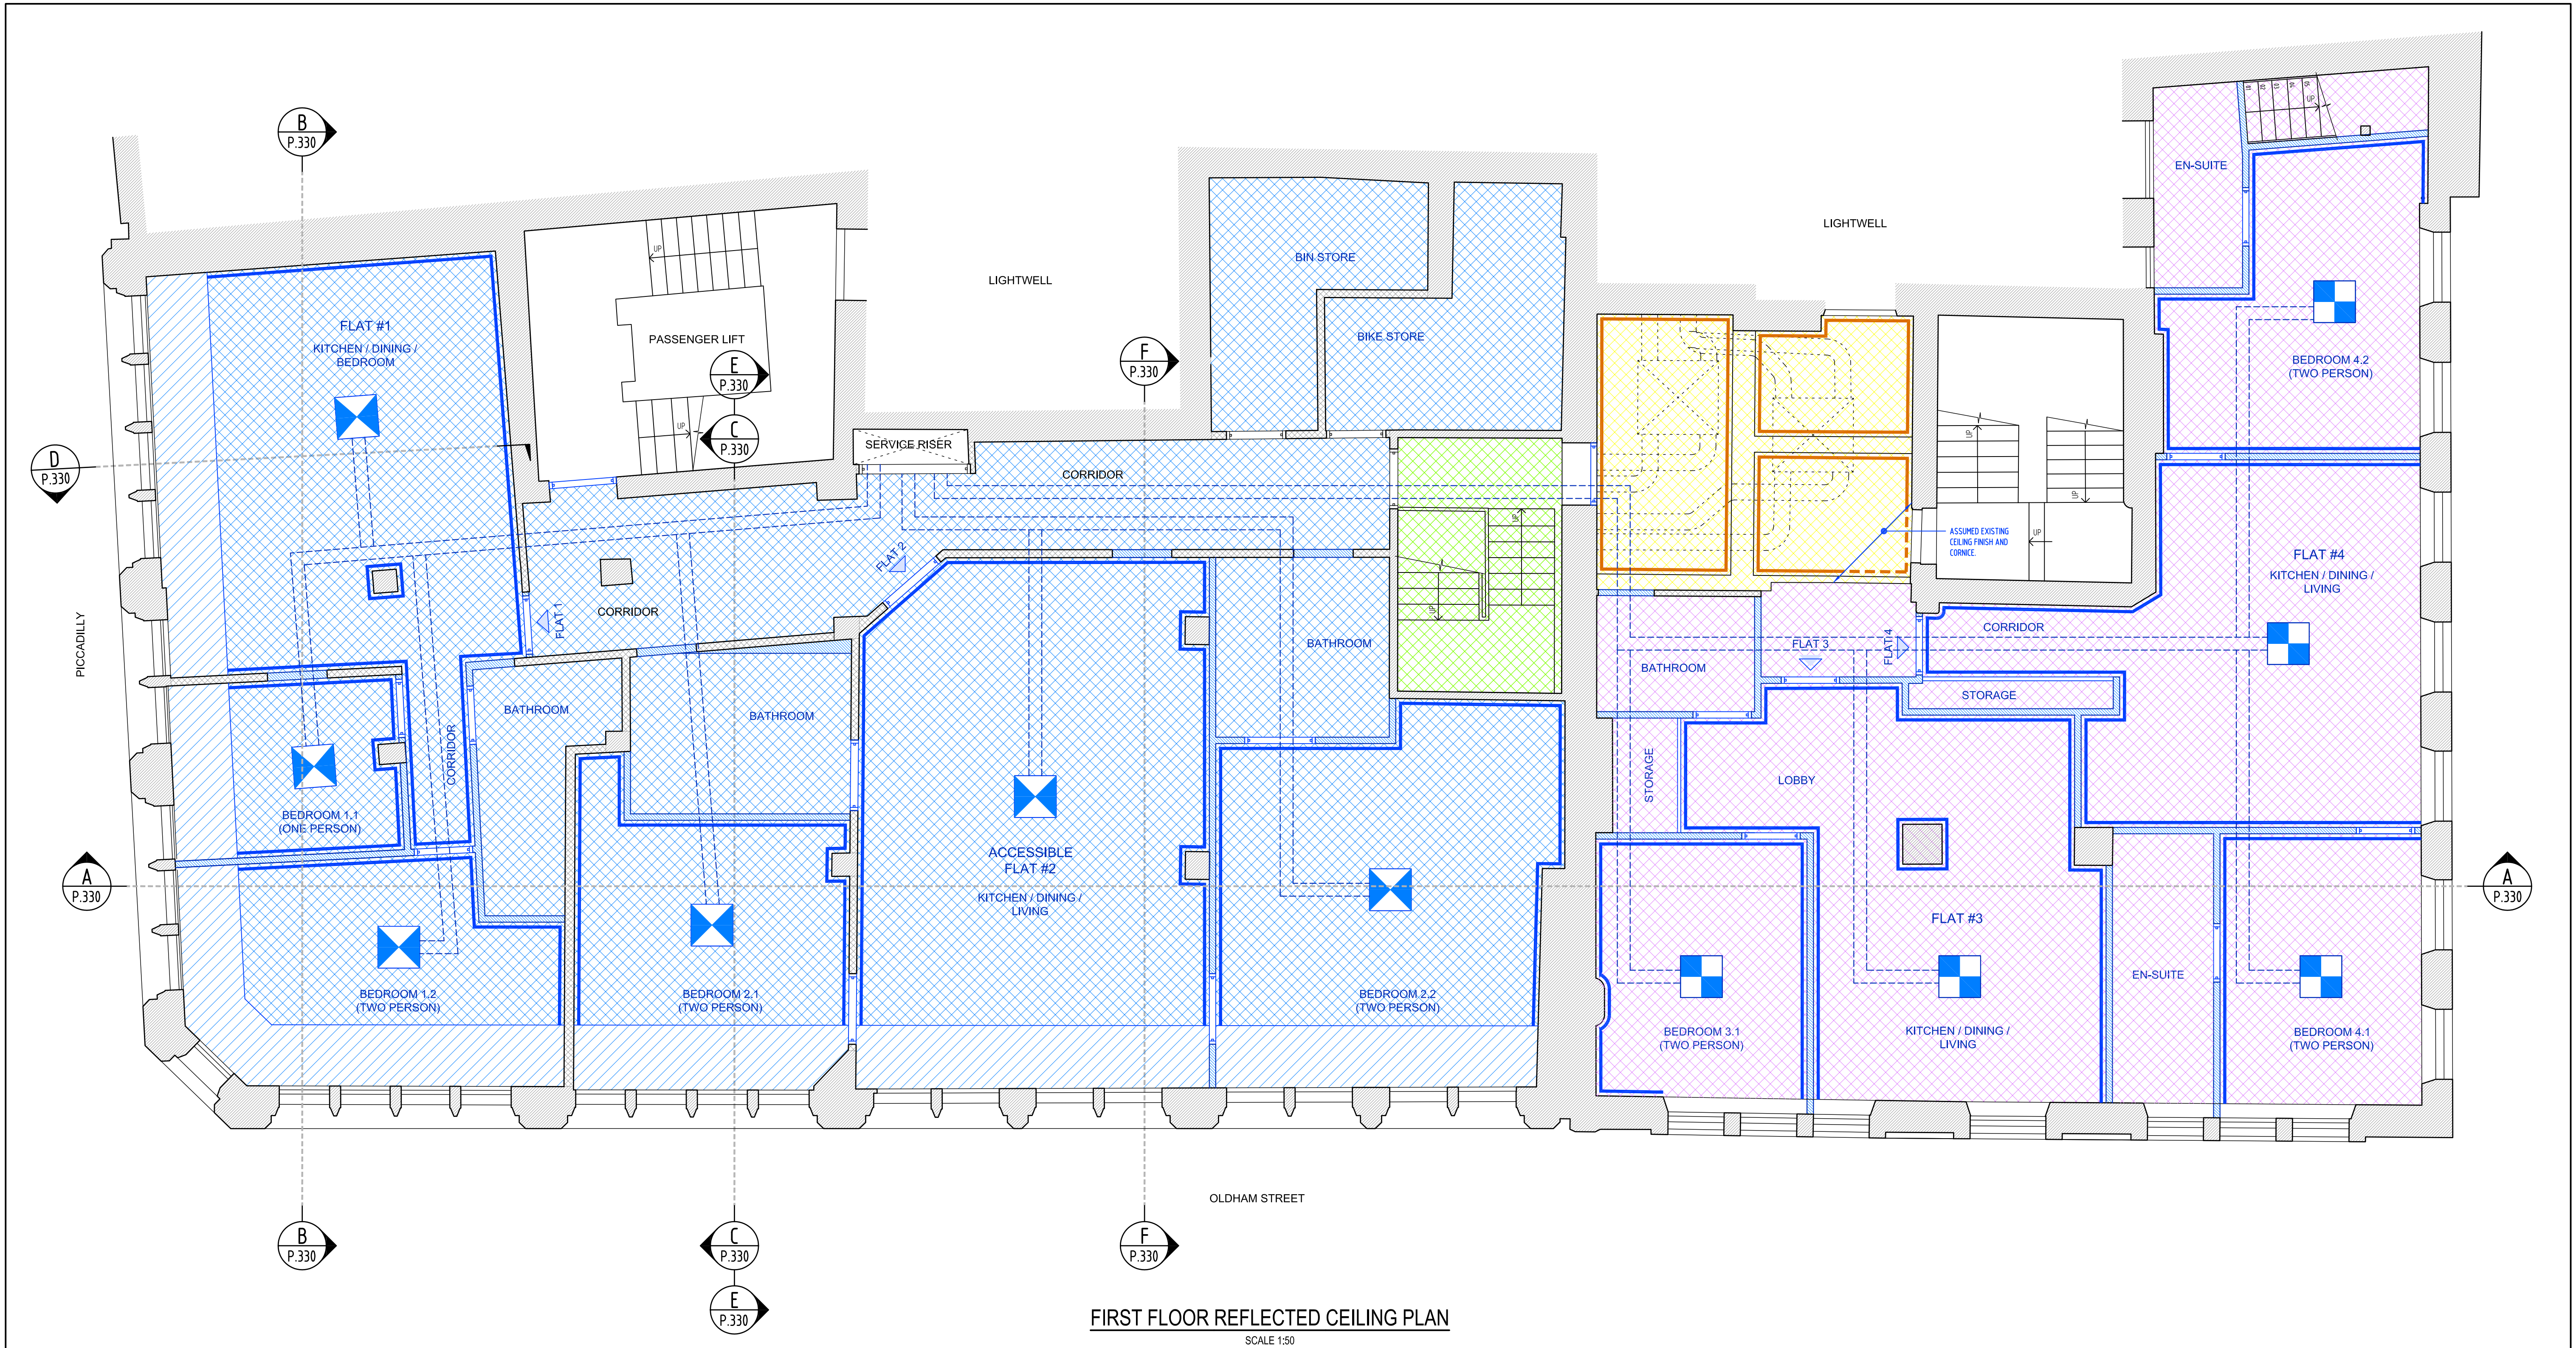

FIRST FLOOR REFLECTED CEILING PLAN
SCALE 1:50

LEGEND:

 
	DENOTES ORIGINAL EXISTING WALL		DENOTES PLASTERBOARD CEILING
	DENOTES NON-ORIGINAL EXISTING WALL		DENOTES RECESSED PLASTERBOARD CEILING
	DENOTES PROPOSED WORKS		DENOTES SUSPENDED CEILING (600x600 GRID SYSTEM)
	DENOTES MECHANICAL VENTILATION INCLUDING COOLING. PIPE RUNS SHOWN INDICATIVELY.		DENOTES FIRE RESISTANT PLASTERBOARD CEILING
	DENOTES EXPOSED MECHANICAL VENTILATION INCLUDING COOLING. PIPE RUNS SHOWN INDICATIVELY.		DENOTES TIGHTLY-ATTACHED CEILING
			DENOTES EXISTING CORNICE
			DENOTES PROPOSED CORNICE

NOTE: ALL CEILING FINISHES AND WALLS HAVE BEEN DETERMINED BY NON-INTRUSIVE VISUAL INSPECTION.

NOTES

- GENERAL:
 - DO NOT SCALE FROM THIS DRAWING. CHECK ALL DIMENSIONS AND CONDITIONS ON SITE.
 - ALL WORKS TO BE CARRIED OUT IN ACCORDANCE WITH CURRENT HEALTH & SAFETY (INCLUDING CDM) REGULATIONS. ALL WORKS TO COMPLY WITH CURRENT BRITISH STANDARDS, CODES OF PRACTICE, BUILDING REGULATIONS AND APPROPRIATE EUROPEAN STANDARDS.
 - ALL STRUCTURAL WORK IS TO BE CARRIED OUT IN ACCORDANCE WITH THE STRUCTURAL ENGINEER'S DETAILS AND CALCULATIONS.
 - PRECISE POSITIONS OF ALL FIXTURES AND FITTINGS IS SUBJECT TO CONFIRMATION ON SITE.
 - THIS DRAWING IS PRODUCED FOR PLANNING APPLICATION ONLY AND SHOULD NOT BE USED FOR ANY OTHER PURPOSES.

SCALE BAR
(1:50 @ A1)
(1:100 @ A3)



REV	DATE	DESCRIPTION	IP	BY
A	26/06/21	DRAWING REVISED		
DRG STATUS				
PLANNING				
DRAWN BY				
ISP DRAWING SOLUTIONS				

JOB TITLE	YORKSHIRE BUILDING SOCIETY 17 PICCADILLY, MANCHESTER
DRG TITLE	SCHEME C - PROPOSED FIRST FLOOR REFLECTED CEILING PLAN

		ISP DRAWING SOLUTIONS 21 MONKS CLOSE MIDDLESEX HA4 9HX TEL: 0044 7886 116912 EMAIL: info@ispdrawingsolutions.co.uk www.ispdrawingsolutions.co.uk					
JOB NO	1192	DRG NO	P.310	REV	A	SCALE	1:50 • A1 1:100 • A3
						DRN	DATE
						IP	04/2021