


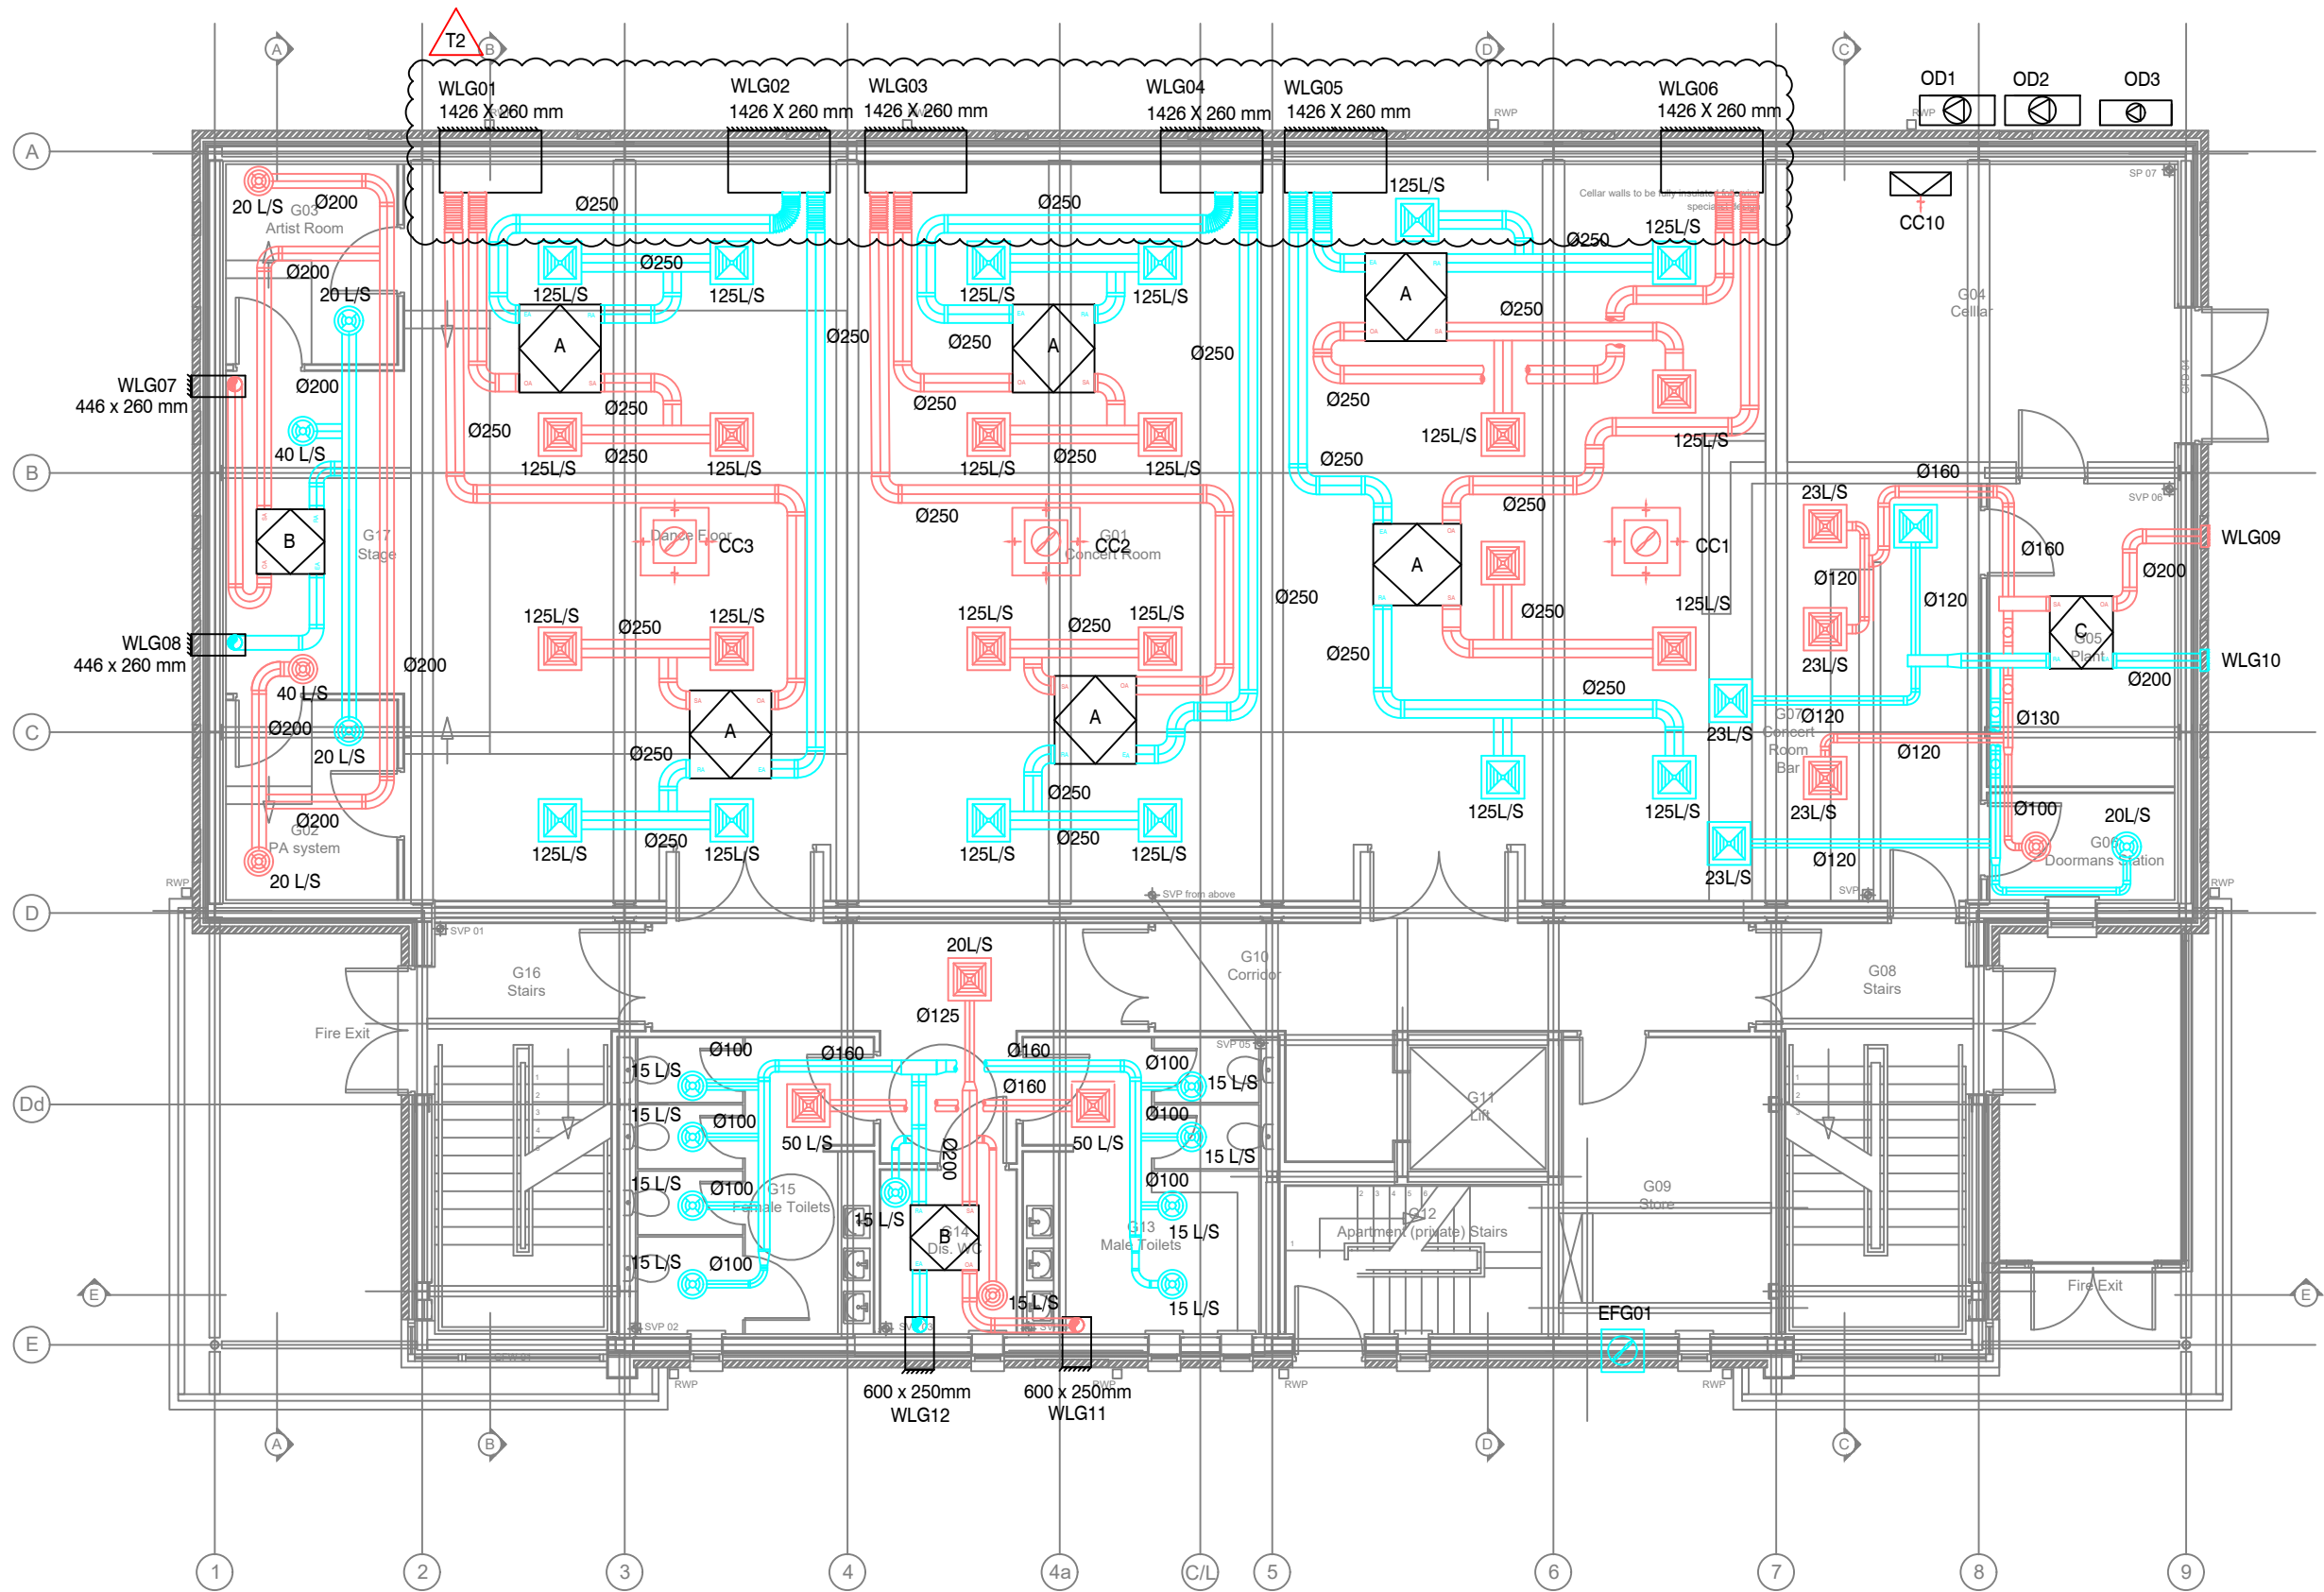

GENERAL NOTES

- Drawings are to be read in conjunction with all relevant specifications, engineers, architects & services drawings, including approved builders work drawings. Contractor to notify engineer of discrepancies between structural drawings & specifications or other drawings.
- All dimensions are in millimeters unless noted otherwise.
- Do not scale from the drawings or the computer digital data, only figured dimensions are to be used.

© This drawing and its contents are strictly the copyright of GLD



Certificate Number 16602-Q15-001
ISO 9001

LEGEND

- A HRU Mitsubishi Lossnay LGH100RVX-E
- B HRU Mitsubishi Lossnay LGH65RVX-E
- C HRU Mitsubishi Lossnay LGH50RVX-E
- Comfort conditioner 4 way blow recessed unit PLTY 100VEM-E
- Extract grille
- Supply grille
- Extract valve
- Supply valve
- Extractor fan
- Plenum box with louver
- OD* Outdoor Condensing unit
- CC10 Comfort conditioner (beer cellar)

T2	27.01.2022	Revised ductwork & Plenum box Amended Louvre size	BP	PC
T1	11.05.2021	Grilles modified	RW	PC
P3	27.11.2020	Updated to suit co-ordinated drawing	VG	PC
P2	16.10.2020	Updated to suit revised layout.	VG	PC
P1	30.07.2020	Preliminary Issue	RW	PC
Rev:	Date:	Amendment:	Drawn:	Check:
Drwn:	RW	Date: 30.07.2020	Scale: 1:100 @ A3	
Chkd:	PC	Date: 30.07.2020	X Ref: 4050 - GA Club Base	

Client:



Project Title:
The Whitehouse Club

Drawing Title:
Ground Floor
HVAC Layout

Status:
TENDER



Drawing No:
J115-GLD-00-DR-M-5700-001

Rev:
T2