


LEGEND	
SYMBOL	DESCRIPTION
	15A UNSWITCHED SINGLE SOCKET OUTLET (1 DENOTES REFERENCE)
	2NO SINGLE RJ45 DATA OUTLETS

ABBREVIATIONS	
CL	CLEANERS SOCKET
HL	HIGH LEVEL (SOFT MOUNTED)
LL	LOW LEVEL (450mm AFFL)

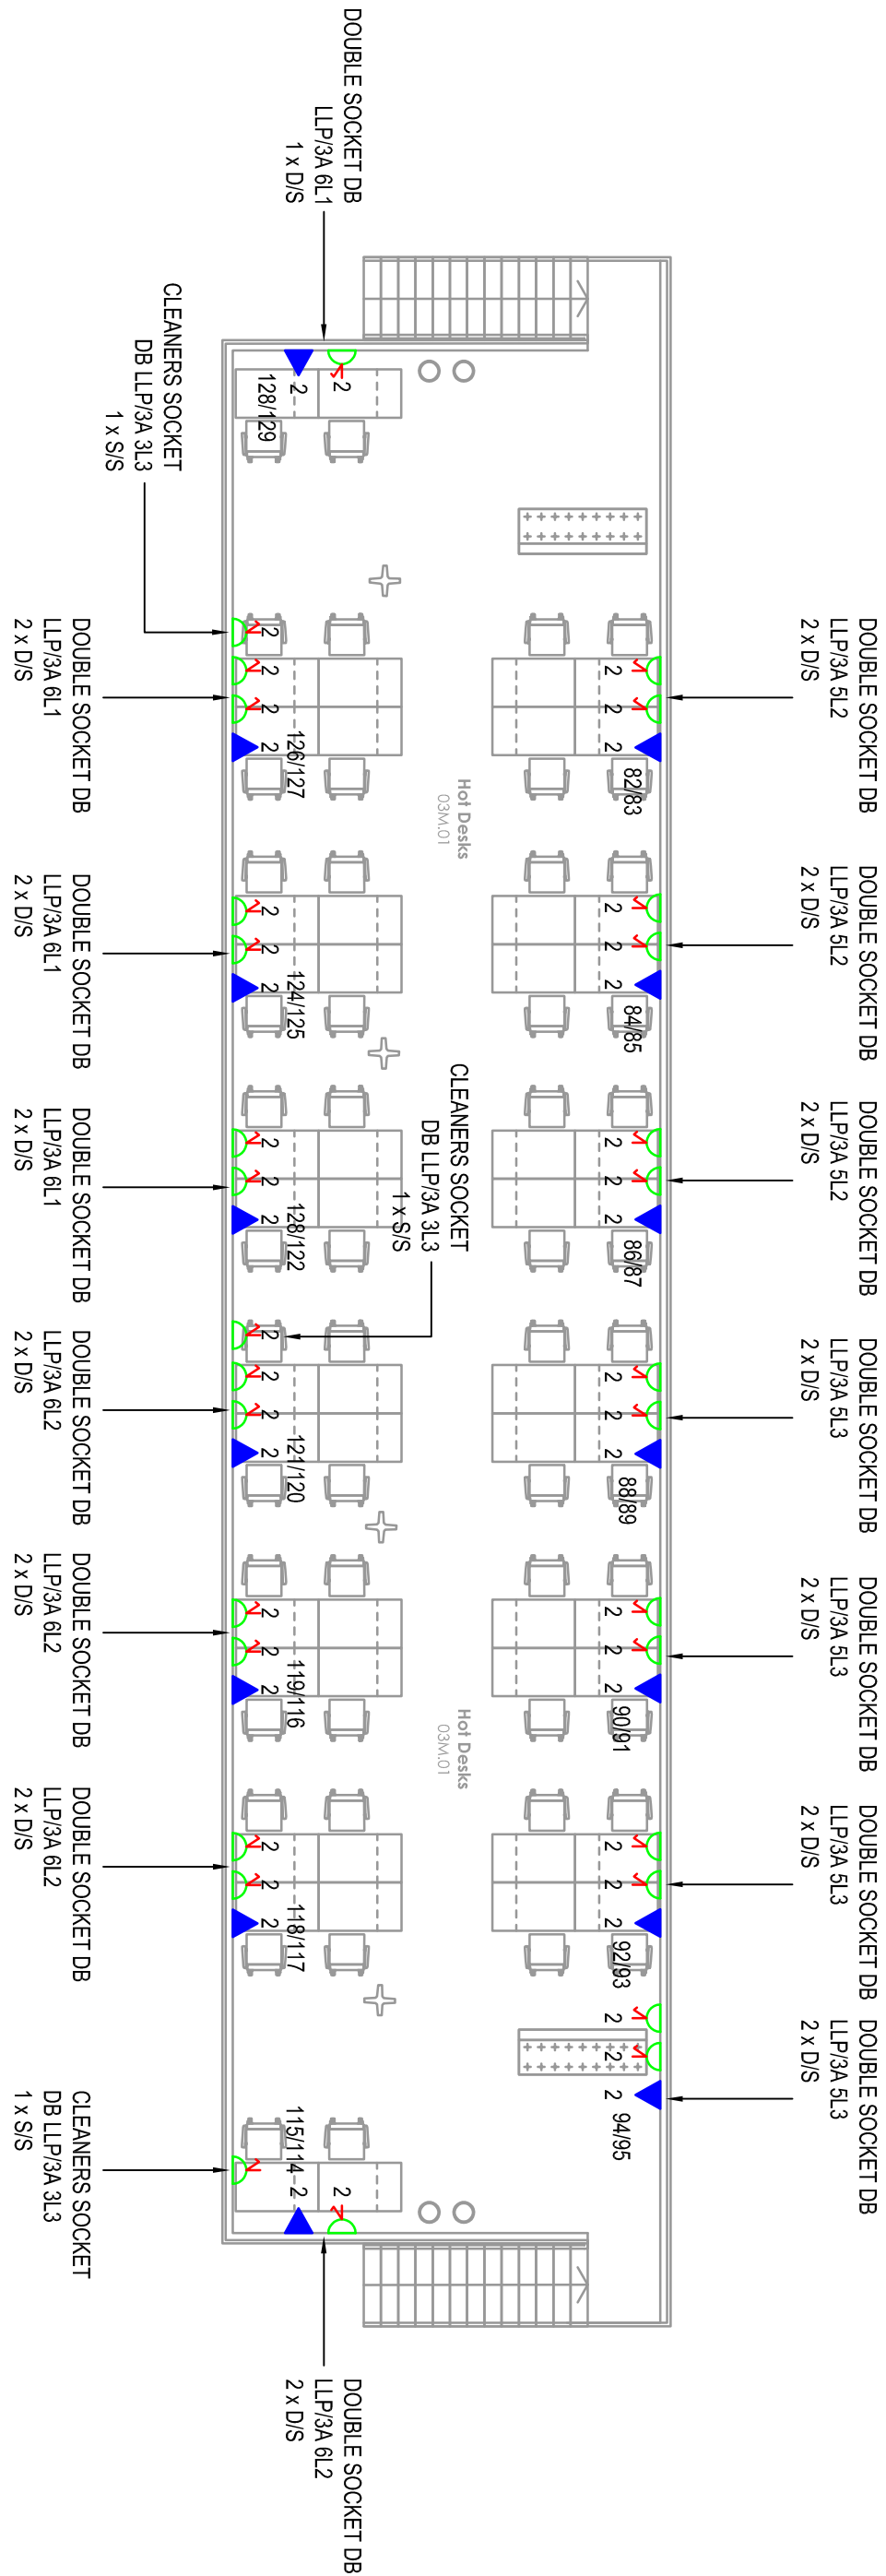

AS FITTED DRAWING

Revisions		Description	Ref	Eng	Date
 • INDUSTRIAL • COMMERCIAL • DOMESTIC HAYVERN ELECTRICAL LTD 56 QUEEN STREET, FARNWORTH, BOLTON, 01204 579975					
Client		MANCHESTER QUAYS LTD			
Project Title		THE BONDED WAREHOUSE, PHASE 2			
Drawing Title		LEVEL 3 – MEZZANINE SMALL POWER AND DATA LAYOUT			
In Association with					
Drawn by		HR	Scales 1:100@A1		
Checked by		JM	(work to figured dimensions)		
Date		JUNE 19			
DRG No.		1799-03-6202	Rev. A/F1		