




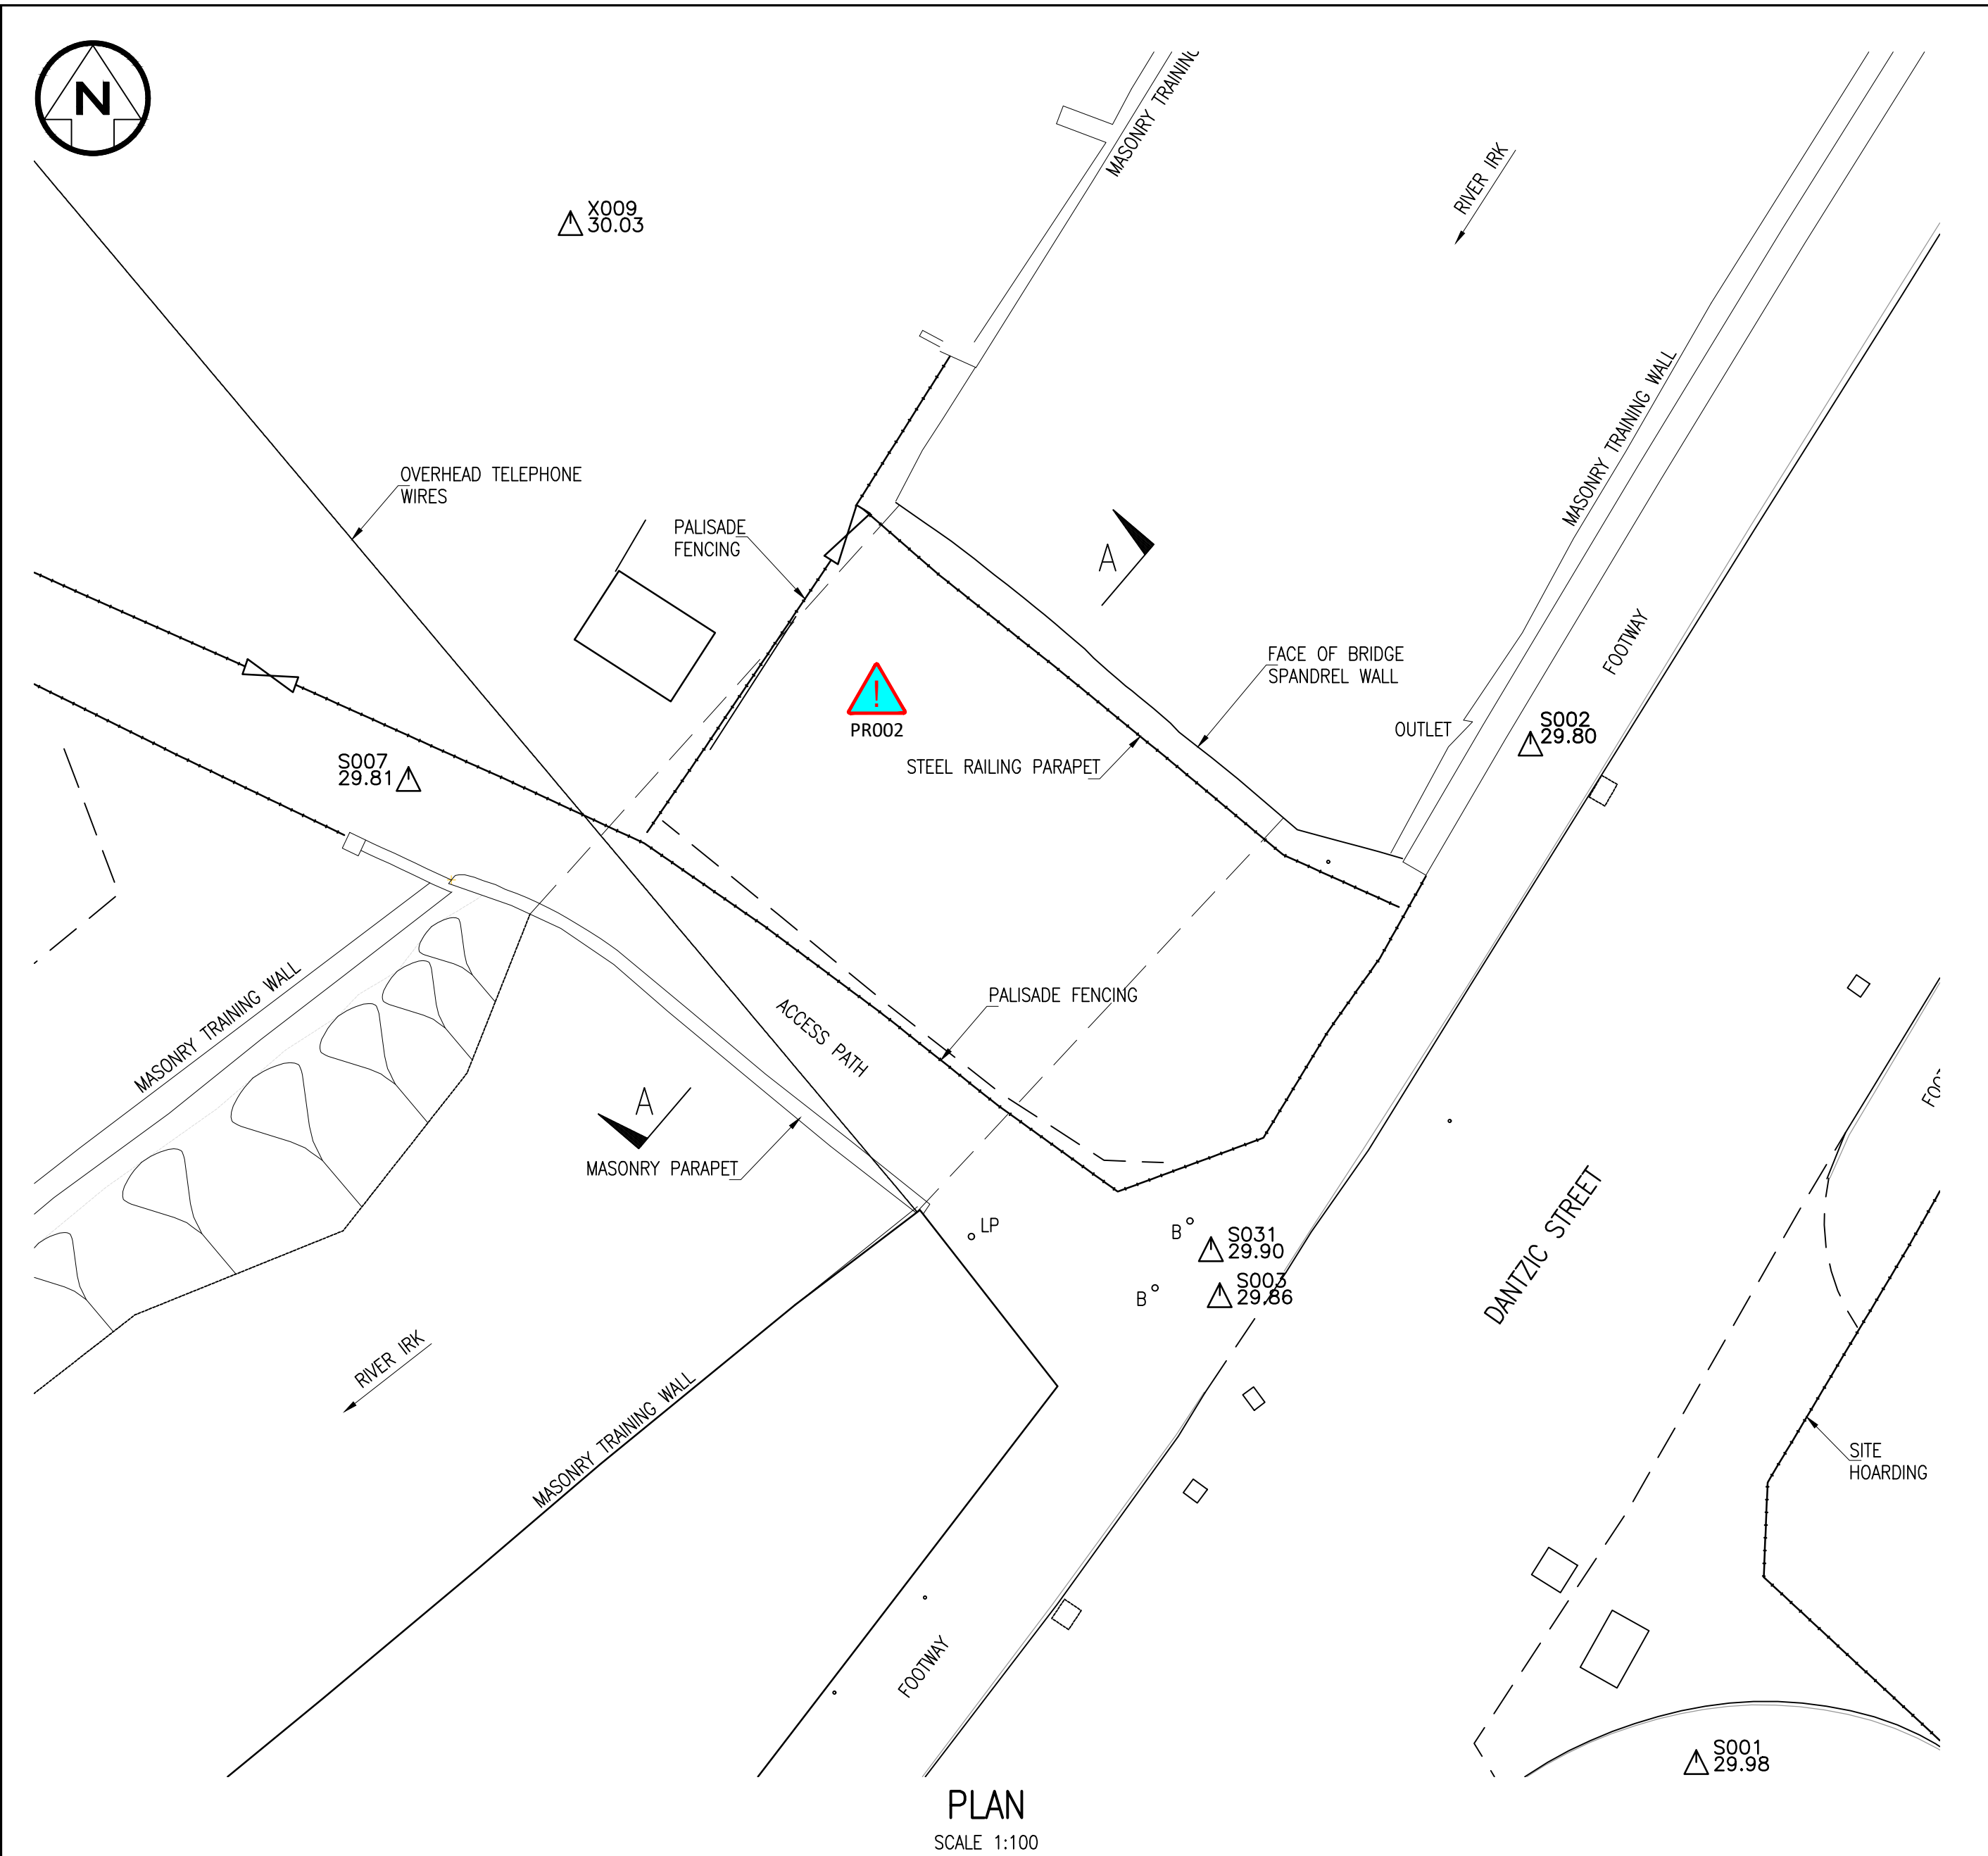


PLAN
SCALE 1:100

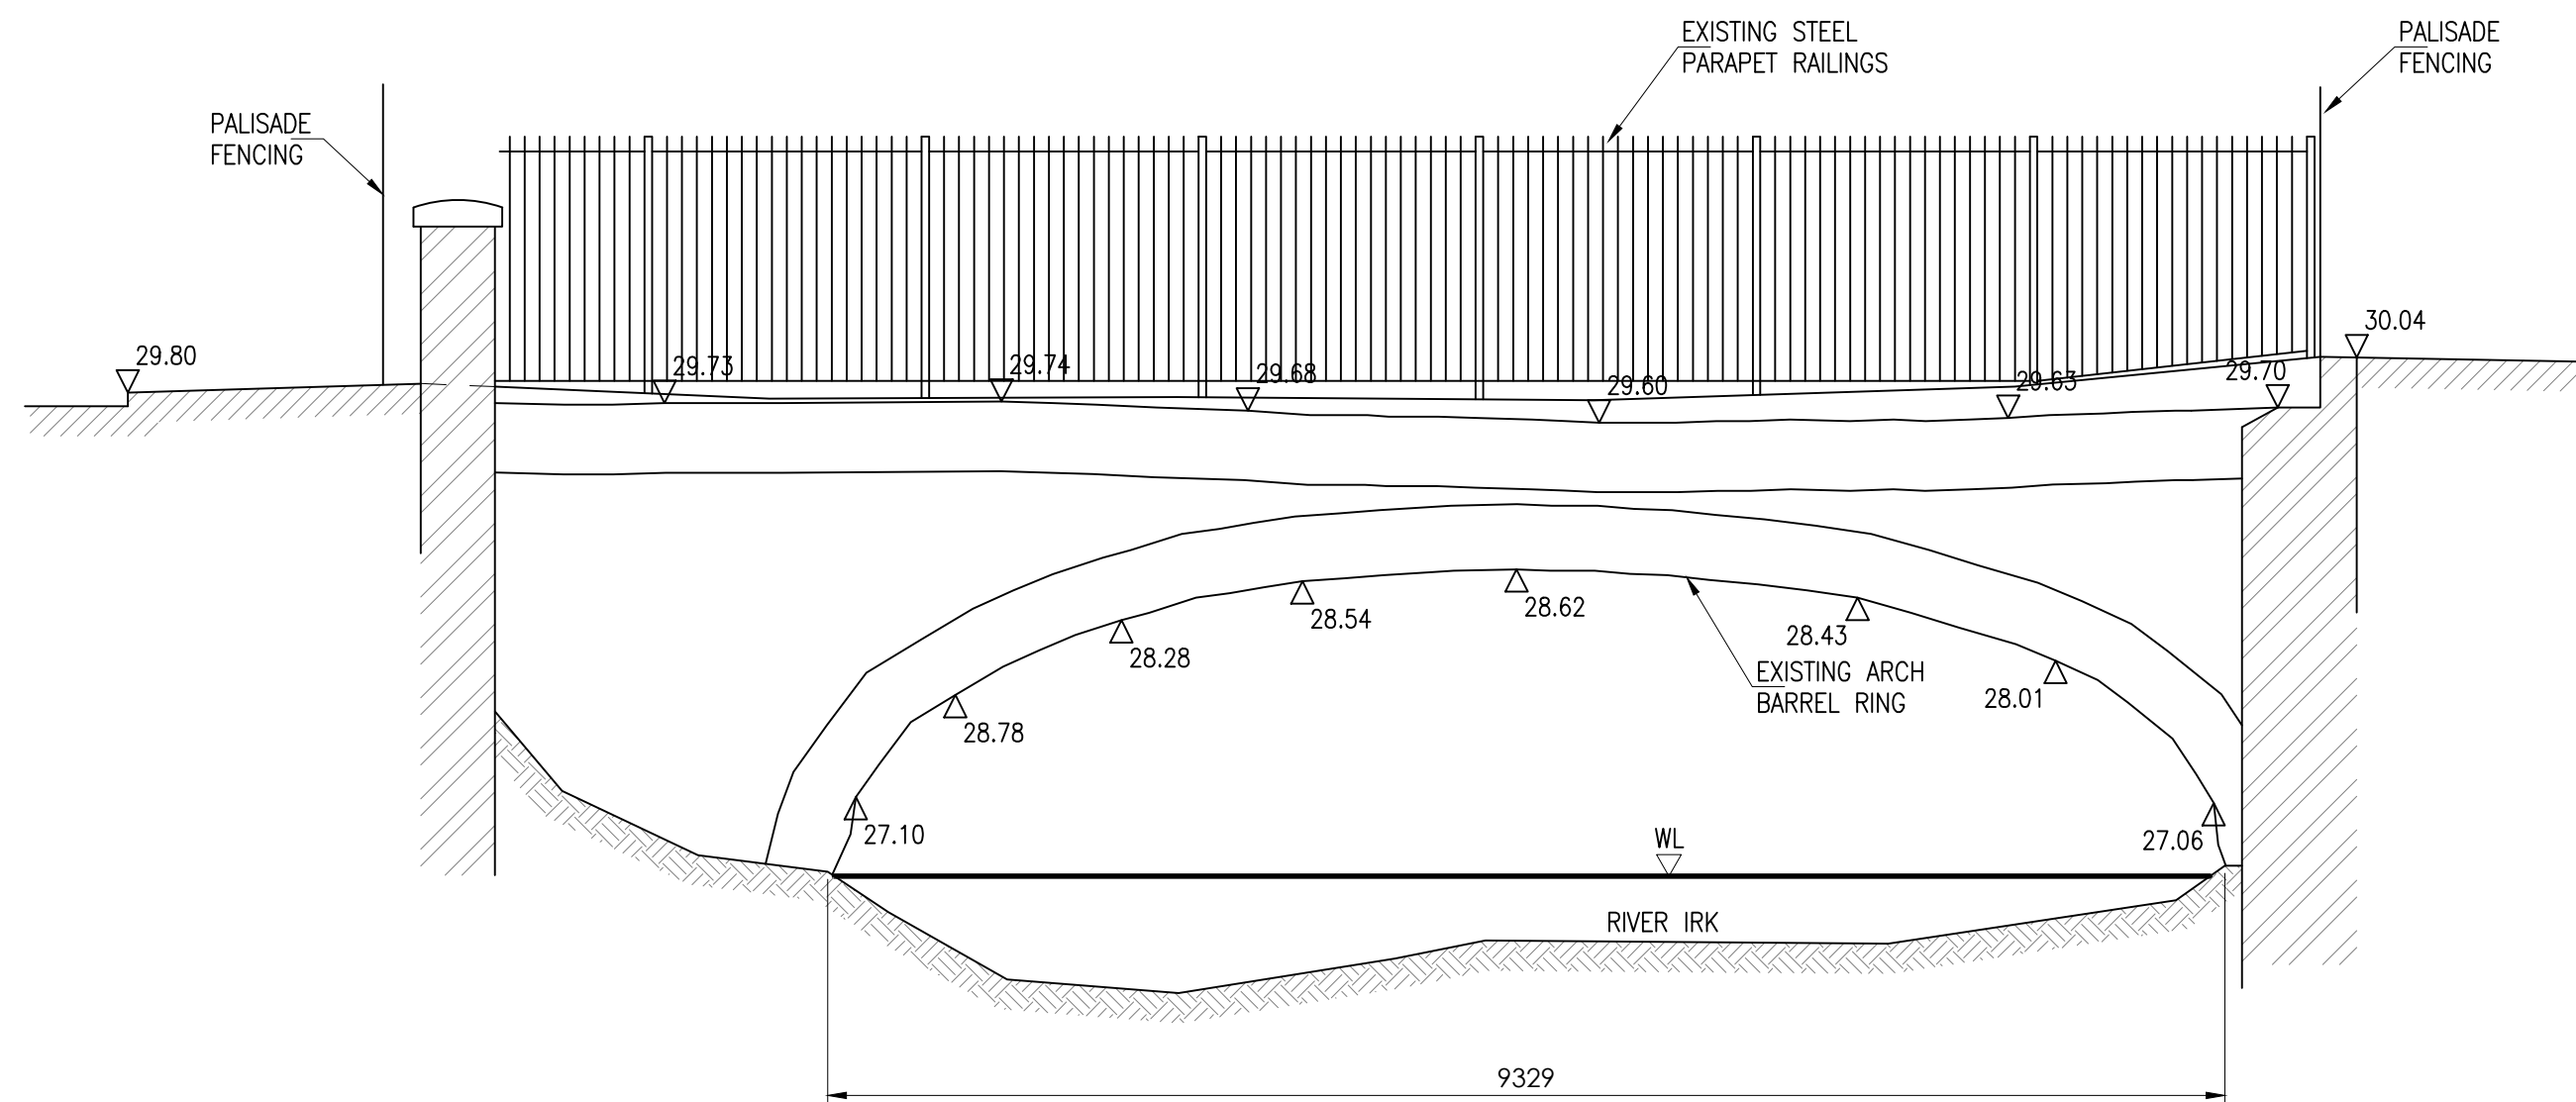

NORTH ELEVATION
SCALE 1:50

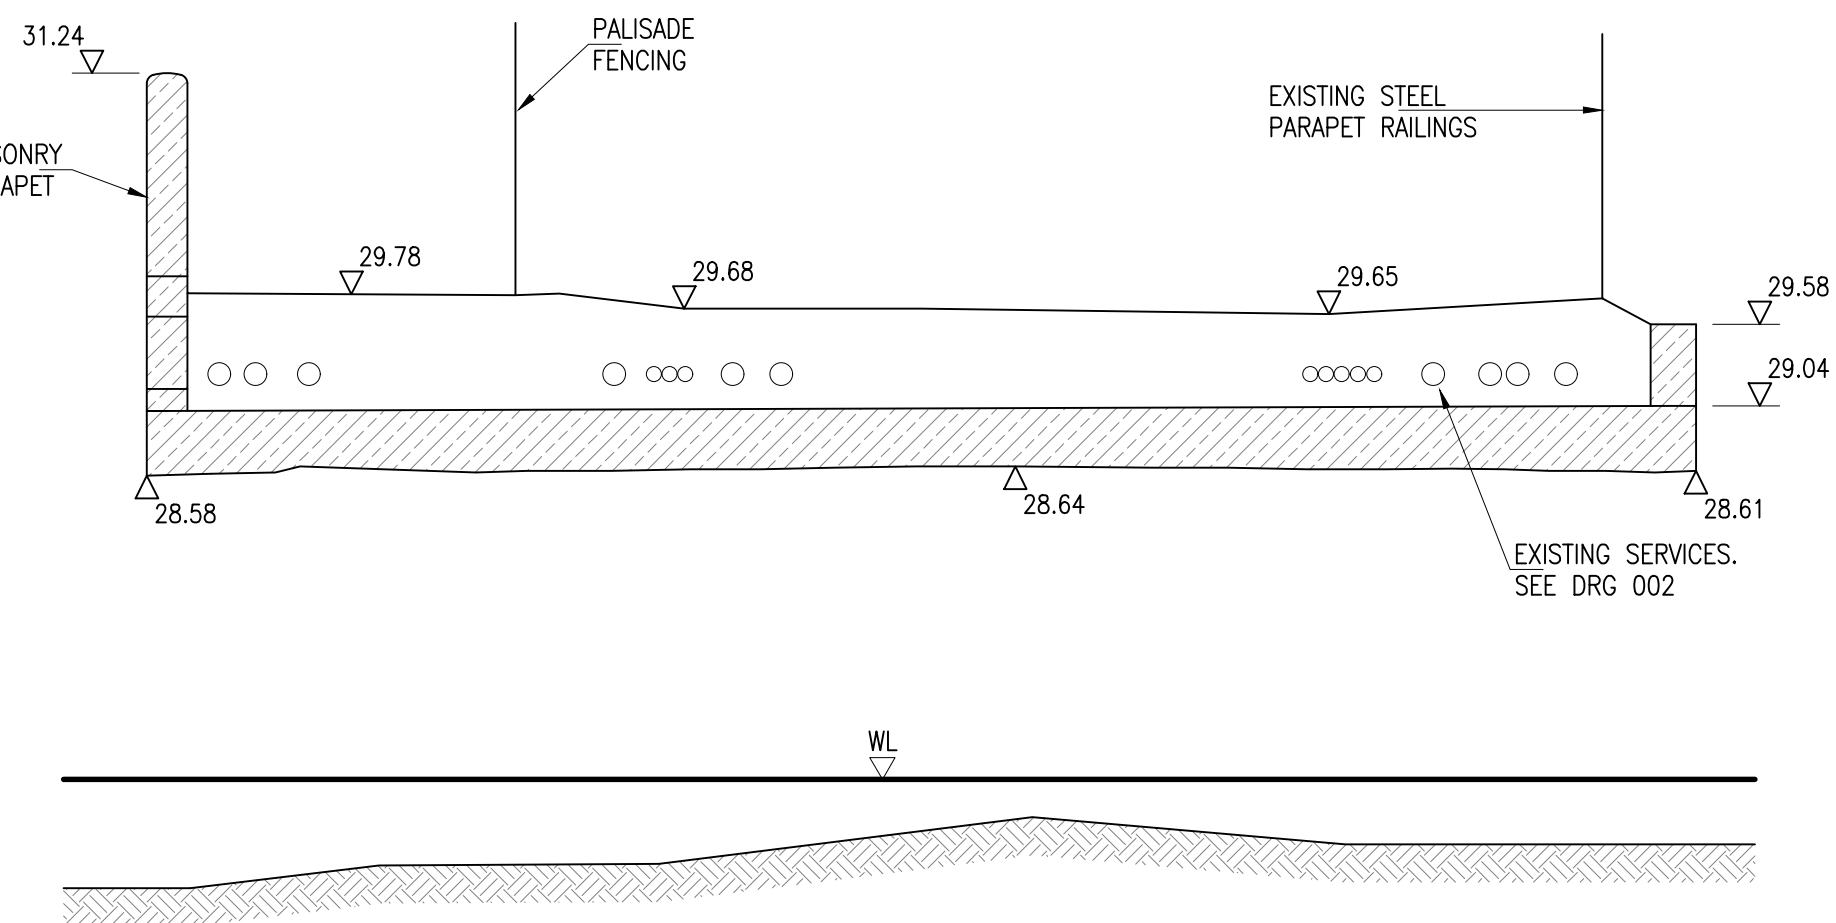

SECTION A-A
SCALE 1:50

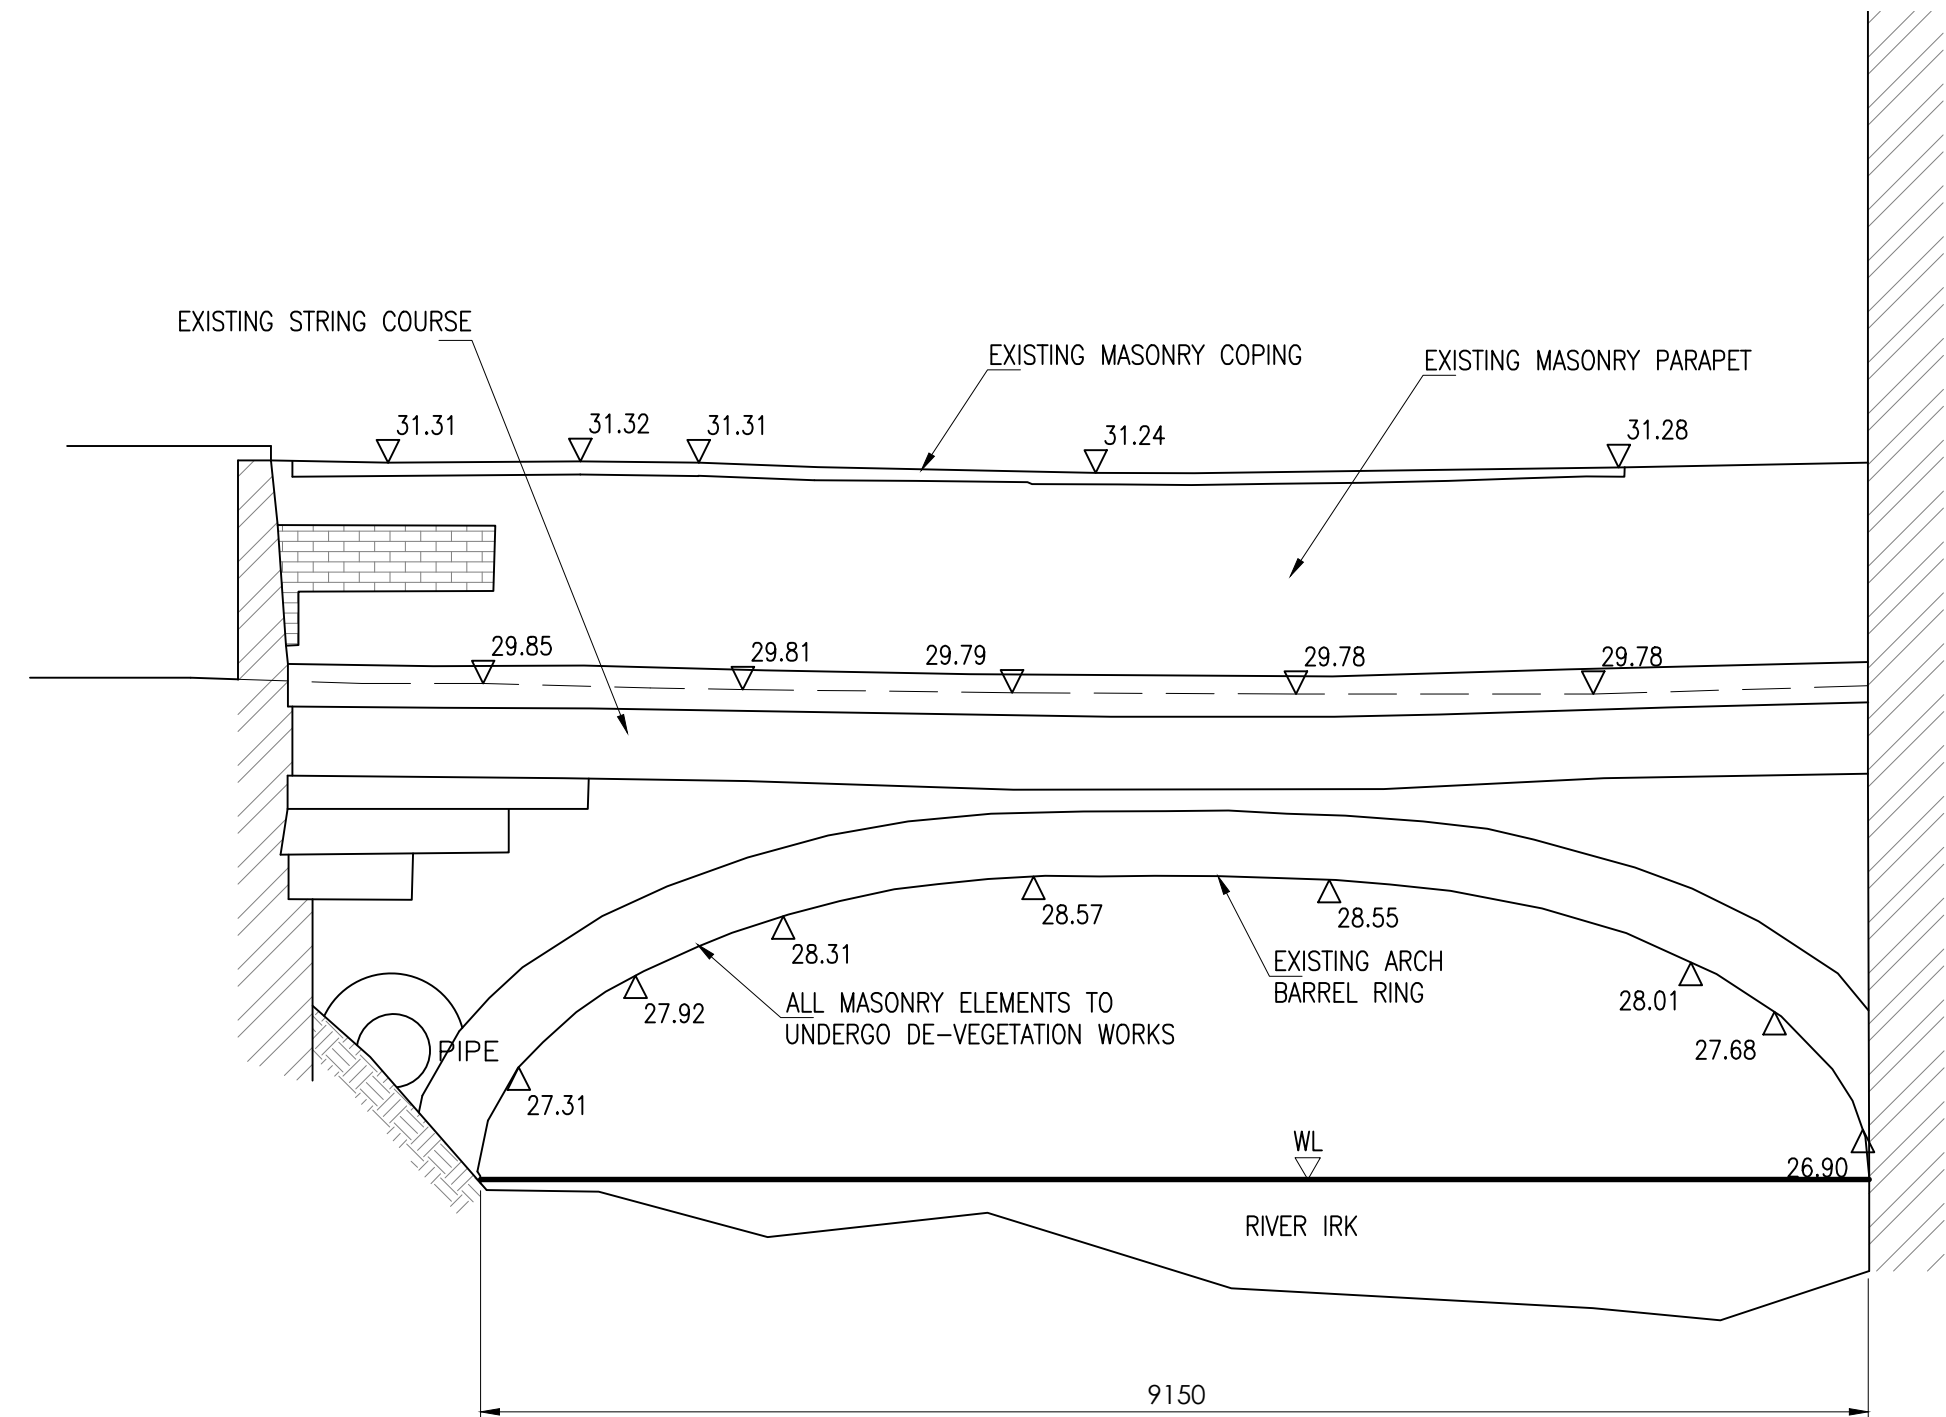

SOUTH ELEVATION
SCALE 1:50

NOTES:

1. ALL DIMENSIONS ARE IN MILLIMETRES AND LEVELS IN METRES UNLESS NOTED OTHERWISE.
2. ALL LEVELS ARE STATED IN METRES.
3. THIS DRAWING IS BASED ON A TOPOGRAPHICAL SURVEY UNDERTAKEN BY SURVEY SOLUTIONS IN DECEMBER 2021.
4. ALL LEVELS RELATE TO THE SURVEY STATIONS SHOWN BELOW:-

STATION	EASTING	NORTHING	LEVEL
S001	384462.503	399322.246	29.980
S002	384459.385	399341.379	29.800
S003	384453.547	399331.017	29.860
S007	384438.307	399340.714	29.810
S031	384453.383	399331.881	29.900
X009	384441.351	399351.158	30.030
5. NO DIMENSIONS OR LEVELS SHALL BE SCALED FROM THIS DRAWING.
6. FOR EXISTING SERVICES INFORMATION REFER TO DRG No 651-276-002.
7. FOR FULL DESIGNERS RISK ASSESSMENT REFER TO DOCUMENT No 651-276-DRA.

HAZARD DIRECTORY

RISKS WILL BE NOTED AND INDICATED BY THIS SYMBOL:	
HAZ001	OVERLOADING BRIDGE AND TRAINING WALL
HAZ002	EXCESSIVE RAKING OUT
HAZ003	WORKING AT HEIGHT
HAZ004	WORKING NEAR A WATERCOURSE (DROWNING)
HAZ005	WORKING NEAR A WATERCOURSE (WEIL'S DISEASE)
HAZ006	STRIKING LIVE SERVICES
HAZ007	TRESPASSING ON SITE
HAZ008	NOISE, DUST AND VIBRATION DURING CONSTRUCTION
HAZ009	COSHH
HAZ010	SHARPS AND NEEDLES
HAZ011	COVID-19
PR001	ENVIRONMENTAL PERMIT
PR002	GRADE II LISTED STRUCTURE
PR003	POLLUTING THE WATERCOURSE
PR004	STRIKING LIVE SERVICES
PR005	WORKING ON PRIVATE LAND
PR006	WORKING NEAR OVERHEAD TELEPHONE WIRES
PR007	SCOURING TO THE ABUTMENTS

P1	SD	MW	MG	14.06.22	FOR PRICING
REV	DRN	CHK	APP	DATE	DESCRIPTION
 Consulting Civil & Structural Engineers					
Client MANCHESTER CITY COUNCIL					
Project ROGER STREET UNION BRIDGE ST 0369					
Title EXISTING GENERAL ARRANGEMENT					
Scale AS SHOWN	Drawn SD	Date 02.03.22	Chkd MW	Approved MG	
Drawing No. 651-276-001				Revision P1	
Status PRICING				Sheet Size A1	