




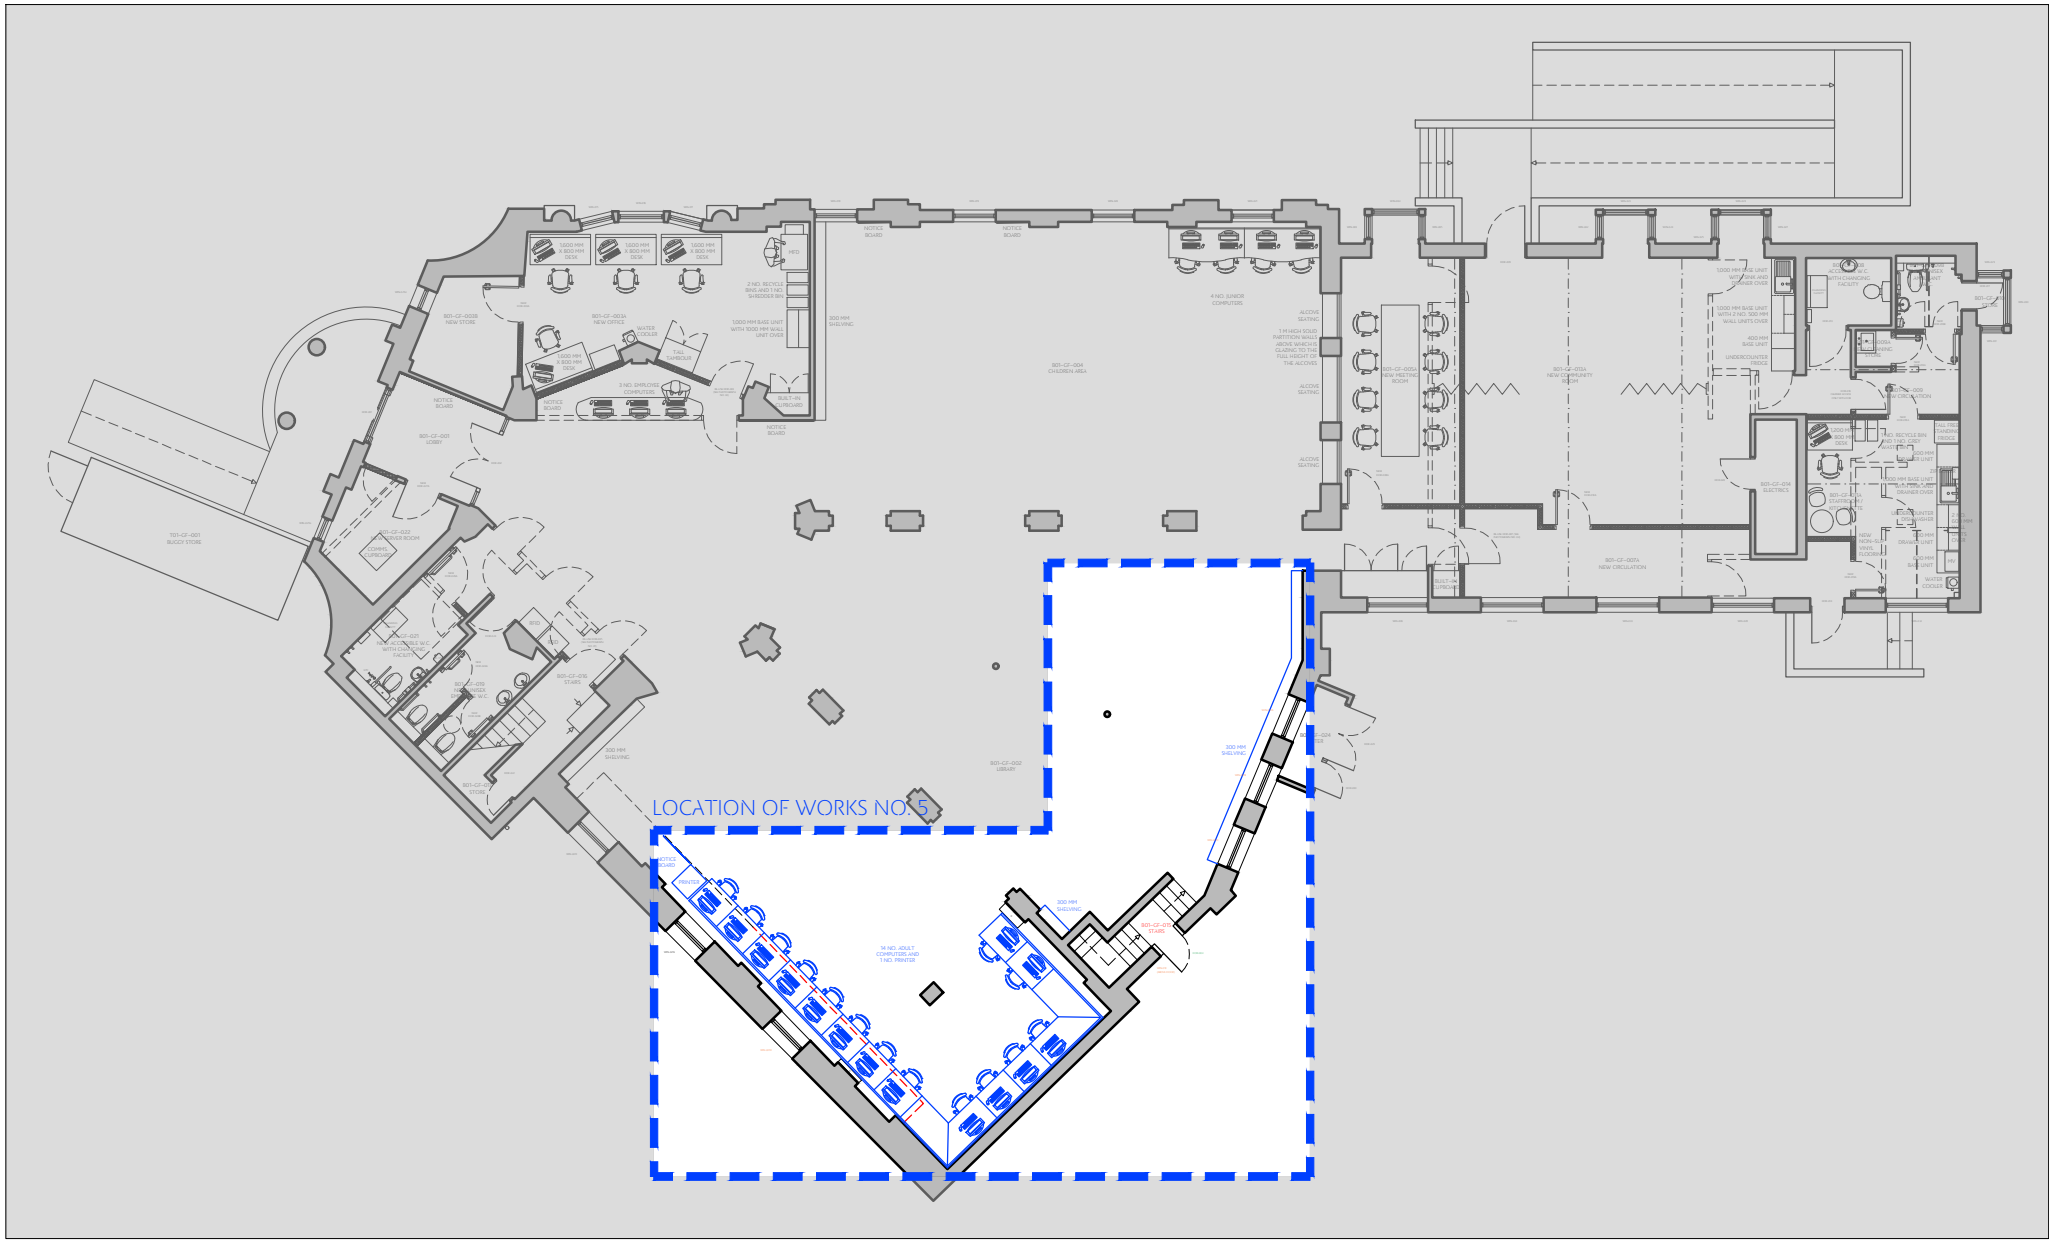

Key Plan
Scale 1:200

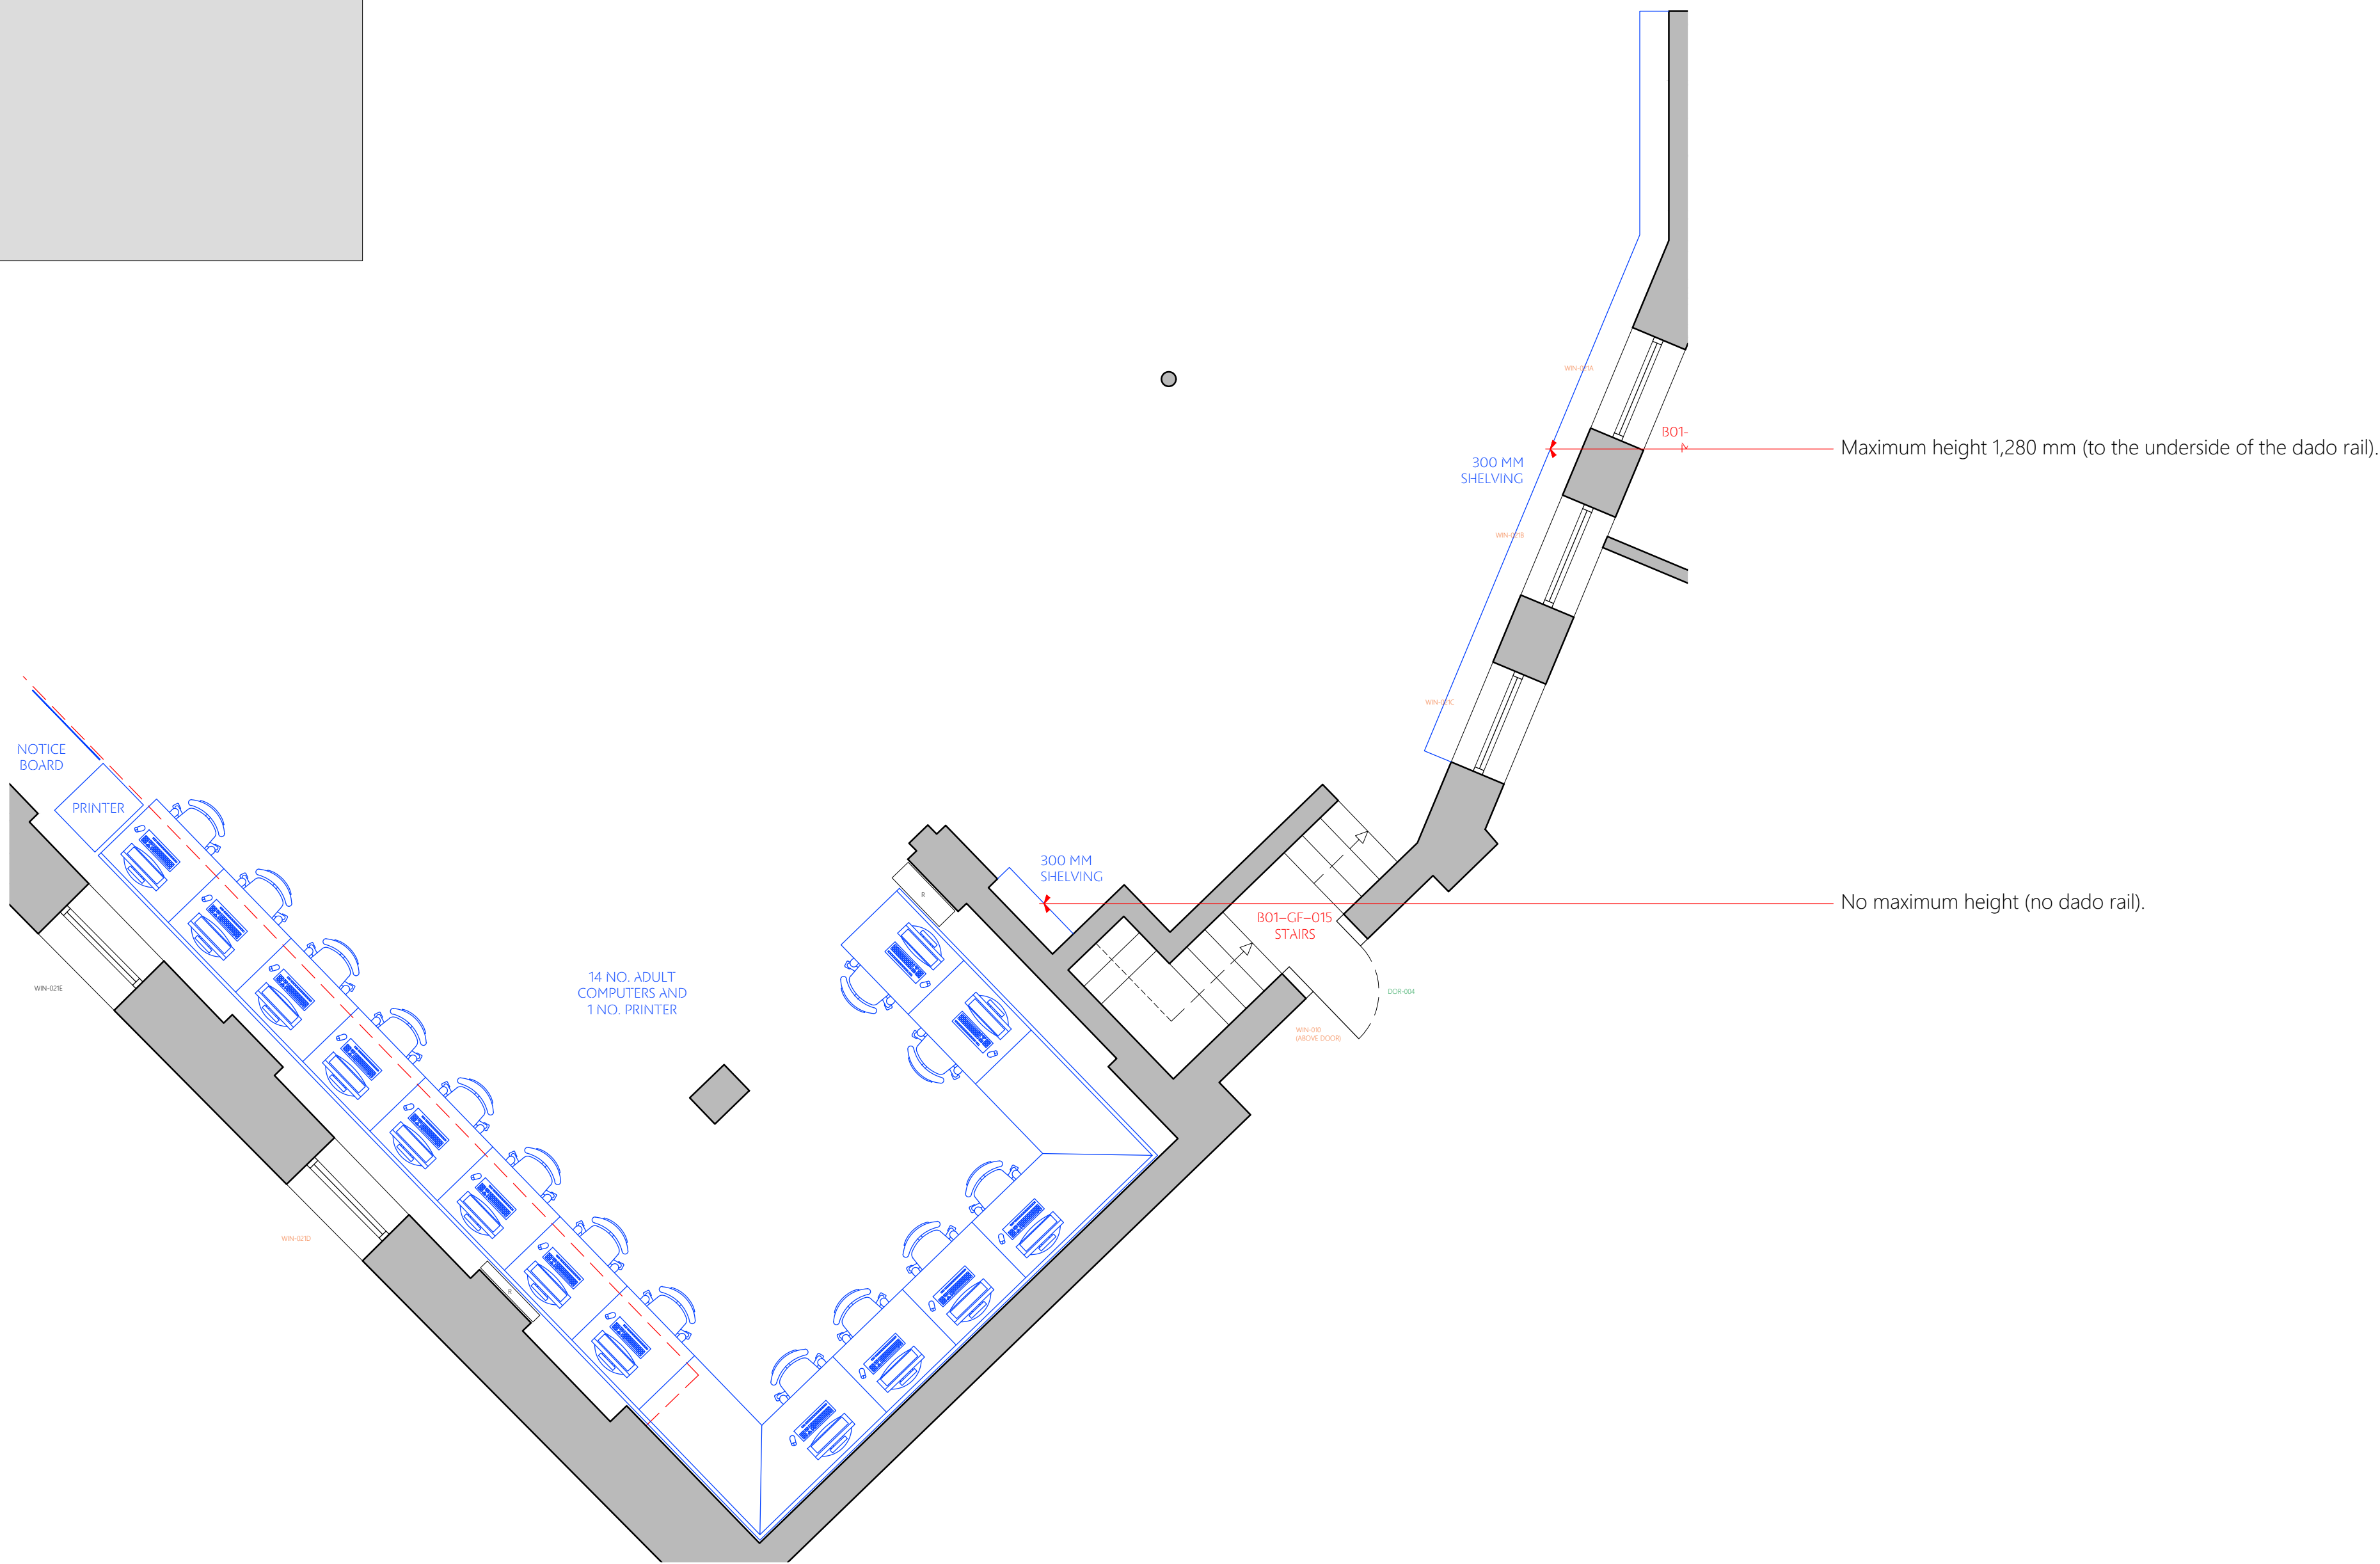

LOCATION OF WORKS NO. 5
Ground Floor Plan as Proposed
Scale 1:50

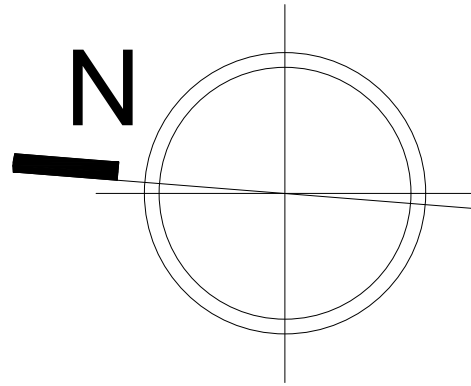

1. DO NOT SCALE FROM THIS DRAWING - USE FIGURED DIMENSIONS ONLY.
2. READ IN CONJUNCTION WITH ALL OTHER CONSULTANTS / SPECIALISTS DRAWINGS, REPORT ANY DISCREPANCIES BEFORE AFFECTED WORK COMMENCES.
3. ALL SETTING OUT DIMENSIONS TO BE CHECKED ON SITE BY CONTRACTOR BEFORE WORK COMMENCES.
4. THIS DRAWING REMAINS COPYRIGHT OF KEPczyk PEARCE SANDERSON LTD. COPY / DISTRIBUTE ONLY WITH CONSENT OF THE AUTHOR.

KEY	
	PUBLIC
	MEETING
	CLERICAL
	KITCHEN
	RESTROOM
	M&E
	STORAGE
	CIRCULATION
ROOM REFERENCES	
DOOR REFERENCES	
WINDOW REFERENCES	
R	RADIATOR
---	REMOVALS AS PROPOSED
---	NEW WORKS AS PROPOSED

Rev. B Revised Layout of Adult Computers and B01-GF-022 (LMC | 2022 07 08)
Rev. A Amended North Symbol (LMC | 2022 07 05)

Contract Open Libraries Development		Location of Works No. 5 as Proposed			
Client Manchester City Council		Contract No. 2141		Drawn LMC	Drawing No. FR 007
Building / Structure Chorlton District Library, Chorlton-cum-Hardy		Date May 2022	Revision B	Scale	Various @ A1
KEPCZYK PEARCE SANDERSON ARCHITECTS, SURVEYORS & HISTORIC BUILDING CONSULTANTS		Address: 75 Wilmslow Road, Handforth, Cheshire SK9 3EN Tel: 01625 400103			