


PLEASE NOTE:
All emergency lighting is to be within the main lights and not separate fittings
RCP plans to be read in conjunction with Schedule of Works and Technical Reference Sheet.
Please refer to Services Engineers specifications for detailed requirements
Setting out of light fittings and other ceiling mounted services to be agreed with architect
Lighting layout and quantity of fittings is subject to check of technical calculations by specialist subcontractor

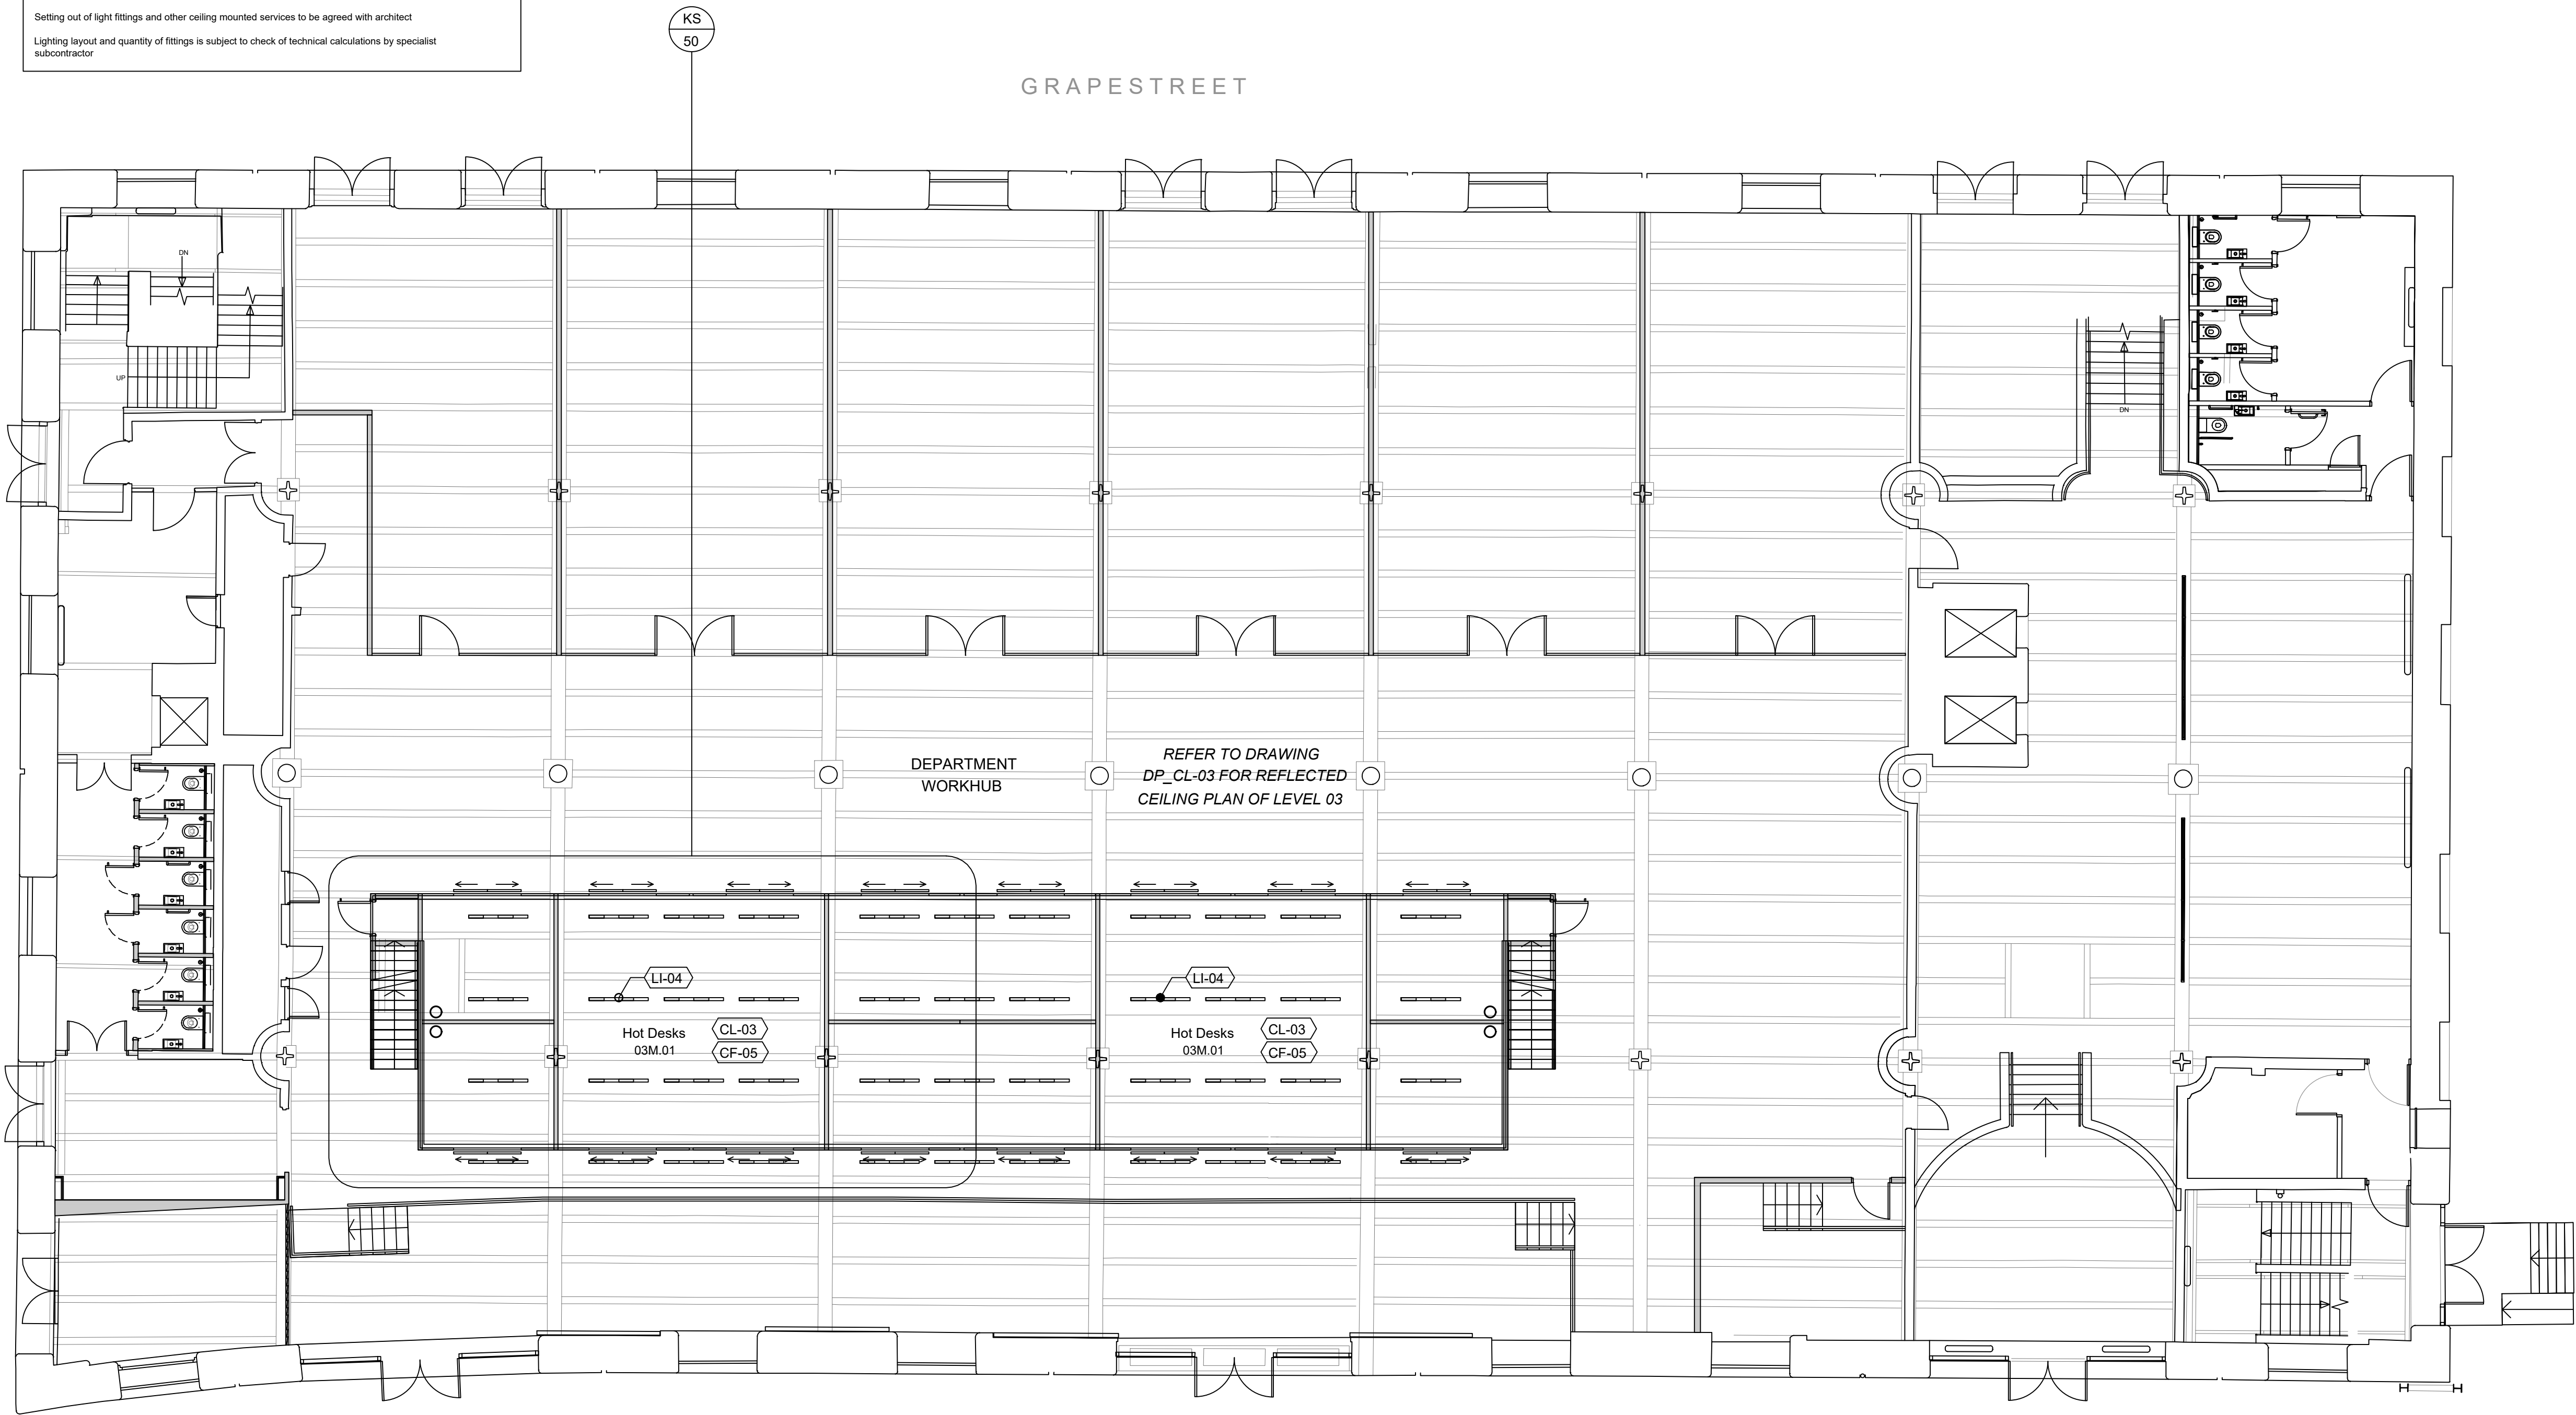

Notes:

Do not scale from this drawing. All dimensions to be checked on-site by contractor to ensure accuracy prior to any installation. All design work produced by Amspec Ltd is for indicative purposes only. It is the client and contractors responsibility to ensure that building control and fire officer approval have been met prior to commencement of site work

Drawing Key
Refer to Lighting Schedule DP_SFEE and Finishes Schedule DP_SF

- CEILING TYPES**
- CL-01 New painted plasterboard MF ceiling
 - CL-02 Existing exposed timber soffit
 - CL-03 Existing exposed brick soffit and steel beams
 - CL-04 Armstrong Microlook 8 mesh suspended ceiling panels
- CEILING FINISHES**
- CF-01 Diamond matt RAL 9010 pure white
 - CF-02 RAL 9005 Jet Black metal paint
 - CF-03 Paint to existing soffit / beams
 - CF-04 Emulsion paint to plasterboard MF ceiling - Black
 - CF-05 Paint to existing steel beams
- LIGHT FITTINGS**
- LI-01 Mini Perfetto Black pendant
 - LI-02 GU11 tube spot directional spotlight
 - LI-03 Existing linear lights on support rails - reused and moved/adjusted where necessary
 - LI-04 Existing linear lights - adjusted to be surface mounted
 - LI-05 Existing linear Reception lights, left in place
 - LI-06 Fitzgerald LED Stellar black finish to casing
 - LI-07 LED light strip - Kitchenette
 - LI-08 Industrielle Brooklyn vintage dome pendant (69)
 - LI-09 Orlight LED spotlights white flush frame
 - LI-10A Zero lighting Silo trio pendant downlight
 - LI-10B 259 lighting self suspended black pendants
 - LI-10C Zero lighting convex large black pendants
 - LI-11 Zero lighting clark black wall lights
 - LI-12 Original BTC large 7380 large black pendant
 - LI-14 Encapsulte stick-tile opal diffuser black tube light
 - LI-16 Zumtobel supersystem black spotlights on track
 - LI-17 Eichholtz versus black wall lights
 - LI-18 Chelsom shaffesbury black/ bronze wall light
 - LI-20 Linear surface mounted light
 - LI-22 Heals Junction black table lamp
 - LI-23 Chelsom space 680mm Ø globe pendant steel grey
 - LI-24 Myklos halo work 1400mm black wall light
 - LI-25 Zero lighting fog 300mm Ø black pendant light
 - LI-26 Tom Kirk flute pendant polished gold clear pendant
 - LI-27 Dyke & Dean globe reflector 200mm Ø brass wall light
 - LI-28 Nir Meiri Moon black floor lamp
 - LI-29 Surface mounted ceiling neon tube light pink
 - LI-30 DLC Lumisheet LED light panel displaying up and down
 - LI-31 Rubn vogue pendant brass light
- MISCELLANEOUS**
- MI-08 Suspended ceiling fan - Work Hub

REV:	DESCRIPTION:	BY:	DATE:
STATUS:	AS BUILT		
CLIENT:	OBI 80 MOSELY STREET MANCHESTER M2 3FX		
ARCHITECT:			
SITE:	18 LOWER BYROM STREET MANCHESTER		
TITLE:	LEVEL 3 MEZZANINE RCP		
SCALE AT A1:	DATE:	DRAWN:	CHECKED:
1:100	27.06.19	CR	IC
PROJECT NO:	DRAWING NO:	REVISION:	
1683	DP_CL-03M		