


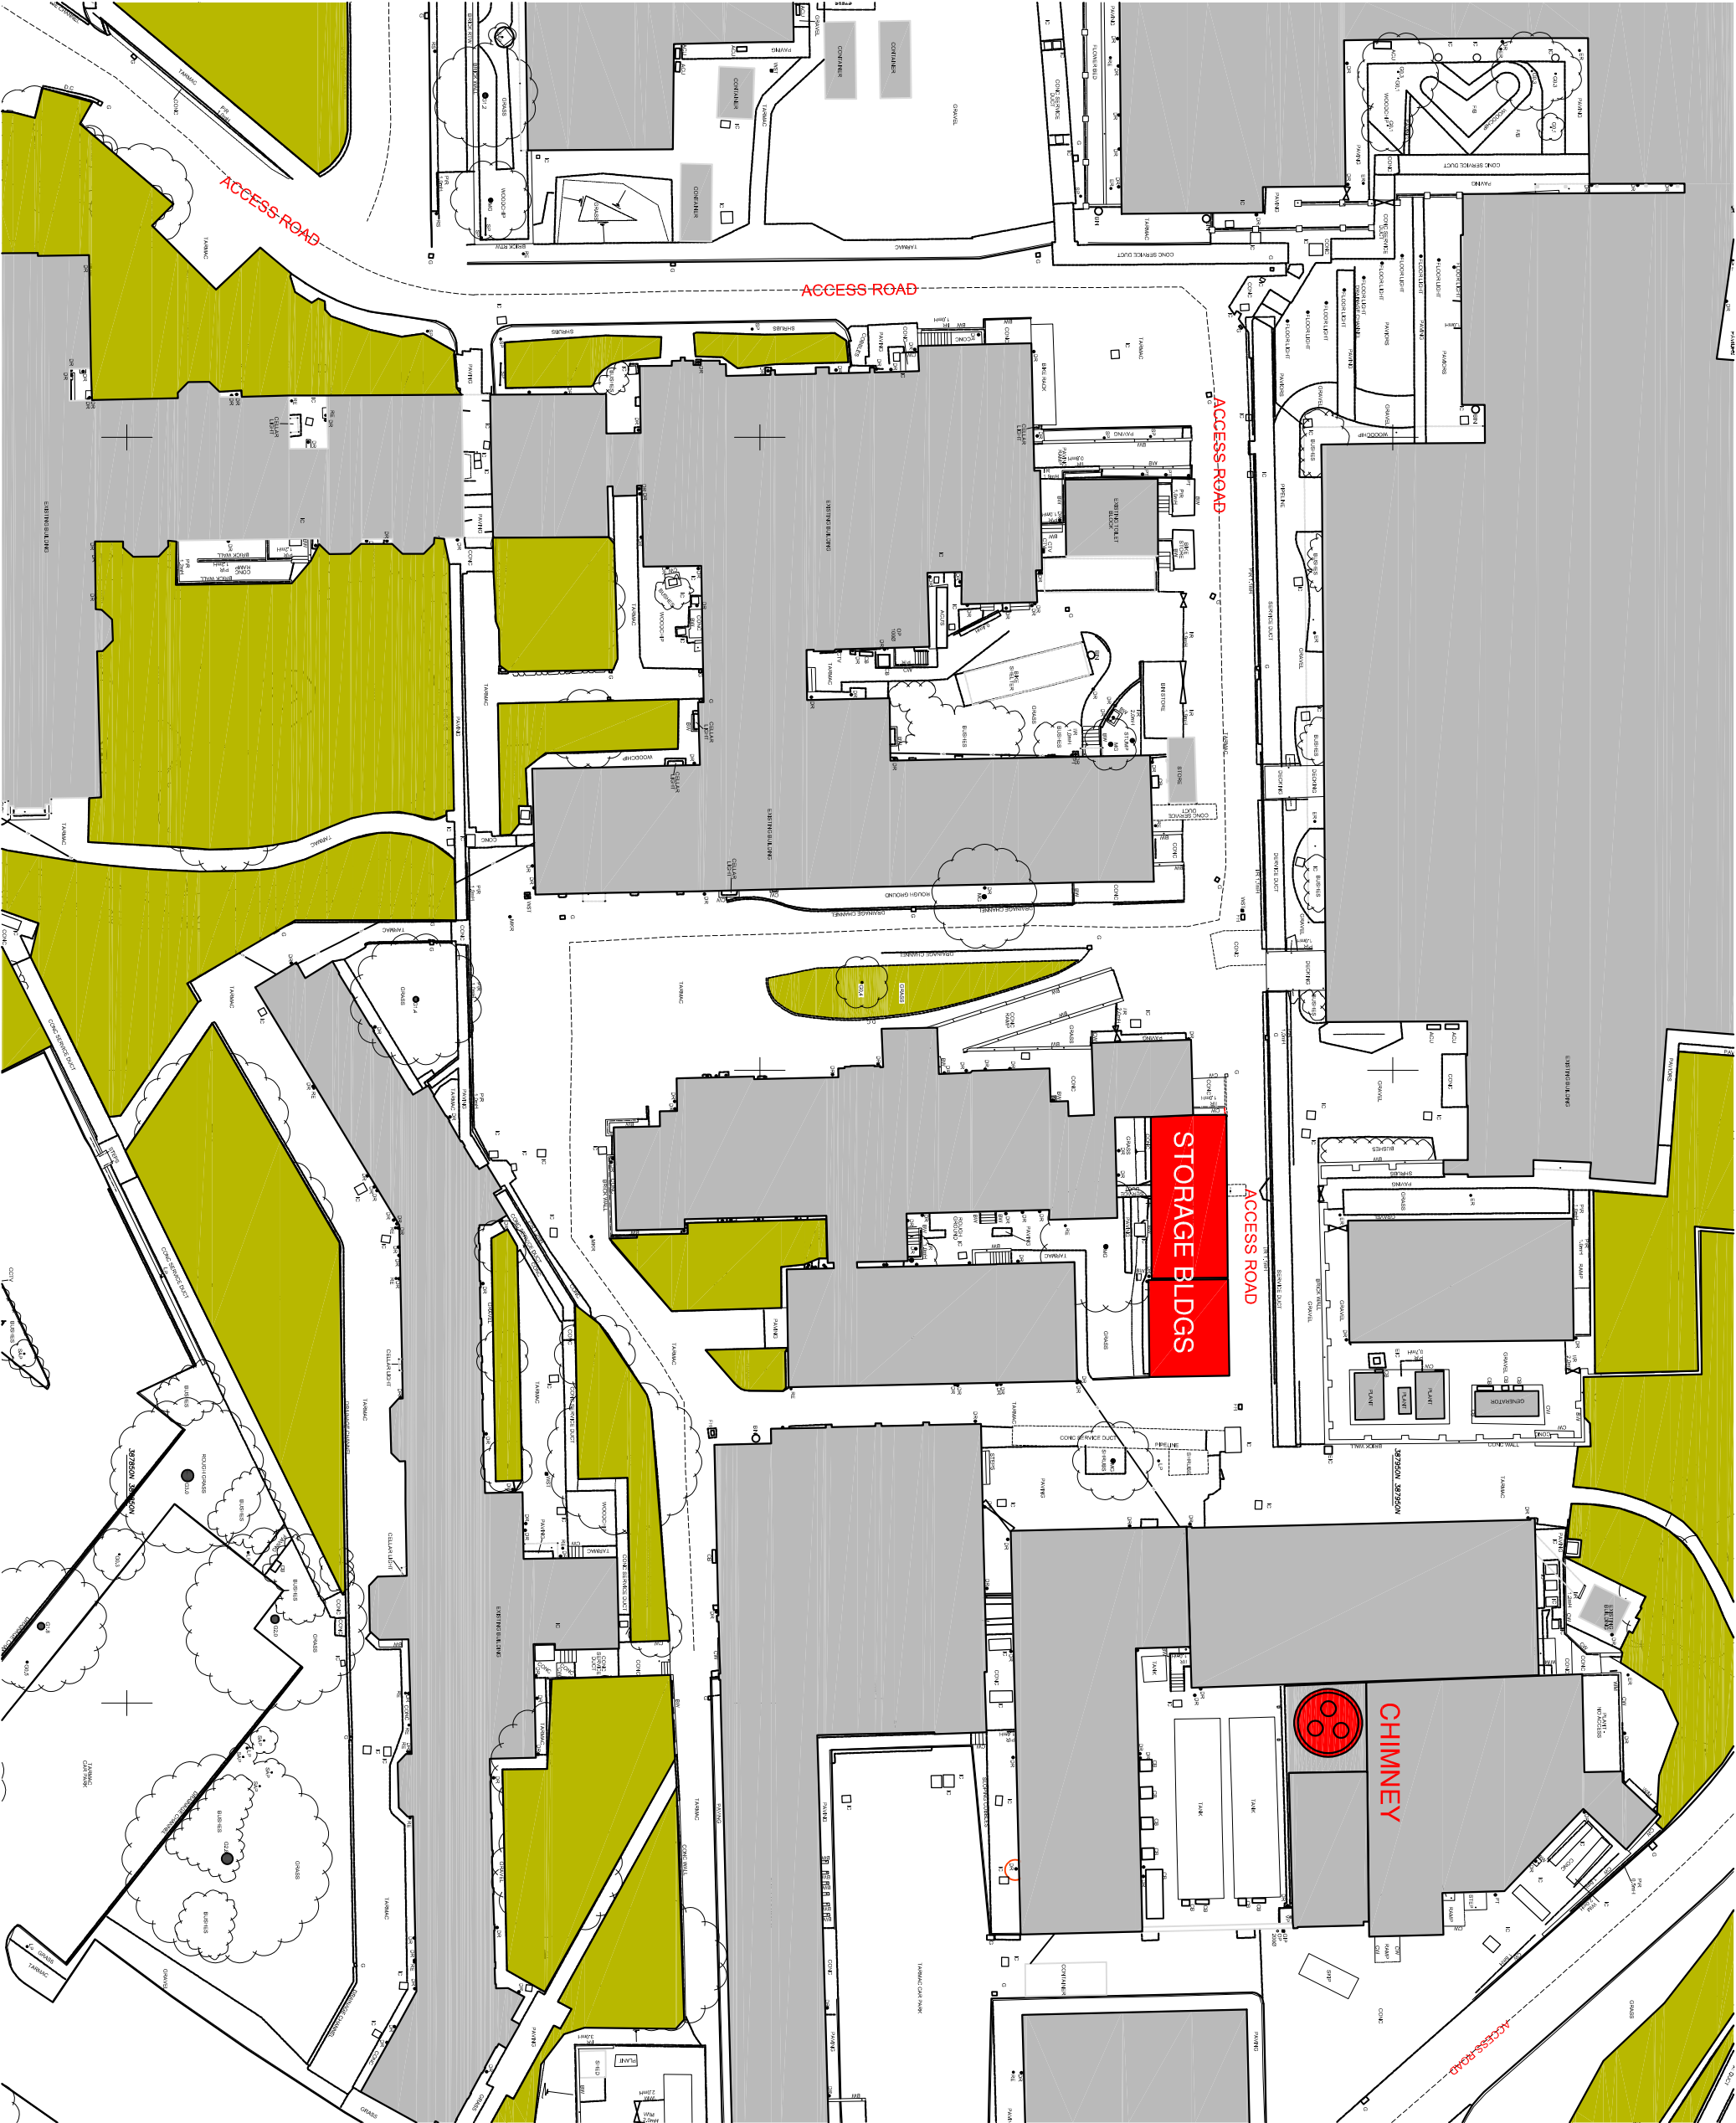

rev	date	by	description	
contract				
CHIMNEY DEMOLITION WYTHENSCHAW HOSPITAL SOUTHMOOR ROAD WYTHENSCHAW M23 9LT				
client				
MANCHESTER UNIVERSITY NHS FOUNDATION TRUST				
dwg no.		rev.		date
5832/ 02				June 22
scales		drawn	checked	
1 / 500 @ A3		RW		
subject				
EXISTING SITE PLAN				

Warburton

associates

Chartered Architects

The Old Police Station, 62 Chapel Street, MANCHESTER M3 7AA

Tel: 0161 833 9345 Fax: 0161 831 7584 mail@warburtonassociates.com