




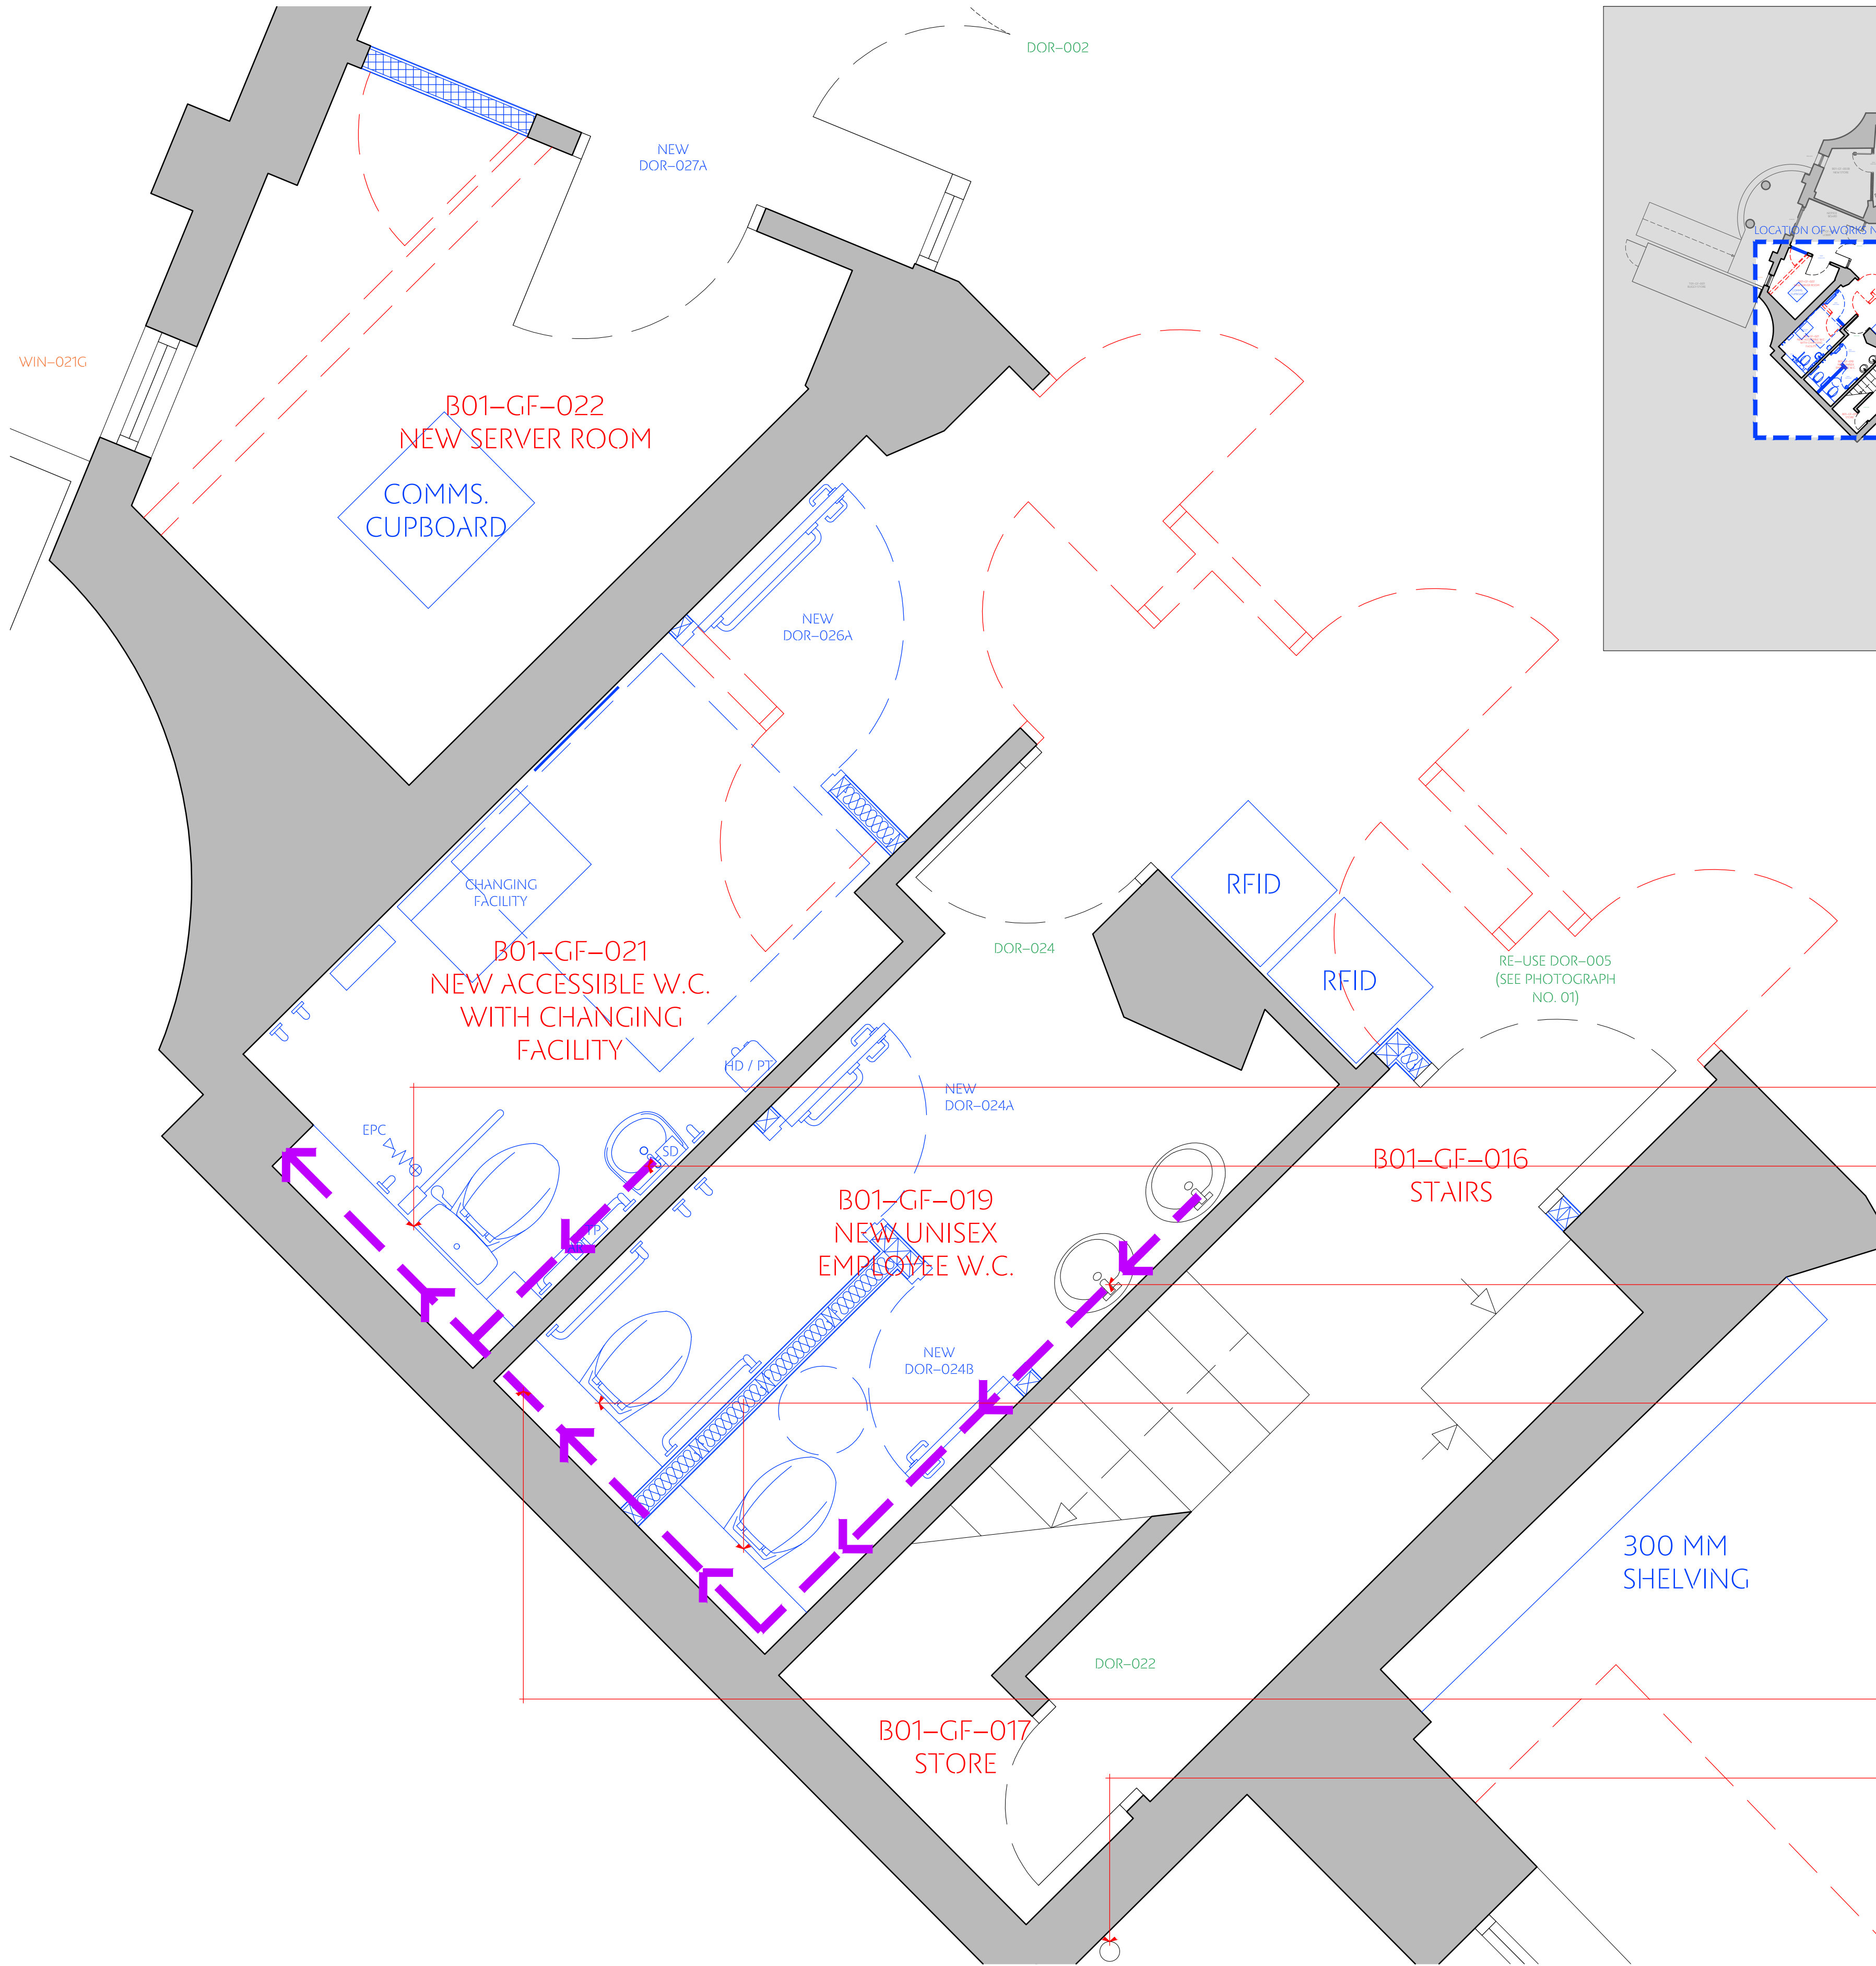

LOCATION OF WORKS NO. 1
Ground Floor Plan as Proposed
Scale 1:20

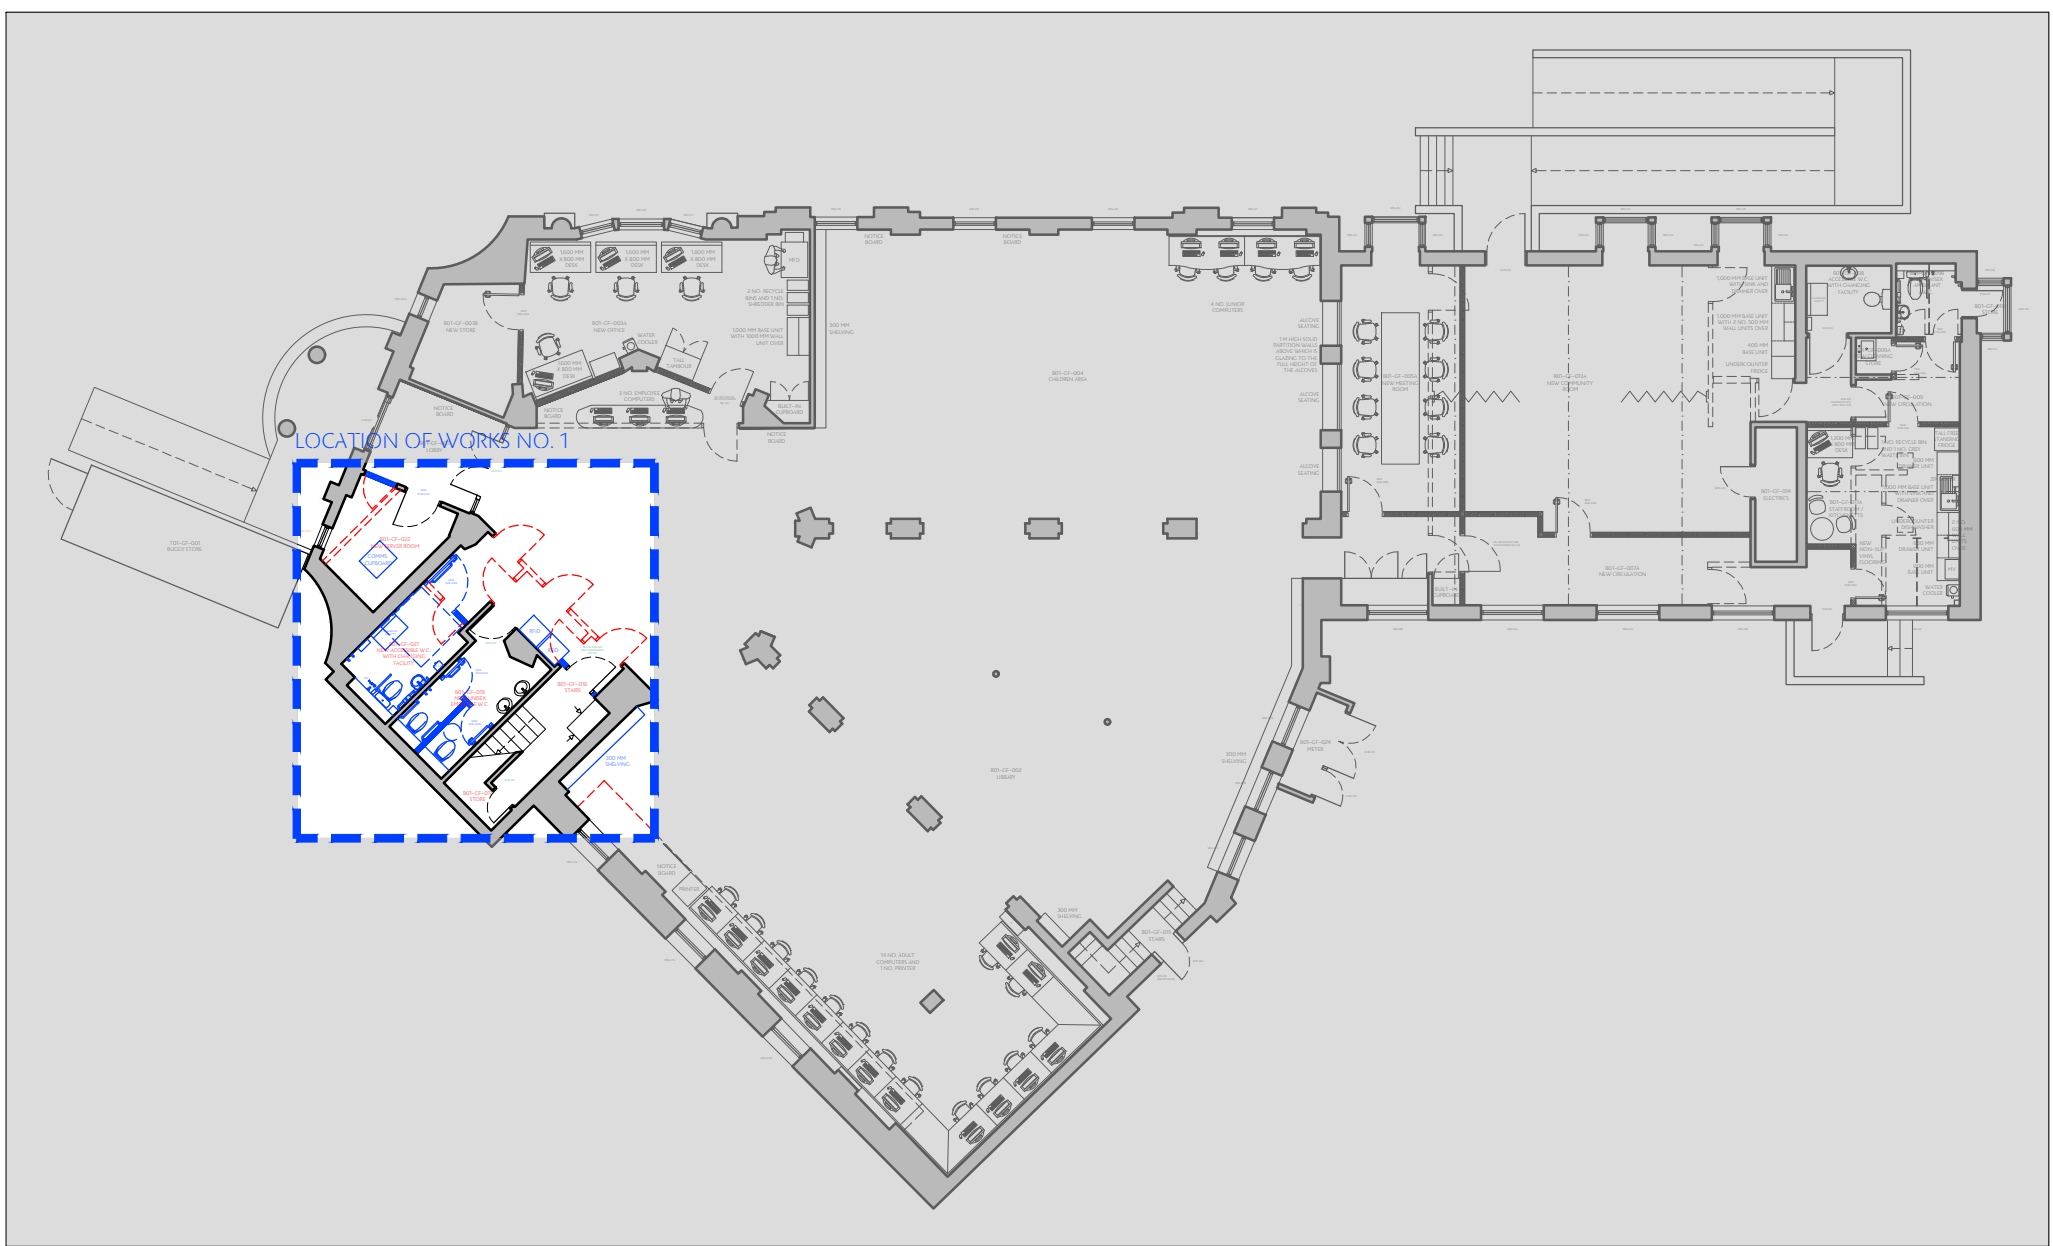

Key Plan
Scale 1:200

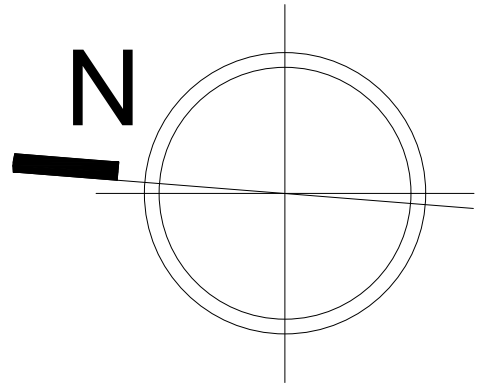

1. DO NOT SCALE FROM THIS DRAWING - USE FIGURED DIMENSIONS ONLY.
2. READ IN CONJUNCTION WITH ALL OTHER CONSULTANTS / SPECIALISTS DRAWINGS, REPORT ANY DISCREPANCIES BEFORE AFFECTED WORK COMMENCES.
3. ALL SETTING OUT DIMENSIONS TO BE CHECKED ON SITE BY CONTRACTOR BEFORE WORK COMMENCES.
4. THIS DRAWING REMAINS COPYRIGHT OF KEPczyk PEARCE SANDERSON LTD. COPY / DISTRIBUTE ONLY WITH CONSENT OF THE AUTHOR.

KEY	
	WASTE PIPE RUNS
	ROOM REFERENCES
	DOOR REFERENCES
	WINDOW REFERENCES
	RADIATOR
	REMOVALS AS PROPOSED
	NEW WORKS AS PROPOSED

Boxing Behind Accessible W.C.
18 mm thick plywood.

New Connection
New 32 mm waste pipe run for handwash basin with trap and rodding eye.

Existing Connection
Existing 32 mm waste pipe run for handwash basins with traps and rodding eye.

Back to Wall W.C.s
Standard IPS (integrated plumbing system) steel frame and panel sets / concealed pipework with access for servicing and maintenance.

Existing Connection
Existing 110 mm low level waste pipe run for W.C.s / connection to underground sewage system.

Existing soil vent pipe.

Contract Open Libraries Development		Location of Works No. 1: Waste Pipe Runs as Proposed					
Client Manchester City Council		Contract No.	2141	Drawn	LMC	Drawing No.	FR 024
Building / Structure Chorlton District Library, Chorlton-cum-Hardy		Date	Jul 2022	Revision	-	Scale	Various @ A1
KEPCZYK PEARCE SANDERSON ARCHITECTS, SURVEYORS & HISTORIC BUILDING CONSULTANTS		Address: 75 Wilmslow Road, Handforth, Cheshire SK9 3EN Tel: 01625 400103					