


KEY


- EXISTING VENT GRILLE
- PROPOSED PLANT & DUCTING ROUTED IN VOID ABOVE CEILING

GENERAL NOTES


1. Do not scale from this print or use as a template.
2. All dimensions must be verified on site before any work is put in hand and any discrepancies must be reported to the Architect. Where any variations occur between small scale and detailed drawings, detail drawings should be worked from.
3. Copyright of this drawing is reserved by Osbornes and is issued on condition that it is not copied or disclosed to any third party either wholly or in part without the consent of Osbornes in writing.

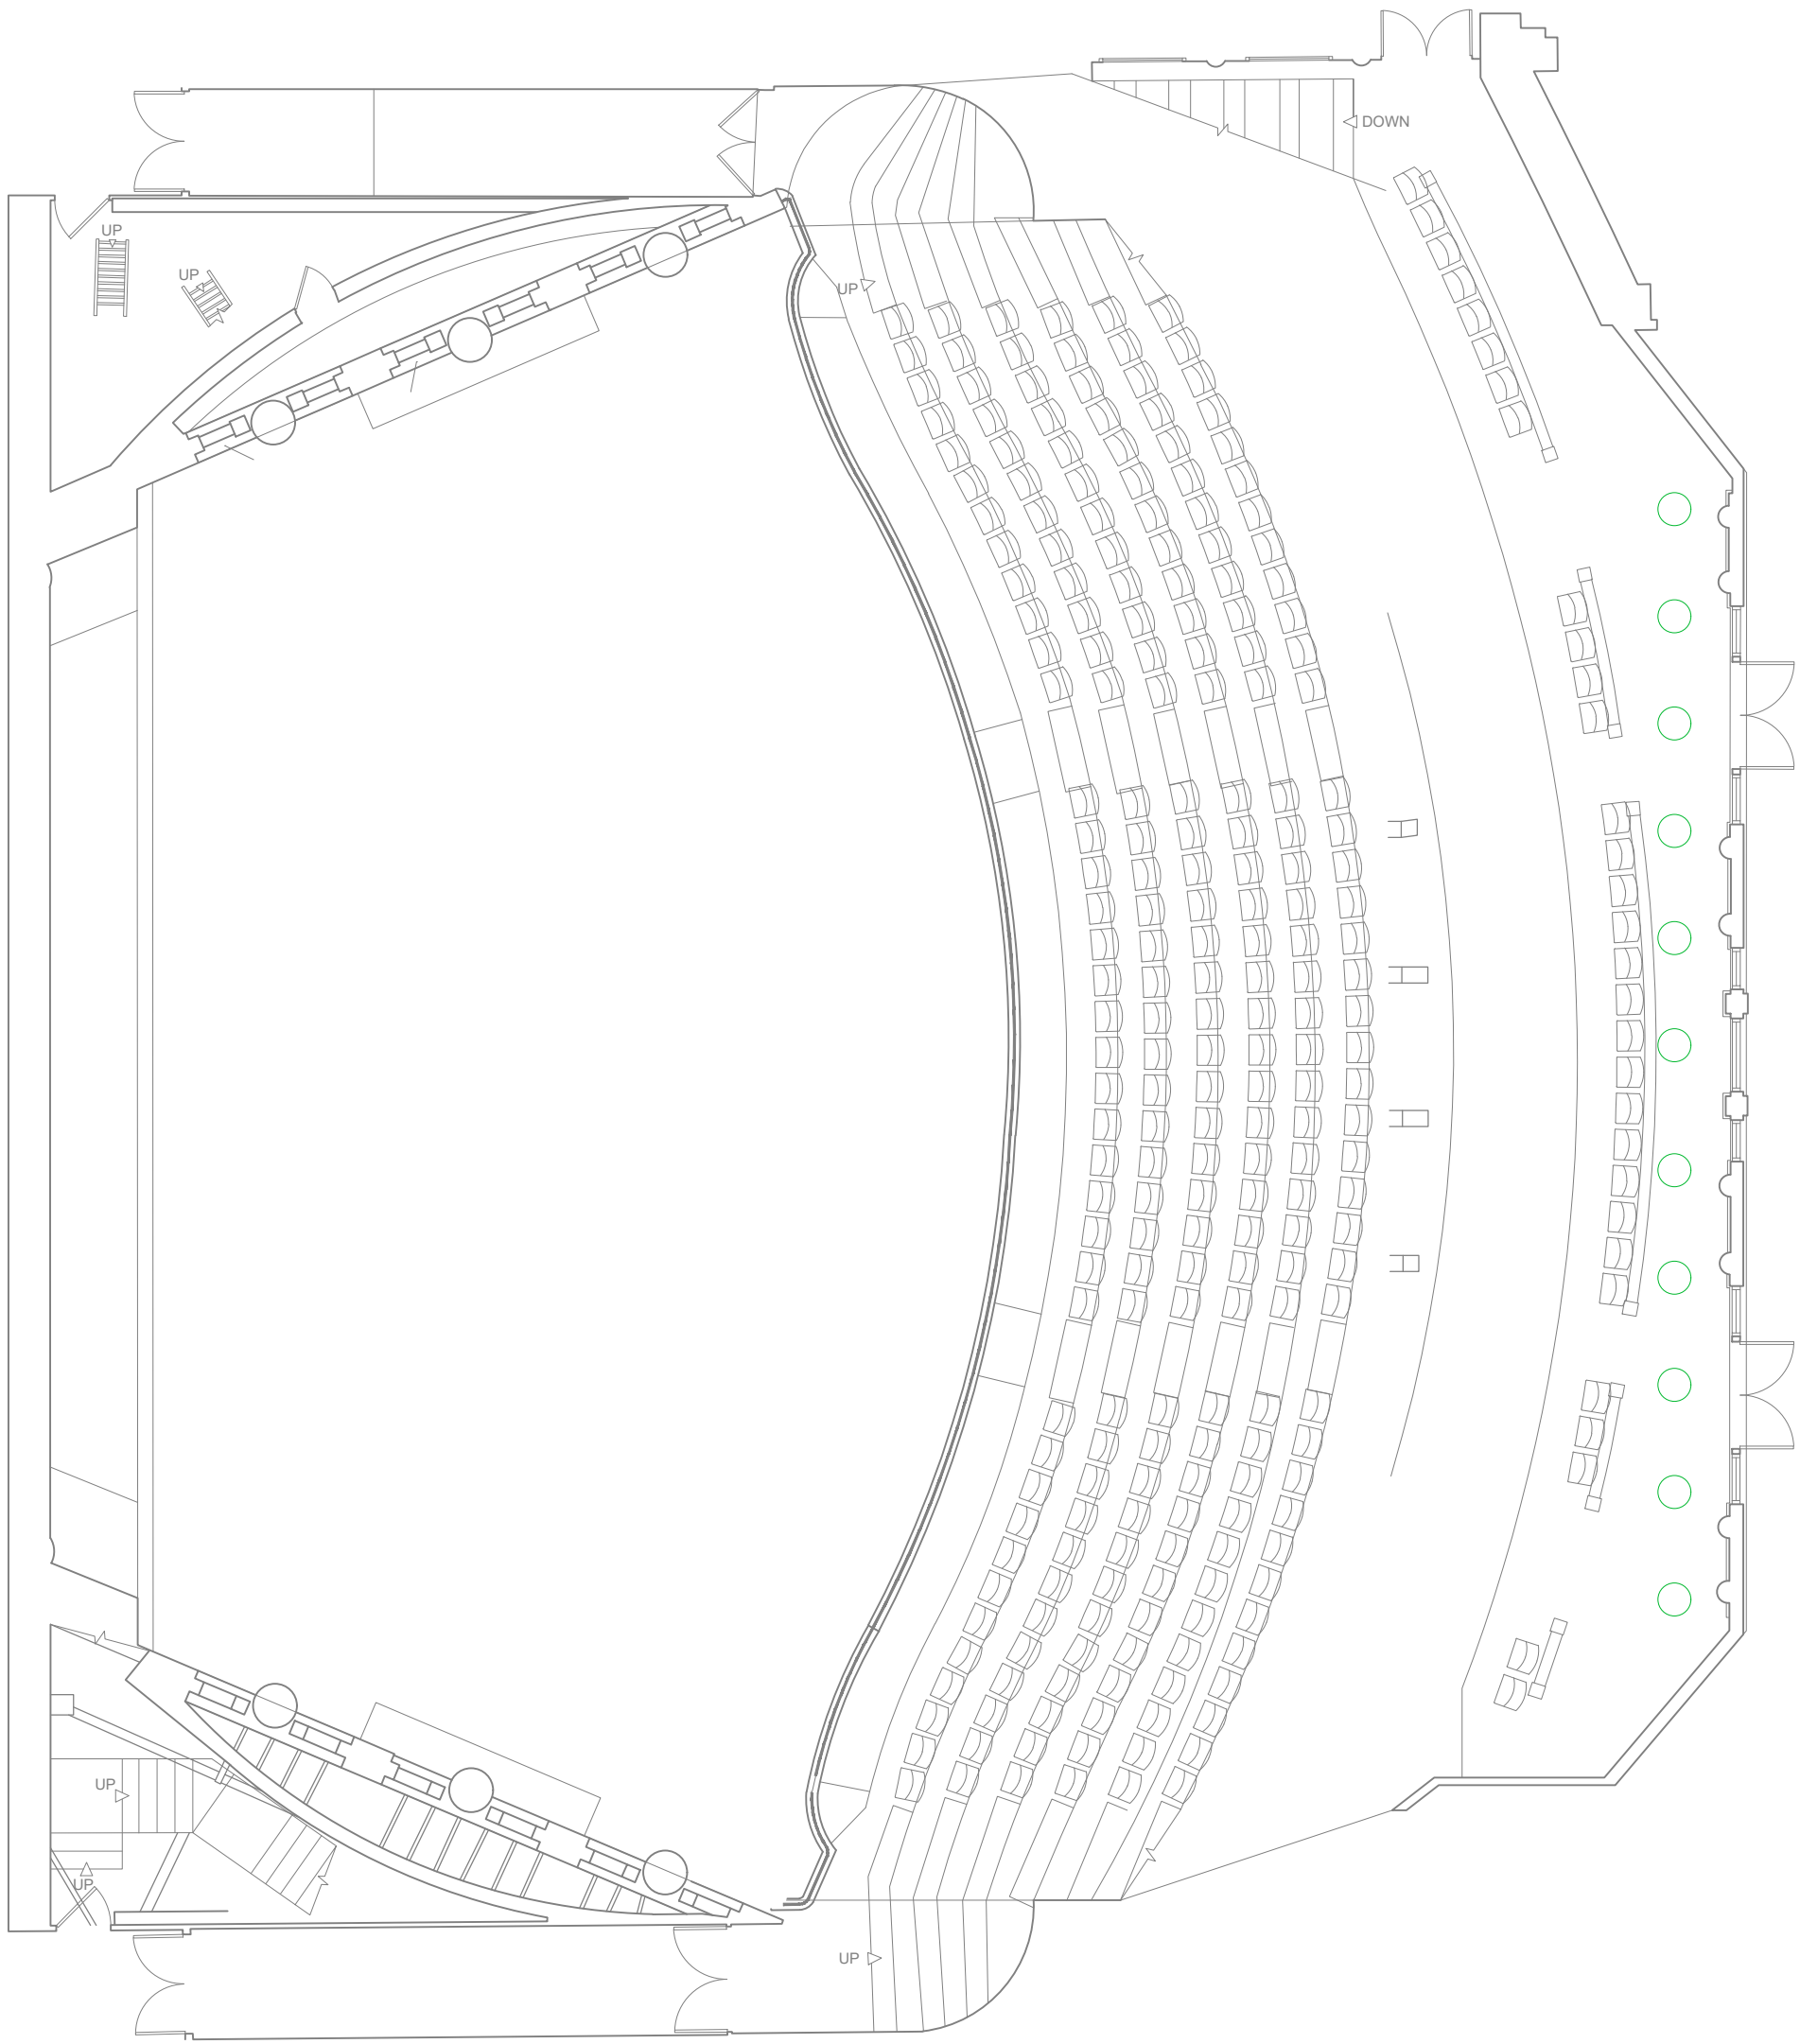



EXISTING AUDITORIUM REFLECTED CEILING PLAN - CIRCLE TIER
1:100

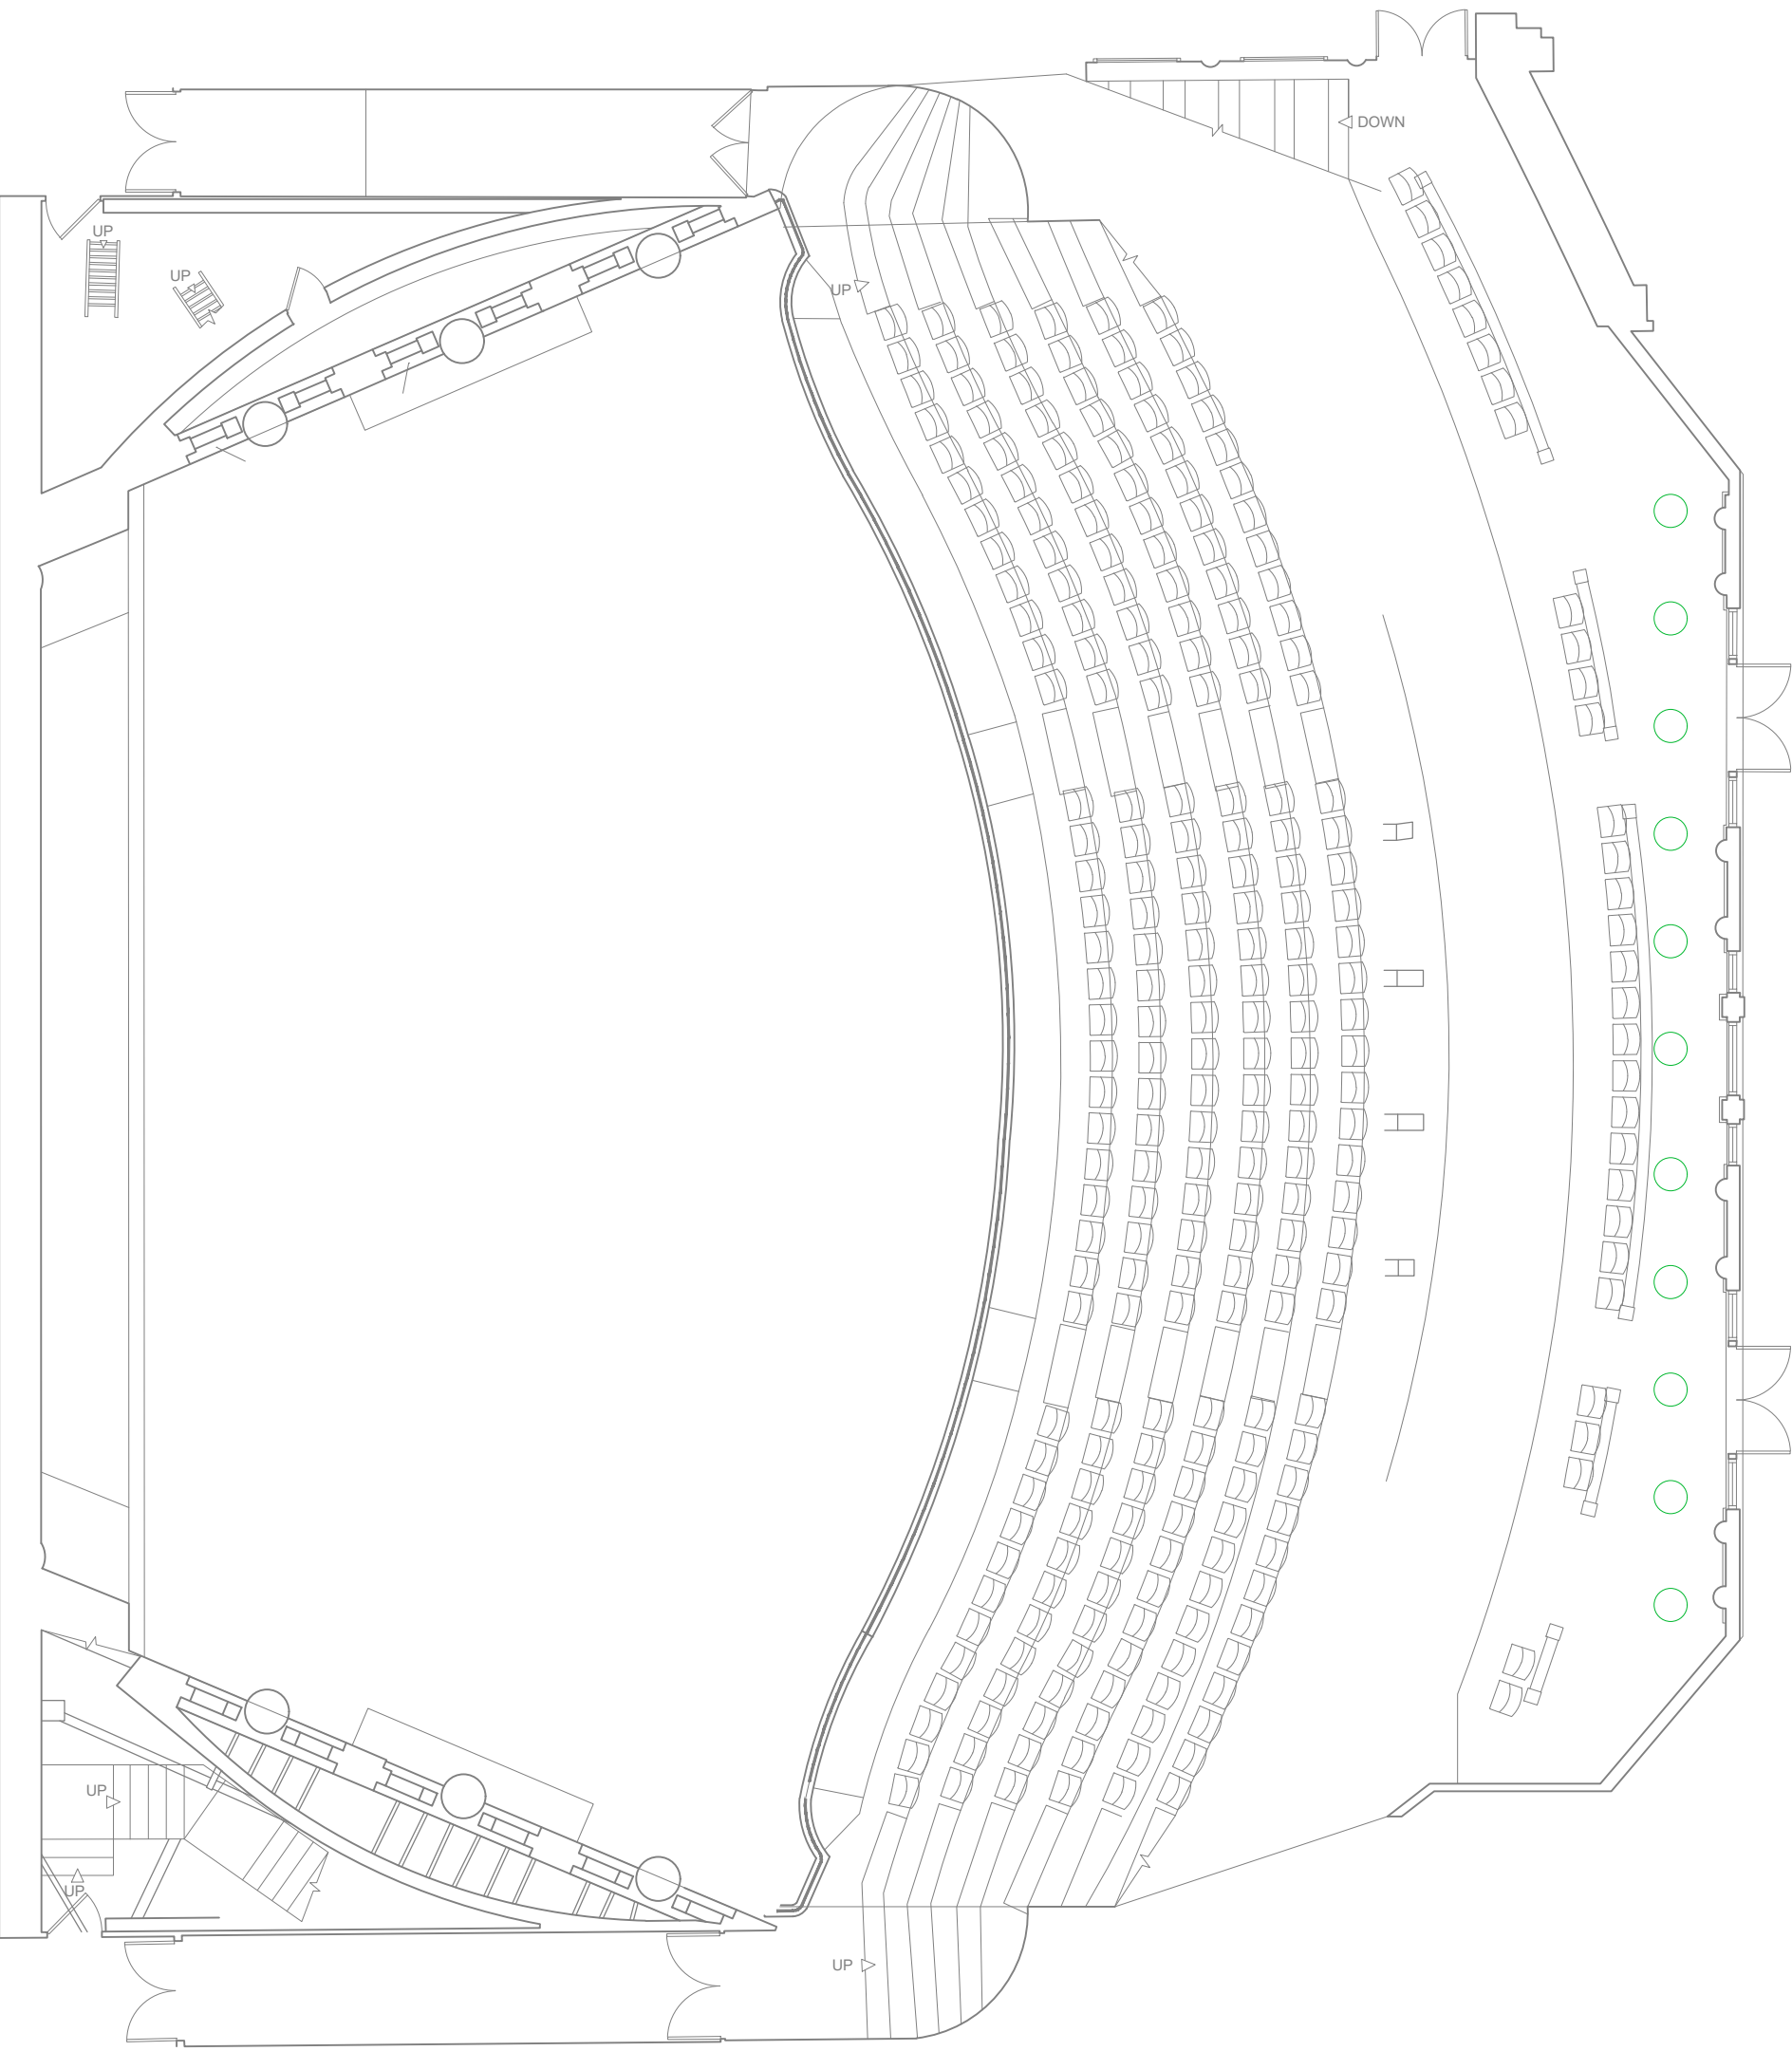

PROPOSED AUDITORIUM REFLECTED CEILING PLAN - CIRCLE TIER
1:100

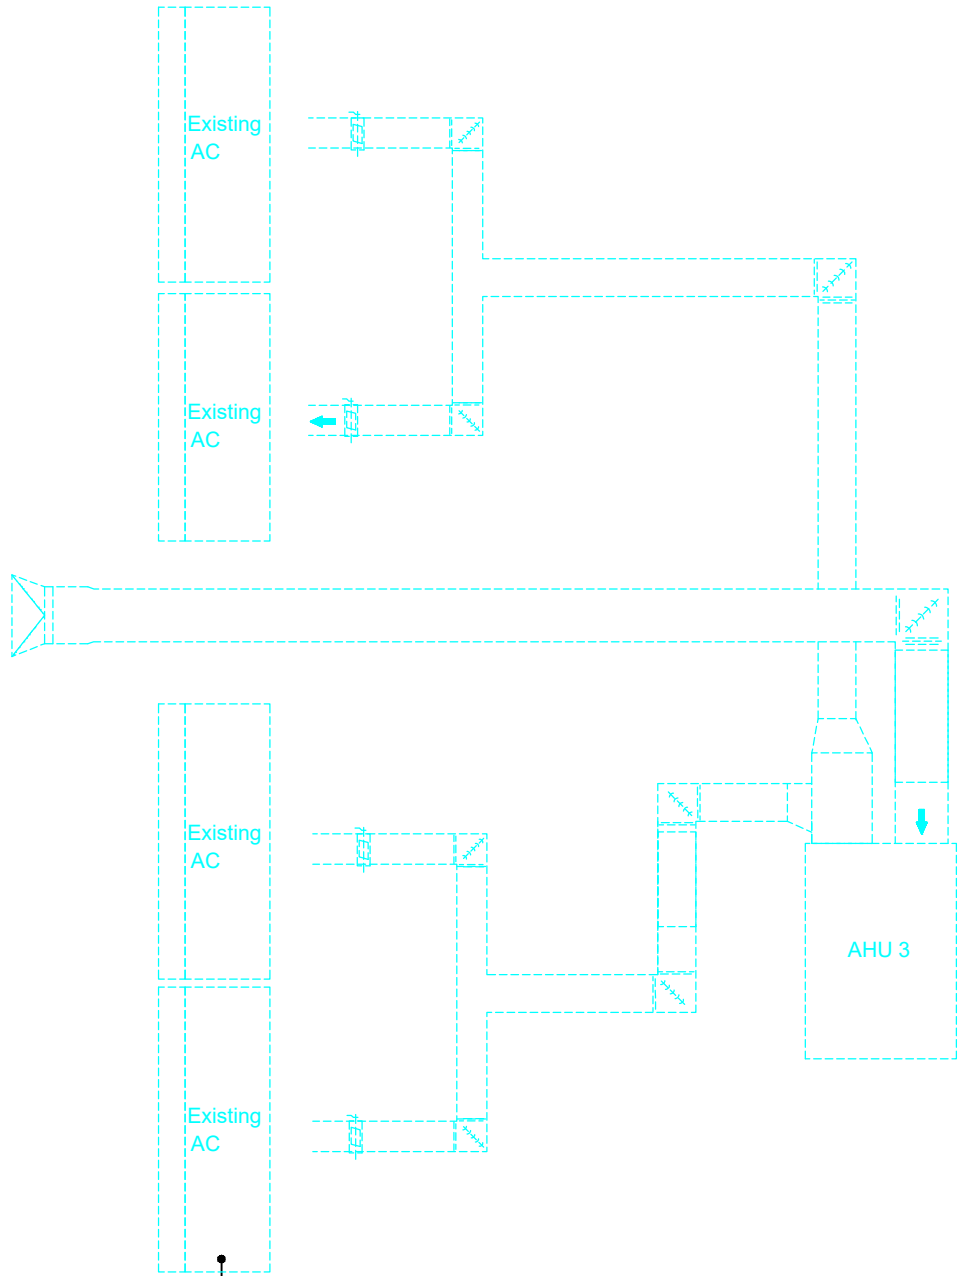

 Proposed services to make use of existing routes and terminations/ external vent positions on front elevation.

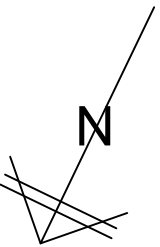

REV B: 15/07/2022 layout update based on M&E consultant information
REV A: 13/07/2022 Additional notes added
OSBORNESCHARTEREDARCHITECTS
The Balconies • Hanley Swan • Malvern • Worcestershire • WR8 0DN
T: 01684 311303 E: architecture@osbornesarchitects.com F: 01684311255 W: osbornesarchitects.com

CLIENT ATG
PROJECT MANCHESTER PALACE THEARTE
TITLE EXSITING AND PROPOSED REFLECTED CEILING PLANS CIRCLE TIER
SCALE 1:100 @ A1
DATE MAY 2022
DRAWN TL
DRAWING NUMBER 22-105-GA3B