


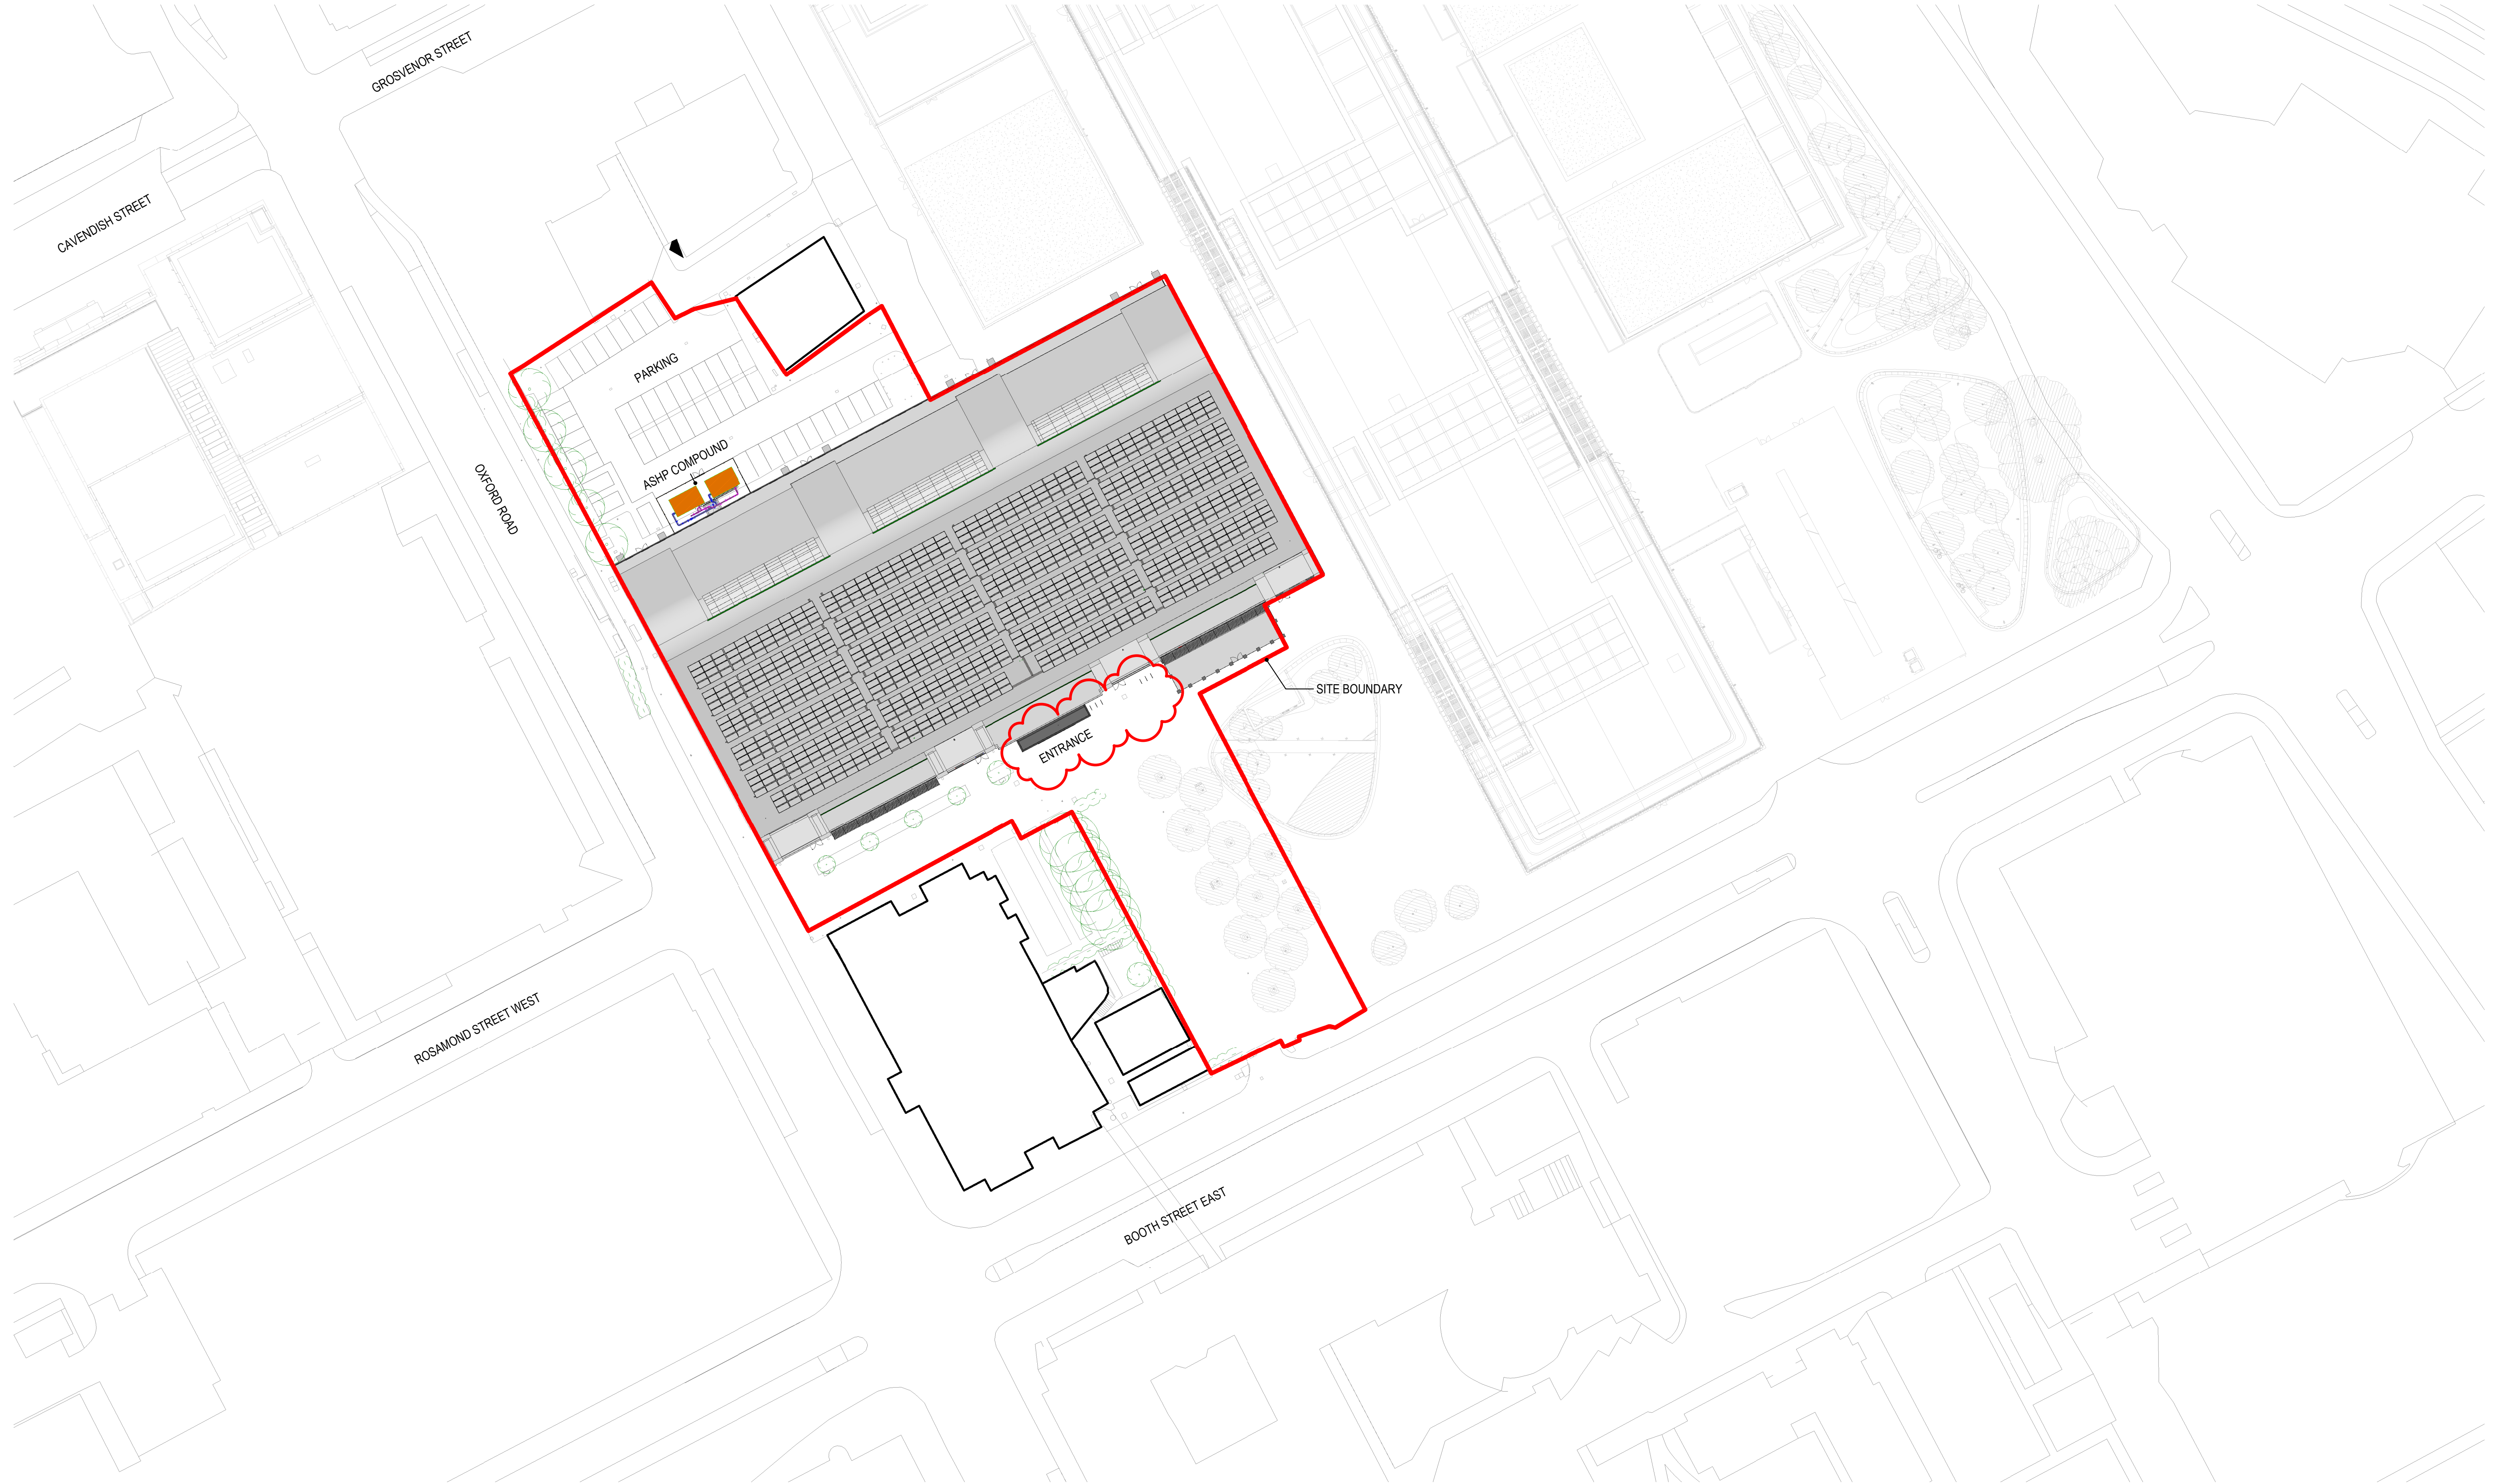

1 | Site GA

1 : 500

rev/	date/	by/	revision notes/
A	01.06.21	DAS	Updated to show approximate location of neighbouring Mec-D Development.
B	22.06.21	DAS	ASHP Compound indicated.
C	30.06.21	DAS	Photovoltaic array indicated & ASHP compound updated.
D	22.07.21	DJ	Stage 3 Issue.
E	13.08.21	DJ	Updates to KIER comments. Mark up drawings dated 04.08.2021.
F	26.08.21	DJ	Planning Issue.
C1	17.01.22	DJ	Stage 5 issue - Site plan.
C2	20.07.22	DJ	Planning issue.

notes:

Levels and Geometry based on Existing Survey.
— Site boundary line

keyplan:

client:
Manchester City Council
project:
Manchester Aquatics Centre
title:
Proposed Site Plan
POZ job no:
P5471
BS drawing no:
MAC- PAL- Z0- ZZ- DR- A- 1050

status:
Planning
revision:
C2
drawing no:
1050
date: 03/08/21
scale: 1 : 500
drawn by: DJ