




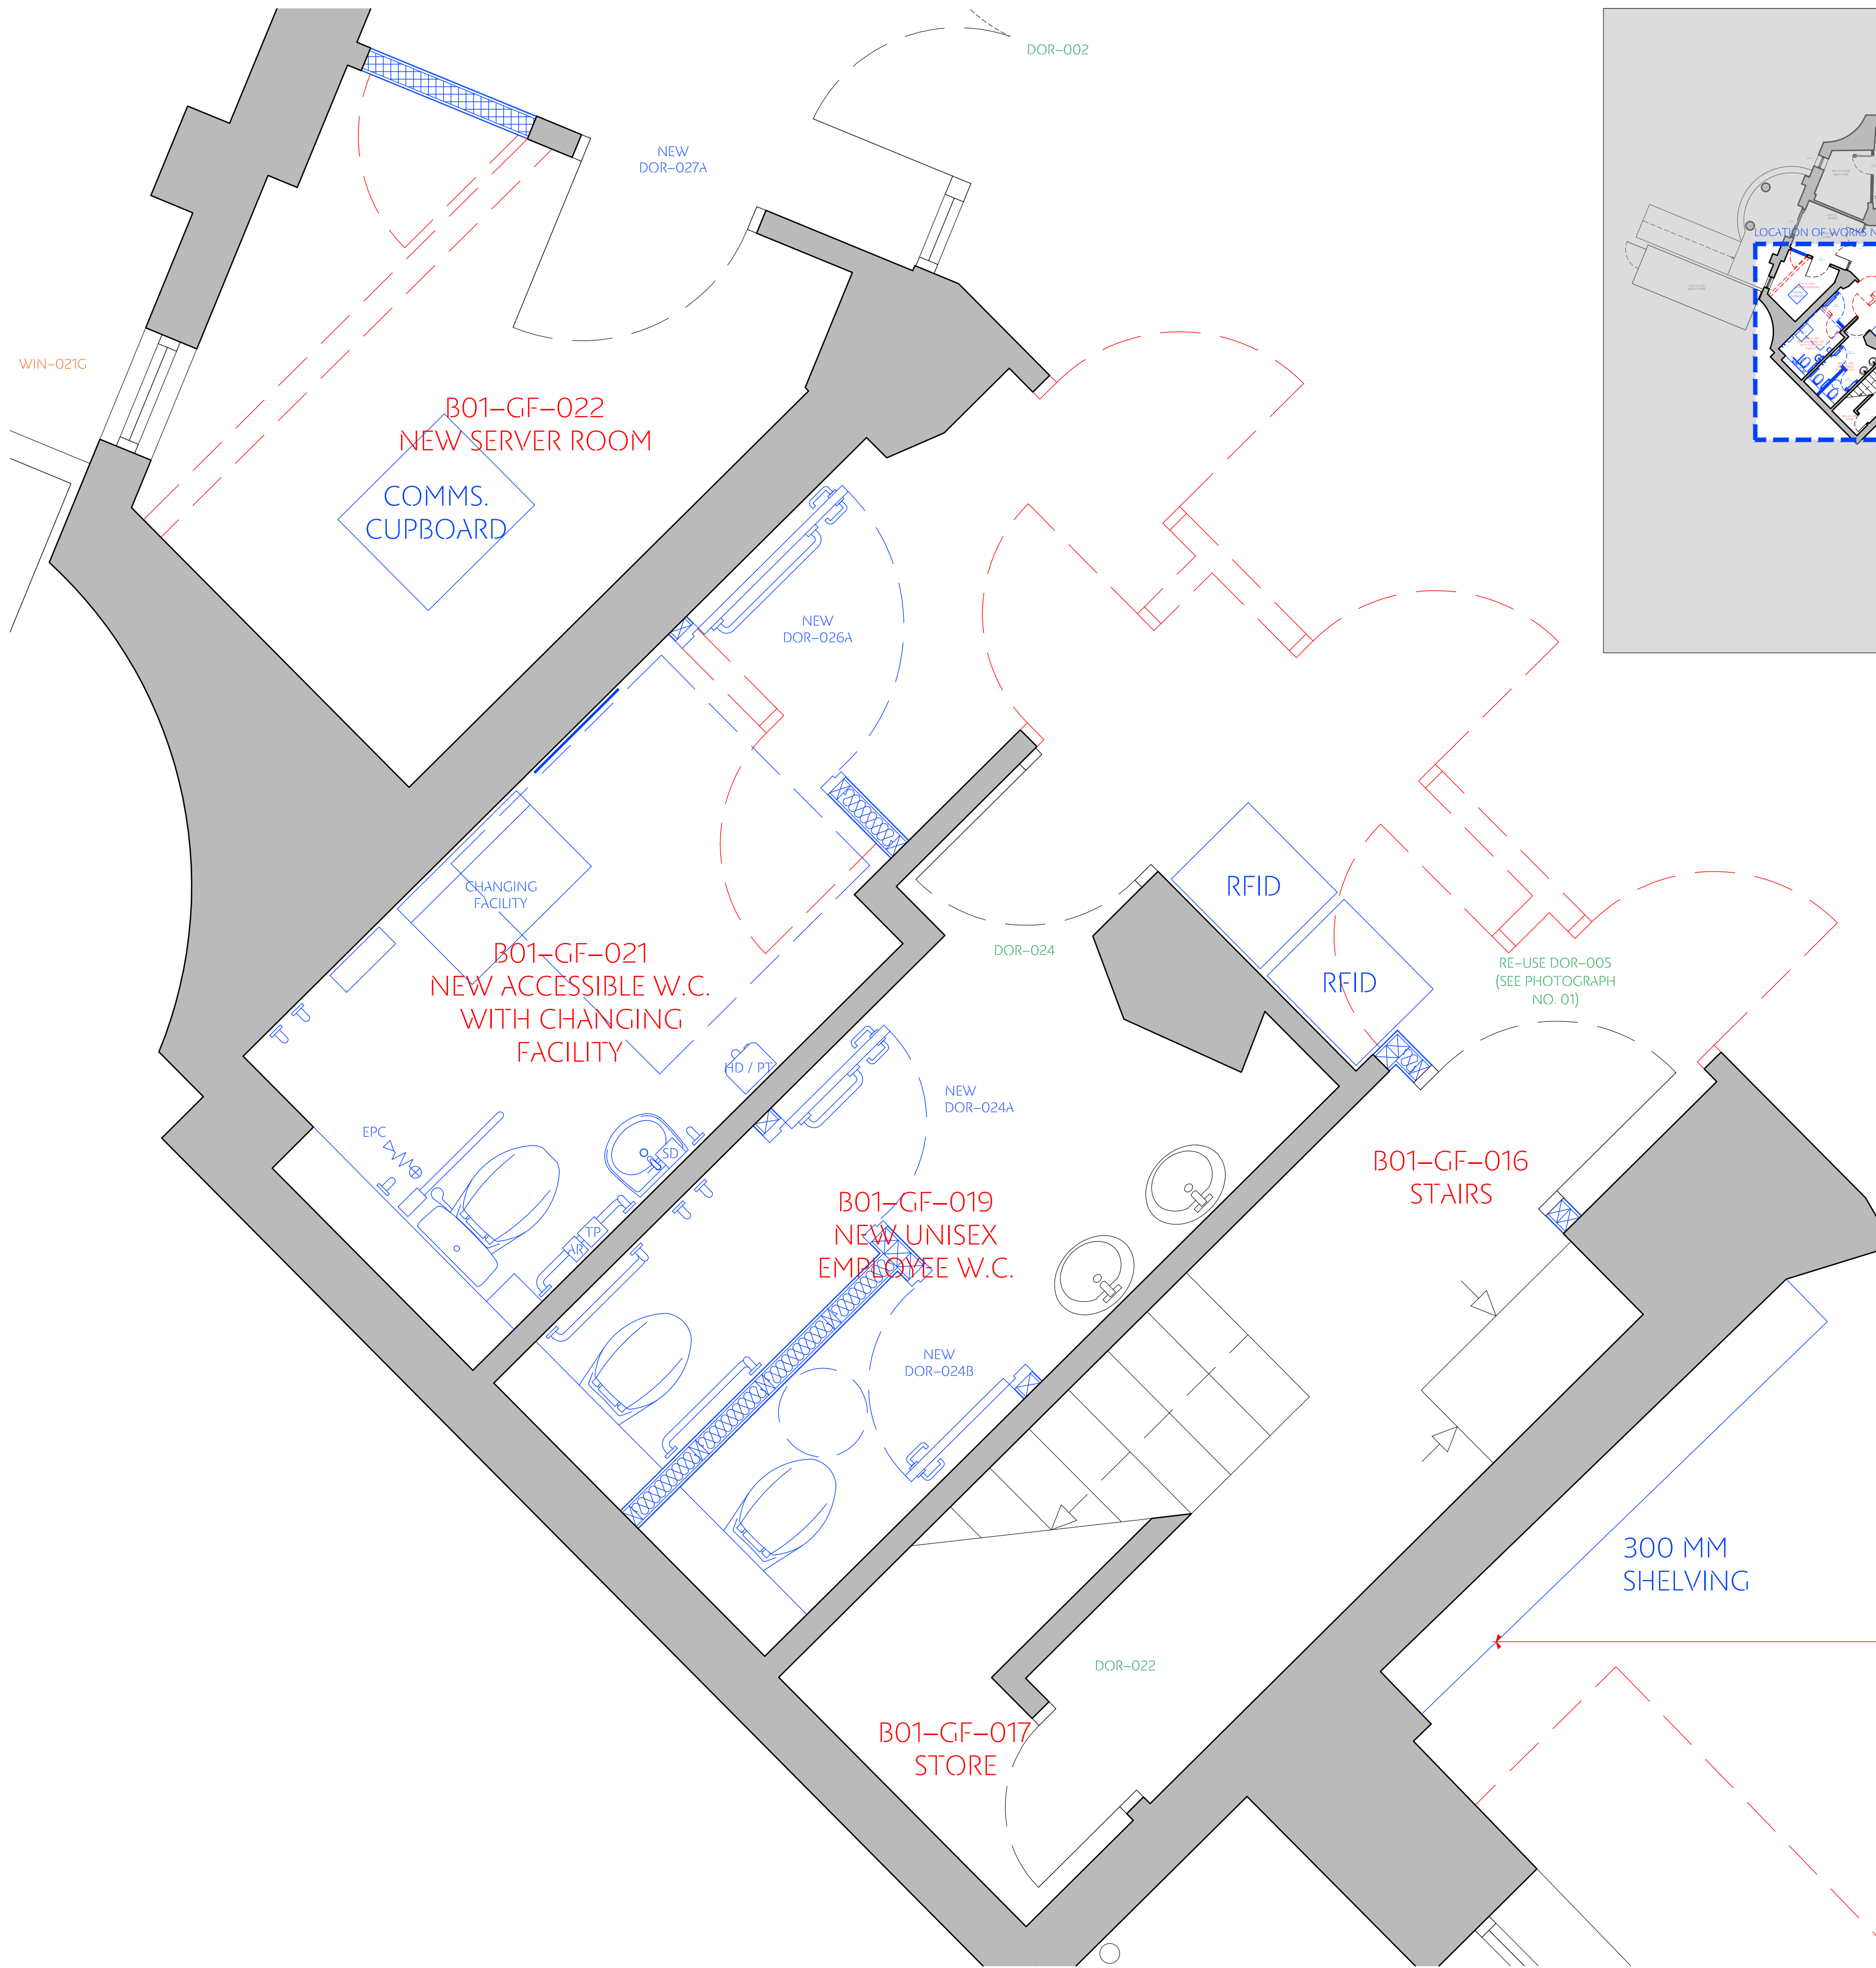

LOCATION OF WORKS NO. 1
Ground Floor Plan as Proposed
Scale 1:20

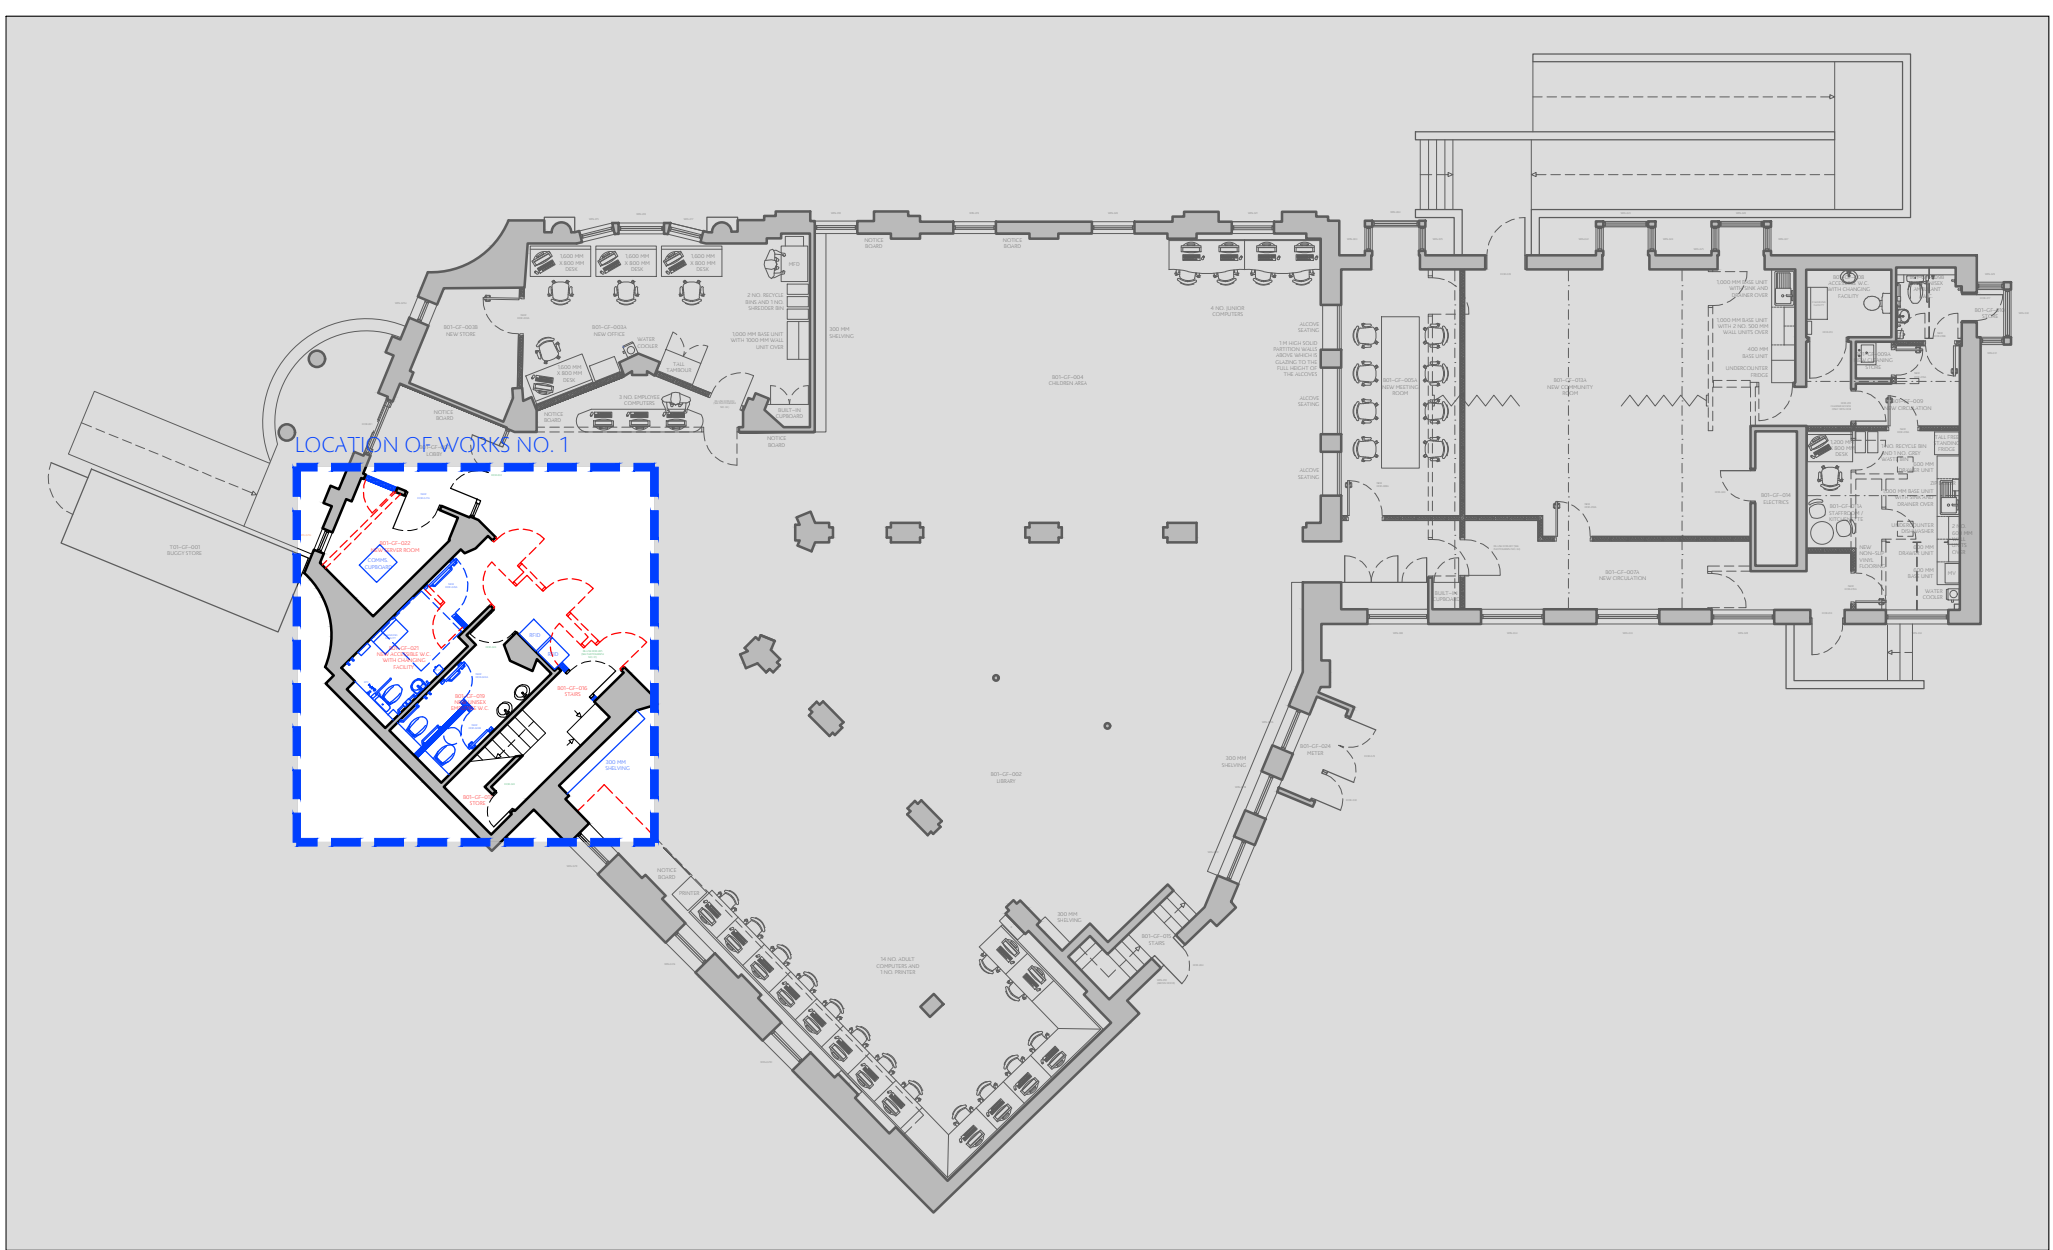

Key Plan
Scale 1:200

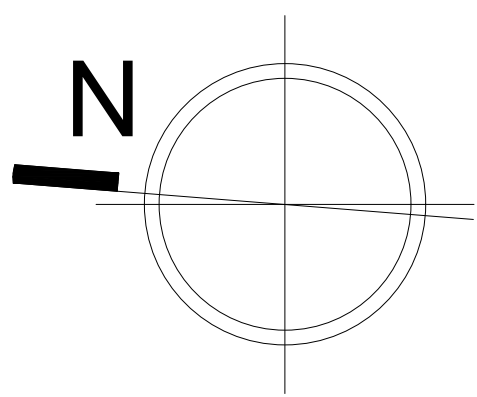

1. DO NOT SCALE FROM THIS DRAWING - USE FIGURED DIMENSIONS ONLY.
2. READ IN CONJUNCTION WITH ALL OTHER CONSULTANTS / SPECIALISTS DRAWINGS, REPORT ANY DISCREPANCIES BEFORE AFFECTED WORK COMMENCES.
3. ALL SETTING OUT DIMENSIONS TO BE CHECKED ON SITE BY CONTRACTOR BEFORE WORK COMMENCES.
4. THIS DRAWING REMAINS COPYRIGHT OF KEP CZYK PEARCE SANDERSON LTD. COPY / DISTRIBUTE ONLY WITH CONSENT OF THE AUTHOR.

KEY	
	PUBLIC
	MEETING
	CLERICAL
	KITCHEN
	RESTROOM
	M&E
	STORAGE
	CIRCULATION
ROOM REFERENCES	
DOOR REFERENCES	
WINDOW REFERENCES	
R	RADIATOR
---	REMOVALS AS PROPOSED
---	NEW WORKS AS PROPOSED



Photograph No. 01
DOR-005

Maximum height 1,240 mm (to the underside of the trunking).

Rev. B Revised Layout of Adult Computers and B01-GF-022 (LMC 2022 07 08)	Location of Works No. 1 as Proposed			
Rev. A Amended North Symbol (LMC 2022 07 05)	Contract Open Libraries Development	Contract No. 2141	Drawn LMC	Drawing No. FR 003
	Client Manchester City Council	Date May 2022	Revision B	Scale Various @ A1
	Building / Structure Chorlton District Library, Chorlton-cum-Hardy	Address: 75 Wilmslow Road, Handforth, Cheshire SK9 3EN		
	KEPCZYK PEARCE SANDERSON ARCHITECTS, SURVEYORS & HISTORIC BUILDING CONSULTANTS		Tel: 01625 400103	