


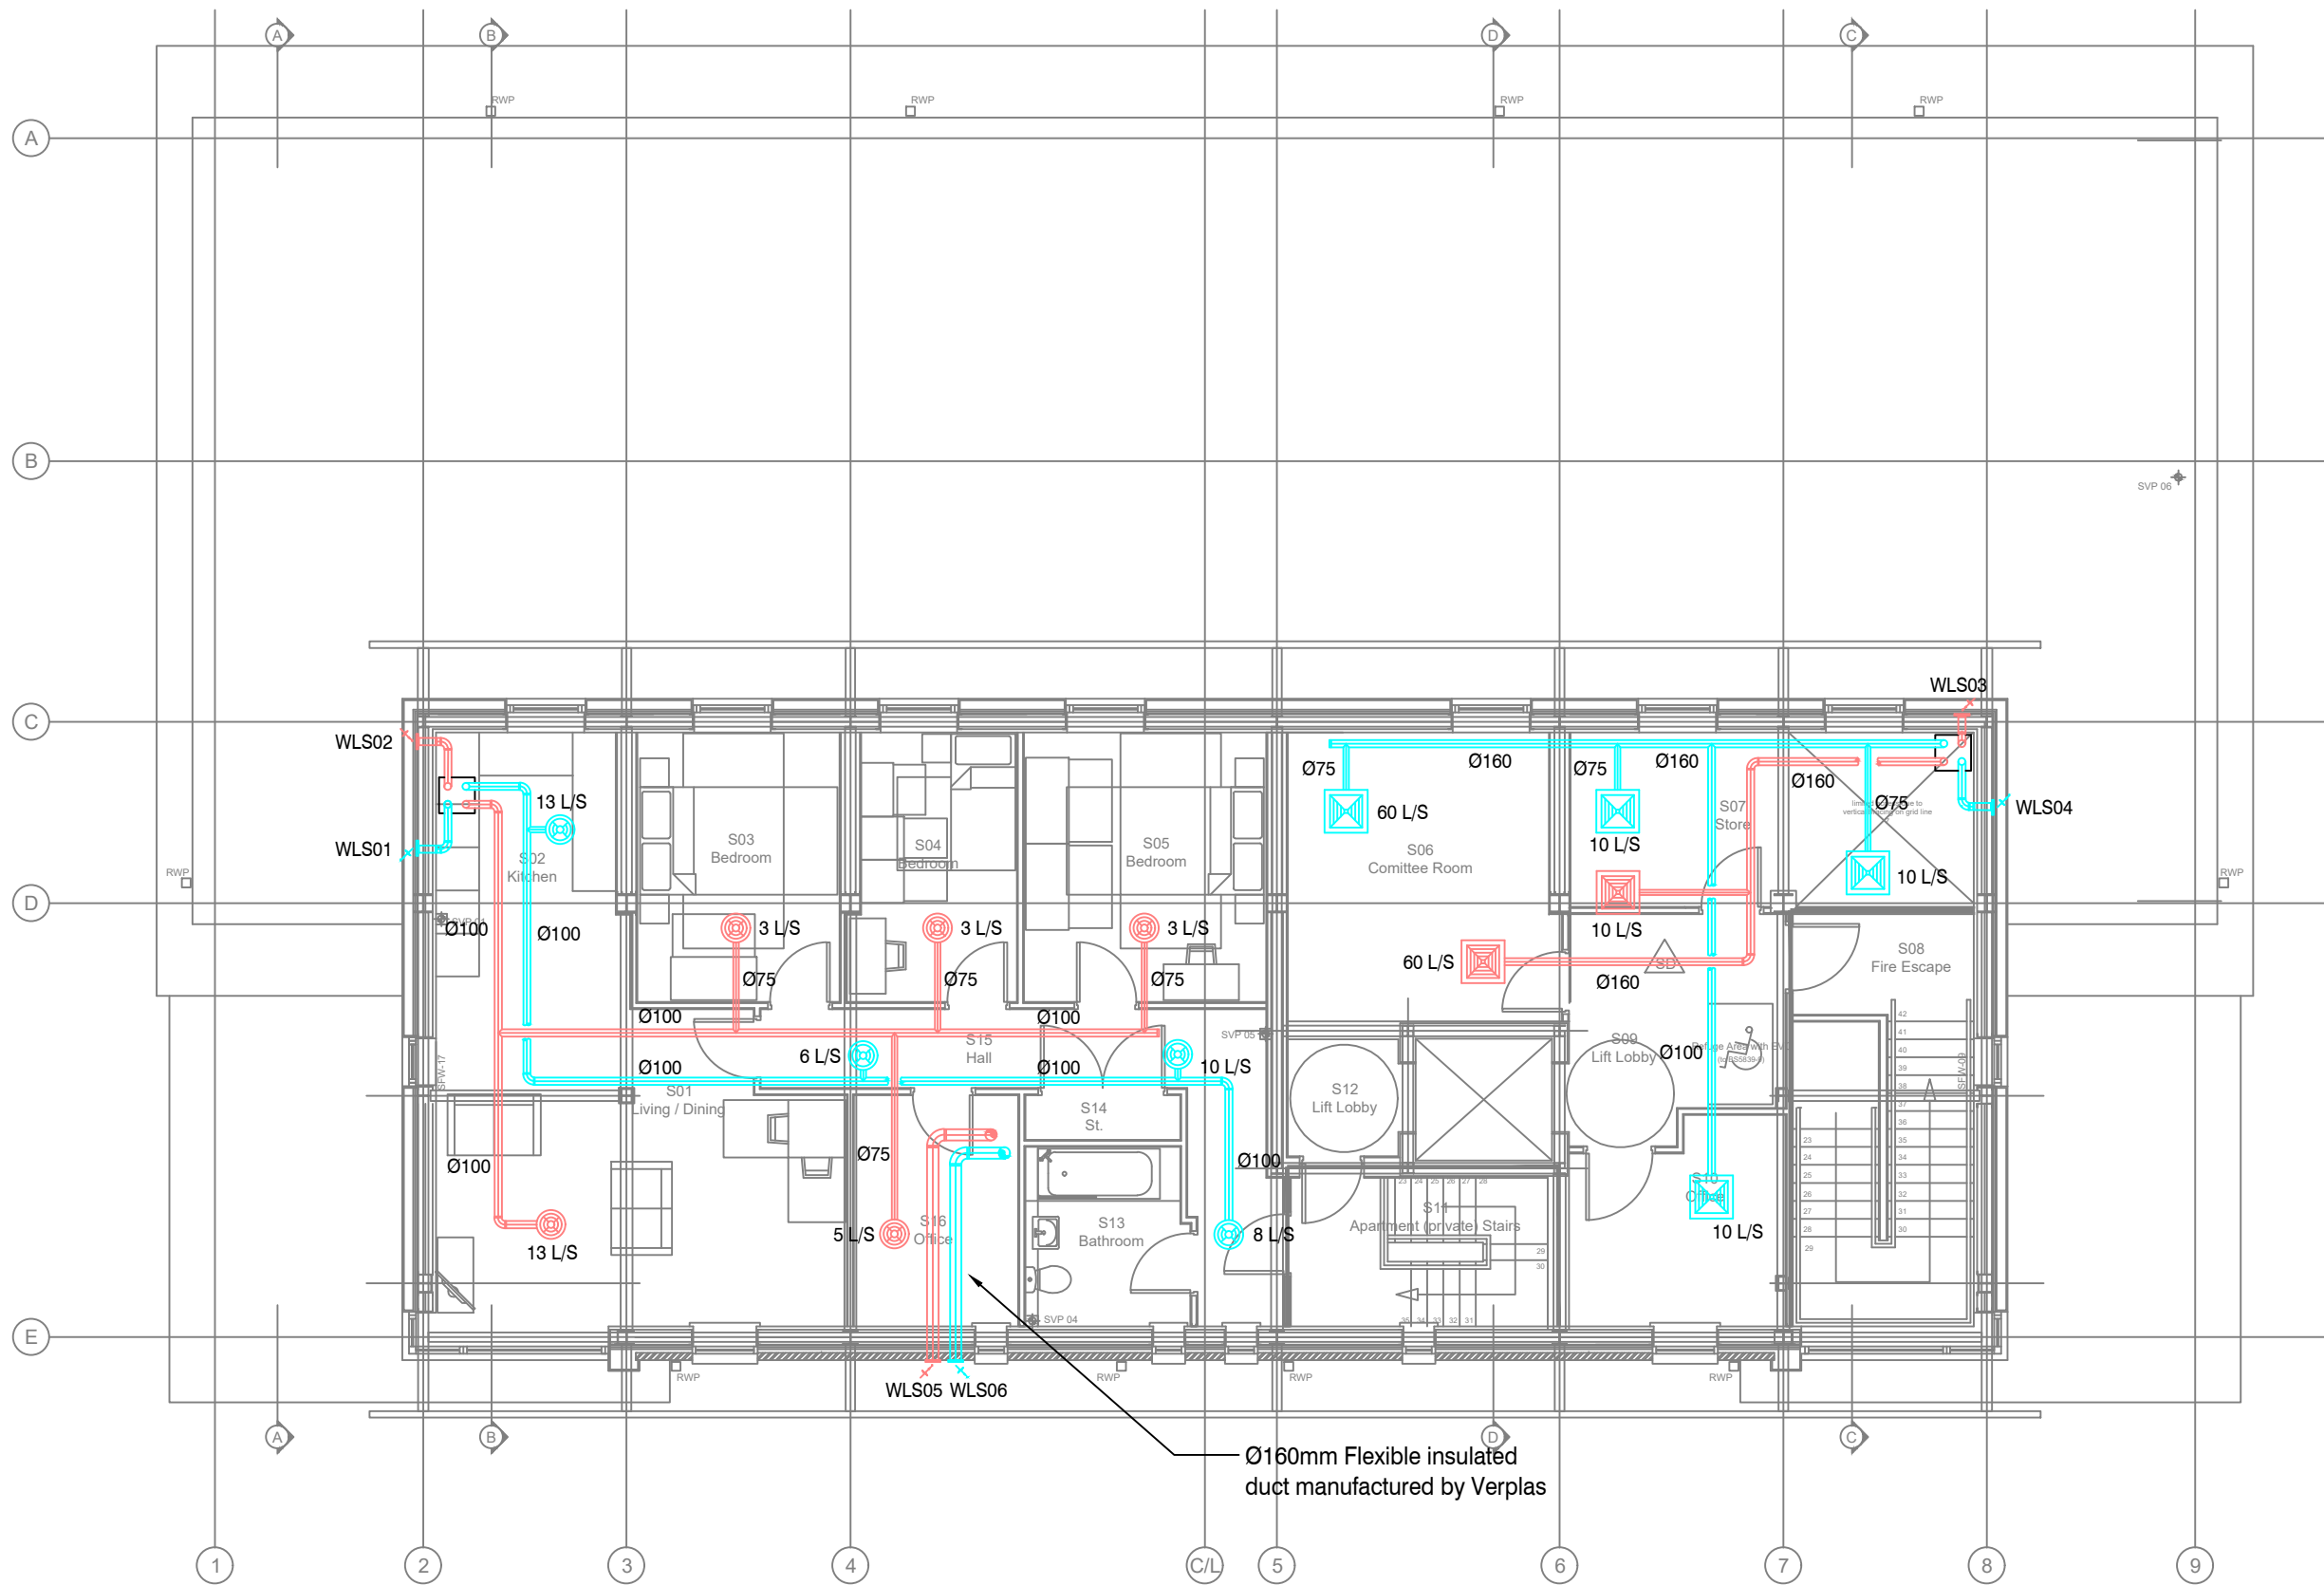

Second Floor Plan

GENERAL NOTES

1. Drawings are to be read in conjunction with all relevant specifications, engineers, architects & services drawings, including approved builders work drawings. Contractor to notify engineer of discrepancies between structural drawings & specifications or other drawings.
2. All dimensions are in millimeters unless noted otherwise.
3. Do not scale from the drawings or the computer digital data, only figured dimensions are to be used.

©

This drawing and its contents are strictly the copyright of GLD



Certificate Number 16602-Q15-001
ISO 9001

GENERAL NOTES



HRU Mitsubishi Lossnay LGH100RVX-E



HRU Mitsubishi Lossnay LGH65RVX-E



HRU Mitsubishi Lossnay LGH50RVX-E



Comfort conditioner 4 way blow recessed unit PLTY 100VEM-E



Extract grille



Supply grille



Extract valve



Supply valve



Extractor fan



Plenum box with louver



Louvre



Heat Recovery Unit

T2	28.01.2022	Updated to suit updated architects layout	VG	PC
T1	12.05.2021	Updated to suit updated architects layout	VG	PC
P3	05.02.2021	Updated to suit revised layout	VG	PC
P2	16.10.2020	Updated to suit revised layout	VG	PC
P1	31.07.2020	Preliminary Issue	RW	PC
Rev:	Date:	Amendment:	Drawn:	Check:
Drawn:	RW	Date:	31.07.2020	Scale: 1:100 @ A3
Chkd:	PC	Date:	31.07.2020	X Ref: 4050 - GA Club Base

Client:



Project Title:
The Whitehouse Club

Drawing Title:
Second Floor
HVAC Layout

Status:
TENDER



Damhouse, Astley Hall Drive
Astley, Manchester, M29 7TX
W: www.gldtechnicalconsulting.co.uk
T: 01942889535 / 01616417097

Drawing No:
J115-GLD-00-DR-M-5700-003

Rev:
T2