




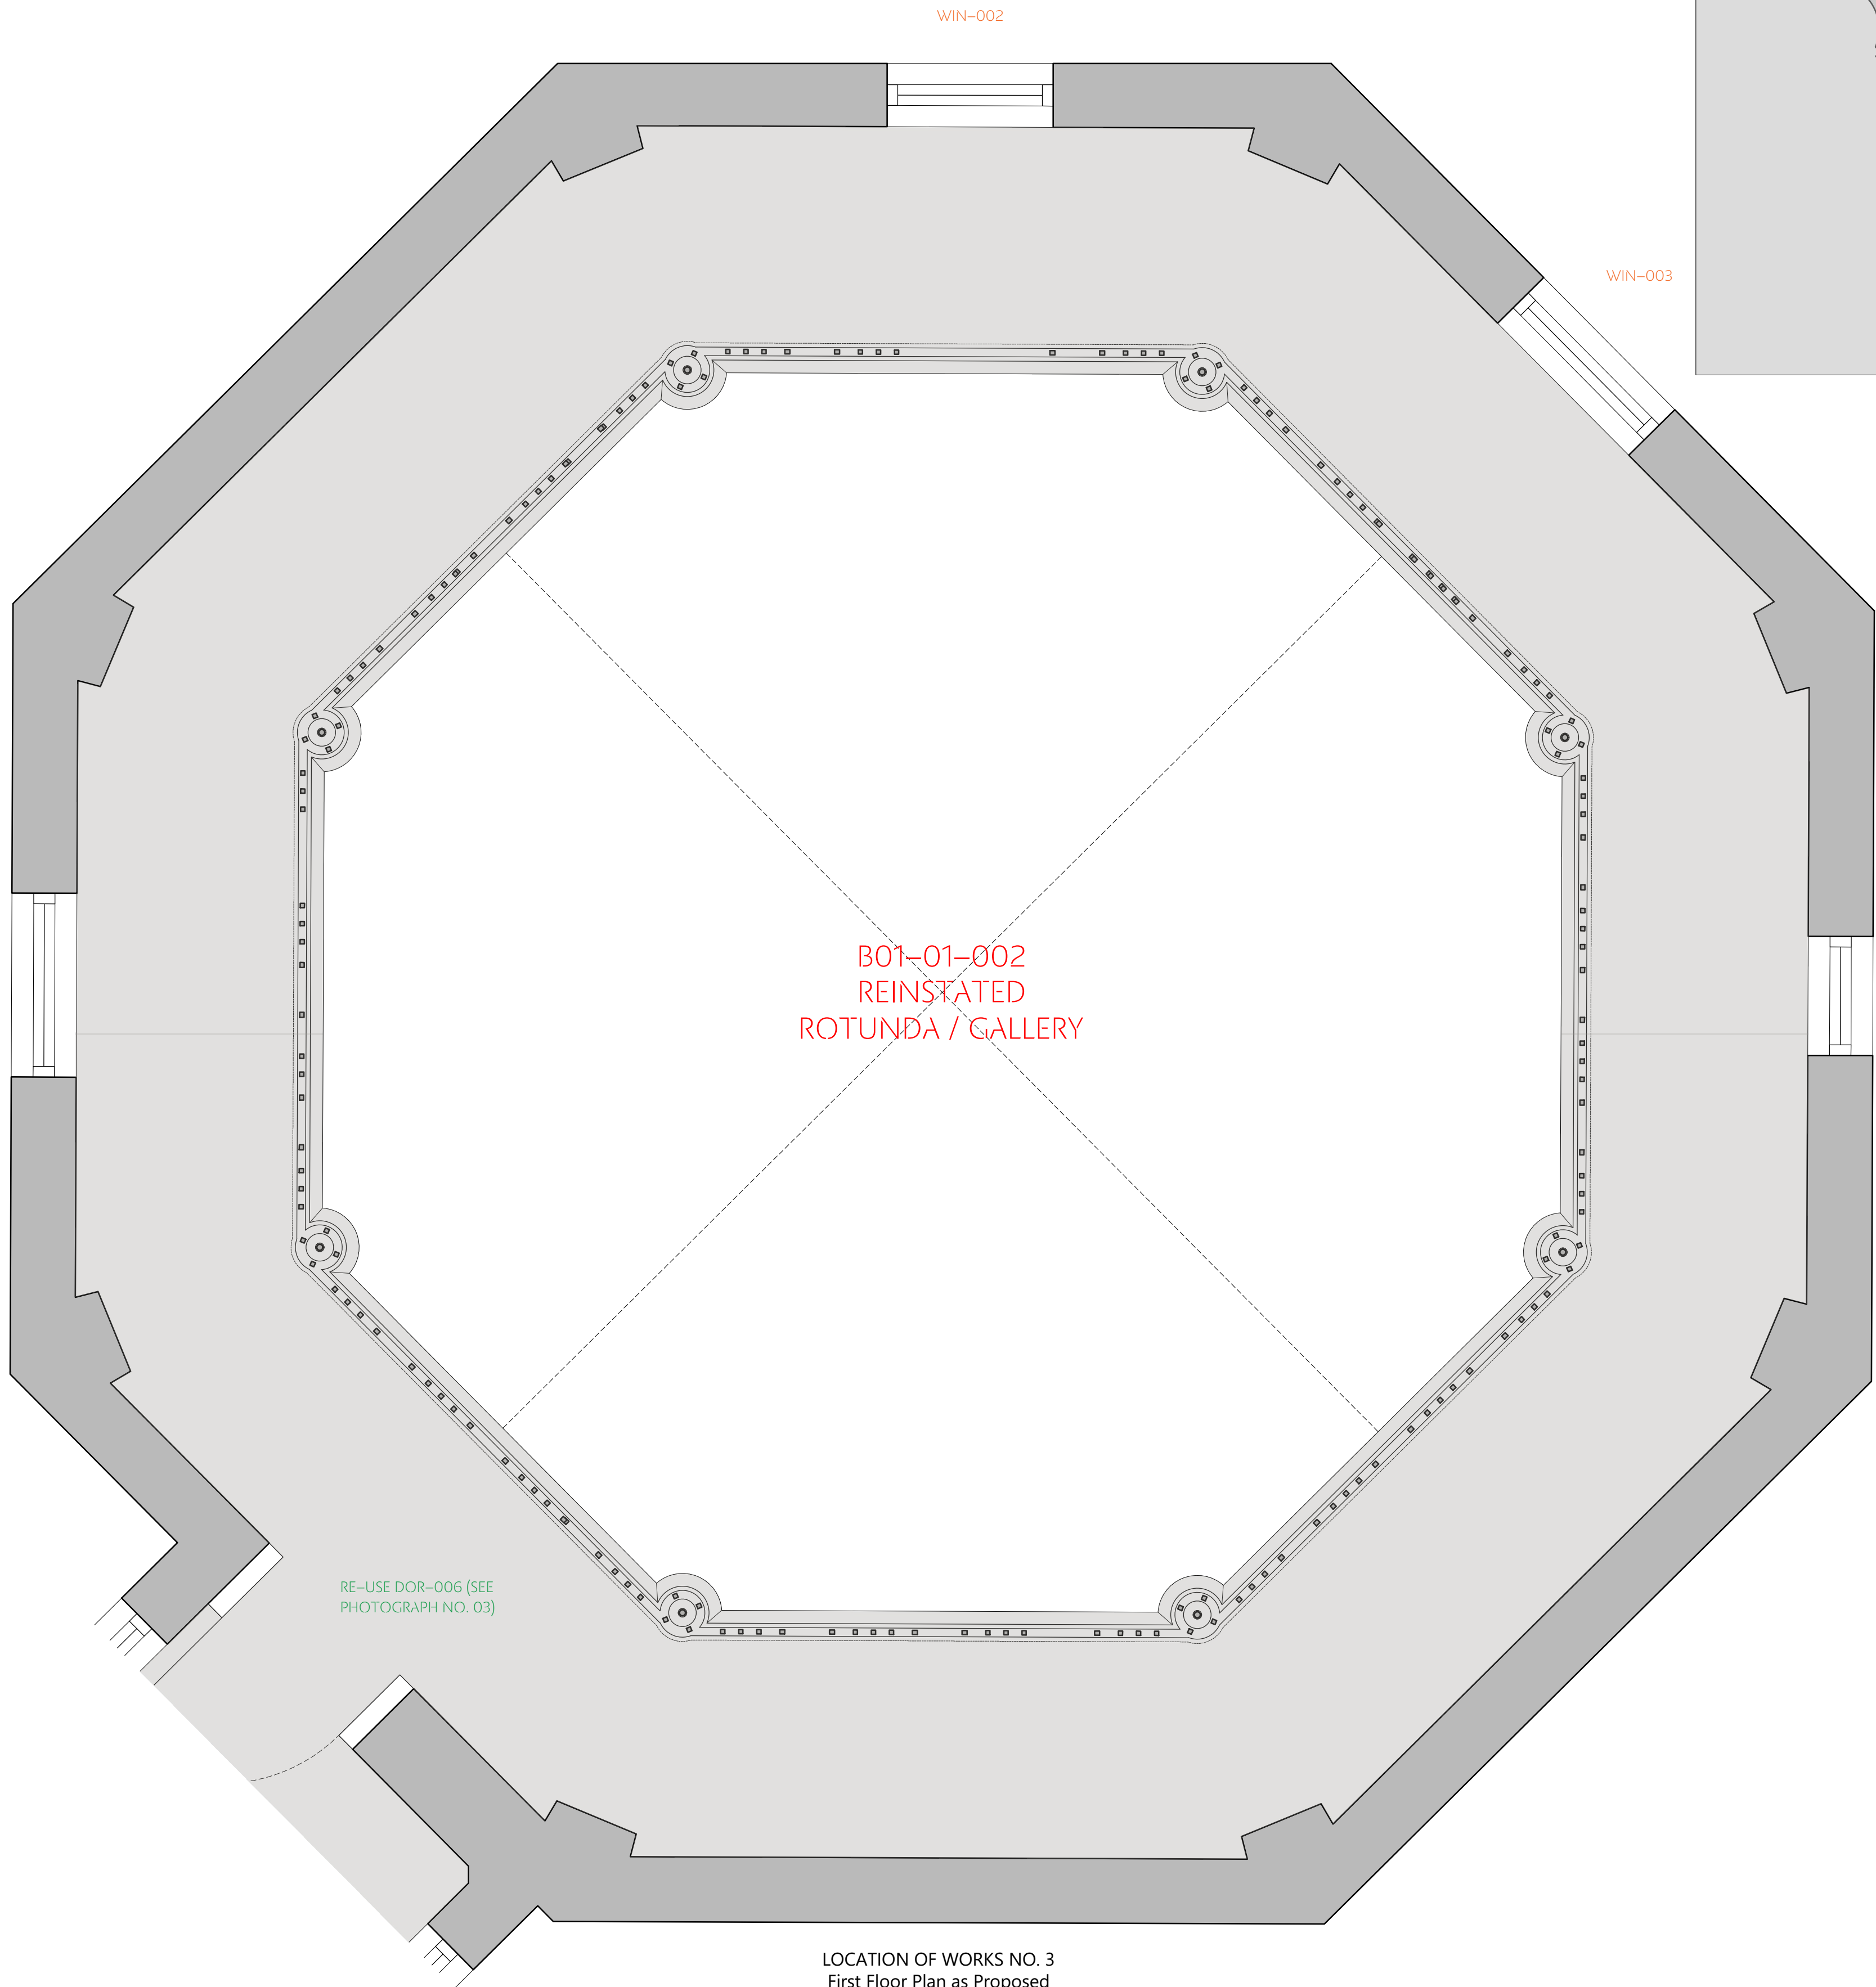

LOCATION OF WORKS NO. 3
First Floor Plan as Proposed
Scale 1:20

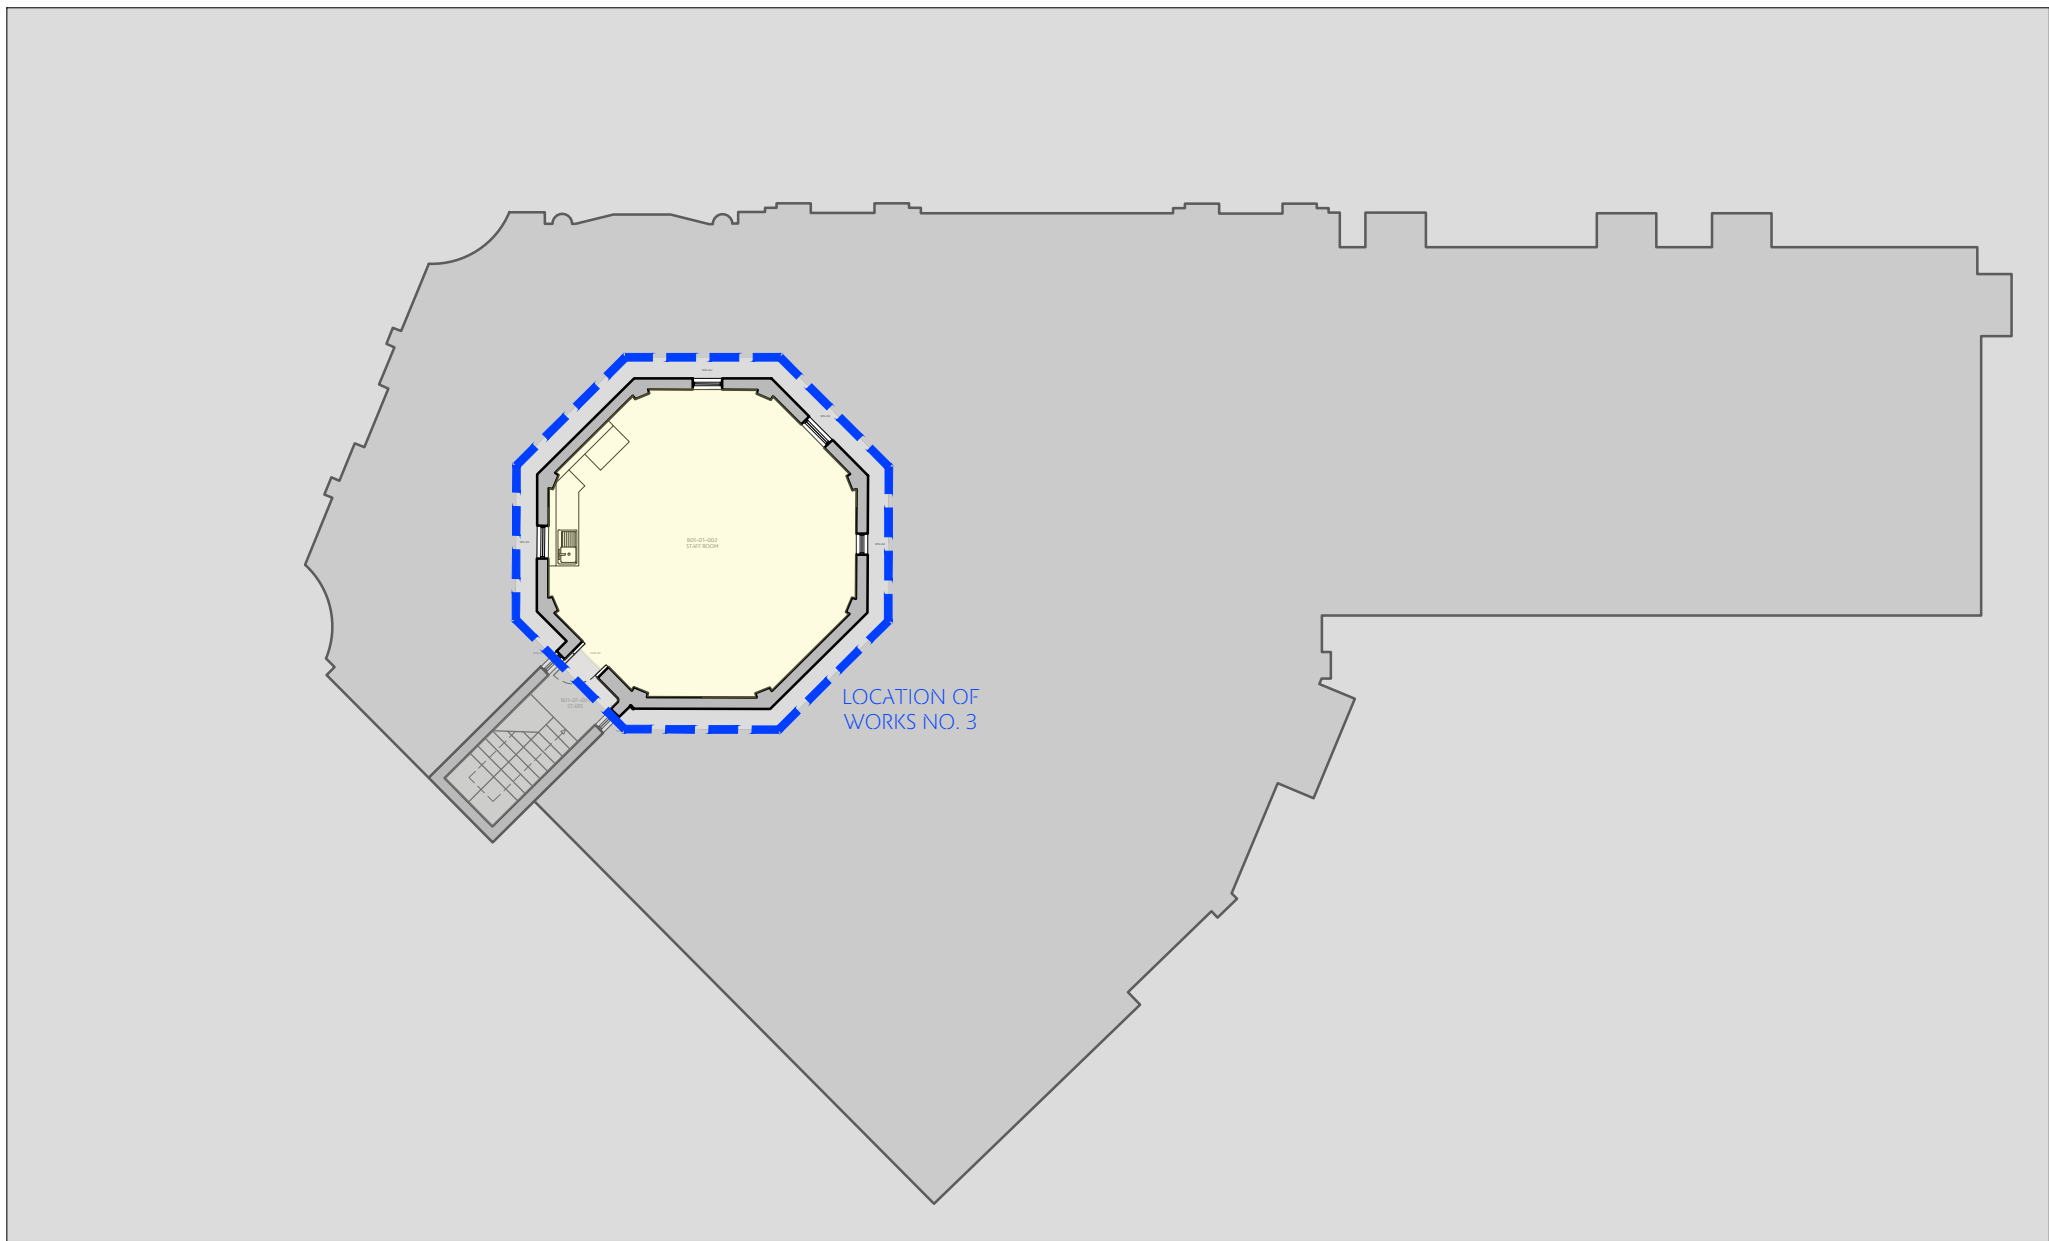

Key Plan
Scale 1:200

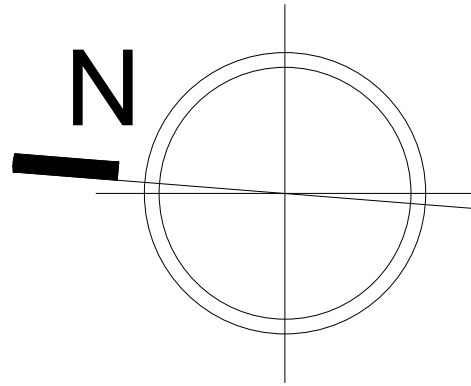

1. DO NOT SCALE FROM THIS DRAWING - USE FIGURED DIMENSIONS ONLY.
2. READ IN CONJUNCTION WITH ALL OTHER CONSULTANTS / SPECIALISTS DRAWINGS, REPORT ANY DISCREPANCIES BEFORE AFFECTED WORK COMMENCES.
3. ALL SETTING OUT DIMENSIONS TO BE CHECKED ON SITE BY CONTRACTOR BEFORE WORK COMMENCES.
4. THIS DRAWING REMAINS COPYRIGHT OF KEP CZYK PEARCE SANDERSON LTD. COPY / DISTRIBUTE ONLY WITH CONSENT OF THE AUTHOR.

KEY

- PUBLIC
- MEETING
- CLERICAL
- KITCHEN
- RESTROOM
- M&E
- STORAGE
- CIRCULATION

ROOM REFERENCES

DOOR REFERENCES

WINDOW REFERENCES

R RADIATOR

--- REMOVALS AS PROPOSED

--- NEW WORKS AS PROPOSED



Photograph No. 03
DOR-006

Rev. B Added Balustrade Detail (LMC | 2022 07 08)
Rev. A Amended North Symbol (LMC | 2022 07 05)

Contract		Open Libraries Development		Location of Works No. 3 as Proposed															
Client		Manchester City Council		Contract No.		2141		Drawn		LMC		Drawing No.		FR 005					
Building / Structure		Chorlton District Library, Chorlton-cum-Hardy		Date		May 2022		Revision		B		Scale		Various @ A1					
KEPCZYK PEARCE SANDERSON ARCHITECTS, SURVEYORS & HISTORIC BUILDING CONSULTANTS																Address: 75 Wilmslow Road, Handforth, Cheshire SK9 3EN Tel: 01625 400103			