


NOTICE

THIS DRAWING INCLUDING THE PRINCIPLES OF DESIGN, REMAINS THE PROPERTY OF HAYVERN ELECTRICAL LTD. AND IS ISSUED ON THE UNDERSTANDING THAT IT IS NOT REPRODUCED OR LOANED IN PART OR WHOLE EXCEPT WITH THE OWNERS WRITTEN CONSENT. IT IS NOT TO BE USED IN ANY MANNER THAT MAY BE DETRIMENTAL TO HAYVERN ELECTRICAL LTD. ACCEPTANCE OF THIS DRAWING WILL BE CONSIDERED AS AN AGREEMENT OF THE ABOVE.

| SYMBOL                                                                                | LEGEND OF SMALL POWER SYMBOLS                                                       |
|---------------------------------------------------------------------------------------|-------------------------------------------------------------------------------------|
|  | HAND DRIVER @1100mm AFL, c/w HIGH LEVEL FUSED CONNECTION UNIT                       |
|  | SUPPLY FOR UNDER COUNTER APPLIANCES SPUR ABOVE COUNTER, UNSWITCHED SOCKET 800mm AFL |
|  | 13A SINGLE SWITCHED SOCKET OUTLET                                                   |
|  | 13A TWIN SWITCHED SOCKET OUTLET                                                     |
|  | 13A TWIN SWITCHED SOCKET OUTLET                                                     |
|  | 13A SINGLE UNSWITCHED SOCKET OUTLET                                                 |
|  | 13A TWIN UNSWITCHED SOCKET OUTLET                                                   |
|  | OUTLET WITH INTEGRAL RCD PROTECTION                                                 |
|  | 13A UNSWITCHED FUSED CONNECTION UNIT                                                |
|  | 13A SWITCHED FUSED CONNECTION UNIT                                                  |
|  | N.B. NOTES SIGN                                                                     |
|  | ISOLATOR                                                                            |
|  | VRLH LIGHT FLOOR PLATE                                                              |
|  | FARP - FIRE ALARM REPEATER PANEL                                                    |
|  | TFR - FRIDGE, D.W., DISHWASHER                                                      |
|  | S - SURFACE, R - RECESSED                                                           |
|  | C - CLEANER SOCKETS, CCTV - CCTV CAMERA                                             |
|  | HL - HIGH LEVEL                                                                     |

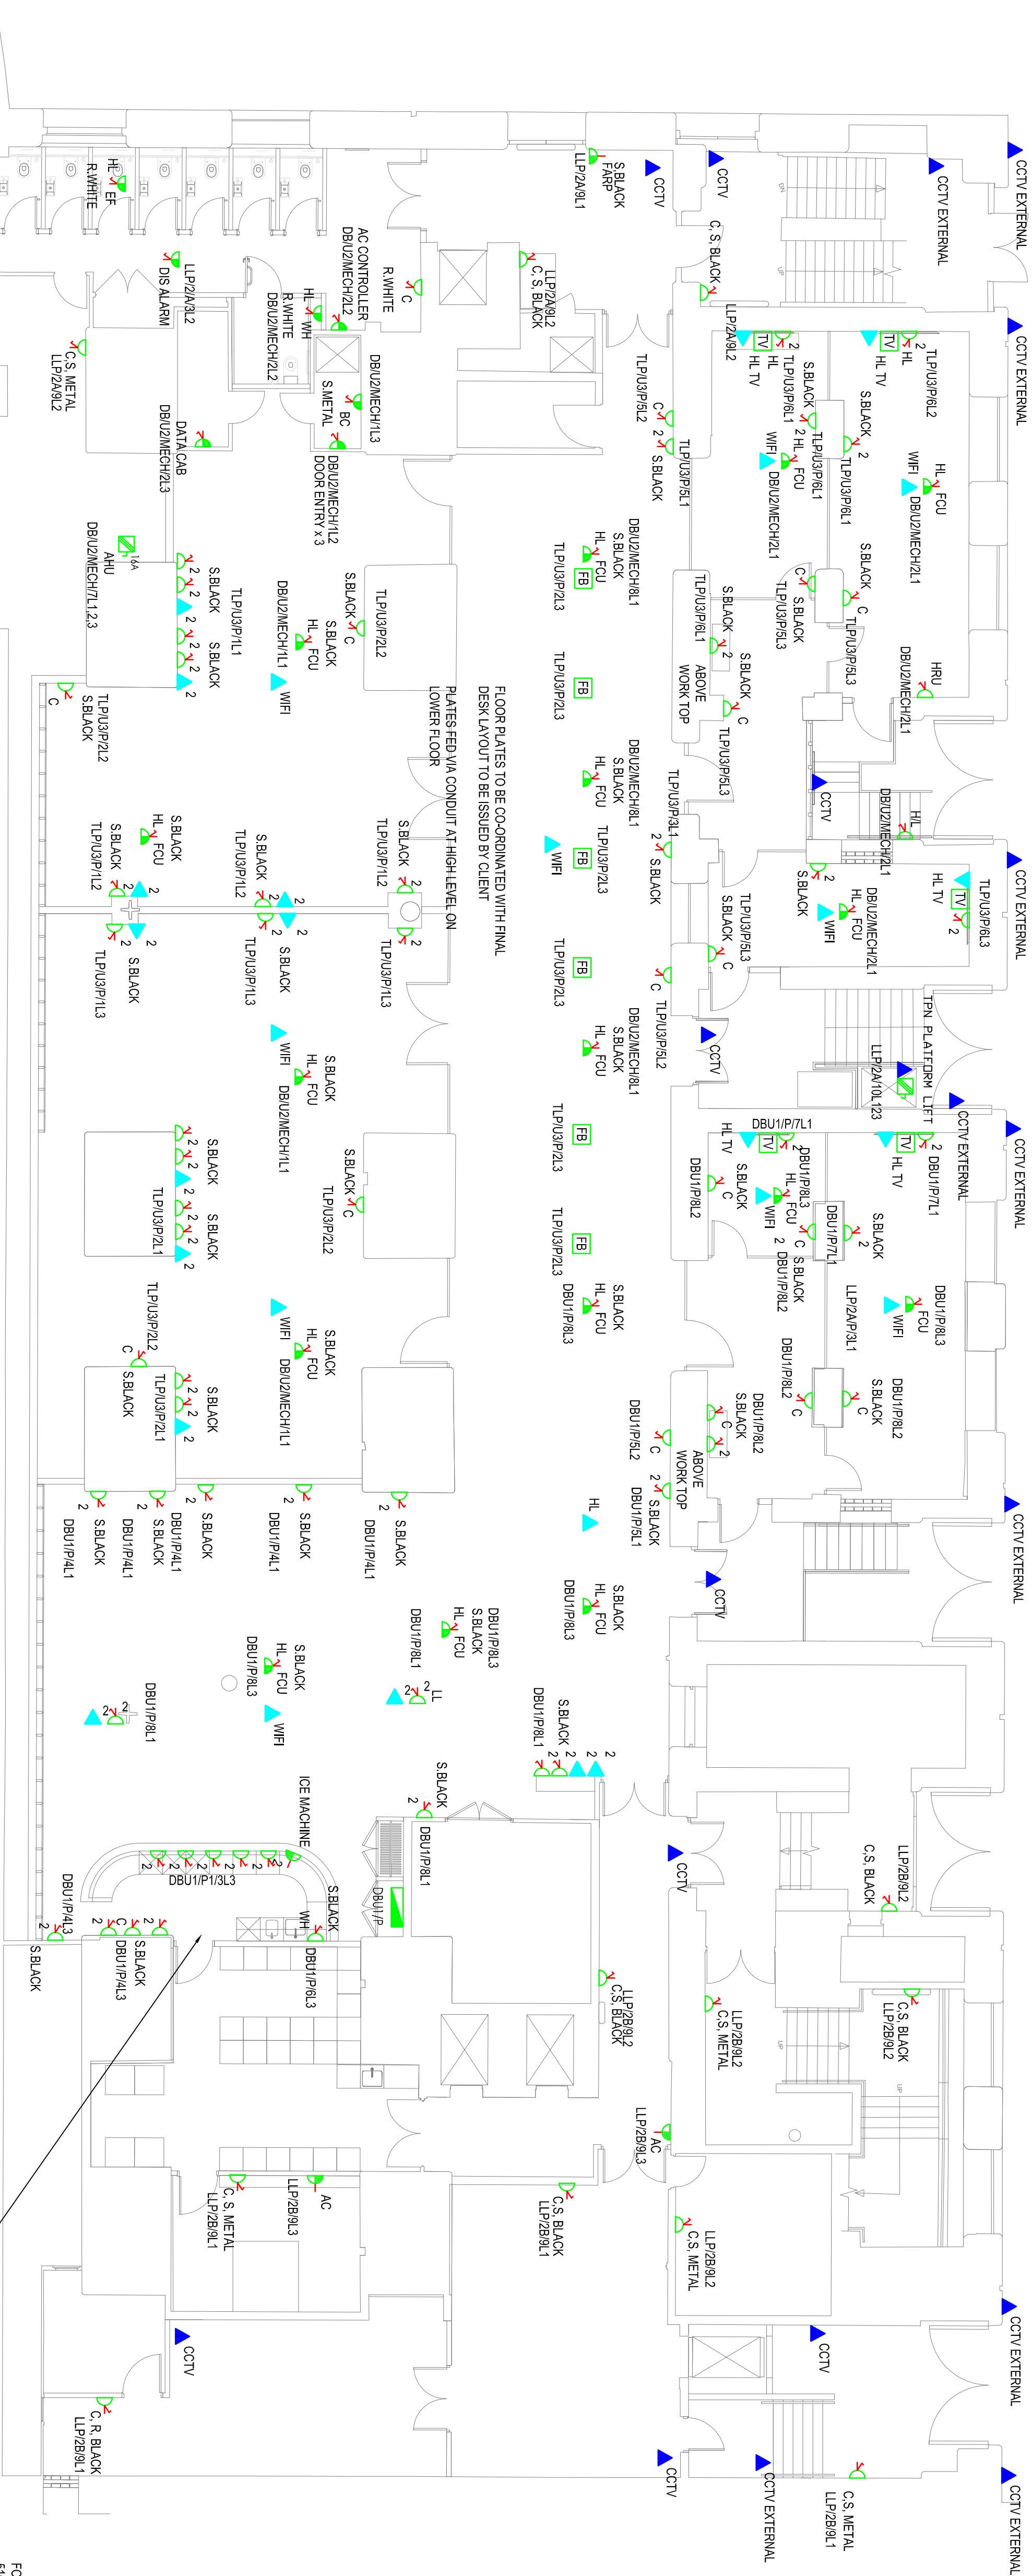

FOR POWER POSITIONS IN THIS AREA SEE DRAWING NO 0271)  
500 BAR POWER OUTLETS ARE AS FOLLOWS:  
2x10 TWIN SOCKET OUTLETS TO BRIDGE - BLACK FINISH  
8x10 TWIN SOCKET OUTLETS GENERAL USE - BLACK FINISH  
2x10 TWIN DATA OUTLETS, TILL AREA - BLACK FINISH  
2x10 TWIN DATA OUTLETS, TILL AREA  
1x10 SPUR - WATER HEATER  
1x10 TWIN SOCKET OUTLET - COFFEE MACHINE - BLACK FINISH  
1x10 TWIN SOCKET OUTLET - ICE CREAM MACHINE - BLACK FINISH  
1x10 ISOLATOR - COFFEE MACHINE

LEVEL 2 - SMALL POWER LAYOUT

AS FITTED DRAWING

| Revisions                                                                                                                                             | Description | Ref                          | Eng | Date |
|-------------------------------------------------------------------------------------------------------------------------------------------------------|-------------|------------------------------|-----|------|
| <div><p>56 QUEEN STREET, FARNWORTH, BOLTON, 01204 579975</p></div> |             |                              |     |      |
| Client MANCHESTER QUAYS LTD                                                                                                                           |             |                              |     |      |
| Project Title THE BONDED WAREHOUSE, PHASE 2                                                                                                           |             |                              |     |      |
| Drawing Title LEVEL 2 SMALL POWER LAYOUT                                                                                                              |             |                              |     |      |
| In Association with                                                                                                                                   |             |                              |     |      |
| Drawn by                                                                                                                                              | HR          | Scales 1:100@A1              |     |      |
| Checked by                                                                                                                                            | BN          | (work to figured dimensions) |     |      |
| Date                                                                                                                                                  | JULY 19     |                              |     |      |
| DWG No.                                                                                                                                               | E002        | Rev. A/F1                    |     |      |