


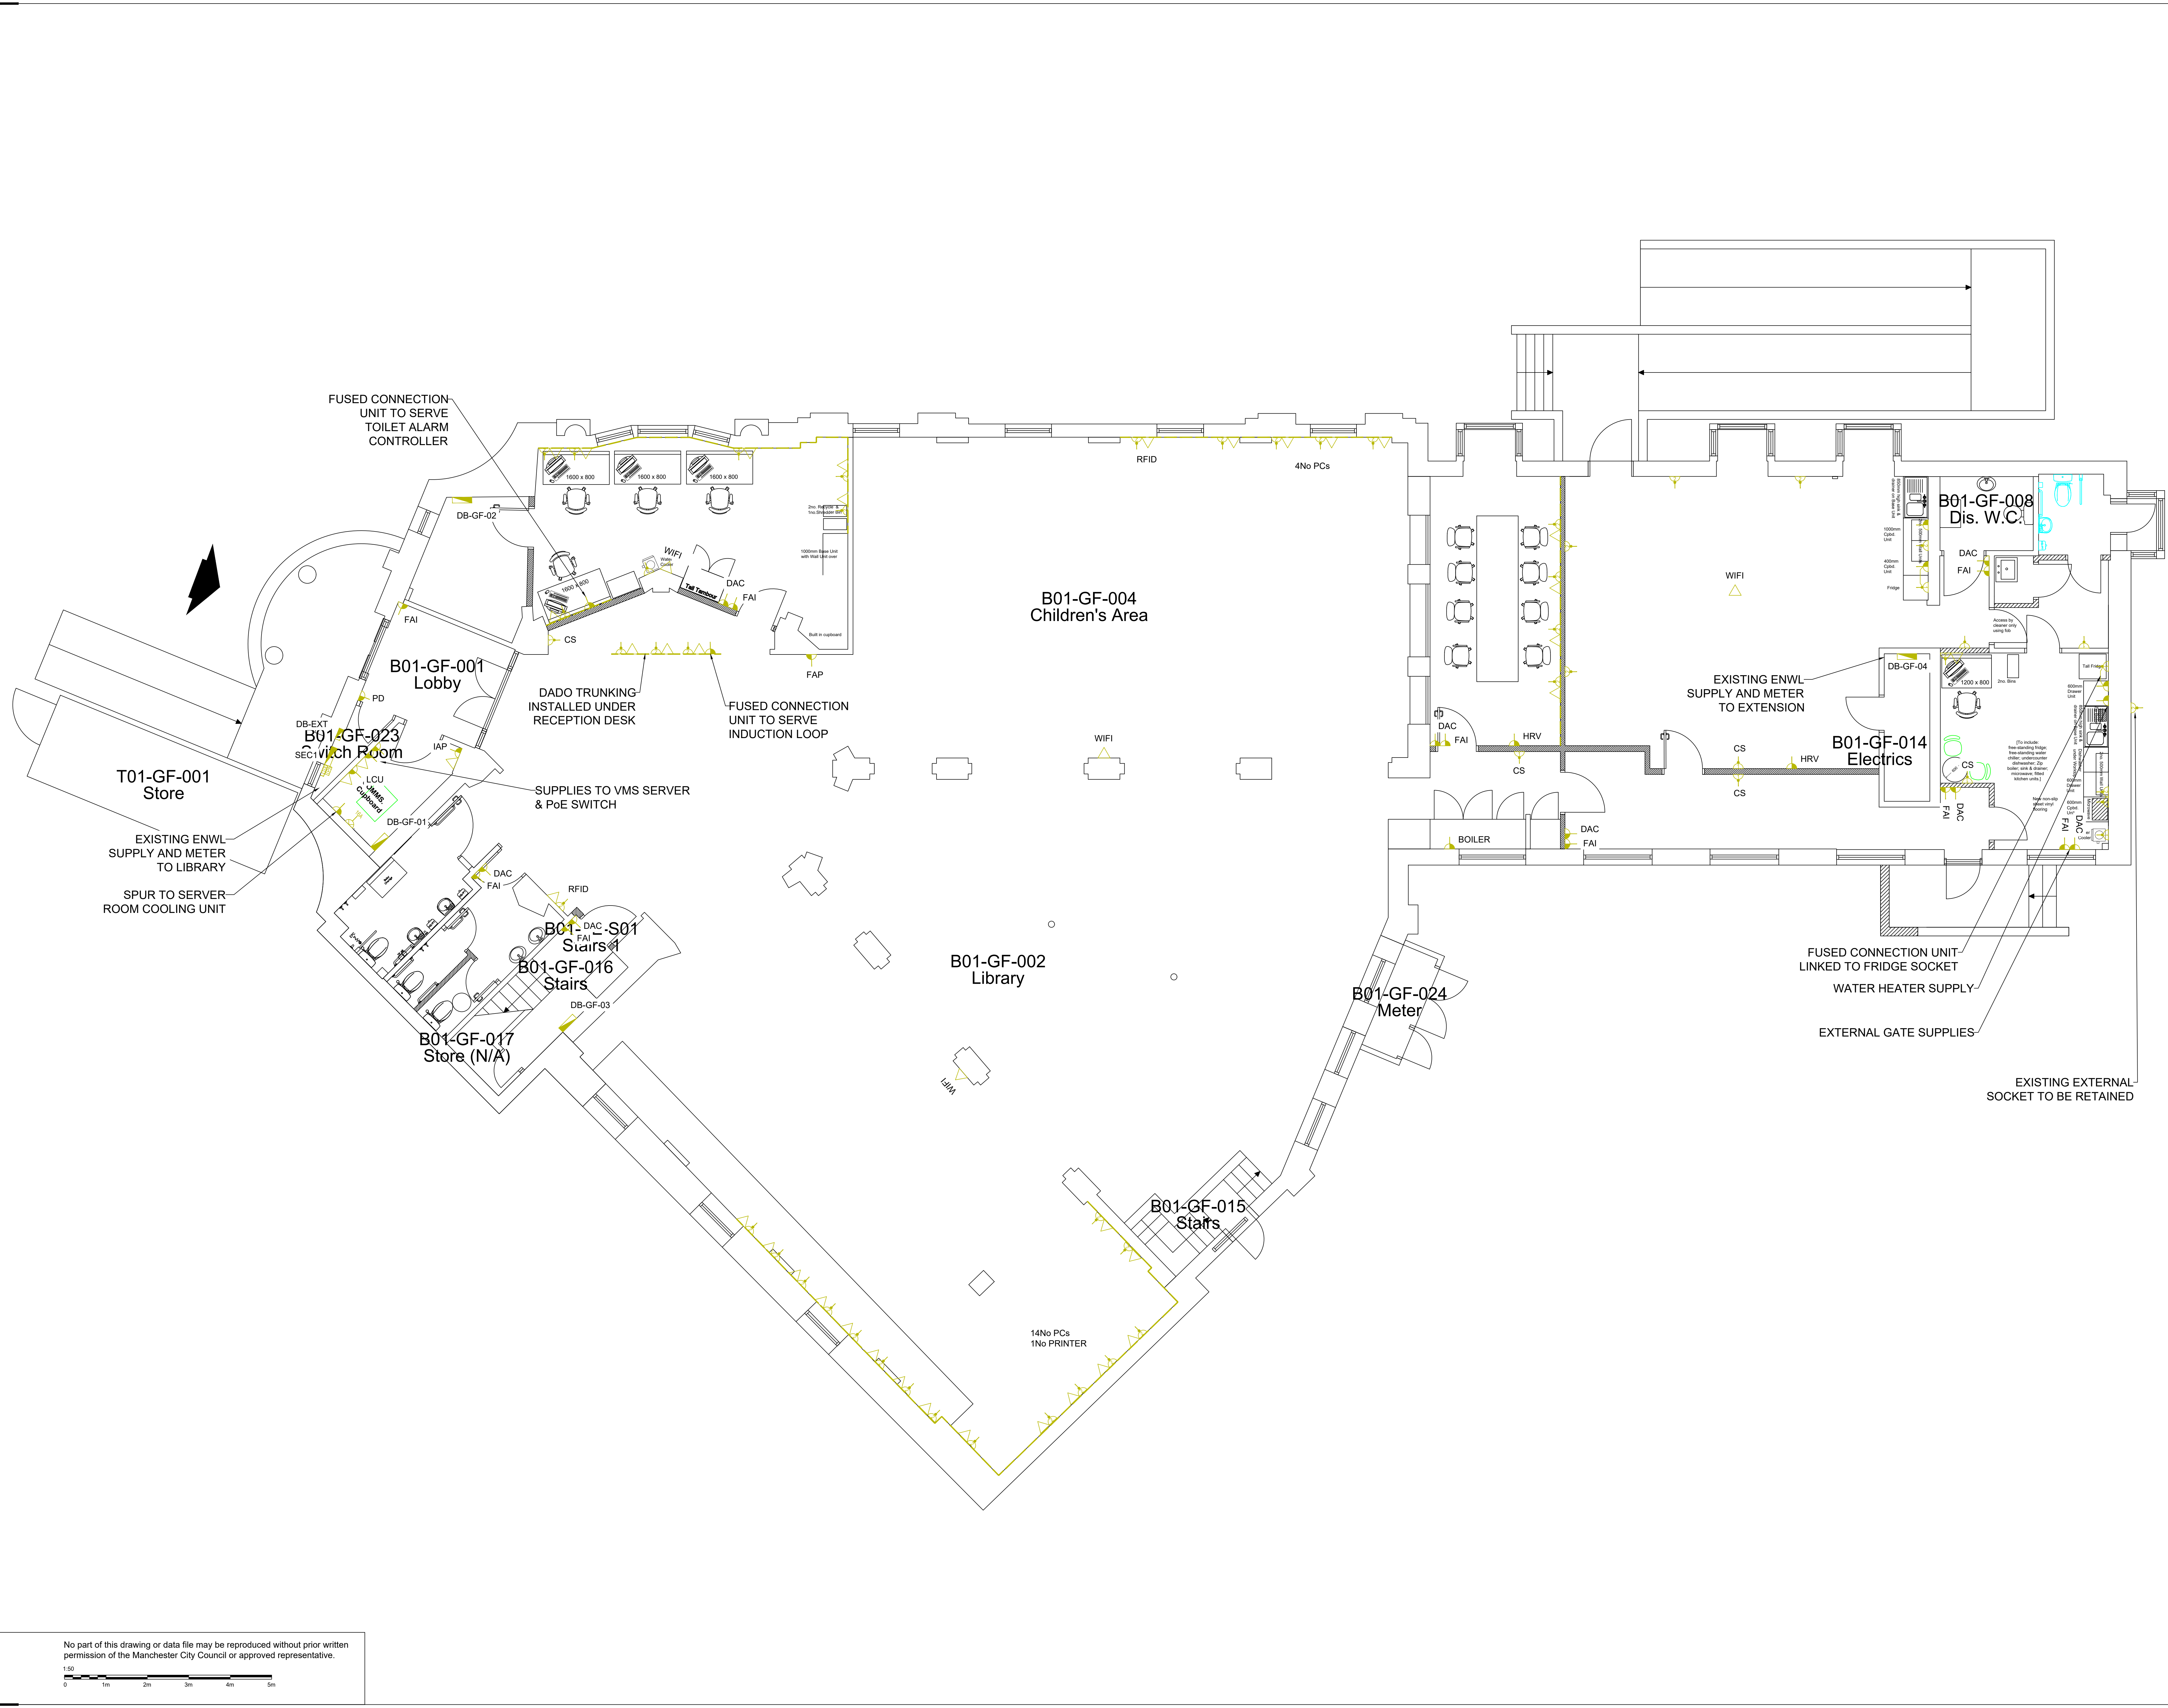

NOTES

- All dimensions are in millimetres unless otherwise stated
- This drawing is to be read with all other relevant documentation
- Do not scale from this drawing, all measurement data should be taken directly from the model

Small power and distribution

- Single switched socket outlet
- Twin switched socket outlet
- Fused connection unit c/w neon indicator
- 16A SPN socket for data rack
- Twin data outlet
- Isolator: Rating as indicated, SPN unless indicated
- Distribution board
- MCCB Panel board
- Dado trunking

DAC Door access controller
FAI Fire alarm interface
LCU Library control unit
CS Cleaner's socket
RFID RFID self checkout unit
FAP Fire alarm panel
IAP Intruder alarm panel
PD Powered doors
HRV Heat Recovery Ventilation

Small power notes

ALL WORKS SHALL BE CARRIED OUT IN ACCORDANCE WITH BS7671 LATEST EDITION AND MCC STANDARD AND PARTICULAR ELECTRICAL SPECIFICATIONS.

THIS DRAWING IS USED FOR GUIDANCE PURPOSES ONLY. IT IS A GENERIC DRAWING THAT HAS BEEN ADAPTED TO SUIT THE REQUIREMENTS OF THE INSTALLATION AND SHOWS THE CONCEPTS RATHER THAN THE EXACT WIRING REQUIRED.

THE EXACT LOCATIONS OF ALL PROPOSED ELECTRICAL INSTALLATIONS/EQUIPMENT SHALL BE FINALISED/AGREED ON SITE WITH THE MAIN CONTRACTOR / CONTRACT ADMINISTRATOR.

DISTANCES, CLEARANCES AND CABLE LENGTHS SHOULD BE CHECKED ON SITE AND NOT SCALED FROM THIS DRAWING.

ALL MAIN EQUIPOTENTIAL BONDING AND SUPPLEMENTARY BONDING SHALL BE CARRIED OUT IN ACCORDANCE WITH THE REQUIREMENTS OF THE CURRENT EDITION OF THE IET WIRING REGULATIONS (BS7671) AND ANY SPECIFIC REQUIREMENT OF THE LOCAL SUPPLY AUTHORITY. ALL ITEMS OF ELECTRICAL DISTRIBUTION EQUIPMENT WITHIN THE CIRCLES AND ALL METALLIC CONTAINMENT SHALL BE BONDED TO THE MAIN EARTHING CONNECTION POINT.

THE CONTRACTOR SHALL SUPPLY AND INSTALL SHOCK POWER UNITS TO THE DATA CABINETS AND SERVER AS DETAILED IN THE ELECTRICAL SPECIFICATION.

DADO SHALL BE MOUNTED AT DESK LEVEL WITH DROPS TO THE SUB-FLOOR CONTAINMENT. THE CONTRACTOR SHALL SUPPLY AND INSTALL NEW OUTLETS TO EACH COMPUTER LOCATION WITH 2ND SOCKETS FOR ADDITIONAL EQUIPMENT.

THE CONTRACTOR SHALL MAKE THEMSELVES FAMILIAR WITH THE EXISTING SERVICES AND INCLUDE FOR ANY ADDITIONAL POWER SUPPLIES FOR EXISTING EQUIPMENT THAT IS TO BE RETAINED.

THE CONTRACTOR SHALL INCLUDE FOR THE SUPPLY AND INSTALLATION OF A FIRE ALARM PANEL KEY SWITCHED FUSED CONNECTION UNIT INSTALLED ADJACENT TO THE MAIN PANEL.

THE EXISTING BOILERS, PUMPS, AND MECHANICAL CONTROL PANEL ARE TO BE RETAINED FOR USE IN THE NEW SCHEME. BOILER SUB-MAINS SHALL BE RETAINED SUBJECT TO CONDITION VERIFICATION.

THE CONTRACTOR SHALL INCLUDE FOR ADDITIONAL DATA OUTLETS REQUIRED FOR CCTV CAMERAS. REFER TO BIBLIOTHECA EQUIPMENT LAYOUT DRAWING FOR DETAILS.

D	MECHANICAL POWER ADDED	12.07.22	TB
C	IAP POWER RELOCATED, SPURS ADDED FOR ACCESS CONTROL	28.06.22	TB
B	RECEPTION AREA AMENDED, LIBRARY PC POWER AMENDED	20.06.22	TB
A	POWER AND DATA REVISED IN LINE WITH BIBLIOTHECA LAYOUT	14.06.22	TB
REV	DESCRIPTION	DATE	BY

MANCHESTER CITY COUNCIL

Capital Programmes Division

Manchester City Council
PO Box 532, Town Hall
Manchester
M60 2LA

DRAWING STATUS

INFORMATION

PROPERTY TITLE
Chorlton District Library
Manchester Road, Chorlton
M21 9PN

UPRN
U10023047970

DPE NO.
-

PROJECT TITLE
Open Libraries

DRAWING TITLE
Proposed Ground Floor Power Layout

JOB NO. LG44705.1	DATE 16.05.22	REV D
SCALE 1:50@A0	AUTHOR TB	CHECKED BY APPROVED BY

DRAWING NO.
MCC-B01-GF-DR-E-0020

No part of this drawing or data file may be reproduced without prior written permission of the Manchester City Council or approved representative.

1:50

0 1m 2m 3m 4m 5m