


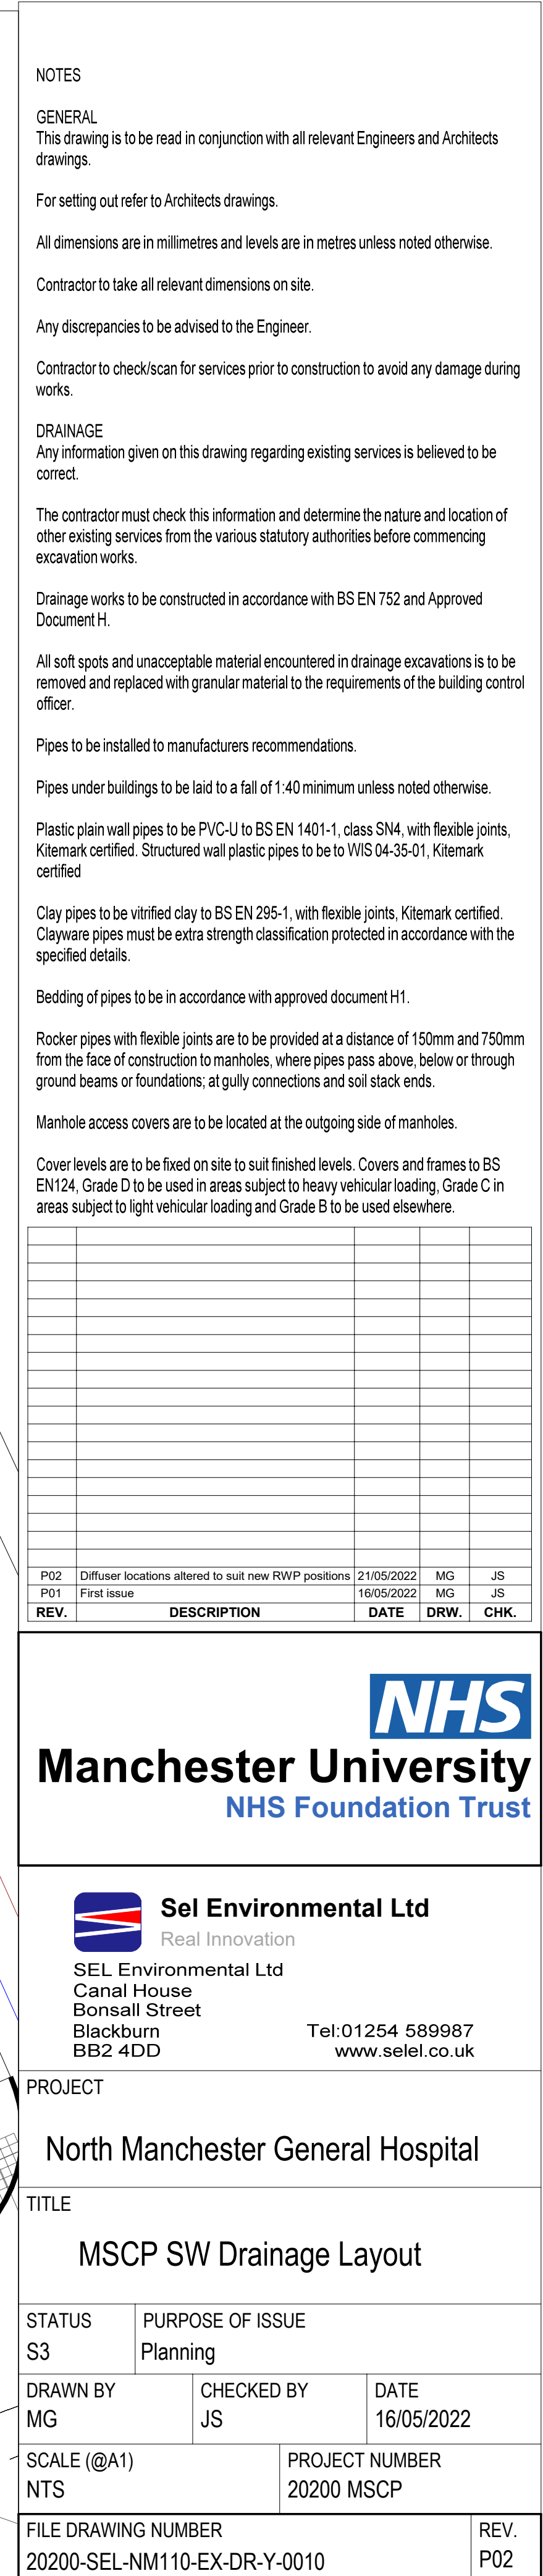

P02	Difuser locations altered to suit new RWP positions	21/05/2022	MG JS
P01	First issue	16/05/2022	MG JS
REV.	DESCRIPTION	DATE	DRW. CHK.

 Manchester University NHS Foundation Trust			
		Sel Environmental Ltd Real Innovation	
SEL Environmental Ltd Canal House Bonsall Street Blackburn BB2 4DD		Tel: 01254 589987 www.selenv.co.uk	
PROJECT			
North Manchester General Hospital			
TITLE			
MSCP SW Drainage Layout			
STATUS S3		PURPOSE OF ISSUE Planning	
DRAWN BY MG		CHECKED BY JS	DATE 16/05/2022
SCALE (@A1) NTS		PROJECT NUMBER 20200 MSCP	
FILE DRAWING NUMBER 2020-SEL-NM110-EX-DR-Y-0010			REV. P02