



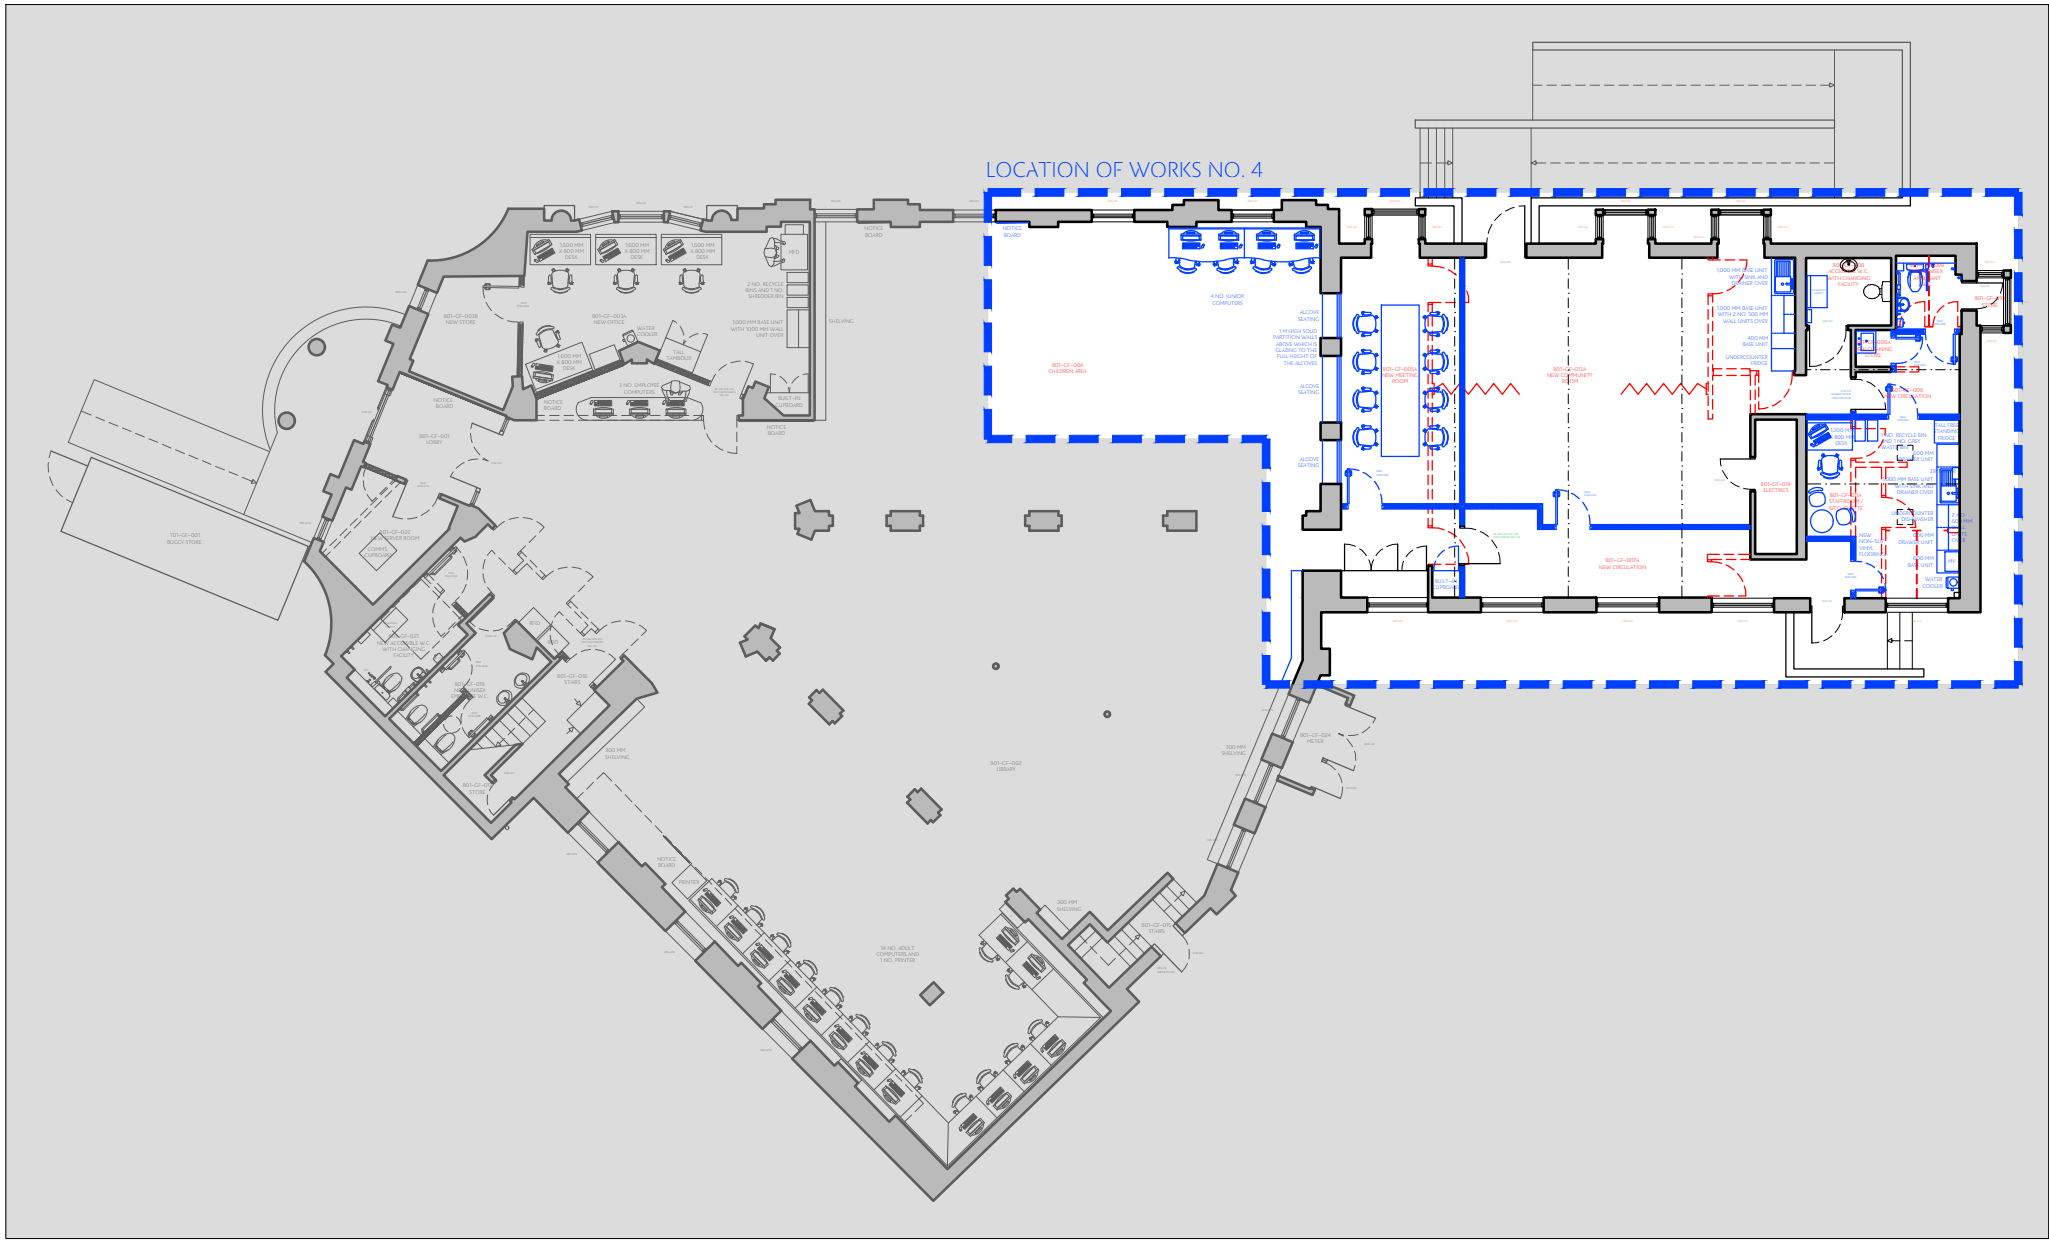

Key Plan
Scale 1:200




Photograph No. 04
DOR-007

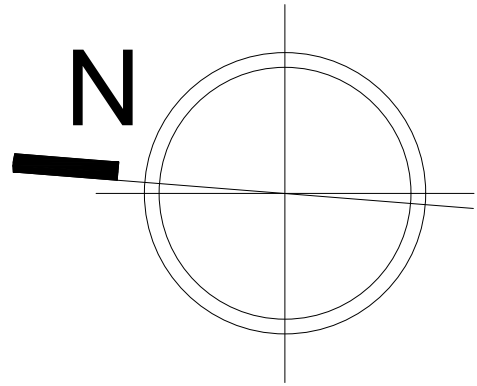

- DO NOT SCALE FROM THIS DRAWING - USE FIGURED DIMENSIONS ONLY.
- READ IN CONJUNCTION WITH ALL OTHER CONSULTANTS / SPECIALISTS DRAWINGS, REPORT ANY DISCREPANCIES BEFORE AFFECTED WORK COMMENCES.
- ALL SETTING OUT DIMENSIONS TO BE CHECKED ON SITE BY CONTRACTOR BEFORE WORK COMMENCES.
- THIS DRAWING REMAINS COPYRIGHT OF KEPczyk PEARCE SANDERSON LTD. COPY / DISTRIBUTE ONLY WITH CONSENT OF THE AUTHOR.

KEY	
	PUBLIC
	MEETING
	CLERICAL
	KITCHEN
	RESTROOM
	M&E
	STORAGE
	CIRCULATION
ROOM REFERENCES	
DOOR REFERENCES	
WINDOW REFERENCES	
R	RADIATOR
---	REMOVALS AS PROPOSED
---	NEW WORKS AS PROPOSED

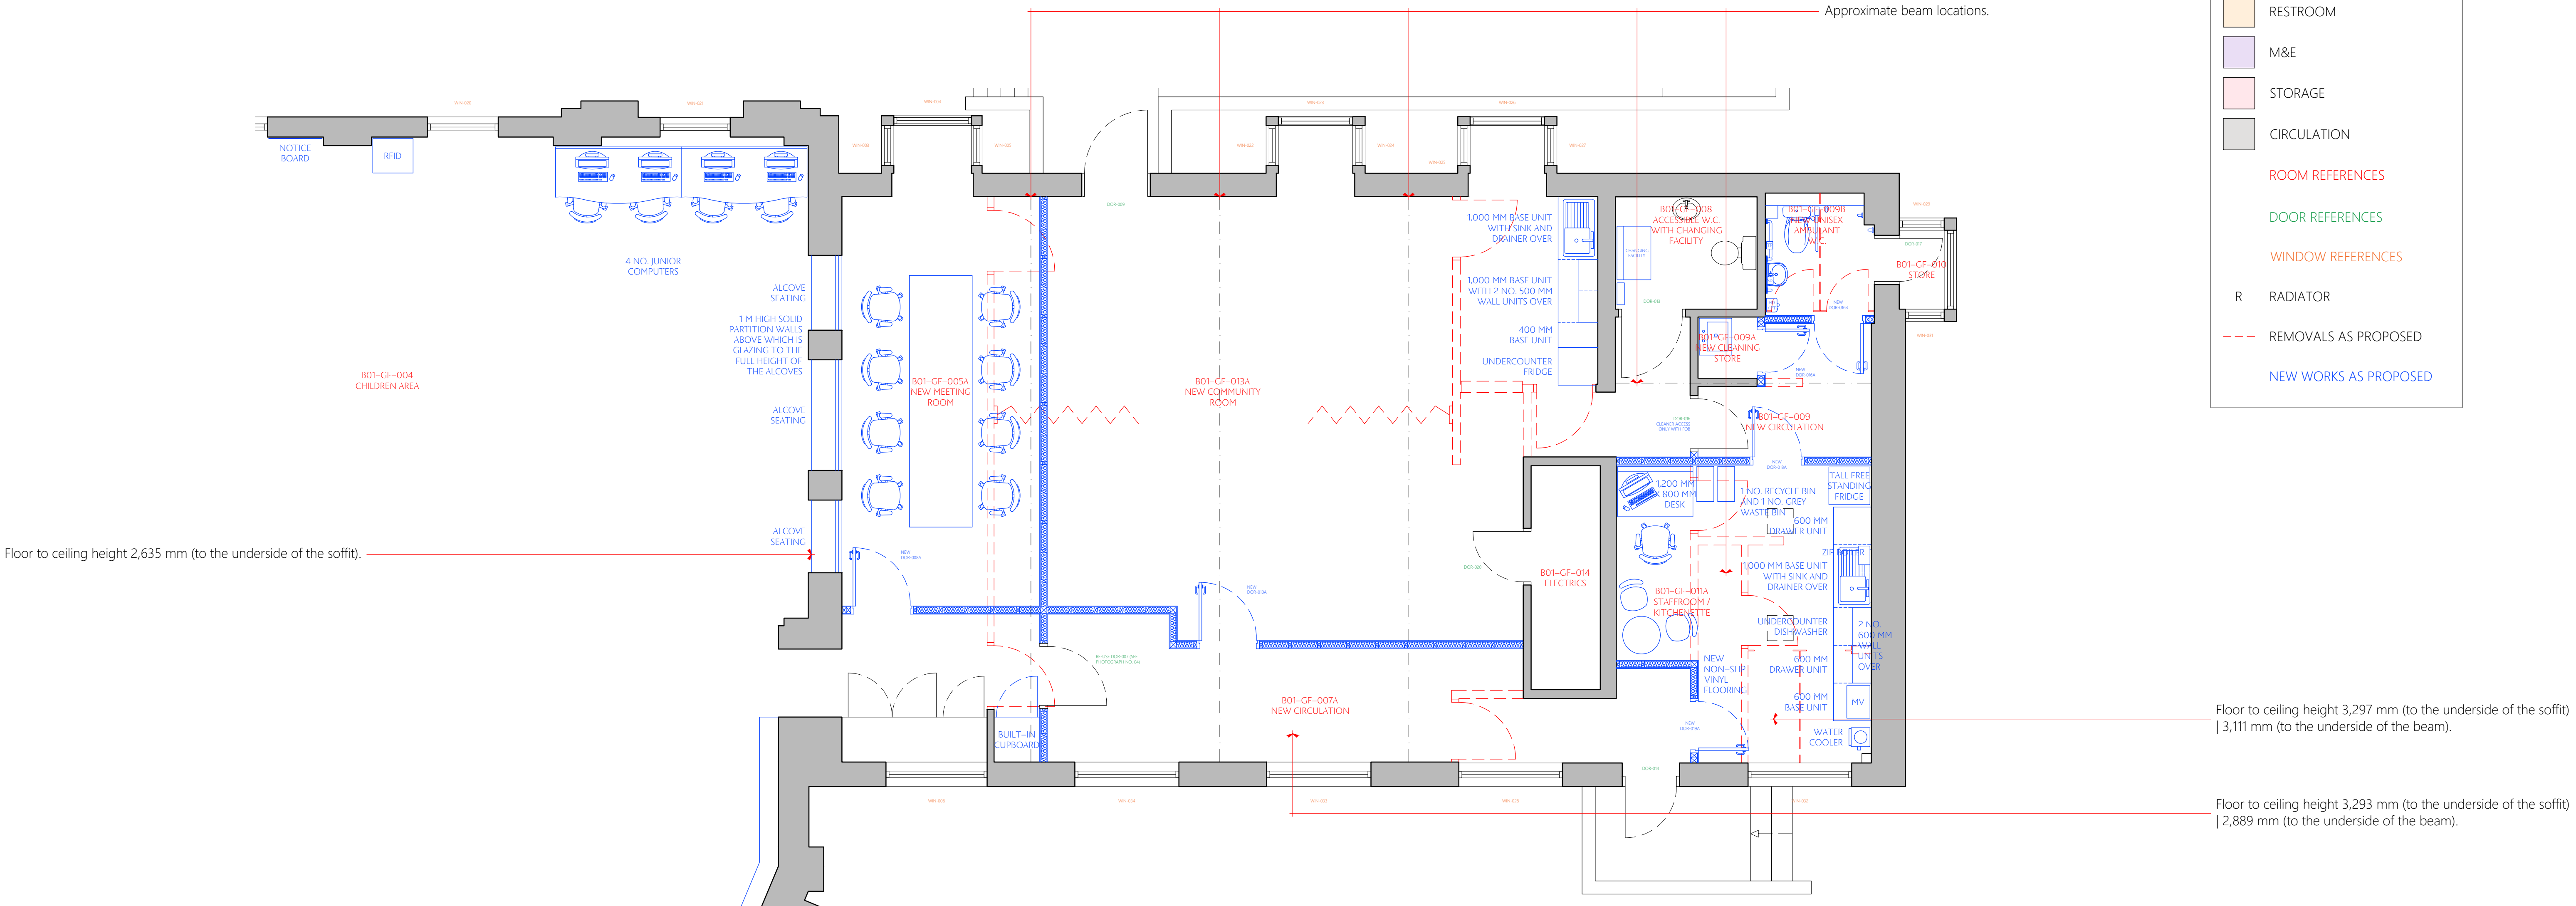

LOCATION OF WORKS NO. 4
Ground Floor Plan as Proposed
Scale 1:50

Rev. B Revised Layout of Adult Computers and B01-GF-022 (LMC | 2022 07 08)
Rev. A Amended North Symbol (LMC | 2022 07 05)

Contract Open Libraries Development		Location of Works No. 4 as Proposed			
Client Manchester City Council		Contract No. 2141		Drawn LMC	Drawing No. FR 006
Building / Structure Chorlton District Library, Chorlton-cum-Hardy		Date May 2022	Revision B	Scale	Various @ A1
KEPCZYK PEARCE SANDERSON ARCHITECTS, SURVEYORS & HISTORIC BUILDING CONSULTANTS		Address: 75 Wilmslow Road, Handforth, Cheshire SK9 3EN Tel: 01625 400103			