


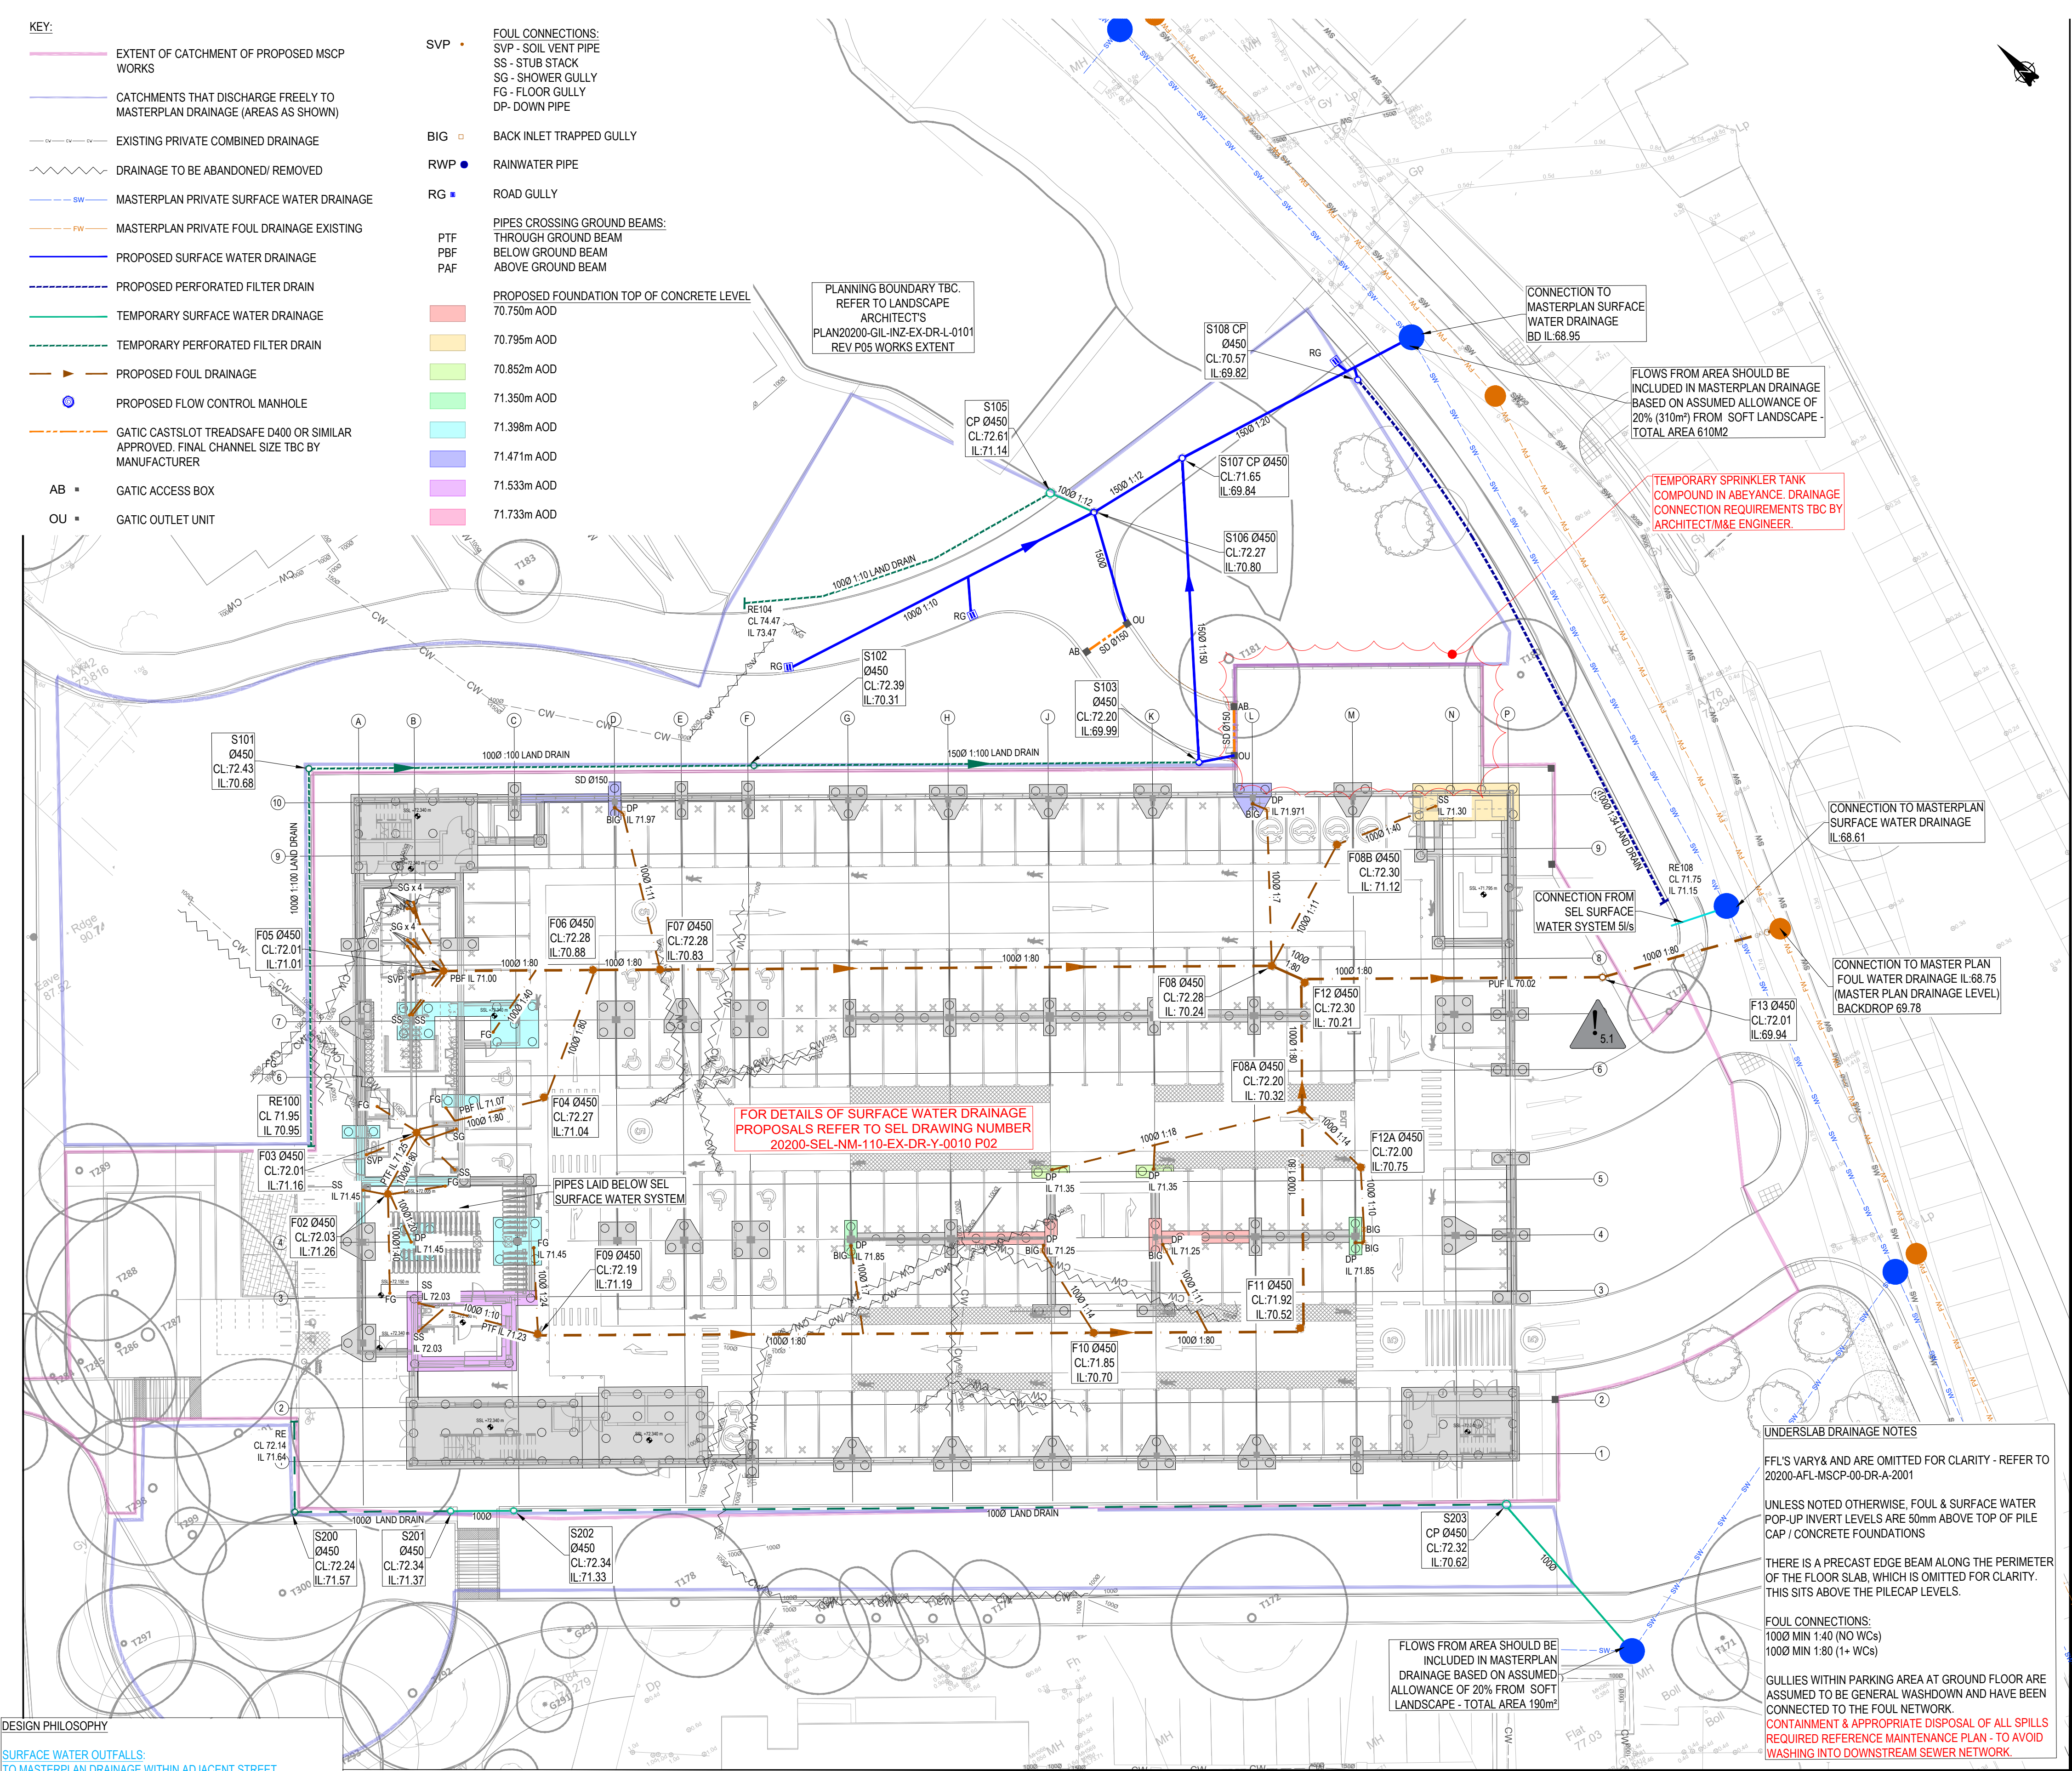

- GENERAL NOTES:
- THIS DRAWING IS TO BE READ IN CONJUNCTION WITH ALL RELEVANT ARCHITECTS AND ENGINEERS DRAWINGS AND SPECIFICATIONS.
 - ALL PRIVATE DRAINAGE WORKS TO BE IN ACCORDANCE WITH CURTINS DRAINAGE SPECIFICATION, 'CIVIL ENGINEERING SPECIFICATION FOR THE WATER INDUSTRY 7th EDITION', BS EN 752 2017 'DRAIN AND SEWER SYSTEMS OUTSIDE BUILDINGS' AND THE BUILDING REGULATIONS APPROVED 'DOCUMENT H'.
 - DO NOT SCALE THIS DRAWING. ANY AMBIGUITIES, OMISSIONS AND ERRORS ON DRAWINGS SHALL BE BROUGHT TO THE ENGINEERS ATTENTION IMMEDIATELY. ALL DIMENSIONS MUST BE CHECKED / VERIFIED ON SITE.
 - DESIGN BASED ON TOPOGRAPHICAL SURVEY AND CCTV SURVEY INFORMATION AVAILABLE AT THE TIME OF THE DESIGN.
 - ALL DIMENSIONS ARE IN METRES AND LEVELS IN METRES ABOVE ORDNANCE DATUM UNLESS OTHERWISE NOTED.
 - COVER LEVELS, GULLY POSITIONS, AND BUILDINGS LOCATION ARE APPROXIMATE AND SHALL BE CONFIRMED BY ARCHITECT/ LANDSCAPE ARCHITECT. CONTRACTOR TO ALLOW FOR ADJUSTMENT TO SUIT AGREED POSITIONS AND FINISHED LEVELS, AND CONFIRM ALL COVER LEVELS ON SITE.
 - ALL INTERNAL DRAINAGE CONNECTIONS ARE PROVIDED TO THE PENETRATION POSITIONS SHOWN ON ARCHITECT AND M&E DRAWINGS. REFER TO DIMENSIONED LOCATIONS AND DIAMETERS ON ARCHITECT'S GROUND FLOOR SETTING-OUT PLANS.
 - ALL UNDERGROUND FOUL DRAINAGE SHOULD BE SUITABLY VENTED AT OR NEAR TO THE HEAD OF RUNS.
 - ALL ACCESS FITTINGS, STACKS, RWP'S AND GULLIES TO BE RODDABLE. ALL TO HAVE LOW LEVEL RODDING ACCESS PLATES UNLESS AN ALTERNATIVE MEANS OF ACCESS IS AGREED. ACCESS POINT TO BE ABOVE ANY GROUND FLOOR CONNECTED APPLIANCE SPILL LEVEL.
 - LARGE ACCESS FITTING REQUIRED ABOVE GROUND WHERE GREATER THAN 12M UP TO 22M TO A JUNCTION. SMALL ACCESS FITTING REQUIRED UP TO 12M TO A JUNCTION.
 - ALL GULLY AND CHANNEL DRAIN OUTLETS AND TERMINATION POINTS TO BE TRAPPED AND RODDABLE. INTERNAL GULLIES AND CHANNEL DRAINS TO BE SPECIFIED BY OTHERS.
 - WHERE NO WCs ARE CONNECTED UPSTREAM, UNDERSLAB FW DRAINAGE TO BE LAID AT 1:40 MIN. AFTER THE CONNECTION OF AT LEAST 1NO WC, A MIN. FALL OF 1:80 APPLIES.
 - ALL CONNECTIONS FROM POP-UPS TO BE LAID AT A CONSTANT GRADIENT TO JUNCTION/ INSPECTION CHAMBER/ MANHOLE UNLESS NOTED OTHERWISE. ANY ISSUES RELATING TO CLASHES WITH FOUNDATIONS ARE TO BE FORWARDED TO THE ENGINEER, ALLOWING SUFFICIENT TIME FOR AN ALTERNATIVE SOLUTION TO BE PROPOSED.
 - INVERT LEVELS AT MANHOLES/ INSPECTION CHAMBERS TO BE USED TO SET OUT PIPEWORK. PIPE GRADIENTS ARE SHOWN INDICATIVELY ONLY.
 - ALL PIPE DIAMETERS GIVEN ARE NOMINAL INTERNAL PIPE DIAMETERS.
 - ALL SEWERS, UNLESS AGREED OTHERWISE STATED, SHALL BE: 100mm to 300mm DIA TO BE VITRIFIED CLAY.
 - AS AN ALTERNATIVE THE CONTRACTOR MAY USE AN APPROVED UNPLASTICISED POLYVINYL CHLORIDE (PVCU) WITH APPROVAL FROM THE ENGINEER.
 - SEWER PIPES TO BE LAID IN MAXIMUM 3 METRE LENGTHS UNLESS THERE IS A SPECIFIC OPERATIONAL NEED TO LAY LONGER LENGTHS.
 - THE FIRST PIPE OUT OF MANHOLES TO BE AS SHORT AS
- DRAWING BASED ON:
- SURVEY
- TOPOGRAPHICAL & UTILITY SURVEY (PROVISIONAL) DATED 09.09.20
- SITE INVESTIGATION
- ARCHITECT'S PLANS
- 2020-AFL-MSCP-ZZ-DR-A-2001 C01 GROUND FLOOR GA
 - 2020-AFL-MSCP-00-DR-A-2301 C01 LEVEL 0 FLOOR SLAB PLAN
- DRAINAGE CONNECTIONS
- FOUL DISCHARGE UNITS AND POPUP ME TAKEN FROM 2020-IES-NM110-00-DR-M-6201 C01
- LANDSCAPE ARCHITECT'S PLANS
- 2020-GIL-INZ-EX-DR-L-0101 P05 PROPOSED LANDSCAPE PLAN NORTH
- LEVELS BASED ON
- 2020-CUR-MSCP-EX-M3-D-7509 C03 MSCP LEVELS
- FOUNDATION PLANS
- 2020-CUR-MSCP-FN-DR-S-1701 C01 FOUNDATION GA
 - 2020-CUR-MSCP-00-DR-S-1702 C01 GROUND FLOOR GA
- REQUIRED INFORMATION
- PLANNING BOUNDARY TO BE CONFIRMED
 - PROPOSED SERVICES PLAN
 - CONFIRMATION OF FOUL DISCHARGE UNITS
 - SPRINKLER TANK AREA CONSTRUCTION TO BE CONFIRMED
- REQUIRED INFORMATION
- PLANNING BOUNDARY TO BE CONFIRMED
 - PROPOSED SERVICES PLAN
 - CONFIRMATION OF FOUL DISCHARGE UNITS
 - SPRINKLER TANK AREA CONSTRUCTION TO BE CONFIRMED

PRACTICABLE SO AS TO PROVIDE A FLEXIBLE JOINT AS CLOSE AS POSSIBLE TO THE OUTSIDE FACE OF THE CONCRETE SURROUND AND CONNECTED TO A LENGTH OF ROCKER PIPE.

- ALL NEW CONNECTIONS INTO EXISTING MANHOLES (OR INTO EXISTING SEWERS) TO BE 'SOFFITS LEVEL' UNLESS OTHERWISE NOTED.
- ALL PRIVATE DRAINAGE PIPES WITH A COVER OF LESS THAN 600mm IN NON-TRAFFICKED AREAS AND LESS THAN 1200mm IN TRAFFICKED AREAS TO BE BEDDED AND SURROUNDED IN CONCRETE (CLASS Z). COMPRESSIBLE MATERIAL SHALL BE PROVIDED AT EVERY PIPE JOINT. WHERE COVER EXCEEDS THIS DEPTH, PIPES ARE TYPICALLY BEDDED AND SURROUNDED IN CLASS S. REFER TO PIPE EMBODIMENT DETAILS DRAWING FOR SPECIFIC TYPES.
- WHERE PIPES ARE LESS THAN 300mm BELOW THE UNDERSIDE OF THE GROUND FLOOR SLAB, CONCRETE ENCASEMENT IS REQUIRED (CLASS Z). COMPRESSIBLE JOINTS ARE TO BE PROVIDED AT EVERY PIPE JOINT WITHIN THE CONCRETE.
- WHERE PIPES ARE MORE THAN 300mm BELOW THE UNDERSIDE OF THE SLAB, CLASS S BEDDING IS ACCEPTABLE.
- SULPHATE RESISTANT CEMENT (C20-DC2) AND PRECAST CONCRETE PRODUCTS MUST BE USED OR A LABORATORY REPORT PROVIDED TO PROVE THAT SUCH PRECAUTIONS ARE NOT REQUIRED.
- WHERE FOUL SEWERS RUN ABOVE SURFACE SEWERS, CONCRETE PROTECTION MAY BE REQUIRED AT CROSSOVERS TO PREVENT ANY POTENTIAL CONTAMINATION.
- ALL CONNECTIONS PASSING THROUGH BASES OR EDGE BEAMS TO BE IN SEALED SLEEVES. ALTERNATIVELY CONNECTIONS MAY BE CAST-IN WITH FLEXIBLE JOINTS NOT GREATER THAN 150MM FROM FACE OF CONCRETE.
- THE CHAMBER SIZE OF MANHOLES WITH MORE THAN ONE CONNECTION MAY NEED TO BE INCREASED TO ACCOMMODATE THE CONNECTIONS AND BENDS.
- ALL MANHOLE COVERS IN BLOCK/SLAB AND EXTERNAL PAVING AREAS TO HAVE RECESSED COVERS OF THE APPROPRIATE GRADE TO ACCEPT ARCHITECT'S PAVING PROPOSAL.
- ALL INTERNAL COVERS TO HAVE MECHANICALLY JOINTED CORNERS AND DOUBLE SEALED WITH RECESSED TRAY TO ALLOW FOR FINISHES.
- UNLESS NOTED OTHERWISE IN THE MANHOLE SCHEDULE, ALL MANHOLE, GULLY AND CHANNEL COVERS (IRONWORK) SHOULD BE THE FOLLOWING SPECIFICATION:
 - B125 LOAD CLASS IN PEDESTRIAN AREAS
 - D400 LOAD CLASS IN VEHICULAR AREAS.
- ALL PROPRIETARY PRODUCTS TO BE INSTALLED IN STRICT ACCORDANCE WITH THE MANUFACTURERS REQUIREMENTS, INSTRUCTIONS AND RECOMMENDATIONS.
- FOUL GULLIES WITHIN GROUND FLOOR PARKING AREAS ARE FOR GENERAL WASHDOWN ONLY. THE PROCEDURE FOR CONTAMINANT & DISPOSAL OF LARGER SPILLS TO BE CONFIRMED AND INCLUDED IN MAINTENANCE PLAN

REV.	DESCRIPTION	DATE	DRW.	CHK.
C01	SURFACE WATER REMOVED AND FOUL UPDATED	25.05.22	EBR	MMW
P11	UPDATED IN LINE WITH MCC COMMENTS	16.02.22	ATL	MMW
P10	STAGE 4 UPDATE	31.01.22	ATL	MMW
P09	STAGE 4 UPDATE	24.01.22	ATL	MMW
P08	STAGE 4 UPDATE	17.12.21	ATL	CG
P07	DRAFT STAGE 4 ISSUE	10.08.21	MMW	MMW
P06	DRAFT STAGE 4 ISSUE	21.07.21	MMW	MMW
P05	DRAFT STAGE 4 ISSUE	28.06.21	MMW	DS

PROJECT

NMGH MSCP

TITLE

Proposed Drainage Layout

STATUS

S4

PURPOSE OF ISSUE

FOR CONSTRUCTION

DRAWN BY

MMW

CHECKED BY

DS

DATE

28/06/2021

SCALE (@A1)

1:200

PROJECT NUMBER

075805

FILE DRAWING NUMBER

20200-CUR-NM110-EX-DR-D-7511

REV.

C01