 





Reproduced by permission of Ordnance Survey on behalf of the Controller of Her Majesty's Stationery Office All rights reserved. © Crown Copyright licence no. 100022432

SITE AREA PLAN

Scale 1:50,000




SITE PHOTOGRAPH

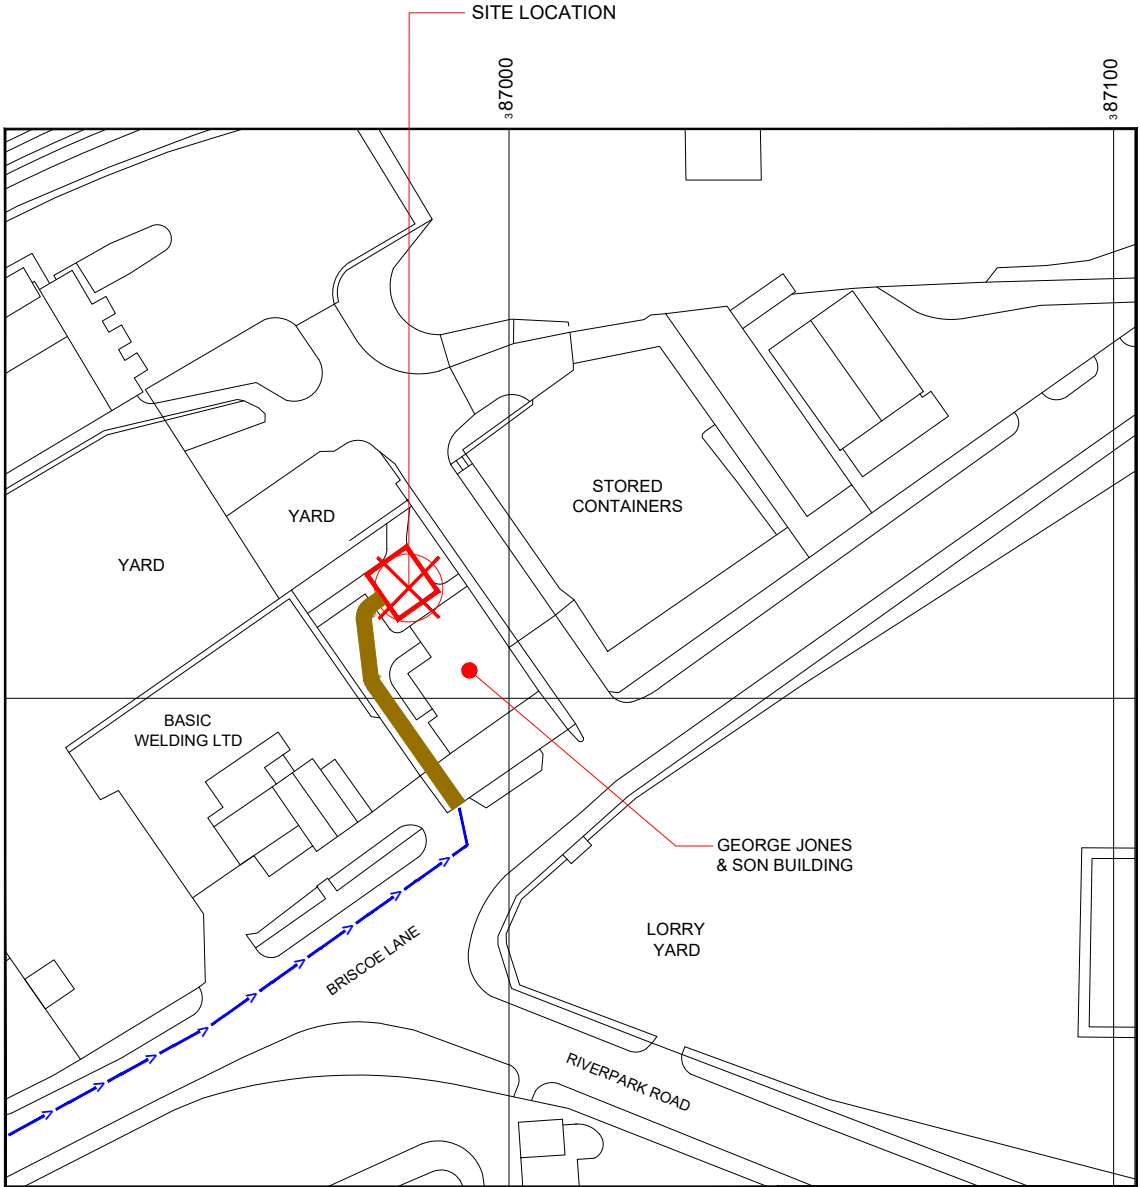

Reproduced by permission of Ordnance Survey on behalf of the Controller of Her Majesty's Stationery Office All rights reserved. © Crown Copyright licence no. 100022432

SITE LOCATION PLAN

 Scale 1:1250



GOOGLE MAPS QR CODE

GOOGLE MAP - Hyperlink to map of the site

GOOGLE STREETVIEW - Hyperlink to streetview of the site

NOTES:

1. ALL DIMENSIONS IN MM UNLESS OTHERWISE NOTED.

From the M60 junction 22 take the A62 towards Manchester. After 5.4km turn left onto the A6010. Take the third left onto Briscoe Lane. The entrance to George Jones & Son is approx 345m on the left hand side. The site is located to the rear of the building.

Site Provider's Property Boundary:



Access Route To Site:



Access Route:



Master:	MBNL / EE / H3G:	Project:	Purpose of Issue:	Issue:
M002	MBNL	NTQ	Planning	B
Date:	07/06/2022	Revision / Upgrade Description:		
Drawn:	D.PARTON	Re-Design with Valmont Slimline Monopole		
Checked:	A.FANNING			
Approved:	P.CONVERY			
Master:	MBNL / EE / H3G:	Project:	Purpose of Issue:	Issue:
M001	MBNL	NTQ	Planning	A
Date:	21/01/22	Revision / Upgrade Description:		
Drawn:	J. BOOTE	First Issue		
Checked:	J. STOCKDALE			
Approved:	J. STOCKDALE			



Hutchison 3G UK Limited
Star House, 20 Grenfell Road
Maidenhead, SL6 1EH
Tel: 01628 765 900
Fax: 01628 765 901



Hatfield Business Park
Hatfield
Hertfordshire
AL10 9BW
Tel: 01707 315000
Fax: 01707 319001



Mobile Broadband Network Limited
Sixth Floor, Thames Tower, Station Road, Reading, RG1 1LX

Design Consultant & Principal Contractor:



WHP Telecoms
Unit 1 Maple Park,
Low Fields Avenue, Leeds
LS12 6HH

Tel: 01133023550
e-mail: info@whptelecoms.com

Site Name: GEORGE JONES & SON

Site ID: 1660400

Address: GEORGE JONES & SON,
232 BRISCOE LANE,
MANCHESTER,
GREATER MANCHESTER,
M40 2XG


Title: 002 SITE LOCATION PLAN

Project: NTQ

Purpose of Issue: GENERAL ARRANGEMENT

EE Cell ID:	MBNL Cell ID:	3UK Cell ID:
79987	MAN506	M0839

Master Drawing No:	Issue:
1660400_MAN506_79987_M0839_M002	B

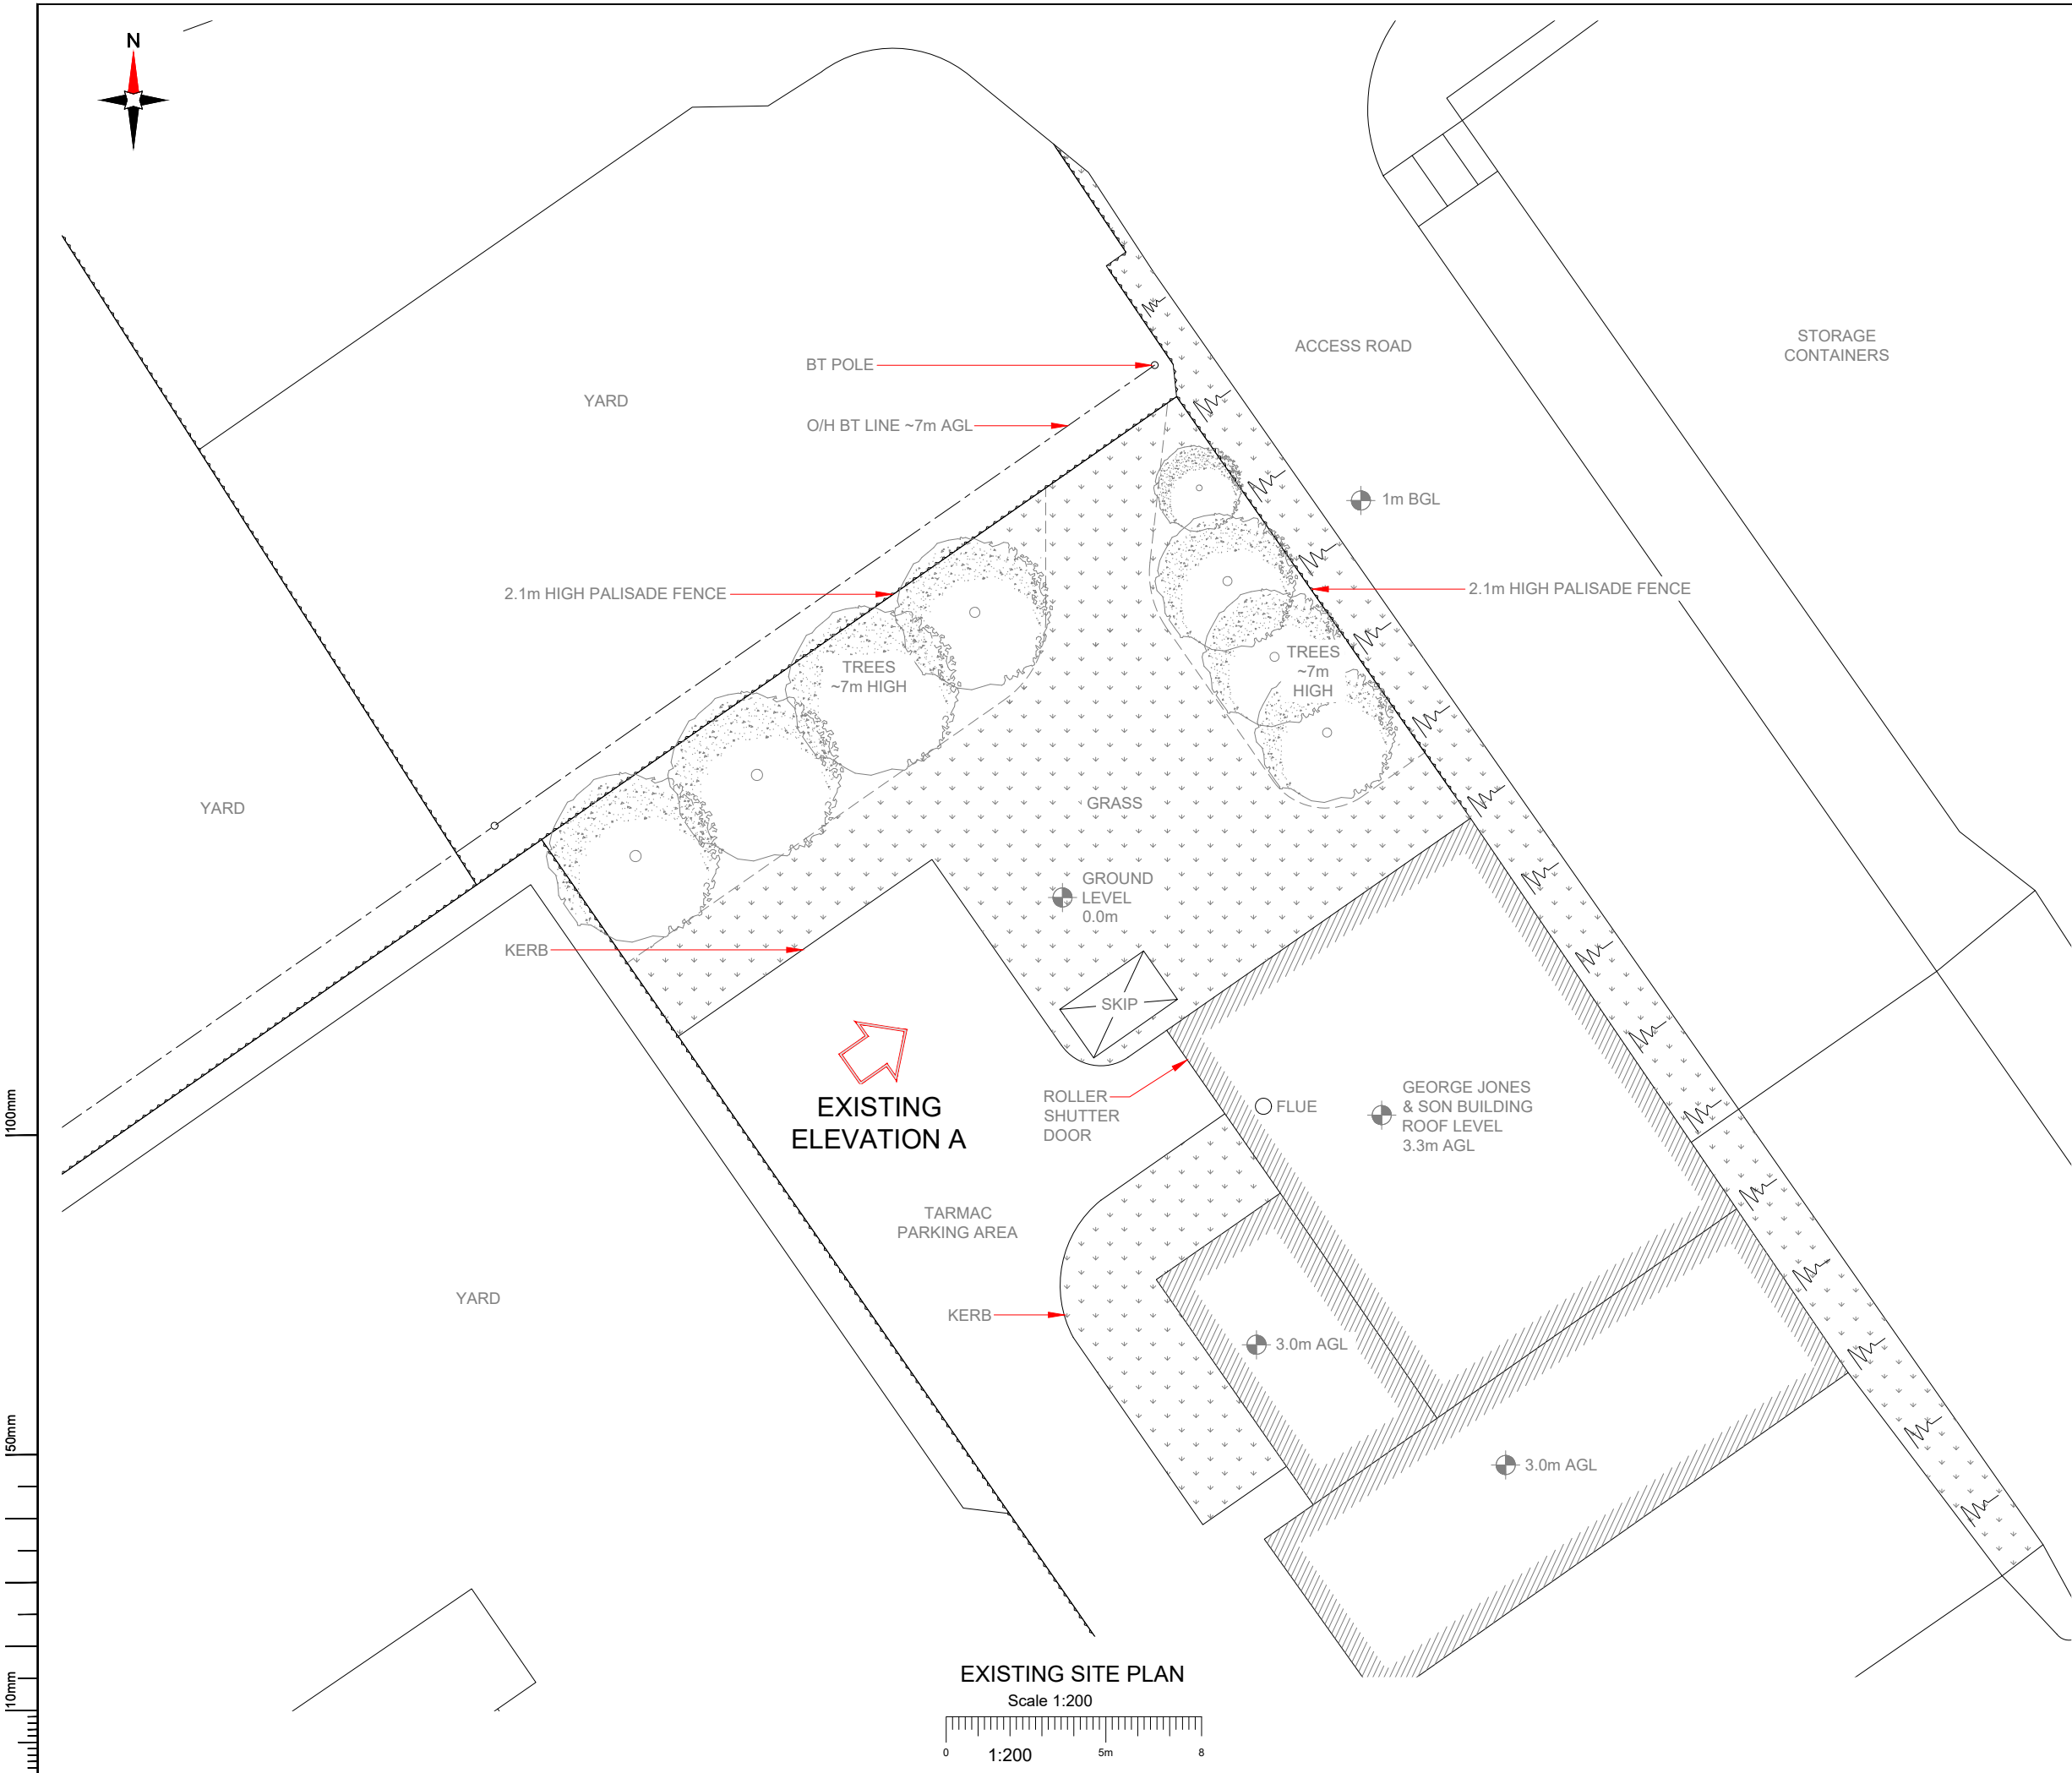

- NOTES:
- ALL DIMENSIONS IN MM UNLESS OTHERWISE NOTED.

Master:	MBNL / EE / H3G:	Project:	Purpose of Issue:	Issue:
M002	MBNL	NTQ	Planning	B
Date:	07/06/2022	Revision / Upgrade Description:		
Drawn:	D.PARTON	Re-Design with Valmont Slimline Monopole		
Checked:	A.FANNING			
Approved:	P.CONVERY			
Master:	MBNL / EE / H3G:	Project:	Purpose of Issue:	Issue:
M001	MBNL	NTQ	Planning	A
Date:	21/01/22	Revision / Upgrade Description:		
Drawn:	J. BOOTE	First Issue		
Checked:	J. STOCKDALE			
Approved:	J. STOCKDALE			



Hutchison 3G UK Limited
Star House, 20 Grenfell Road
Maidenhead, SL6 1EH
Tel: 01628 765 000
Fax: 01628 765 001



H3G Base Station Information line:
0845 6043000
Available 8am-8pm Monday to Friday



Hatfield Business Park
Hatfield
Hertfordshire
AL10 9BW
Tel: 01707 315000
Fax: 01707 319001



Mobile Broadband Network Limited
Sixth Floor, Thames Tower, Station Road, Reading, RG1 1LX

Design Consultant & Principal Contractor:



WHP Telecoms
Unit 1 Maple Park,
Low Fields Avenue, Leeds
LS12 6HH
Tel: 01133023550
e-mail: info@whptelecoms.com

Site Name: **GEORGE JONES & SON**

Site ID: **1660400**

Address: **GEORGE JONES & SON,
232 BRISCOE LANE,
MANCHESTER,
GREATER MANCHESTER,
M40 2XG**

Title: **100 EXISTING SITE PLAN**

Project: **NTQ**

Purpose of Issue: **GENERAL ARRANGEMENT**


EE Cell ID: 79987	MBNL Cell ID: MAN506	3UK Cell ID: M0839
-----------------------------	--------------------------------	------------------------------

Master Drawing No: 1660400_MAN506_79987_M0839_M002	Issue: B
--	--------------------

100mm

50mm

10mm

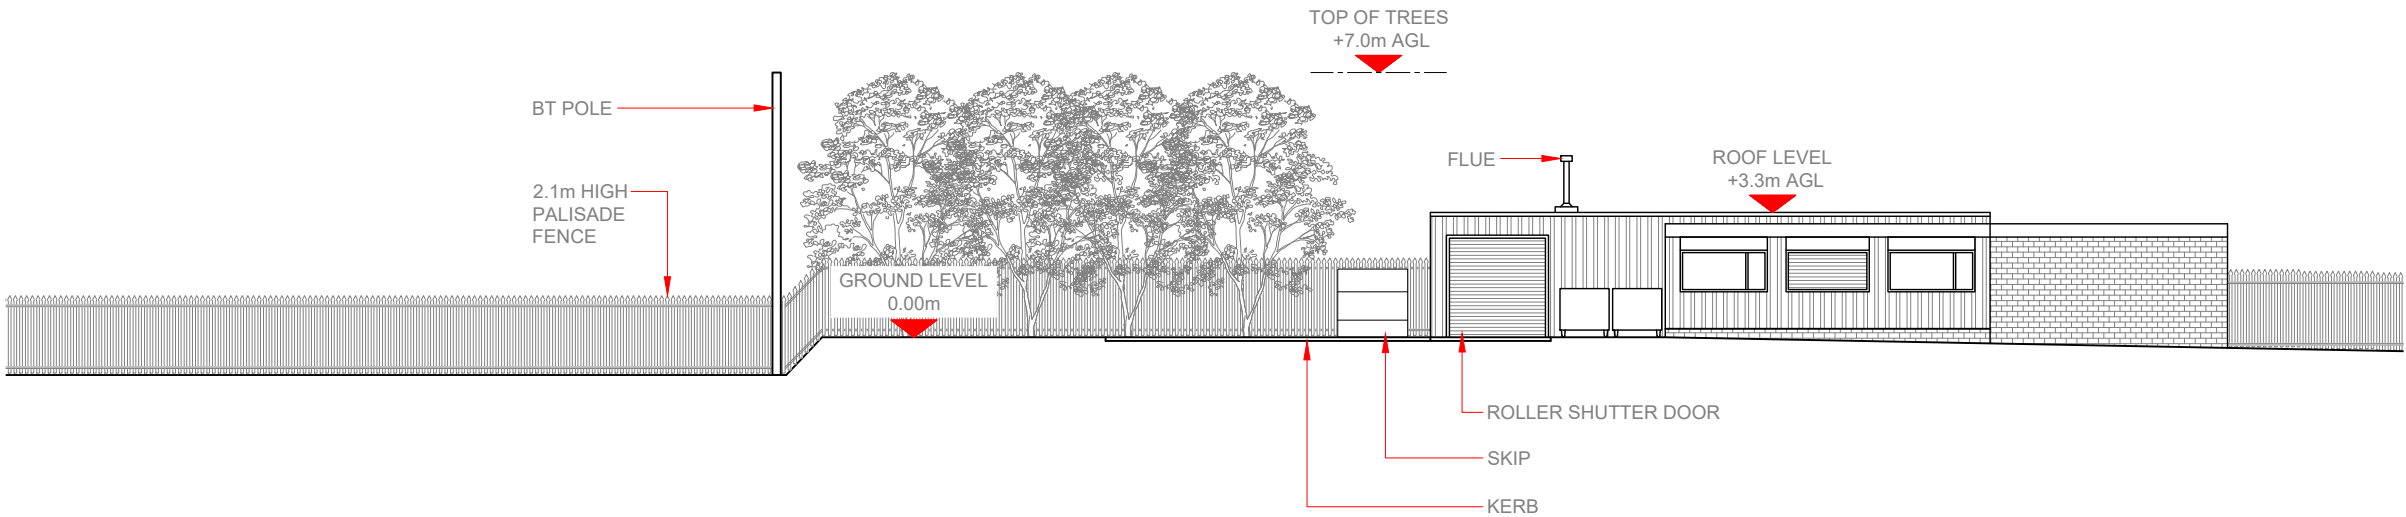

EXISTING ELEVATION A

Scale 1:200



NOTES:

1. ALL DIMENSIONS IN MM UNLESS OTHERWISE NOTED.

Master:	MBNL / EE / H3G:	Project:	Purpose of Issue:	Issue:
M002	MBNL	NTQ	Planning	B
Date:	07/06/2022	Revision / Upgrade Description:		
Drawn:	D.PARTON	Re-Design with Valmont Slimline Monopole		
Checked:	A.FANNING			
Approved:	P.CONVERY			
Master:	MBNL / EE / H3G:	Project:	Purpose of Issue:	Issue:
M001	MBNL	NTQ	Planning	A
Date:	21/01/22	Revision / Upgrade Description:		
Drawn:	J. BOOTE	First Issue		
Checked:	J. STOCKDALE			
Approved:	J. STOCKDALE			



Hutchison 3G UK Limited
Star House, 20 Grenfell Road
Maidenhead, SL6 1EH
Tel: 01628 765 000
Fax: 01628 765 001

H3G Base Station Information line:
0845 6043000
Available 8am-8pm Monday to Friday



Hatfield Business Park
Hatfield
Hertfordshire
AL10 9BW

Tel: 01707 315000
Fax: 01707 319001



Mobile Broadband Network Limited
Sixth Floor, Thames Tower, Station Road, Reading, RG1 1LX

Design Consultant & Principal Contractor:



WHP Telecoms
Unit 1 Maple Park,
Low Fields Avenue, Leeds
LS12 6HH

Tel: 01133023550
e-mail: info@whptelecoms.com

Site Name:
GEORGE JONES & SON

Site ID:
1660400

Address:
**GEORGE JONES & SON,
232 BRISCOE LANE,
MANCHESTER,
GREATER MANCHESTER,
M40 2XG**


Title:
150 EXISTING ELEVATION A

Project:
NTQ

Purpose of Issue:
GENERAL ARRANGEMENT

EE Cell ID:	MBNL Cell ID:	3UK Cell ID:
79987	MAN506	M0839

Master Drawing No:	Issue:
1660400_MAN506_79987_M0839_M002	B

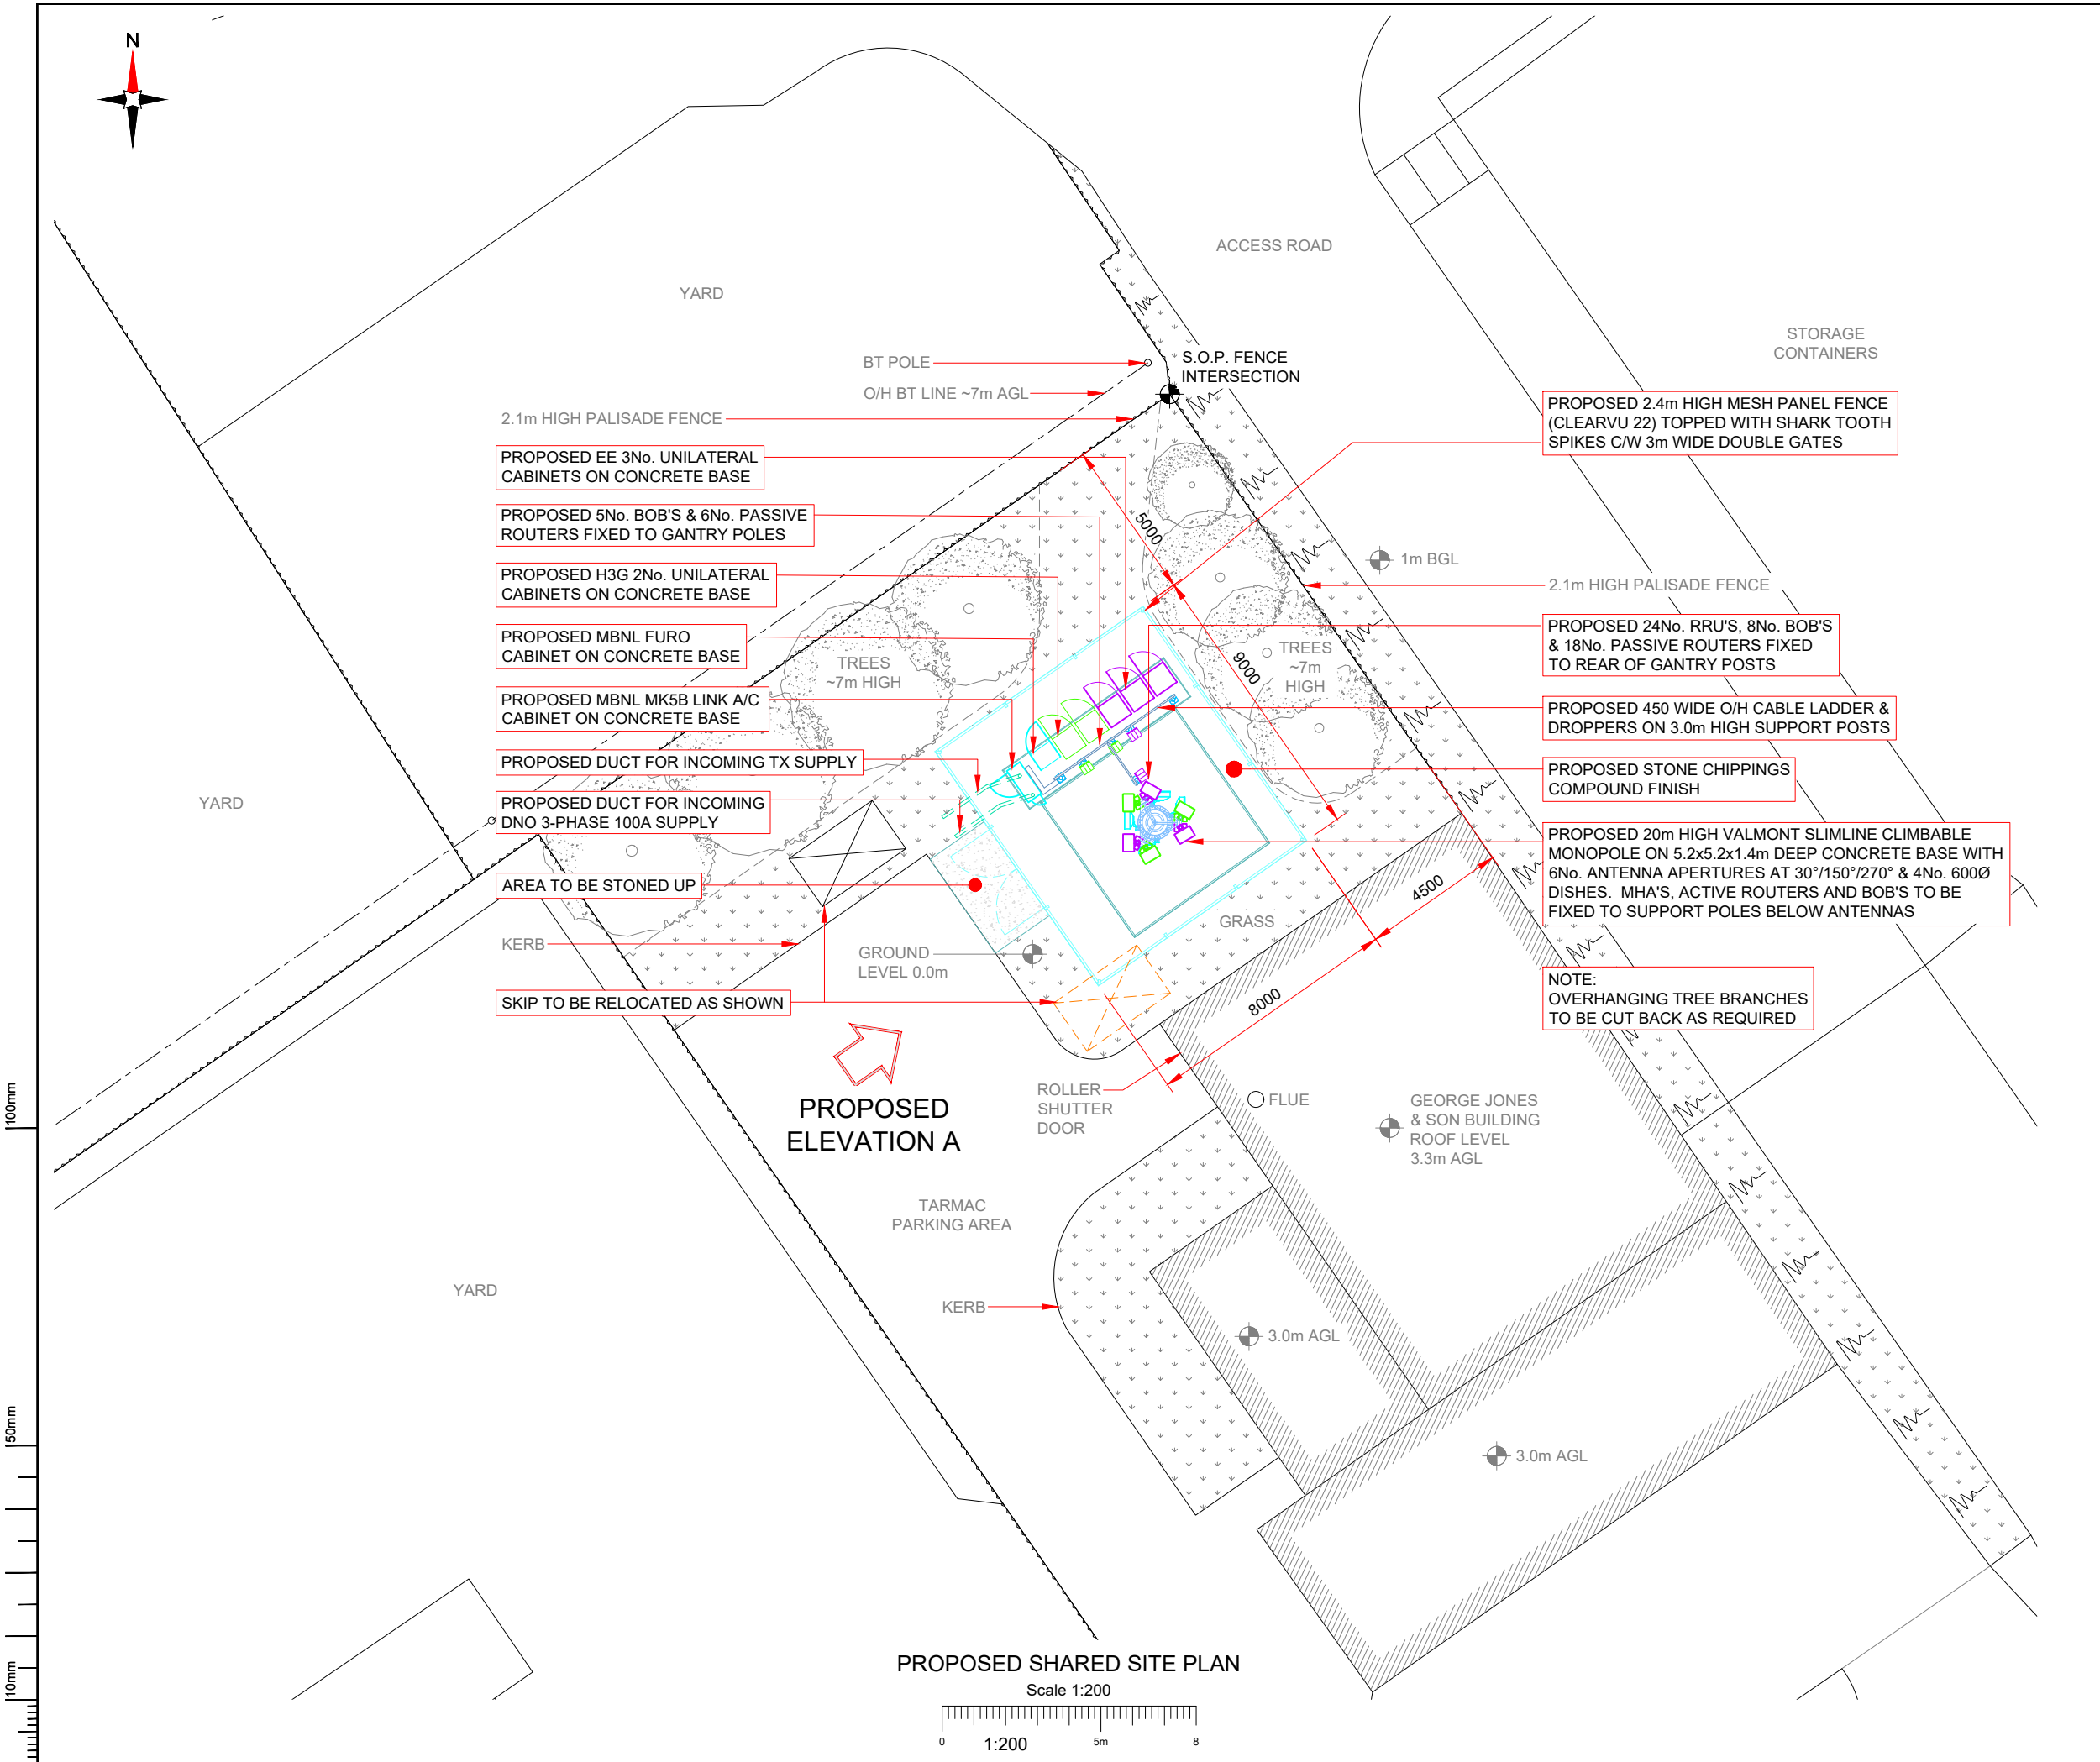

NOTES:

1. ALL DIMENSIONS IN MM UNLESS OTHERWISE NOTED.

SHARED CONFIGURATION SITE

RF CONFIG

H3b

Master:	MBNL / EE / H3G:	Project:	Purpose of Issue:	Issue:
M002	MBNL	NTQ	Planning	B
Date:	07/06/2022	Revision / Upgrade Description:		
Drawn:	D.PARTON	Re-Design with Valmont Slimline Monopole		
Checked:	A.FANNING			
Approved:	P.CONVERY			
Master:	MBNL / EE / H3G:	Project:	Purpose of Issue:	Issue:
M001	MBNL	NTQ	Planning	A
Date:	21/01/22	Revision / Upgrade Description:		
Drawn:	J. BOOTE	First Issue		
Checked:	J. STOCKDALE			
Approved:	J. STOCKDALE			



Hutchison 3G UK Limited
Star House, 20 Grenfell Road
Maidenhead, SL6 1EH
Tel: 01628 765 000
Fax: 01628 765 001



Hatfield Business Park
Hatfield
Hertfordshire
AL10 9BW
Tel: 01707 315000
Fax: 01707 319001



Mobile Broadband Network Limited
Sixth Floor, Thames Tower, Station Road, Reading, RG1 1LX

Design Consultant & Principal Contractor:



WHP Telecoms
Unit 1 Maple Park,
Low Fields Avenue, Leeds
LS12 6HH

Tel: 01133023550
e-mail: info@whptelecoms.com

Site Name:
GEORGE JONES & SON

Site ID:
1660400

Address:
GEORGE JONES & SON,
232 BRISCOE LANE,
MANCHESTER,
GREATER MANCHESTER,
M40 2XG

Title:
200 PROPOSED SHARED SITE PLAN

Project:
NTQ

Purpose of Issue:
GENERAL ARRANGEMENT


EE Cell ID: 79987	MBNL Cell ID: MAN506	3UK Cell ID: M0839
----------------------	-------------------------	-----------------------

Master Drawing No: 1660400_MAN506_79987_M0839_M002	Issue: B
---	-------------

100mm

50mm

10mm

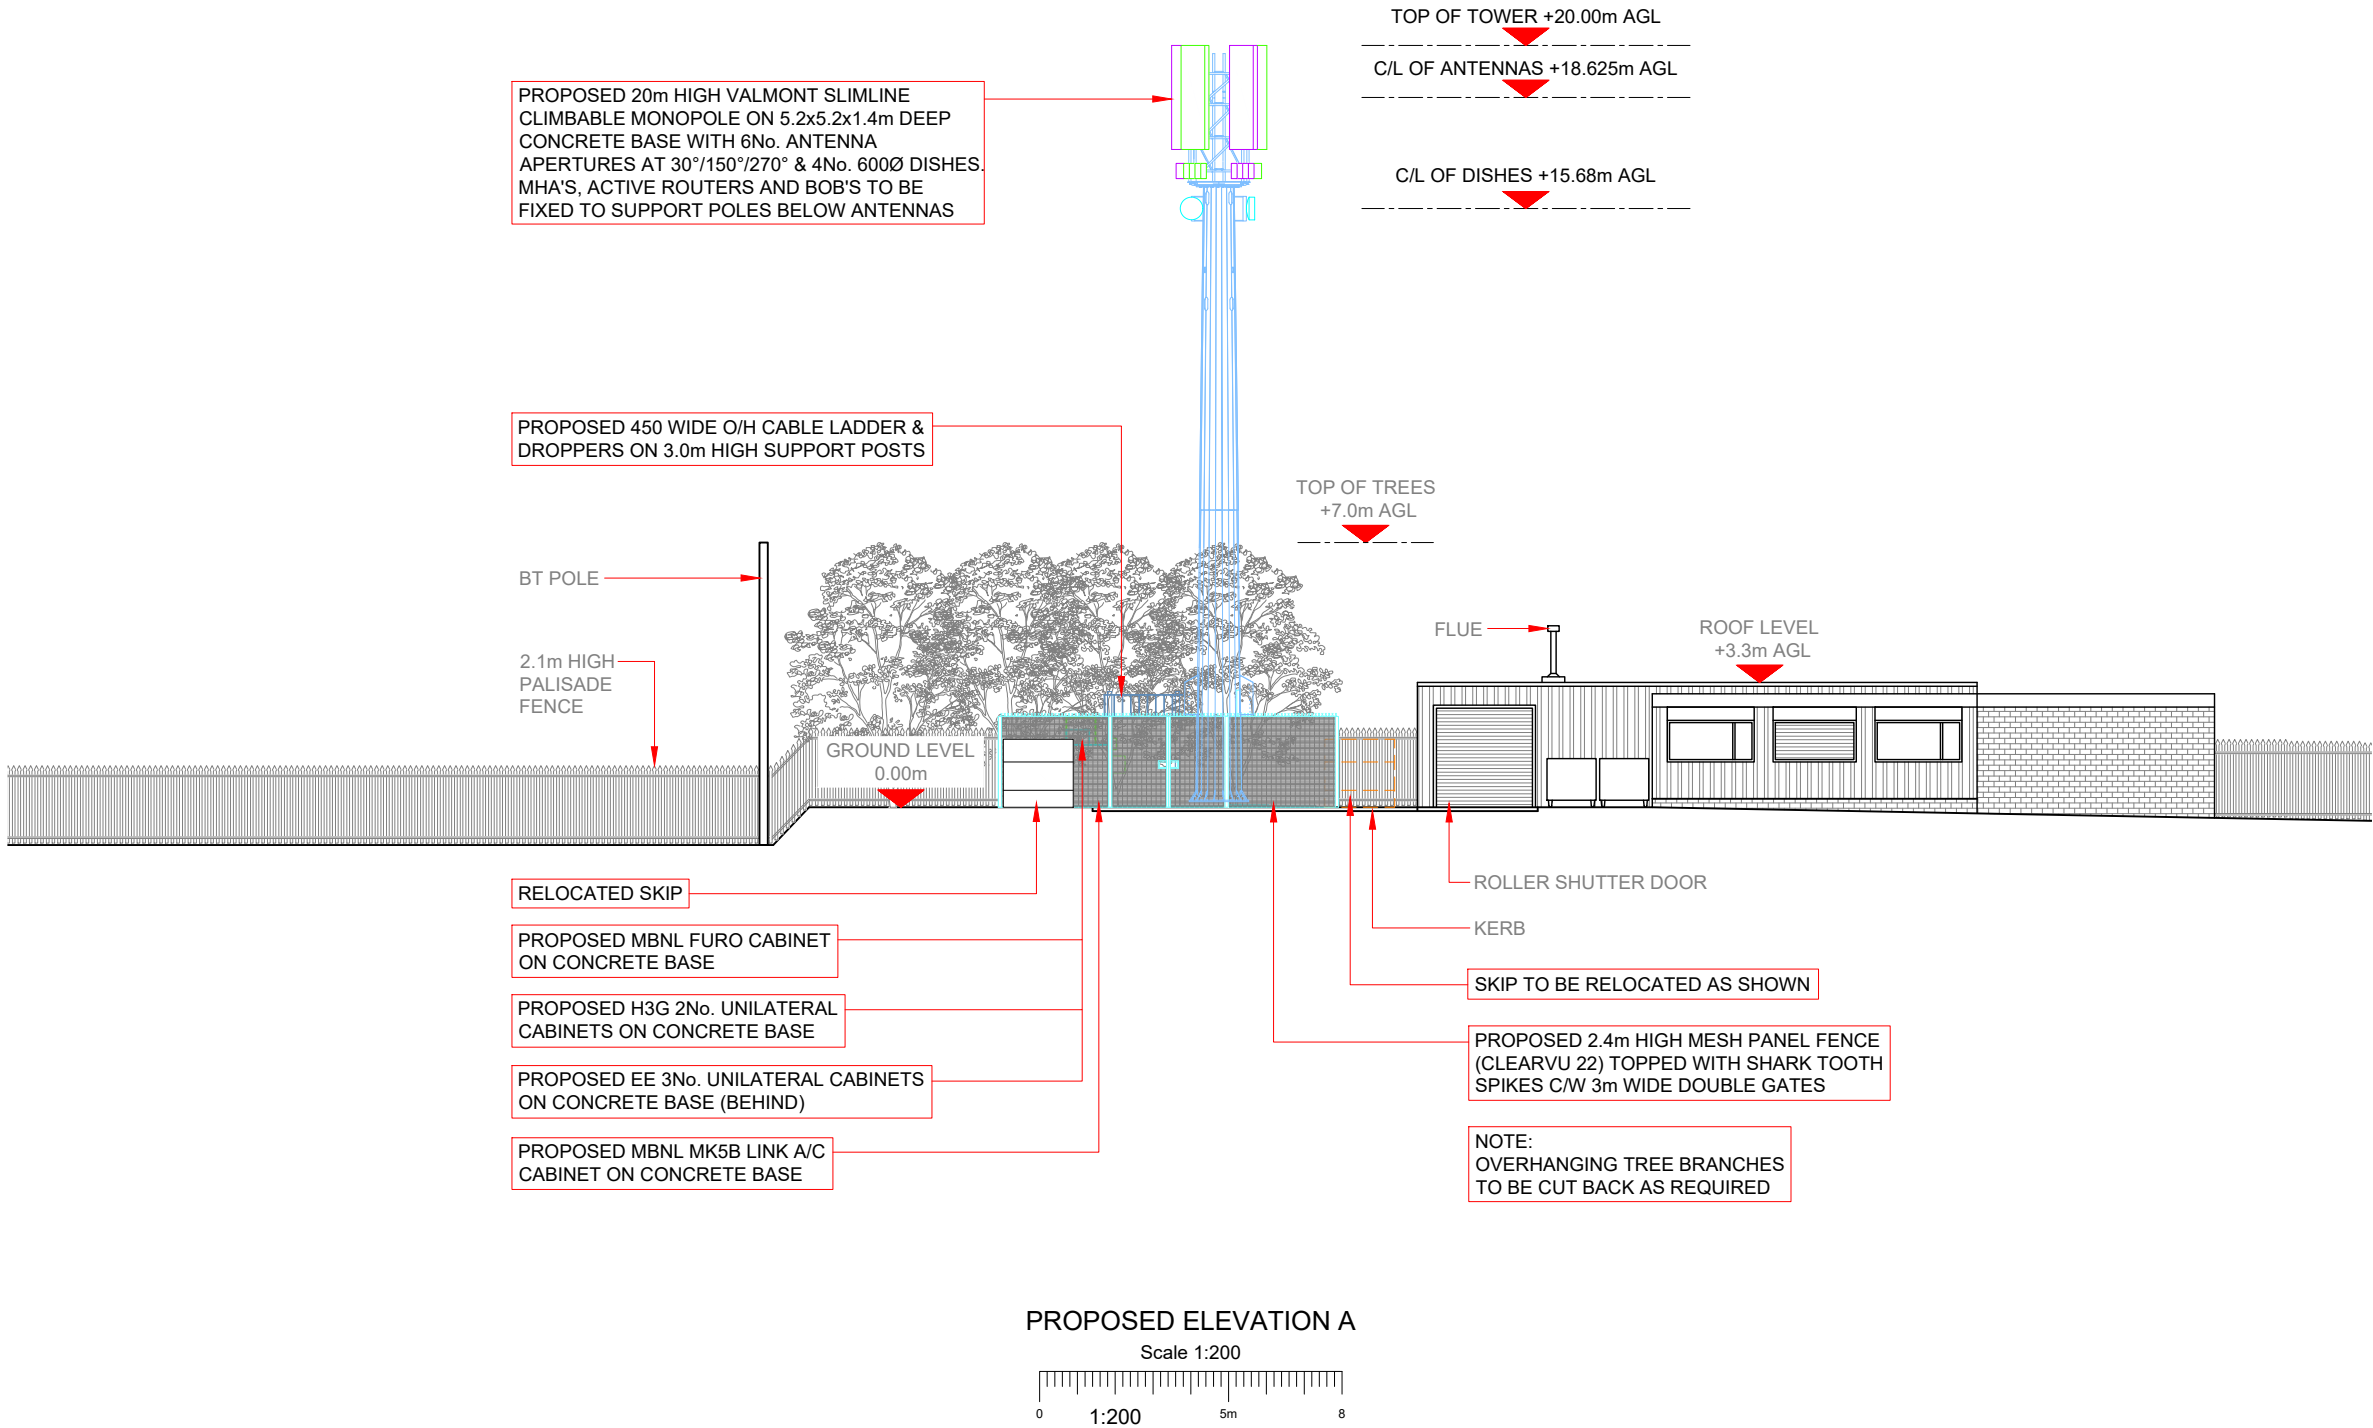

- NOTES:
- ALL DIMENSIONS IN MM UNLESS OTHERWISE NOTED.

SHARED CONFIGURATION SITE

RF CONFIG

H3b

Master:	MBNL / EE / H3G:	Project:	Purpose of Issue:	Issue:
M002	MBNL	NTQ	Planning	B
Date:	07/06/2022	Revision / Upgrade Description:		
Drawn:	D.PARTON	Re-Design with Valmont Slimline Monopole		
Checked:	A.FANNING			
Approved:	P.CONVERY			
Master:	MBNL / EE / H3G:	Project:	Purpose of Issue:	Issue:
M001	MBNL	NTQ	Planning	A
Date:	21/01/22	Revision / Upgrade Description:		
Drawn:	J. BOOTE	First Issue		
Checked:	J. STOCKDALE			
Approved:	J. STOCKDALE			



Hutchison 3G UK Limited
Star House, 20 Grenfell Road
Maidenhead, SL6 1EH
Tel: 01628 765 000
Fax: 01628 765 001
H3G Base Station Information line:
0845 6043000
Available 8am-8pm Monday to Friday



Hatfield Business Park
Hatfield
Hertfordshire
AL10 9BW
Tel: 01707 315000
Fax: 01707 319001



Mobile Broadband Network Limited
Sixth Floor, Thames Tower, Station Road, Reading, RG1 1LX

Design Consultant & Principal Contractor:



WHP Telecoms
Unit 1 Maple Park,
Low Fields Avenue, Leeds
LS12 6HH

Tel: 01133023550
e-mail: info@whptelecoms.com

Site Name:
GEORGE JONES & SON

Site ID:
1660400

Address:
GEORGE JONES & SON,
232 BRISCOE LANE,
MANCHESTER,
GREATER MANCHESTER,
M40 2XG

Title:
250 PROPOSED SHARED ELEVATION A

Project:
NTQ

Purpose of Issue:
GENERAL ARRANGEMENT

EE Cell ID: 79987	MBNL Cell ID: MAN506	3UK Cell ID: M0839
----------------------	-------------------------	-----------------------

Master Drawing No: 1660400_MAN506_79987_M0839_M002	Issue: B
---	-------------