



REVISIONS

- FIRST ISSUE

21.05.2021 OC

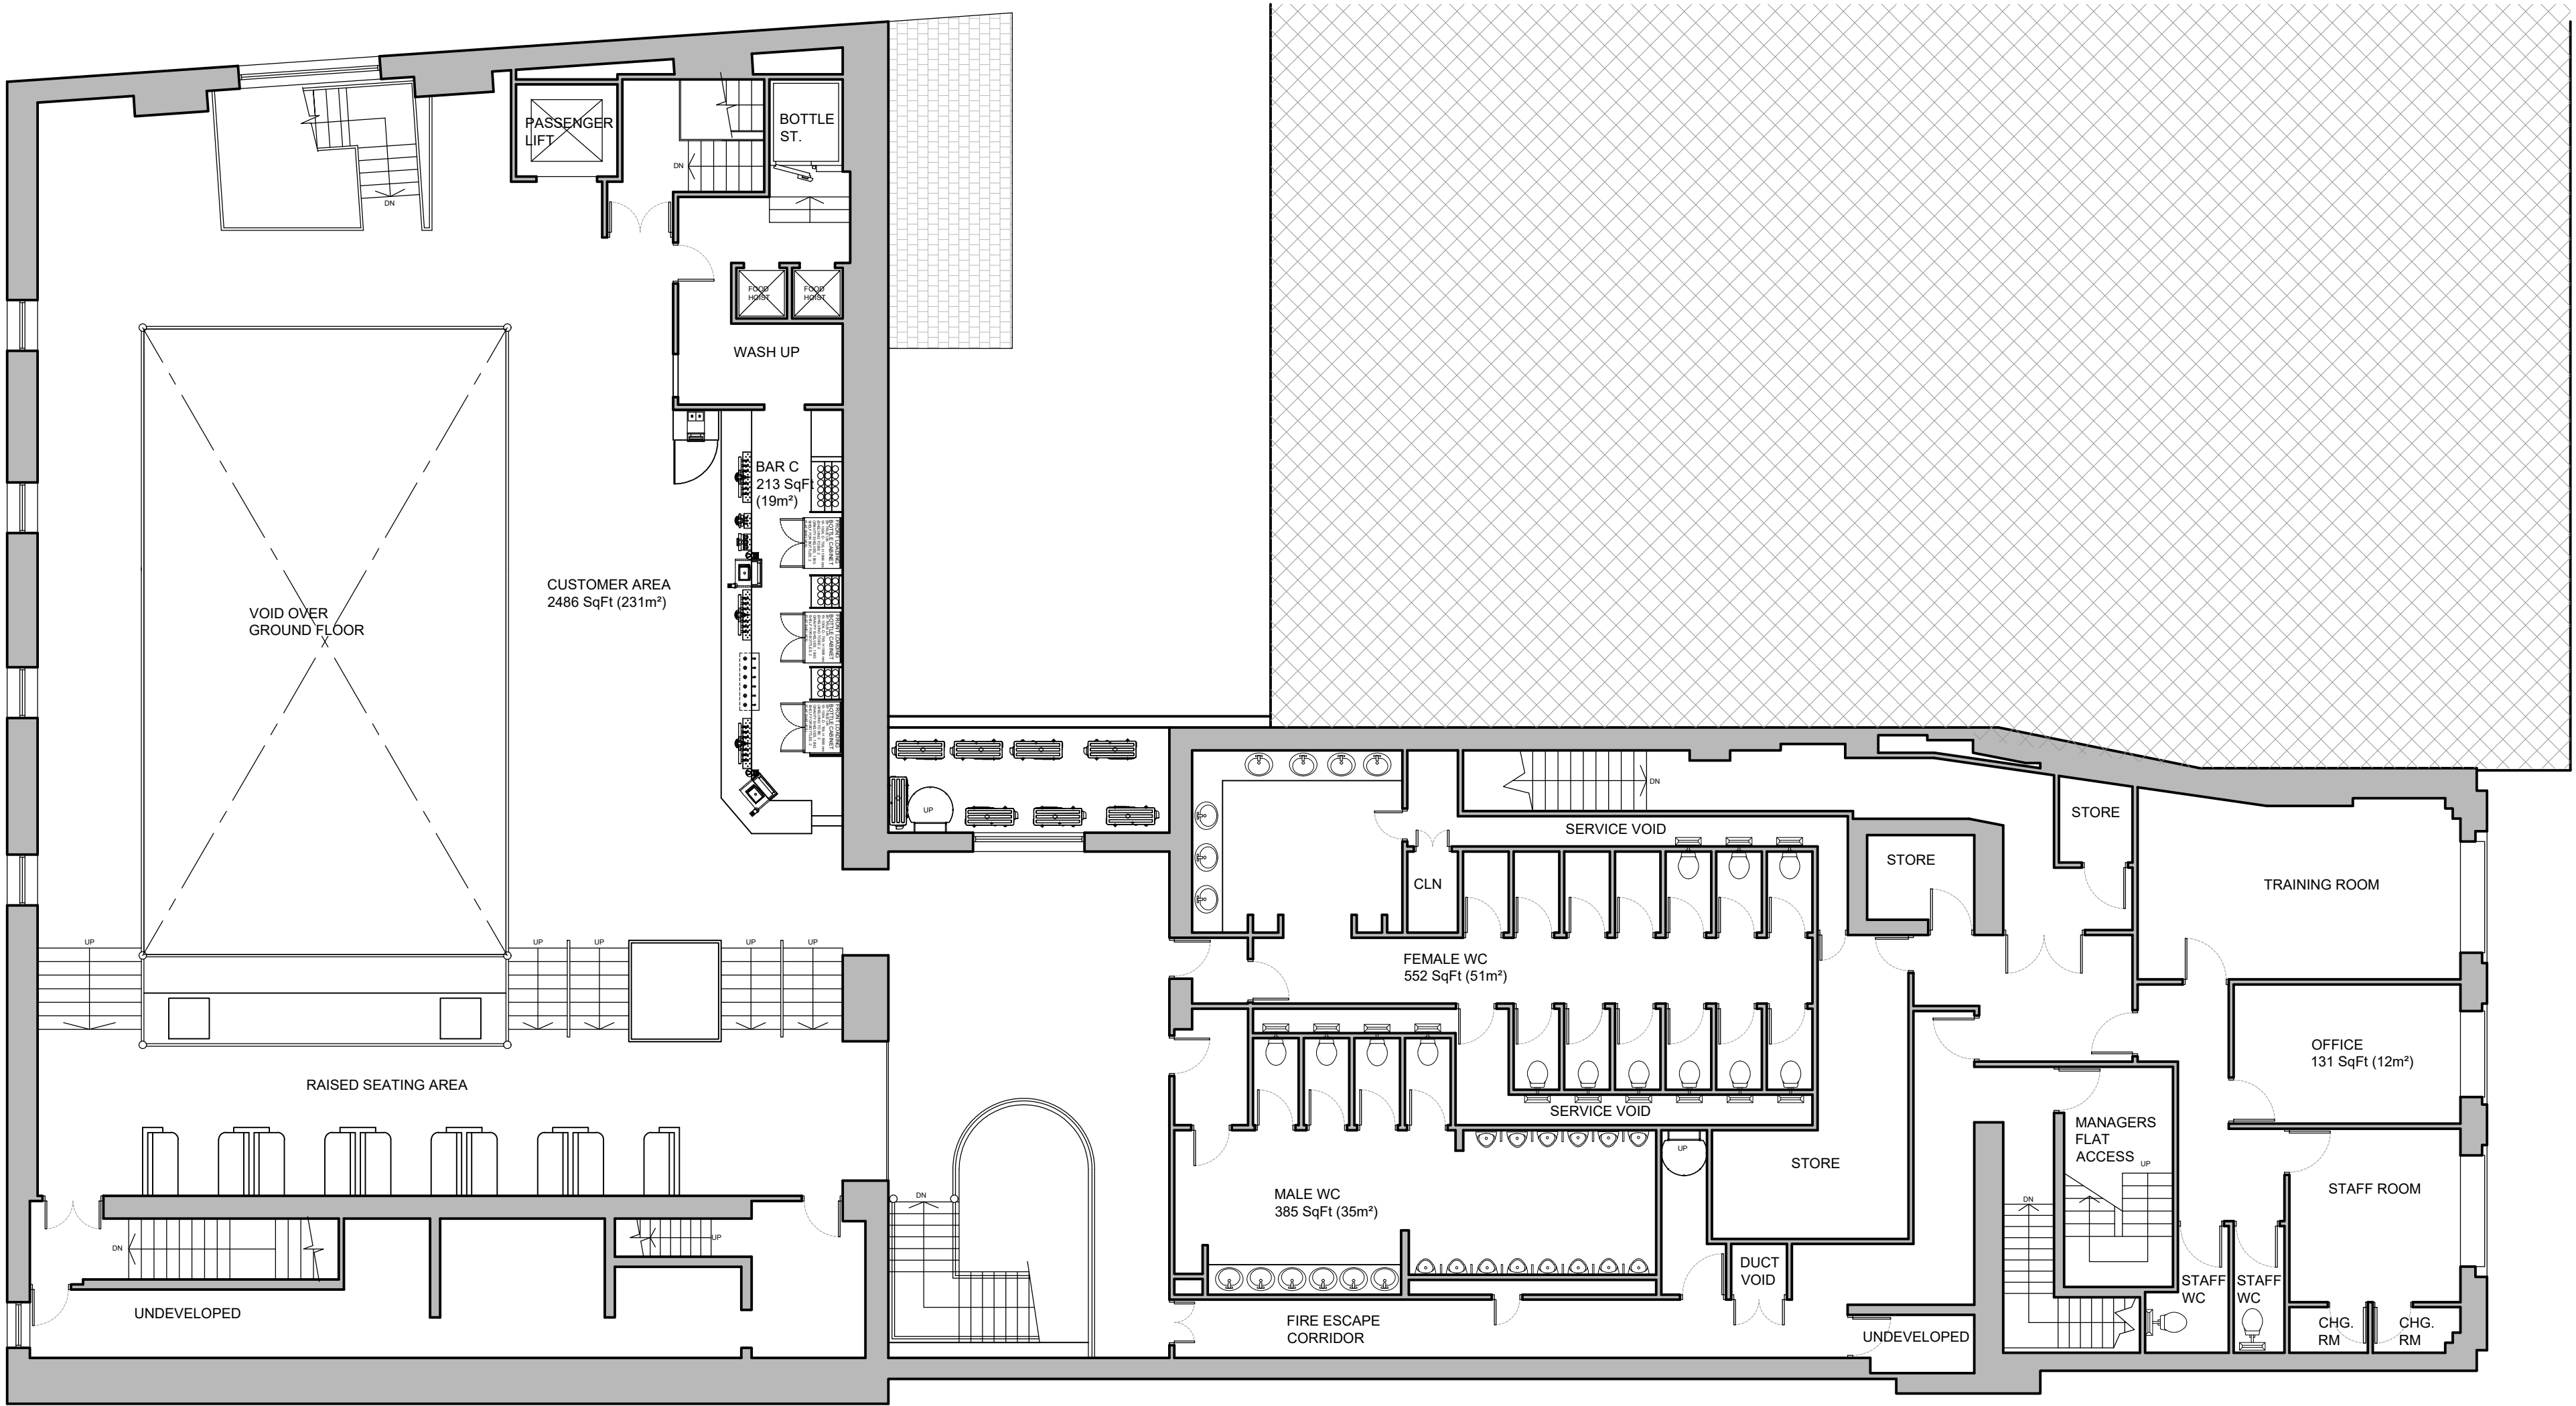

 EXISTING FIRST FLOOR PLAN
Scale 1:100



HARRISON INCE

ARCHITECTS INTERIOR DESIGNERS

JD WETHERSPOON PLC

CLIENT

THE MOON UNDER WATER (PN193)
68-74 DEANS GATE, MANCHESTER, M3 2FN

PROJECT

EXISTING FIRST FLOOR PLAN

TITLE

DATE MAY 2021

SCALE 1:100 @ A1

JOB NO. JDX1277

DWG. NO. AS02

DRAWN CAD/OC

CHECKED

2-4 LITTLE PETER STREET
RUN HOUSE
KNOTT MILL
MANCHESTER
M15 4PS
TEL: 0161 236 3650
EMAIL: enquiries@harrison-ince.co.uk