



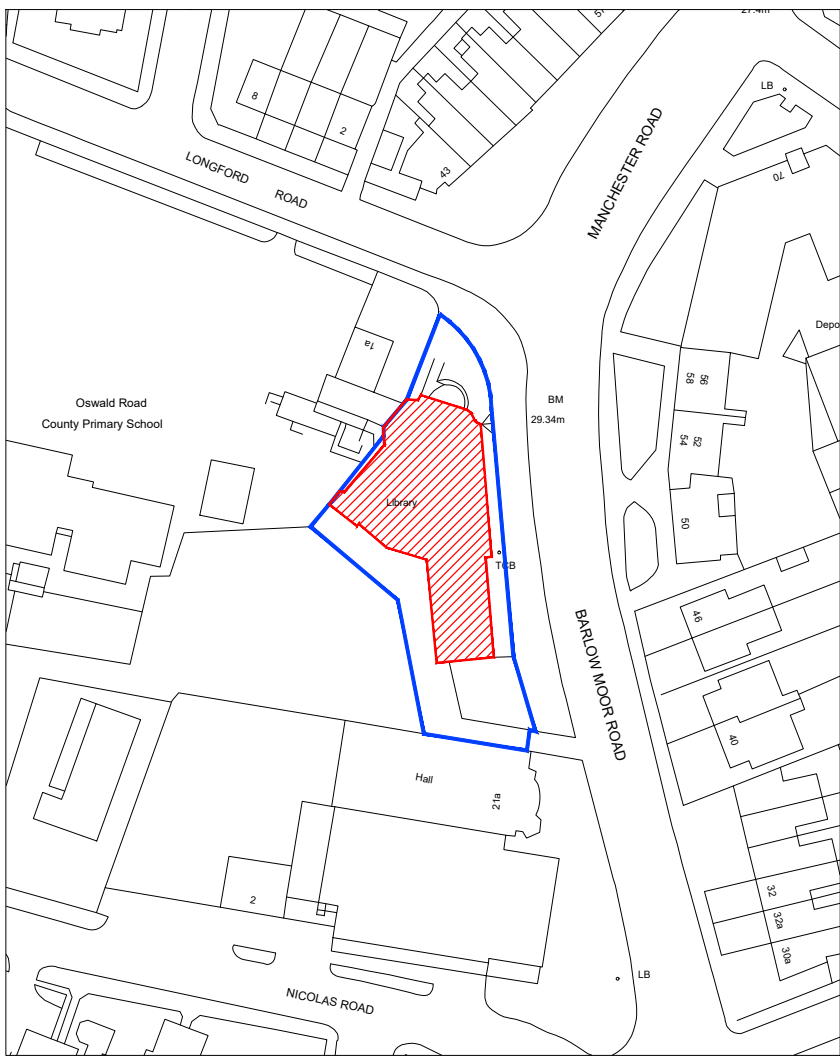


Location Plan as Existing
Scale 1:1250



Ground Floor Plan as Existing
Scale 1:100

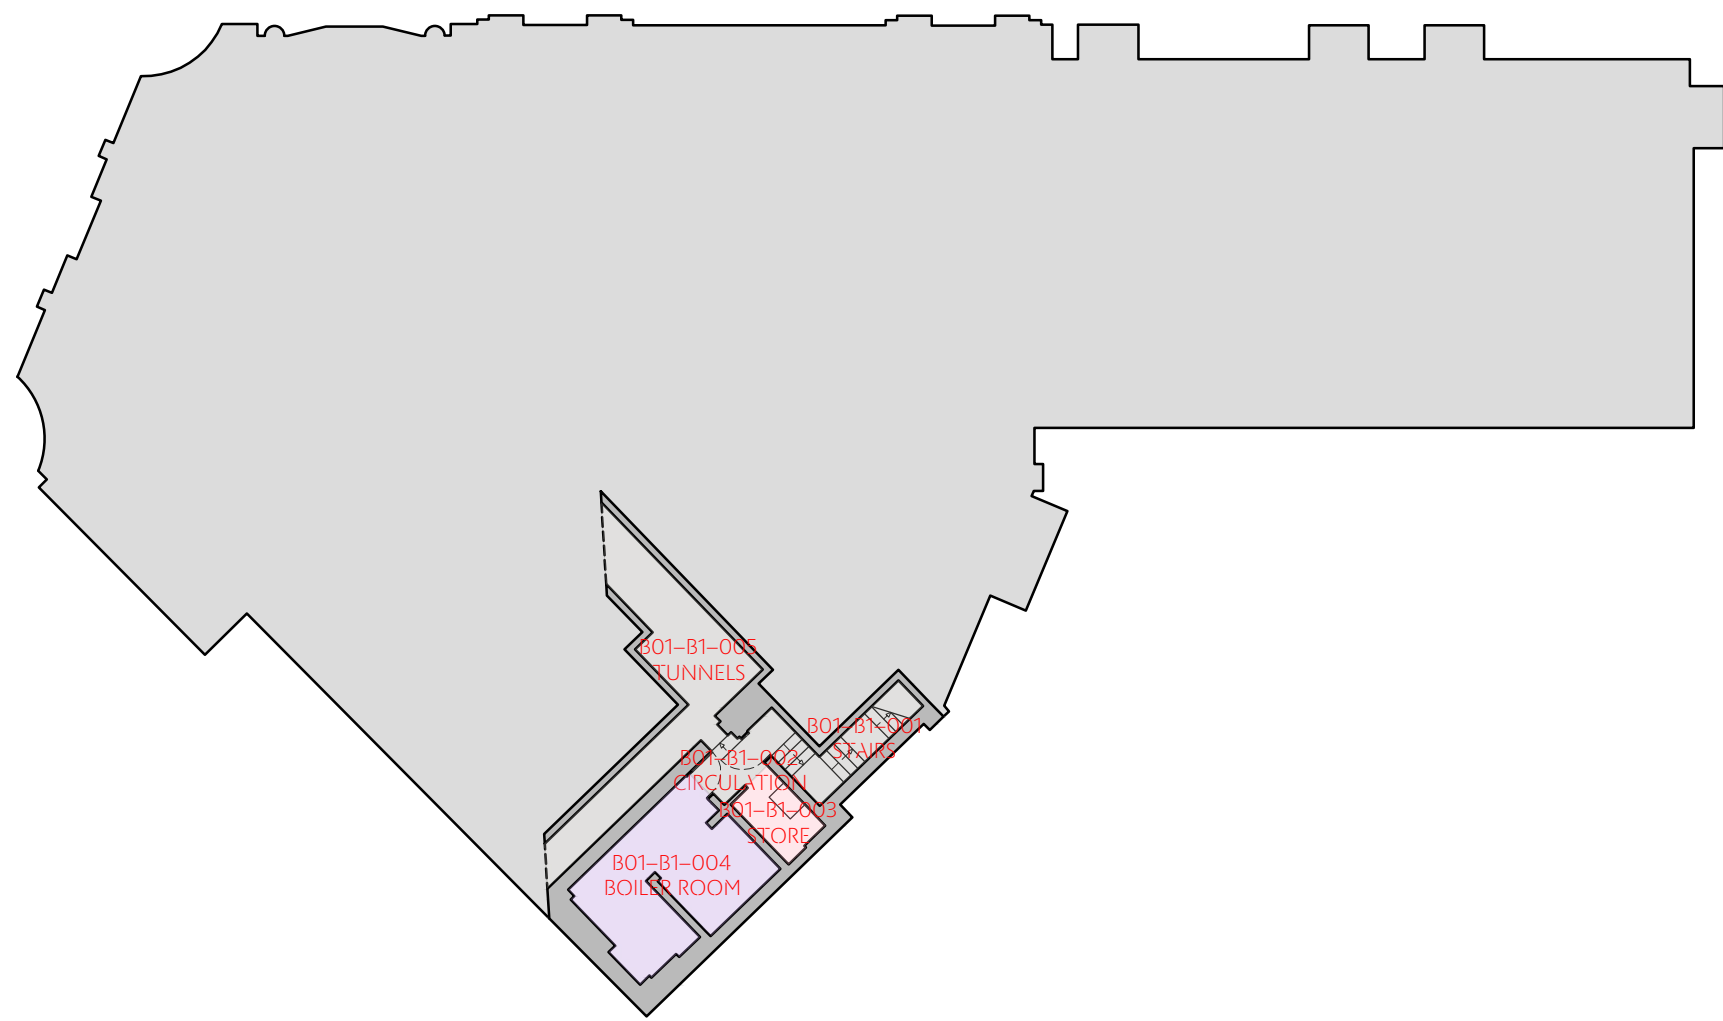

Basement Floor Plan as Existing
Scale 1:200

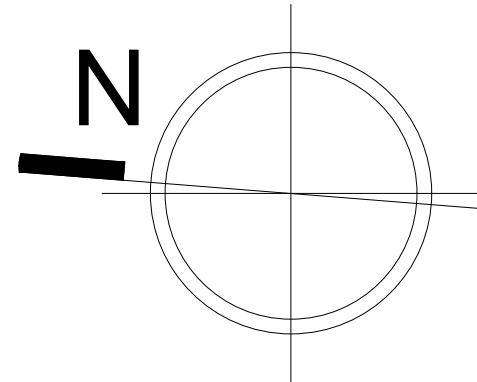

1. DO NOT SCALE FROM THIS DRAWING - USE FIGURED DIMENSIONS ONLY.
2. READ IN CONJUNCTION WITH ALL OTHER CONSULTANTS / SPECIALISTS DRAWINGS, REPORT ANY DISCREPANCIES BEFORE AFFECTED WORK COMMENCES.
3. ALL SETTING OUT DIMENSIONS TO BE CHECKED ON SITE BY CONTRACTOR BEFORE WORK COMMENCES.
4. THIS DRAWING REMAINS COPYRIGHT OF KEP CZYK PEARCE SANDERSON LTD. COPY / DISTRIBUTE ONLY WITH CONSENT OF THE AUTHOR.

KEY	
	PUBLIC
	MEETING
	CLERICAL
	KITCHEN
	RESTROOM
	M&E
	STORAGE
	CIRCULATION
	ROOM REFERENCES
	DOOR REFERENCES
	WINDOW REFERENCES
	R RADIATOR
	REMOVALS AS PROPOSED
	NEW WORKS AS PROPOSED

Rev. A Amended North Symbols (LMC | 2022 07 05)

Contract		Open Libraries Development		Basement and Ground Floor Plans as Existing											
Client		Manchester City Council		Contract No.		2141		Drawn		LMC		Drawing No.		FR 001	
Building / Structure		Chorlton District Library, Chorlton-cum-Hardy		Date		May 2022		Revision		A		Scale		Various @ A1	
KEPCZYK PEARCE SANDERSON ARCHITECTS, SURVEYORS & HISTORIC BUILDING CONSULTANTS															
Address:				75 Wilmslow Road, Handforth, Cheshire SK9 3EN											
Tel:				01625 400103											