






GENERAL NOTES:

- THIS DRAWING IS TO BE READ IN CONJUNCTION WITH ALL RELEVANT ARCHITECTS AND ENGINEERS DRAWINGS AND SPECIFICATIONS.
- DO NOT SCALE THIS DRAWING. ANY AMBIGUITIES, OMISSIONS AND ERRORS ON DRAWINGS SHALL BE BROUGHT TO THE ENGINEERS ATTENTION IMMEDIATELY. ALL DIMENSIONS MUST BE CHECKED / VERIFIED ON SITE.
- ALL DIMENSIONS ARE IN MILLIMETRES UNLESS NOTED OTHERWISE.
- REFER TO THE DRAINAGE LAYOUT FOR THE LOCATION OF THE FLOW CONTROL..
- FLOW CONTROL TO BE INSTALLED STRICTLY IN ACCORDANCE WITH THE MANUFACTURER'S REQUIREMENTS.
- WHERE ALTERNATIVE FLOW CONTROL DEVICE IS PREFERRED, IT WILL BE SUBJECT TO REDESIGN TO CONFIRM WHETHER THE SYSTEM HAS CAPACITY.
- DO NOT SCALE THIS DRAWING. ANY AMBIGUITIES, OMISSIONS AND ERRORS ON DRAWINGS SHALL BE BROUGHT TO THE ENGINEERS ATTENTION IMMEDIATELY. ALL DIMENSIONS MUST BE CHECKED / VERIFIED ON SITE.

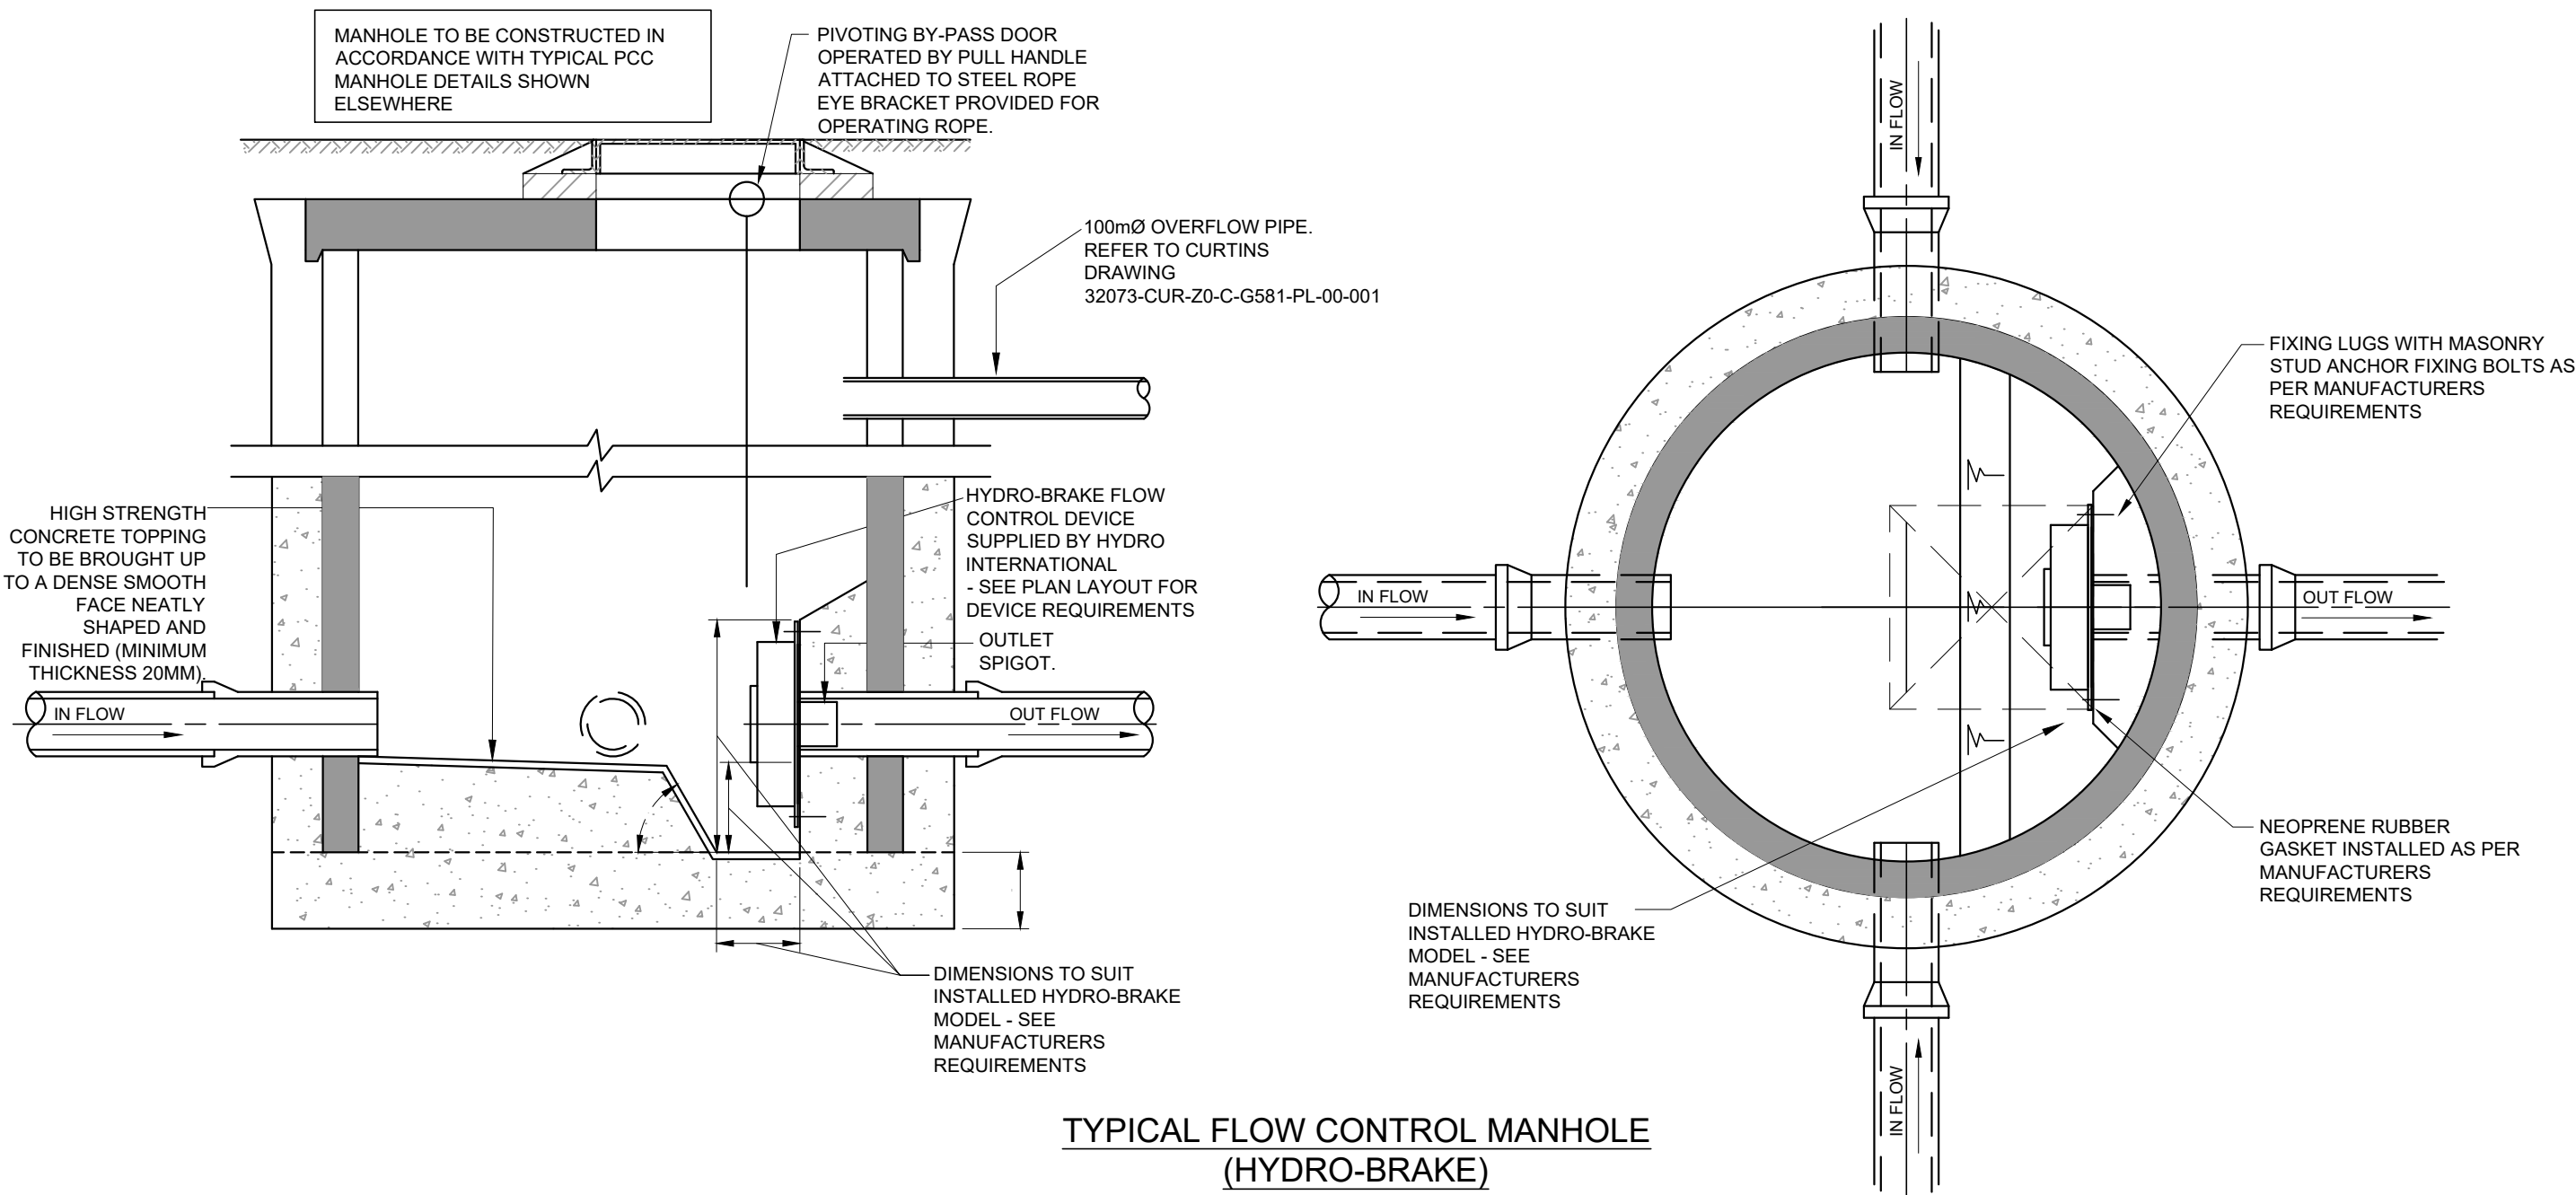

SWMH 7 HYDROBRAKE DETAIL

SWMH 9 HYDROBRAKE DETAIL

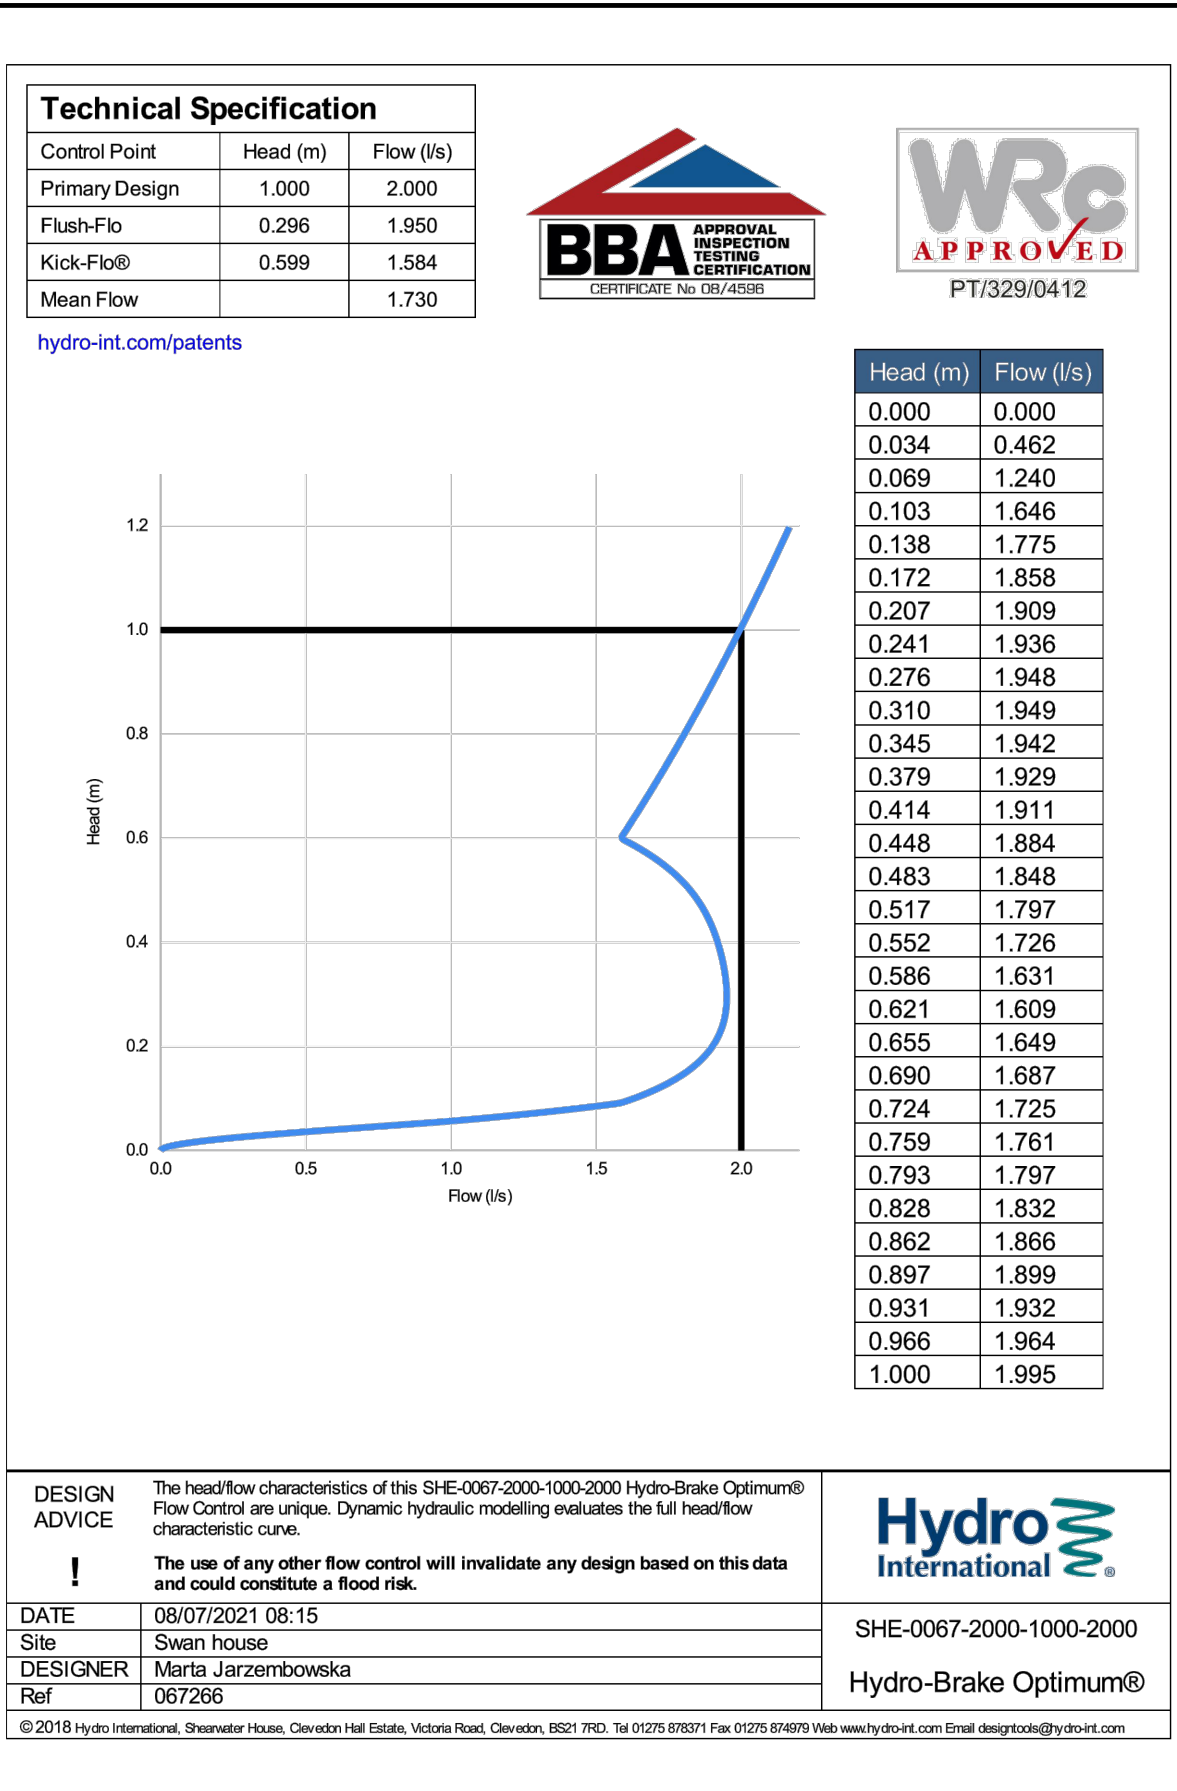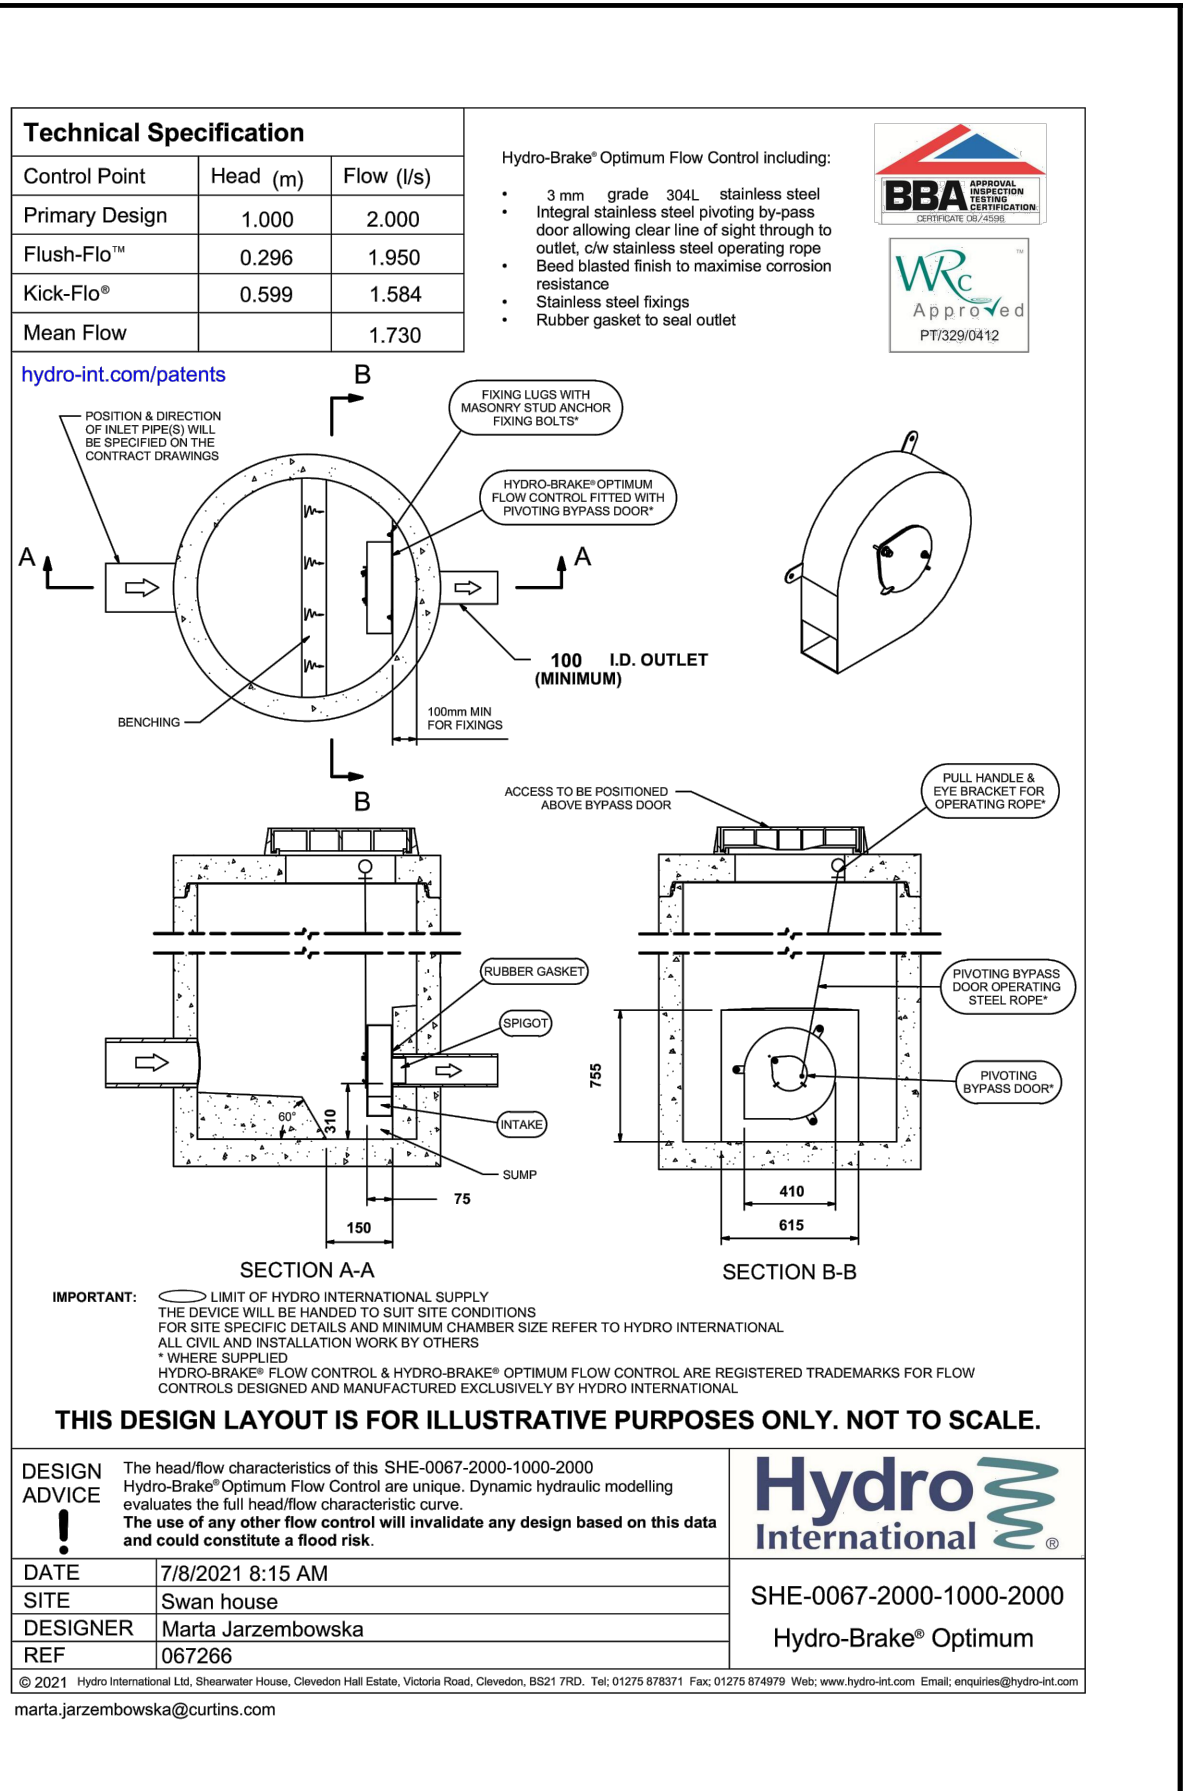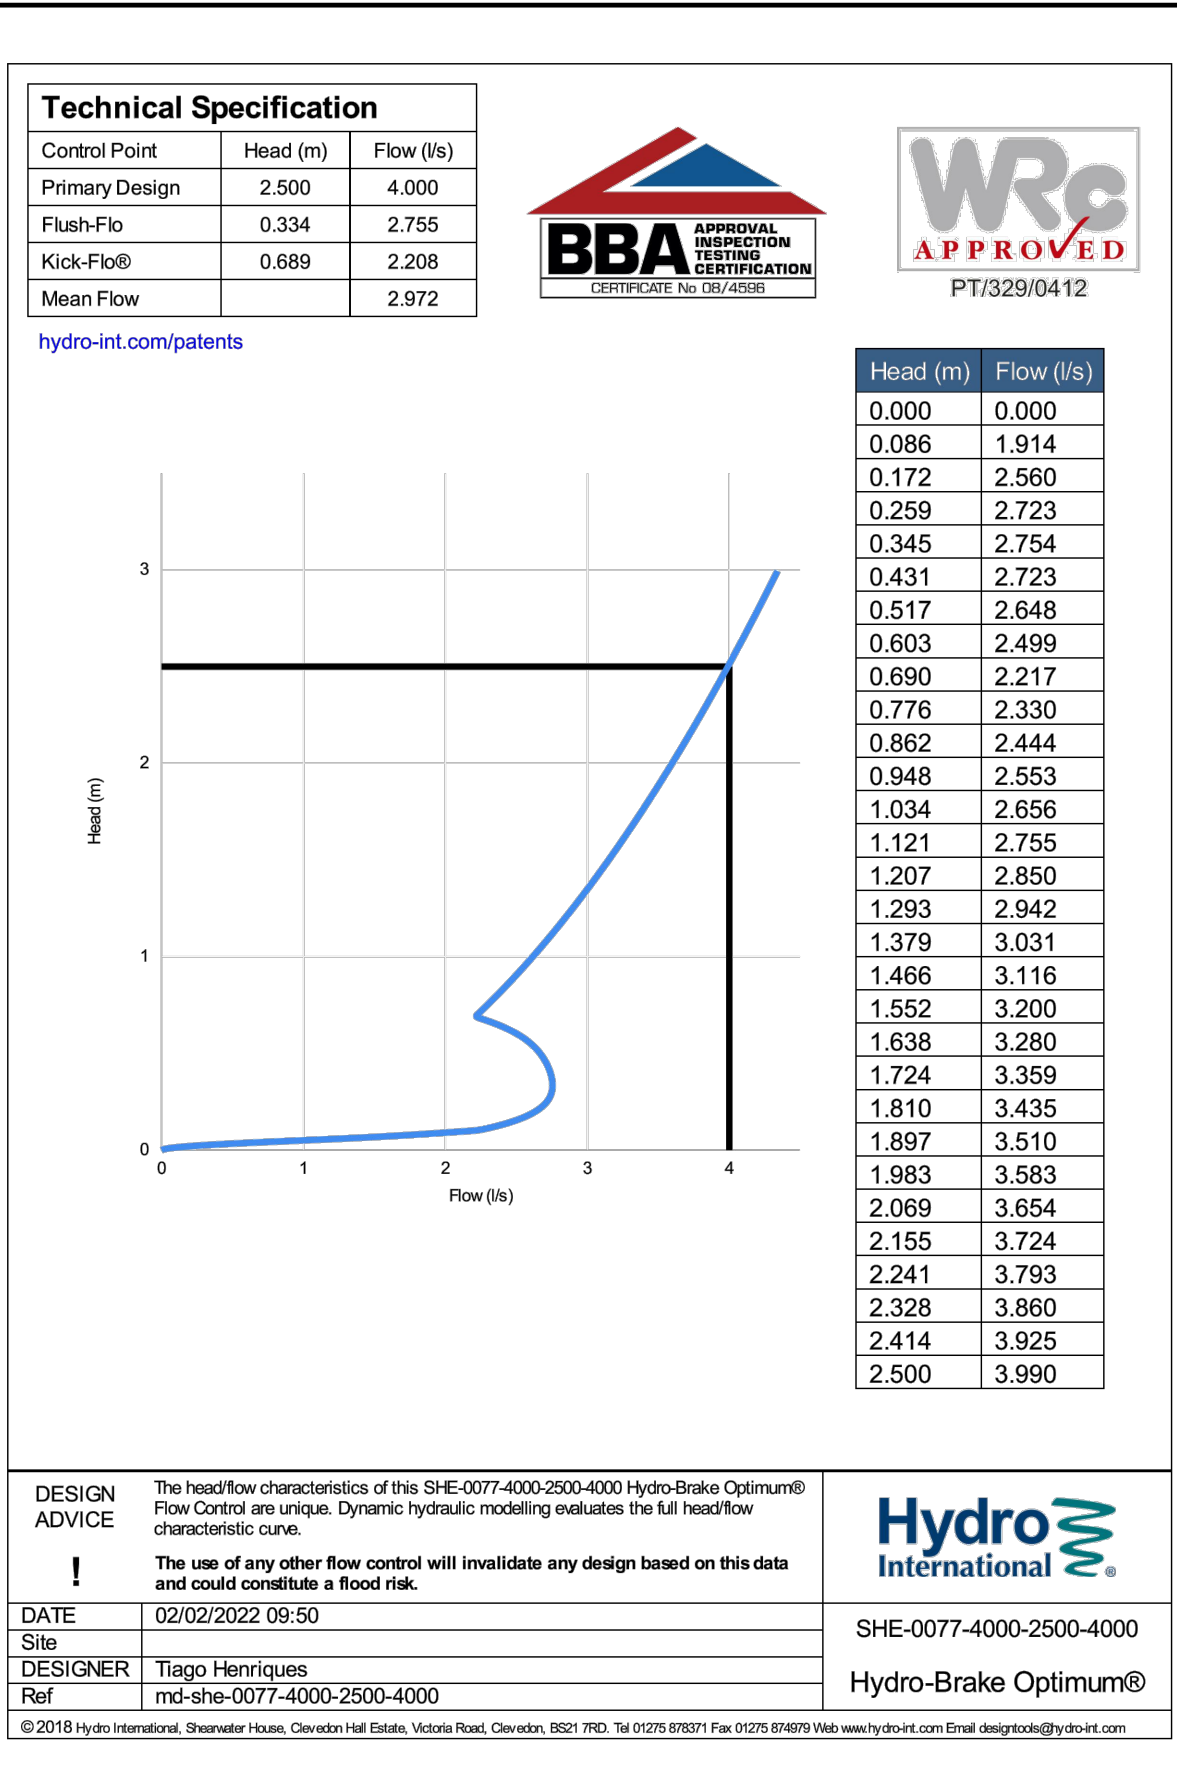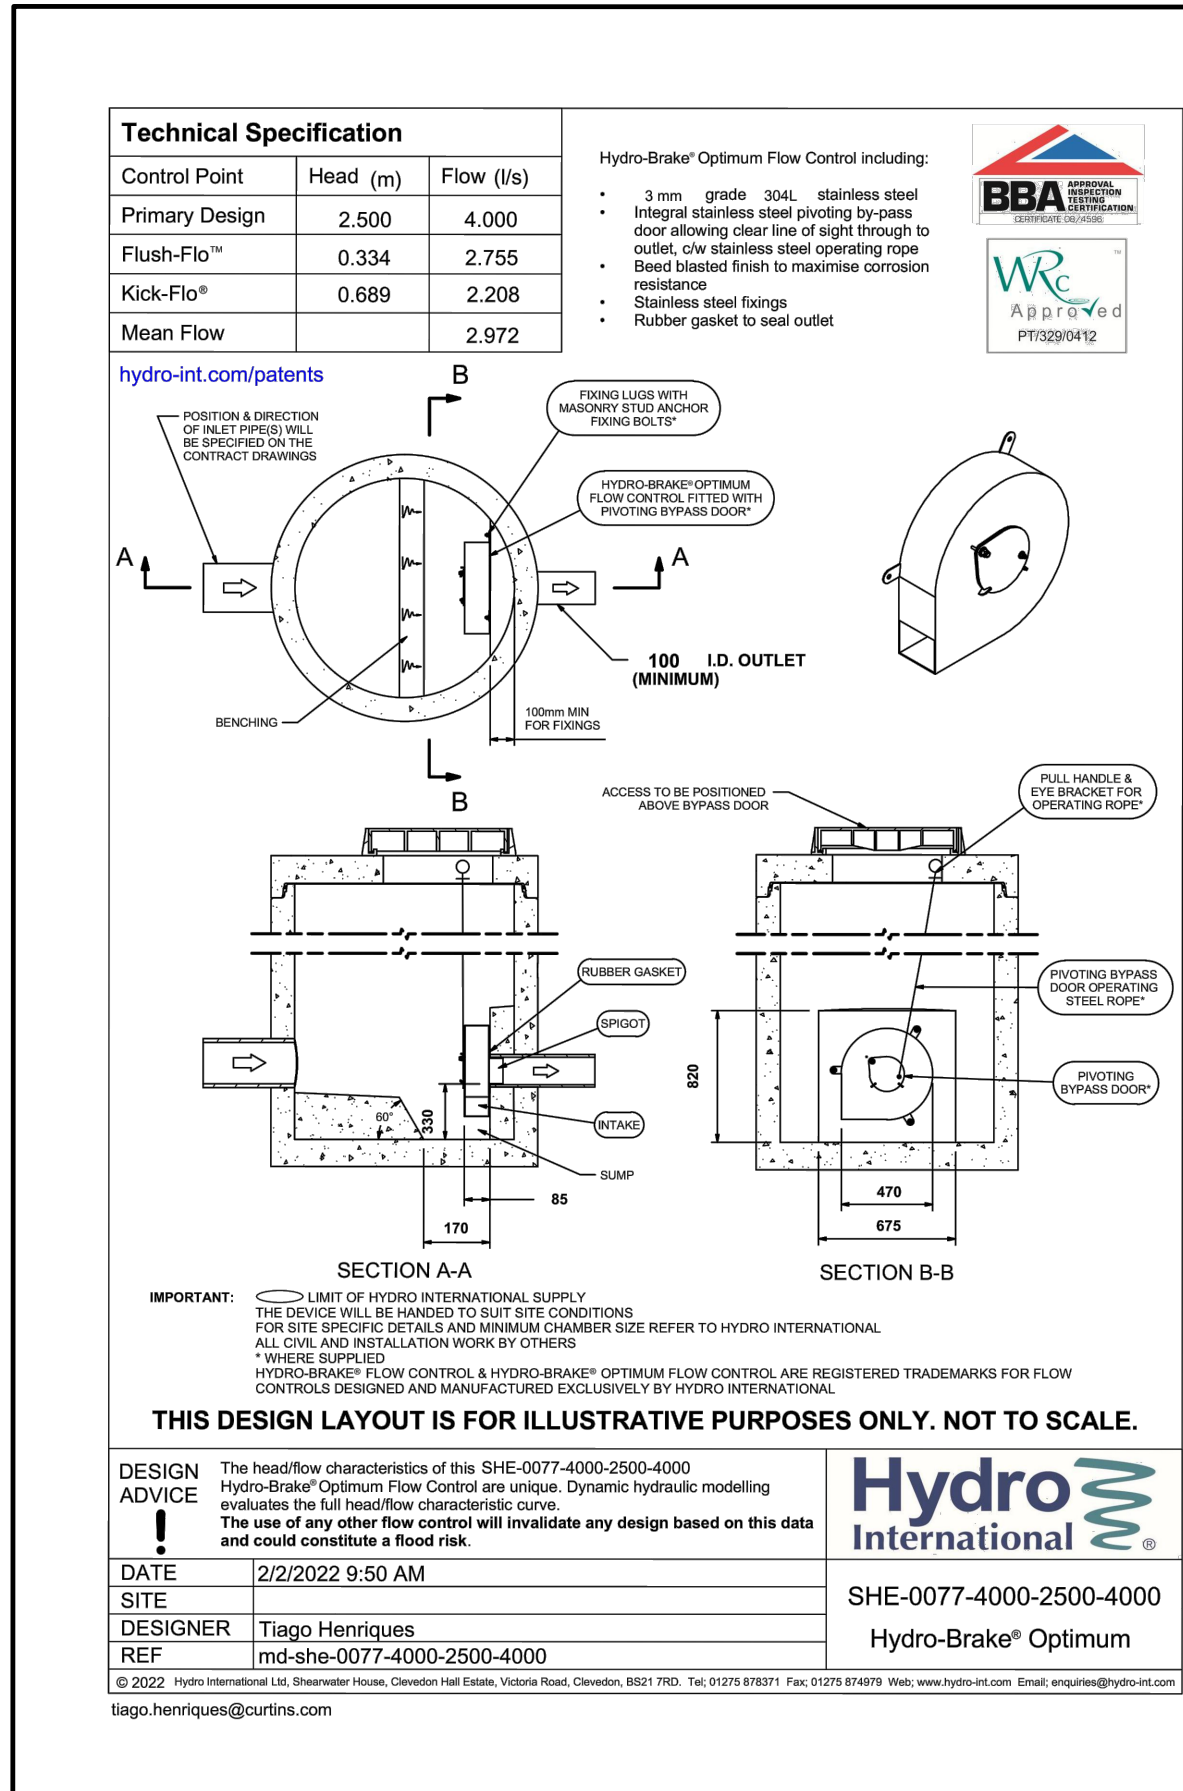

C02	HYDROBRAKE TYPE SW7 AMENDED	02/02/22	MW	MW
C01	FOR CONSTRUCTION	02/12/21	MW	MW
P01	STAGE 4 ISSUE	08/07/21	CS	MW

Rev:	Description:	Date:	By:	Chkd:
------	--------------	-------	-----	-------

curtins

Merchant Exchange, 17-19 Whitworth Street West, Manchester, M1 5WG
0161 235 2384
manchester@curtins.com
www.curtins.com

Civils & Structures • Transport Planning • Environmental • Infrastructure • Geotechnical • Conservation & Heritage • Principal Designer
Birmingham • Bristol • Cambridge • Cardiff • Douglas • Dublin • Edinburgh • Glasgow • Kentish • Leeds • Liverpool • London • Manchester • Nottingham

Status: **FOR CONSTRUCTION**

Project: **SWAN HOUSE, ROCHDALE ROAD**

Orig Title: **DRAINAGE DETAILS SHEET 4**

Project No:	Size:	Date:	Drawn By:	Designed By:	Checked By:	RG Series:
067266	A1	18/01/21	MW	MW	CG	26
Scale:	1:20					

Project Code:	Originator:	Volume:	Role:	Uniclass:	Type:	Level:	Number:	Rev:
---------------	-------------	---------	-------	-----------	-------	--------	---------	------

32073 - CUR - Z0 - C - G581- DE - XX- 007- C02