


CONDENSER EQUIPMENT SPECIFICATION


CU UNIT REF	NUMBER	WEIGHT	DIMENSION	SOUND POWER (COOLING)
RXYSCQ4T	CU No 1	89 KG	823mm (H) 940mm (W) 480mm (D)	51 dBA
RZAG 35A	CU No 2	52 KG	734mm (H) 870mm (W) 373mm (D)	48 dBA
RZAG 35A	CU No 3	52 KG	734mm (H) 870mm (W) 373mm (D)	48 dBA
RZAG 35A	CU No 4	52 KG	734mm (H) 870mm (W) 373mm (D)	48 dBA
RZASG 125L	CU No 5	70 KG	990mm (H) 940mm (W) 320mm (D)	49 dBA




EXTERNAL SERVICE YARD POSITION FOR CONDENSERS

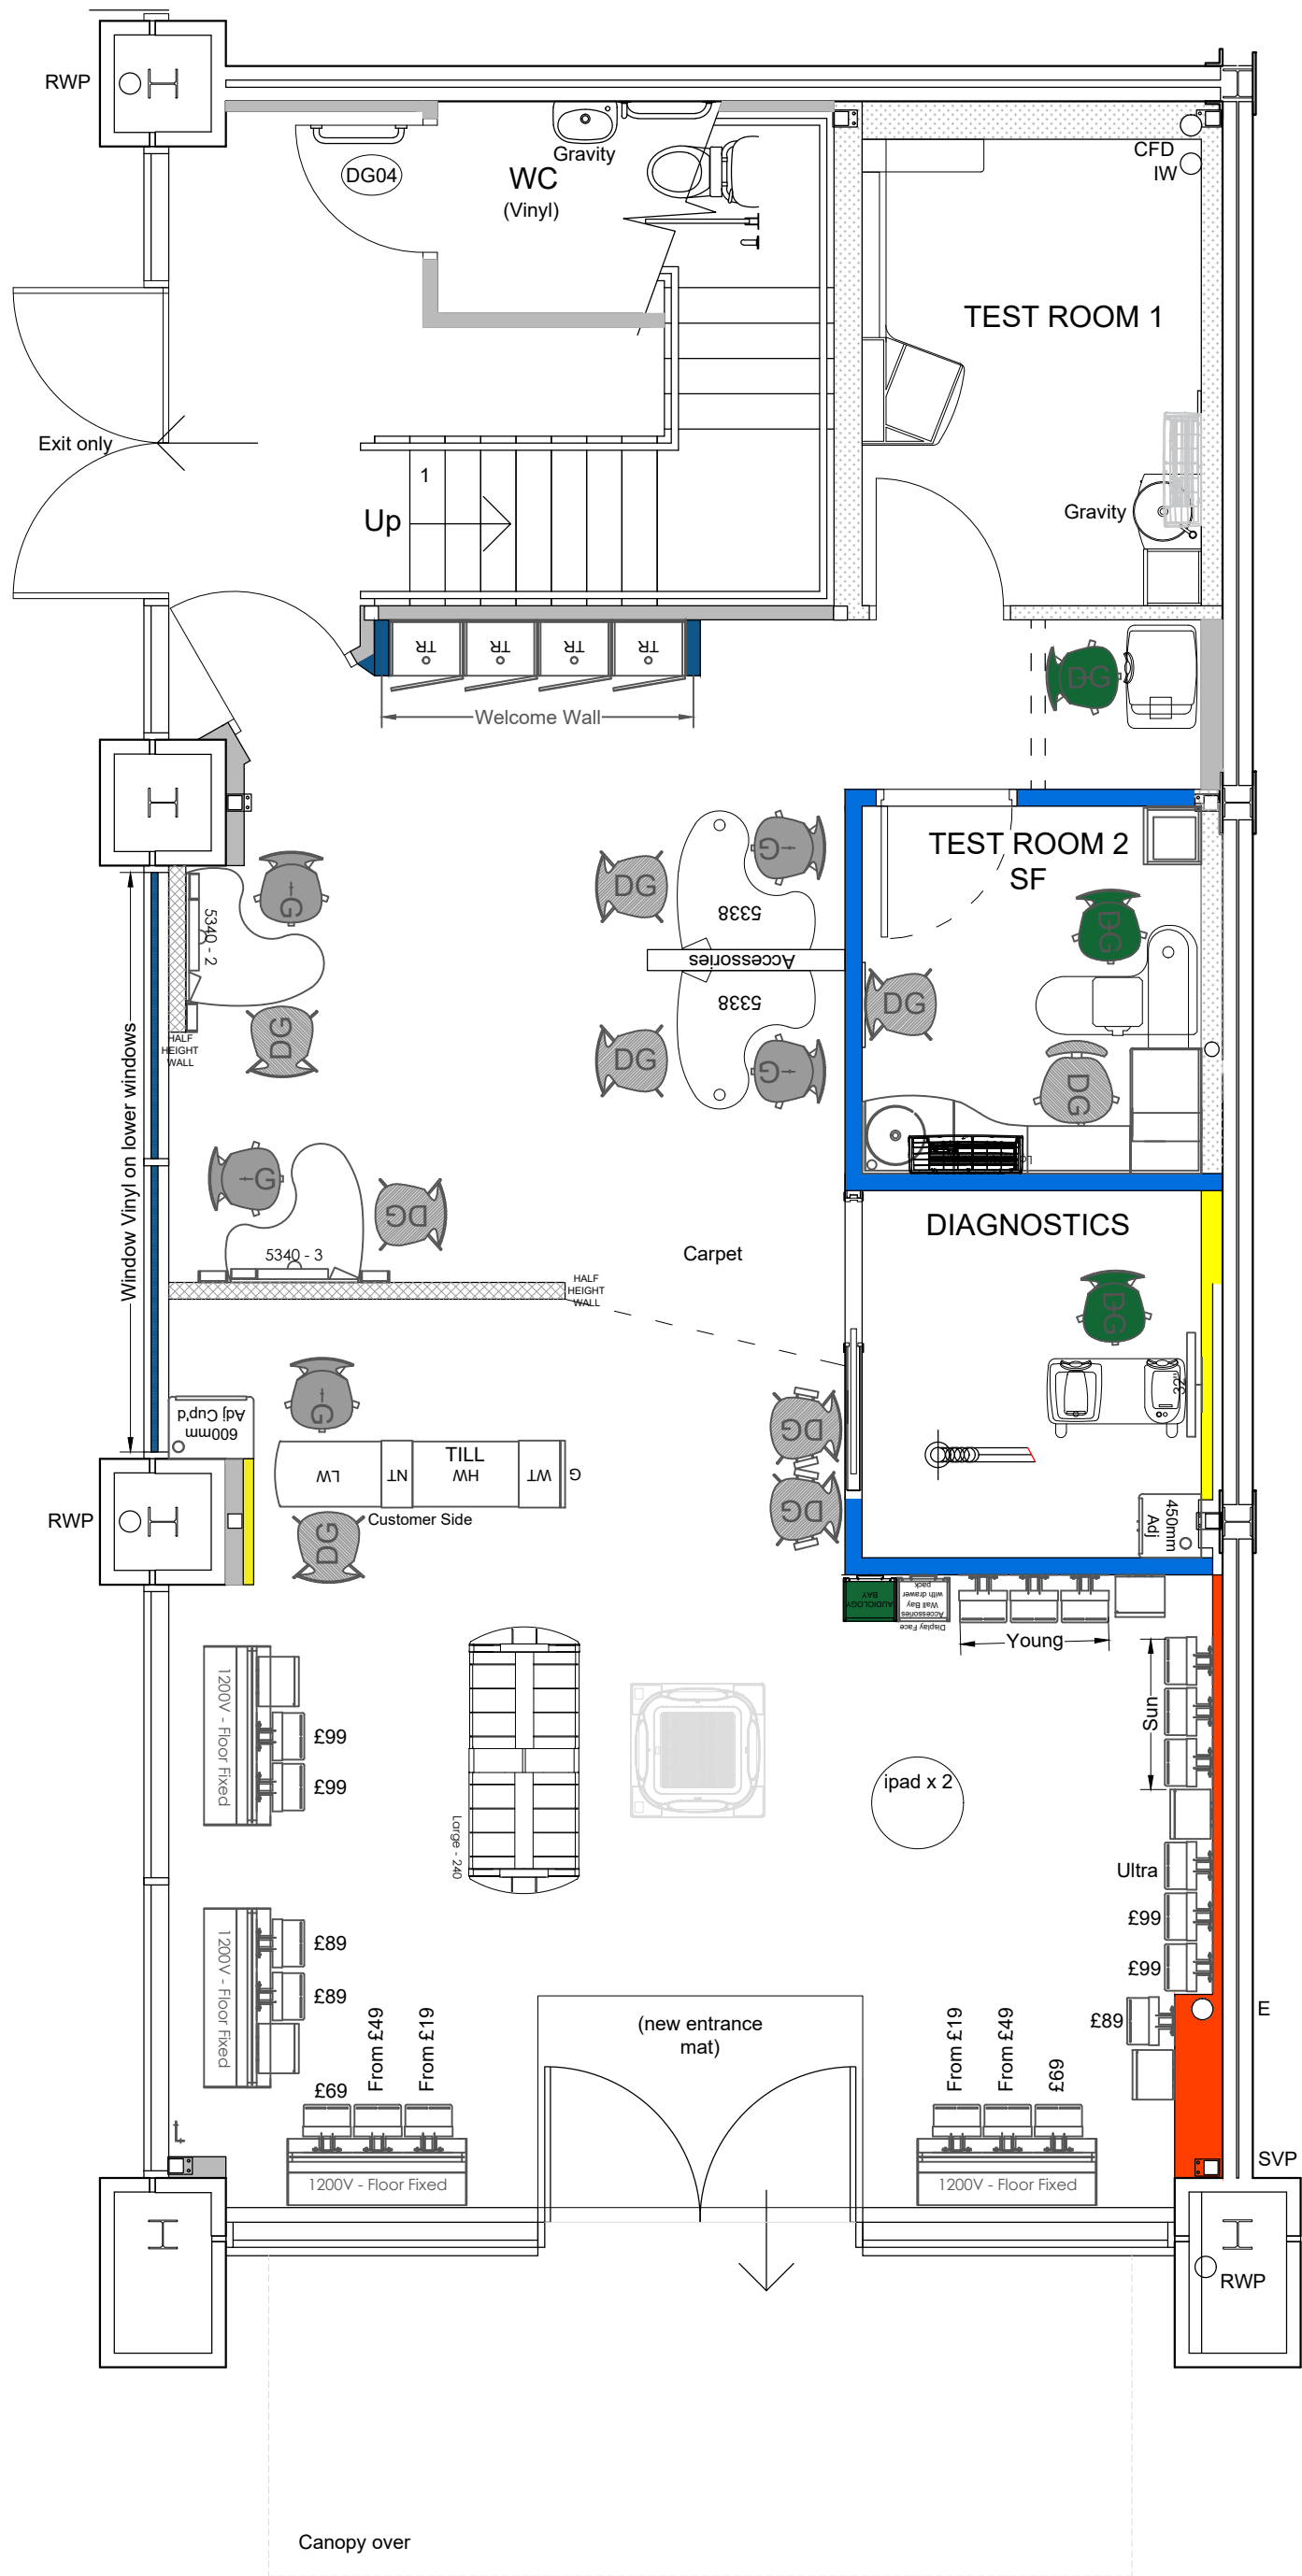



PROPOSED GROUND FLOOR PLAN

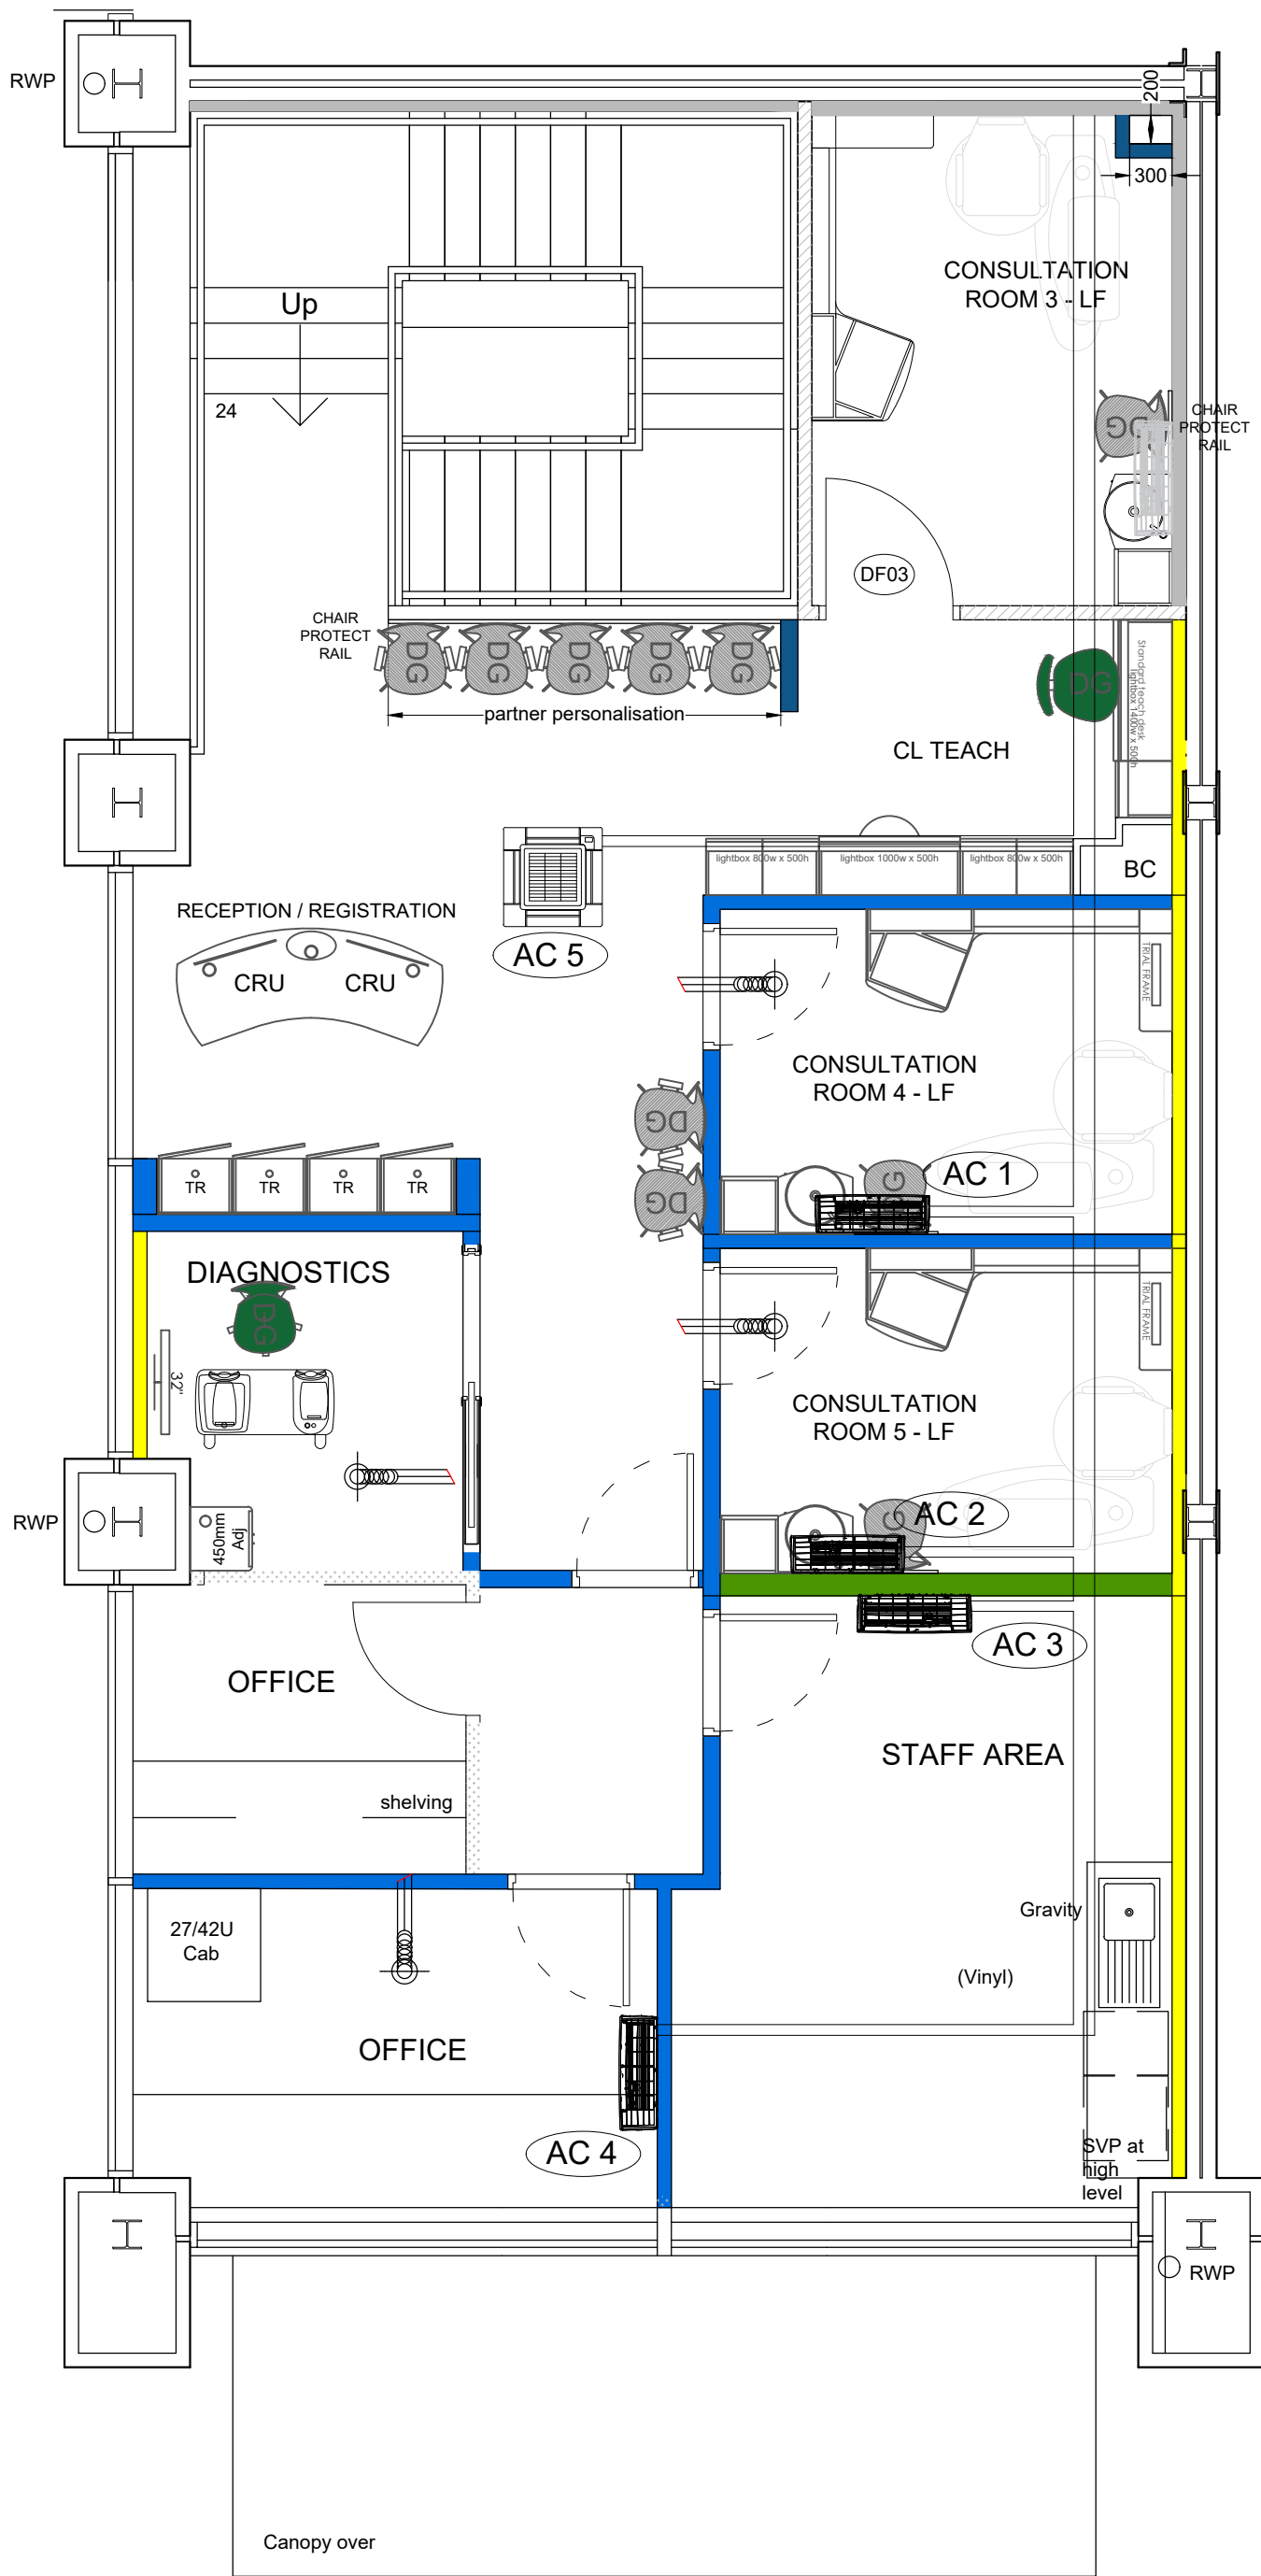

PROPOSED FIRST FLOOR PLAN

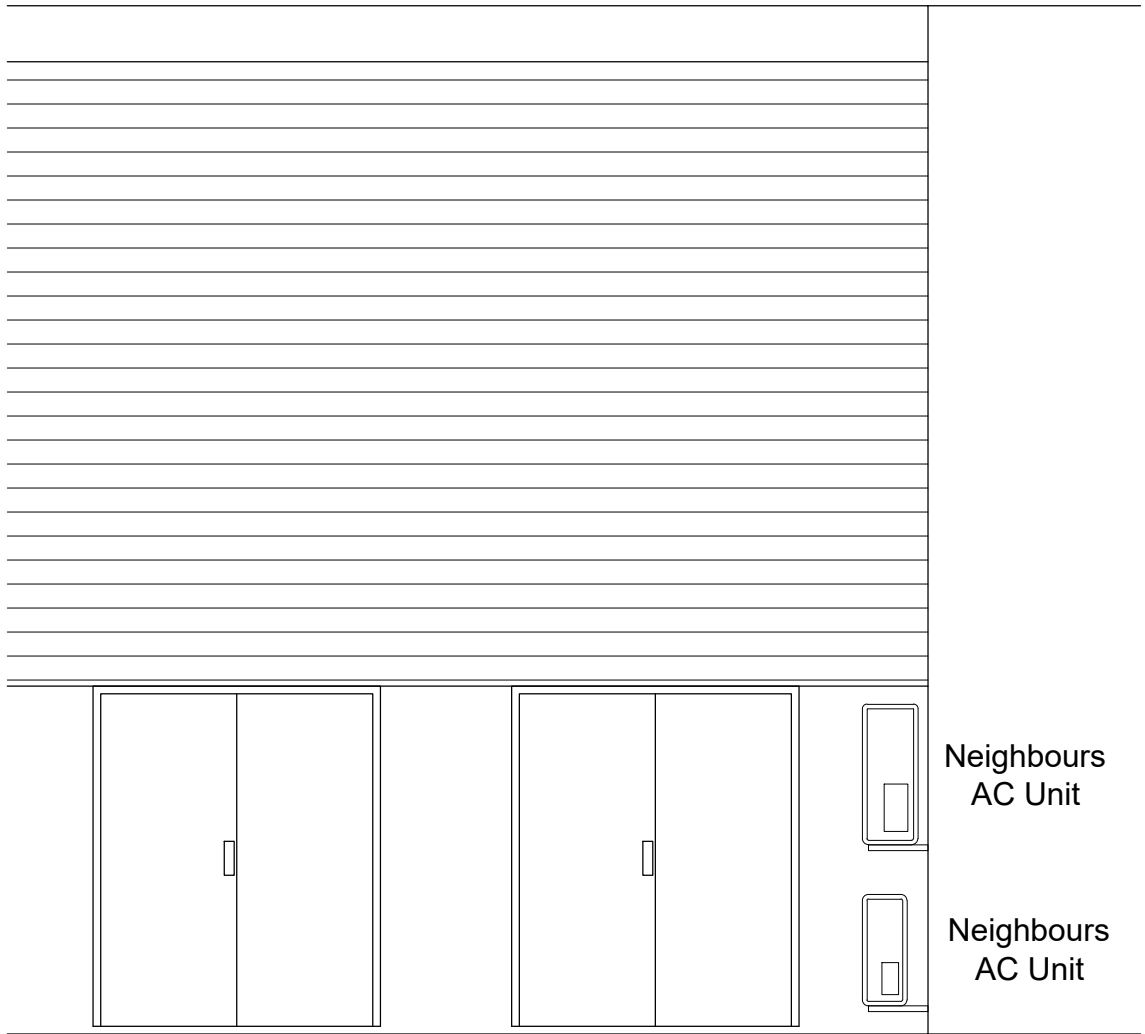

EXISTING REAR ELEVATION

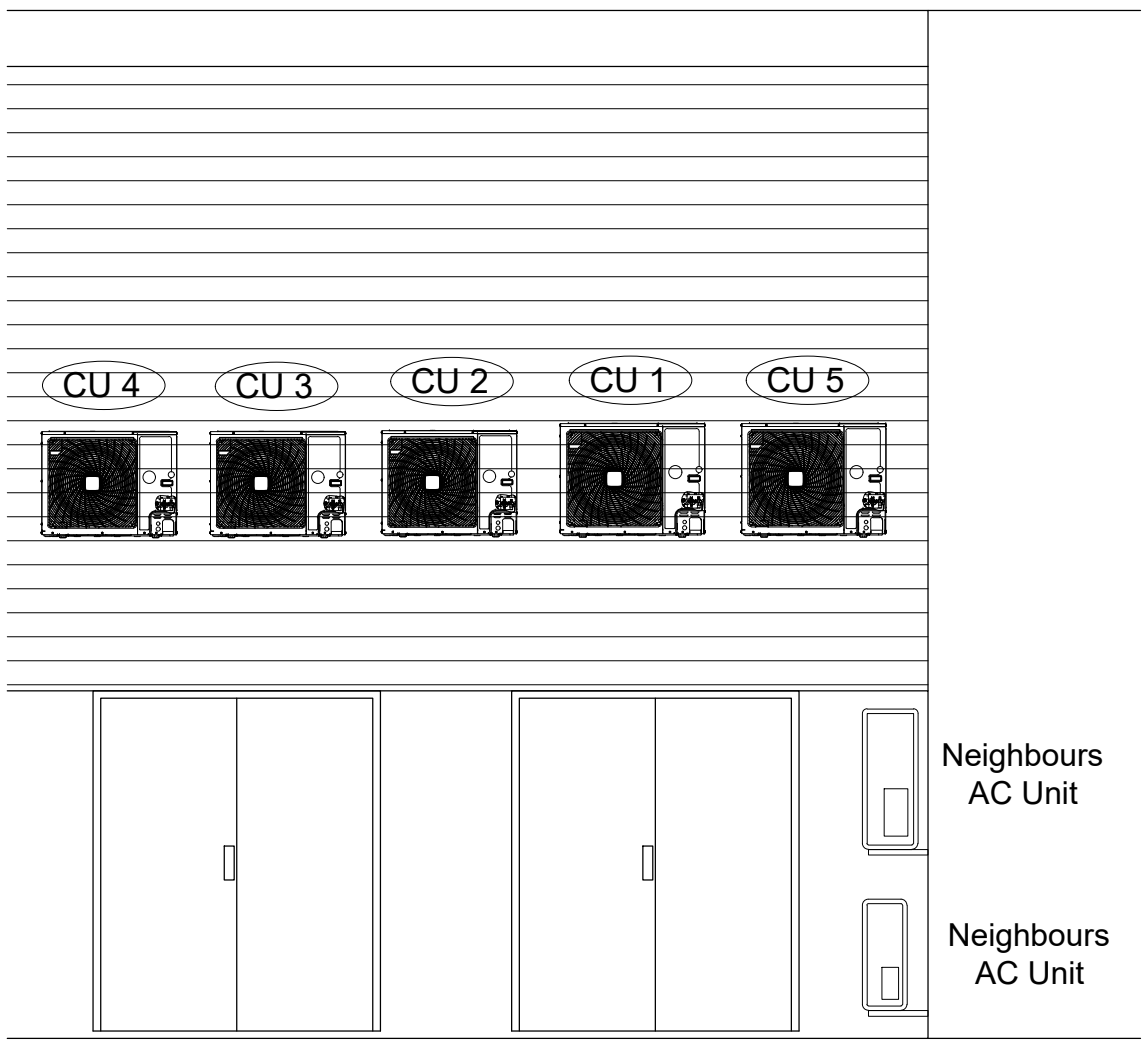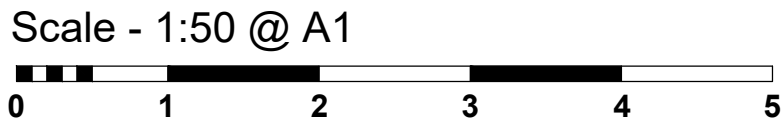

PROPOSED REAR ELEVATION

this drawing remains the property of fisch design limited and duplication of this drawing in whole or any part is strictly forbidden without prior written permission from fisch design ltd
all structural alterations are to be approved by a structural engineer

DWG NO: 2024-01	REVISION: -
CLIENT: Specsavers	
PROJECT: Lime Square, Unit 17-18 Ashton Old Road Openshaw M11 1DA	
TITLE: Existing & Proposed AC Elevations & Details	
ORIGIN: EB	CHECKED: MM
SCALE: 1:50@A1	DATE: 21.06.22
fisch STRUCTURED CREATIVITY	FISCH DESIGN LTD 1 HERITAGE BUSINESS CENTRE DERBY ROAD, BELPER DERBYSHIRE, DE56 1SW
+44 (0)1773 828222 / WWW.FISCHDESIGN.CO.UK / MAIL@FISCHDESIGN.CO.UK	