

HEALTH AND SAFETY INFORMATION
IN ADDITION TO THE HAZARDS/RISKS NORMALLY ASSOCIATED WITH THE TYPES OF WORK DETAILED ON THIS DRAWING, NOTE THE FOLLOWING CONSTRUCTION
NO ABNORMAL RESIDUAL RISKS IDENTIFIED AT THIS STAGE OF THE DESIGN
MAINTENANCE / CLEANING / OPERATION
NO ABNORMAL RESIDUAL RISKS IDENTIFIED AT THIS STAGE OF THE DESIGN
DECOMMISSIONING / DEMOLITION
NO ABNORMAL RESIDUAL RISKS IDENTIFIED AT THIS STAGE OF THE DESIGN

LEGEND	
SYMBOL	DESCRIPTION
	DA - NEW DISCHARGE / EXHAUST AIR DUCTWORK
	EA - NEW EXTRACT AIR DUCTWORK
	IA - NEW INTAKE AIR DUCTWORK
	SA - NEW SUPPLY AIR DUCTWORK
	REFRIGERANT PIPEWORK
	FIRE RATED DUCTWORK

This document and its contents are the property of the Purchaser/Employer and Crookes Walker Consulting. They may not be copied or reproduced in any way, in part or whole, without prior written approval of both parties. Visitors will read at their own risk. This drawing shall be read in conjunction with the CWC Mechanical and / or Electrical Specifications. DO NOT SCALE FROM THIS DRAWING


DRAWING BACKGROUNDS:

COMPANY	MODEL NAME
RDA	BNYM-RDA-XX-ZZ-M3-CA-000001 P2
TPB	BNYM-TPB-ZZ-ZZ-M3-AD-PR0001
BHE	NP4-BHE-04-XX-M3-S-0001
BIL	NP4-BIL-ZZ-ZZ-M3-Y-0001, Billington IFC Model S1 - For Coordination
SHF	NP4-SHF-ZZ-ZZ-M3-A-0001
TPB	UB881-TPB-ZZ-ZZ-M3-8B0001-S1-P2
GENERAL NOTES UB881-TPB-ZZ-ZZ-M3-PR0001 T3	

- THIS DRAWING IS TO BE READ IN CONJUNCTION WITH THE COMPLETE RIBA STAGE 4 DOCUMENTATION PROVIDED BY THE ARCHITECTURAL AND ENGINEERING DESIGN TEAMS.
- THIS DRAWING PORTRAYS THE RIBA STAGE 4 DESIGN PROPOSALS AND IS NOT A CONSTRUCTION OR INSTALLATION DRAWING. ALL INSTALLATION ARE SUBJECT TO FINAL SPATIAL AND SITE COORDINATION.
- THE CONTRACTOR SHALL REMAIN RESPONSIBLE FOR CHECKING ALL DIMENSIONS AND LEVELS ON SITE PRIOR TO THE COMPLETION OF THE INSTALLATION DRAWINGS, PLACING ORDERS FOR MATERIALS, SERVICES AND BEFORE COMMENCING ANY MANUFACTURE / FIXINGS.
- AGREE ALL EQUIPMENT SETTING OUT WITH THE CLIENT TEAM PRIOR TO CONSTRUCTION.

DRAWING SPECIFIC NOTES:

- ALL REFRIGERATION PIPEWORK IS TO BE THERMALLY INSULATED AND LOCATED ON GALVANISED CABLE TRAY UNLESS OTHERWISE AGREED.
- DRAWING TO BE UPDATED ONCE FINAL ARCHITECTURAL RCPs HAVE BEEN PROVIDED/INSTRUCTED.

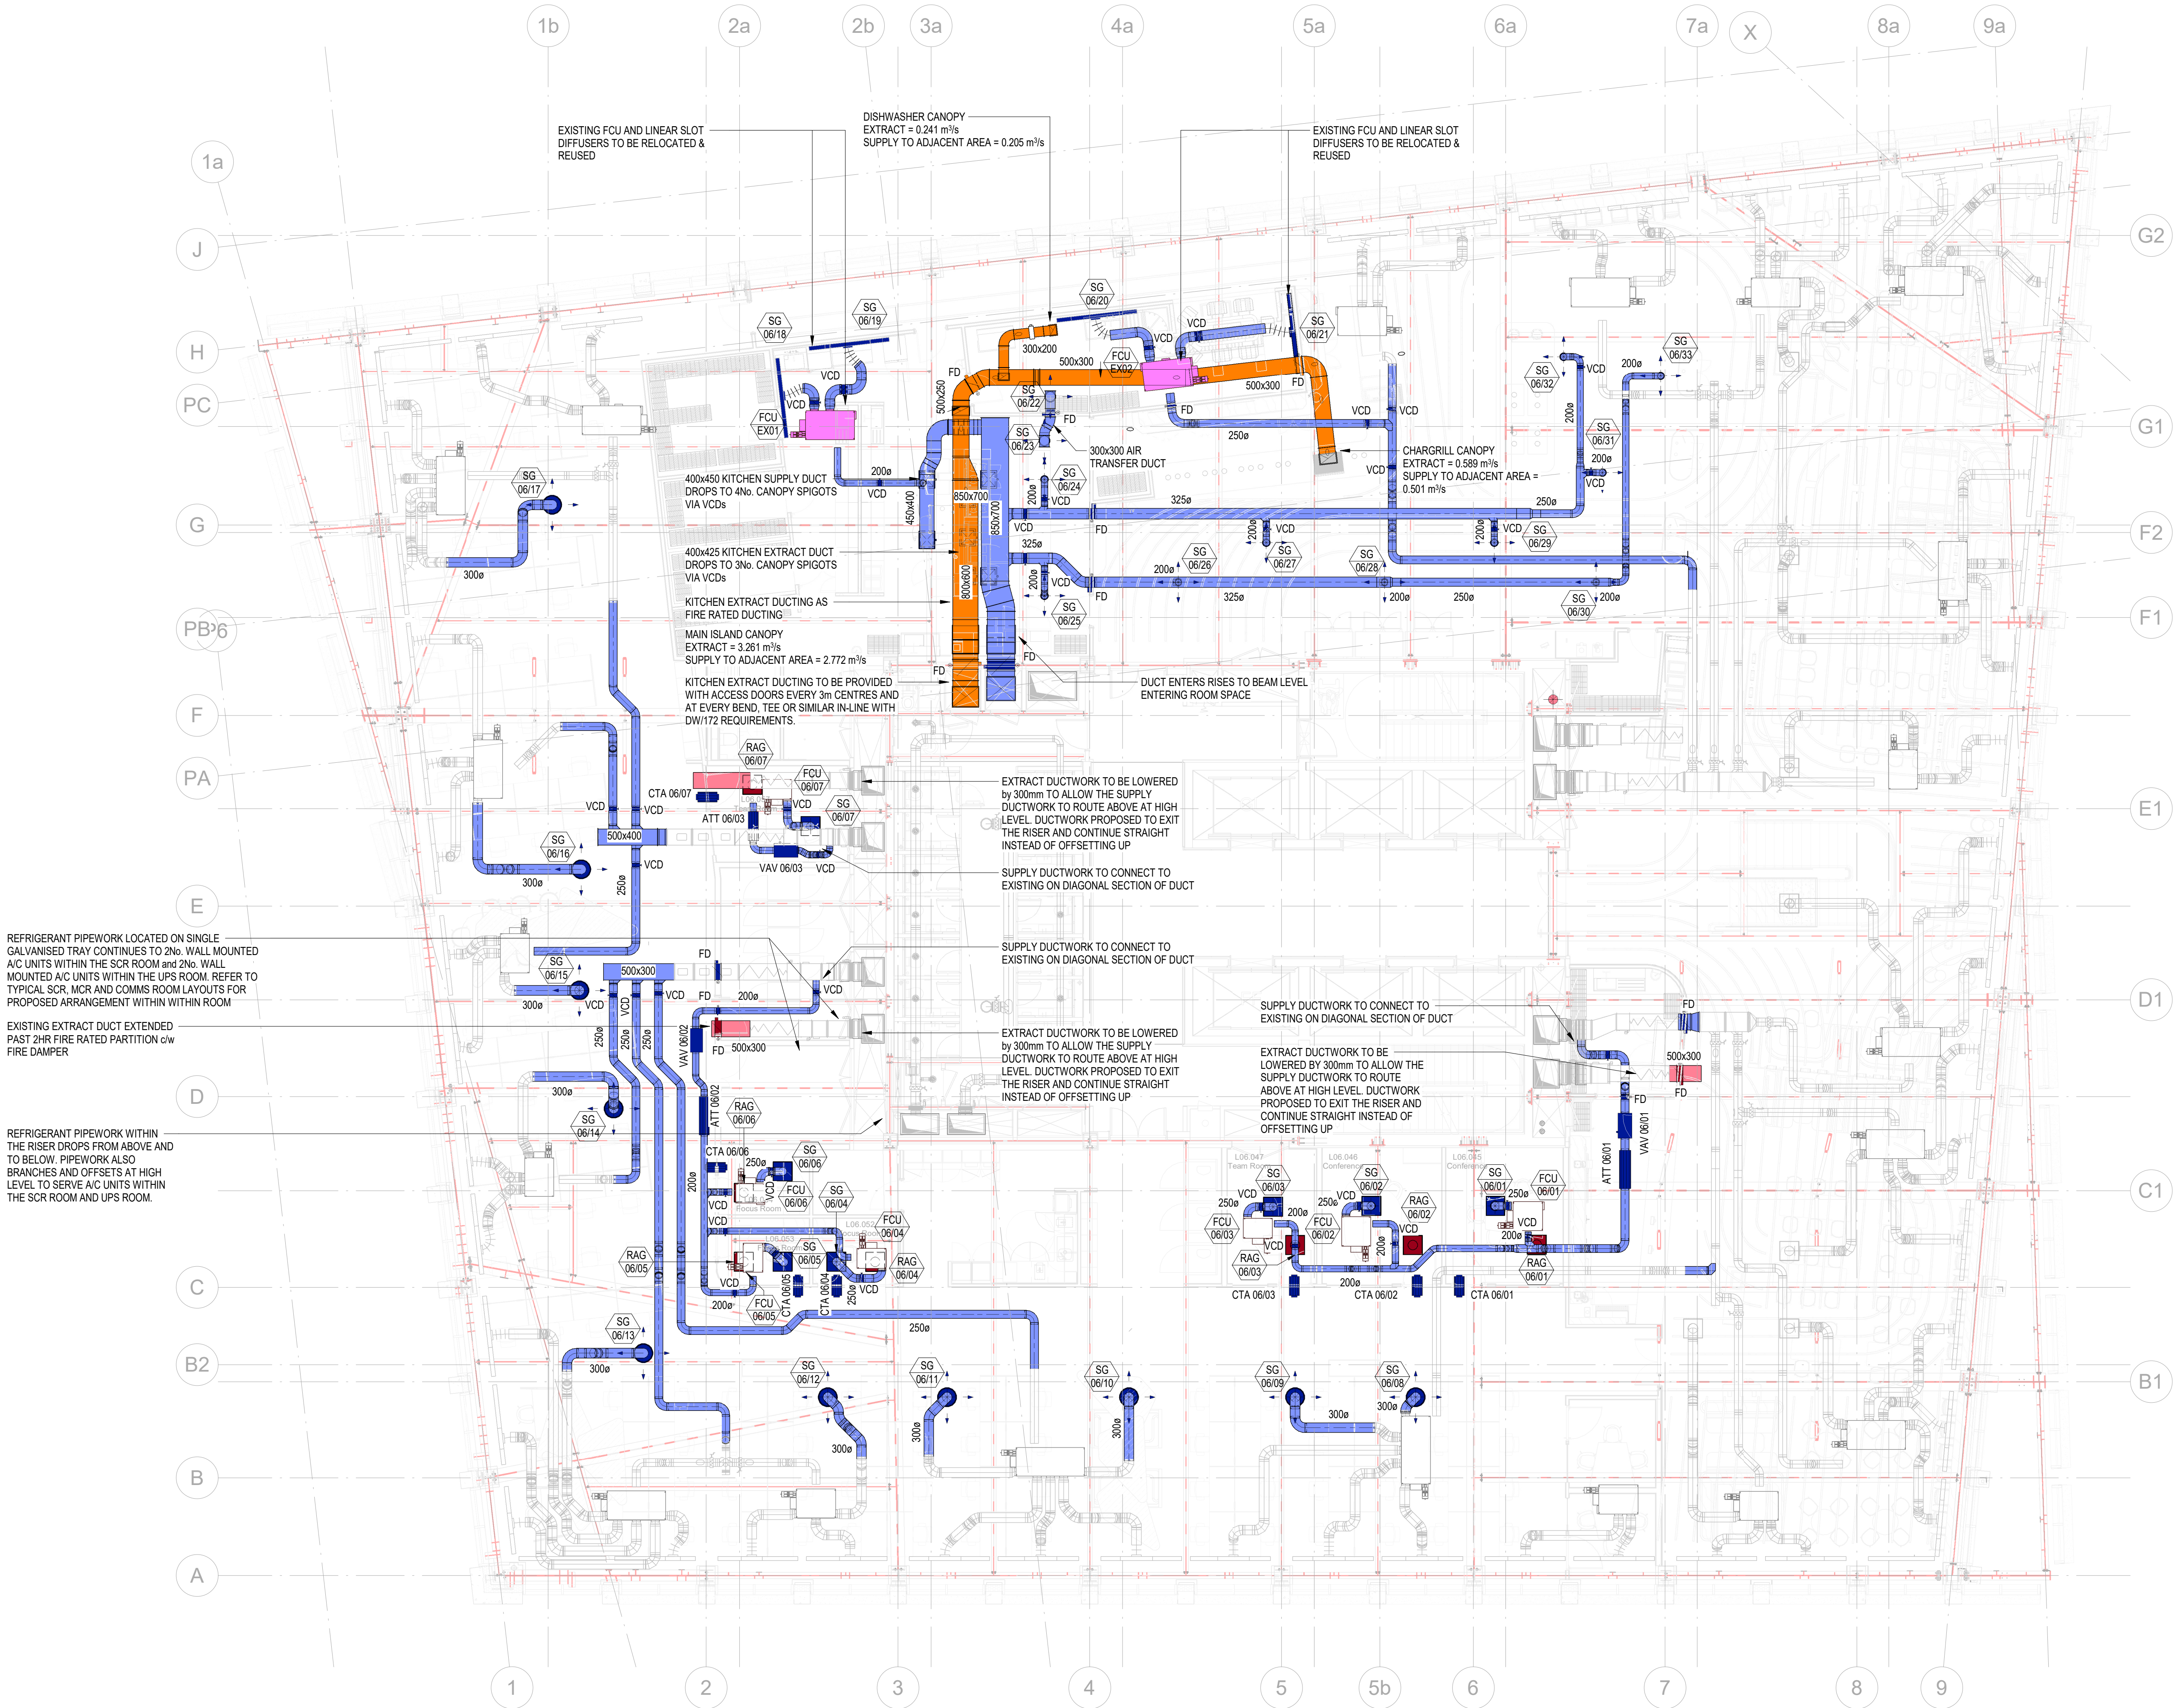

P01	31.08.25	ISSUED FOR COMMENT	RB	JB
Rev	Date	Description	Eng	Chk

CWC
crookes walker consulting

Suite 5a, Bldg. 17 Maritime Street
Manchester M2 5AW
Tel: 0161 834 9899
The Plaza, Old Hall Street,
Liverpool L3 9QU
Tel: 0151 600 5400
E-mail: admin@cwcon.co.uk
Website: www.cwcon.co.uk

Client

BNY overbury

Project
4 ANGEL SQUARE

Drawing Title
**LEVEL 06
VENTILATION LAYOUT**

Status
PRELIMINARY

Project No. 3594	Drawn RVB	Scale / Paper Size 1 : 100 @ A0	Rev P01
---------------------	--------------	------------------------------------	------------