




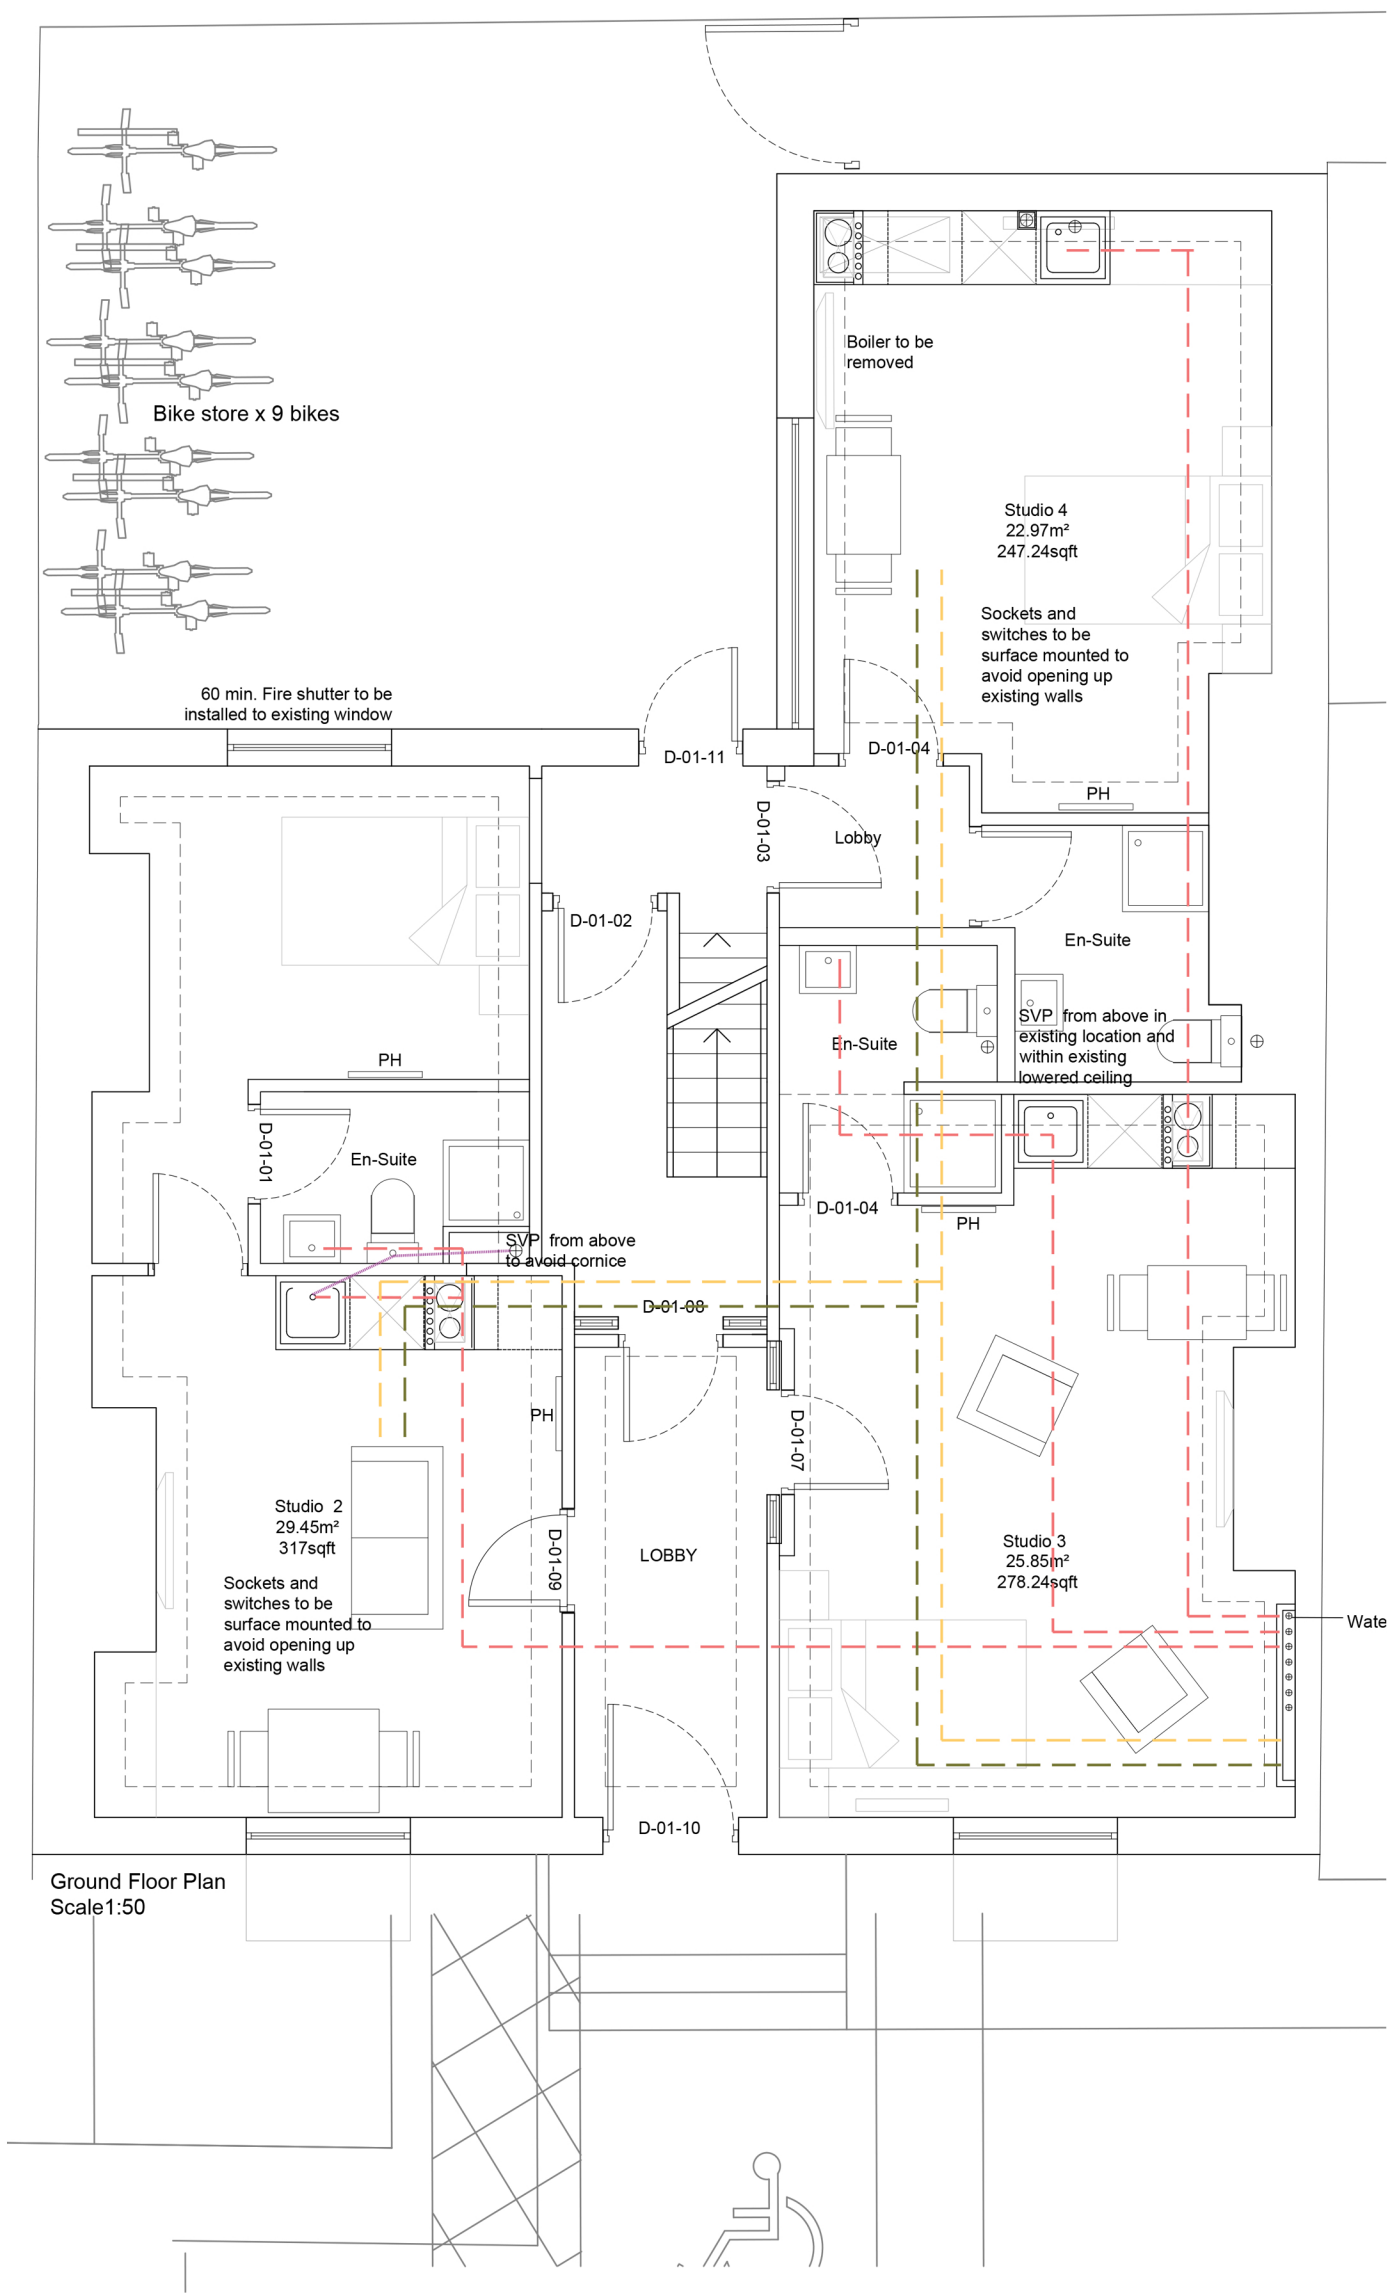


Ground Floor Plan
Scale 1:50

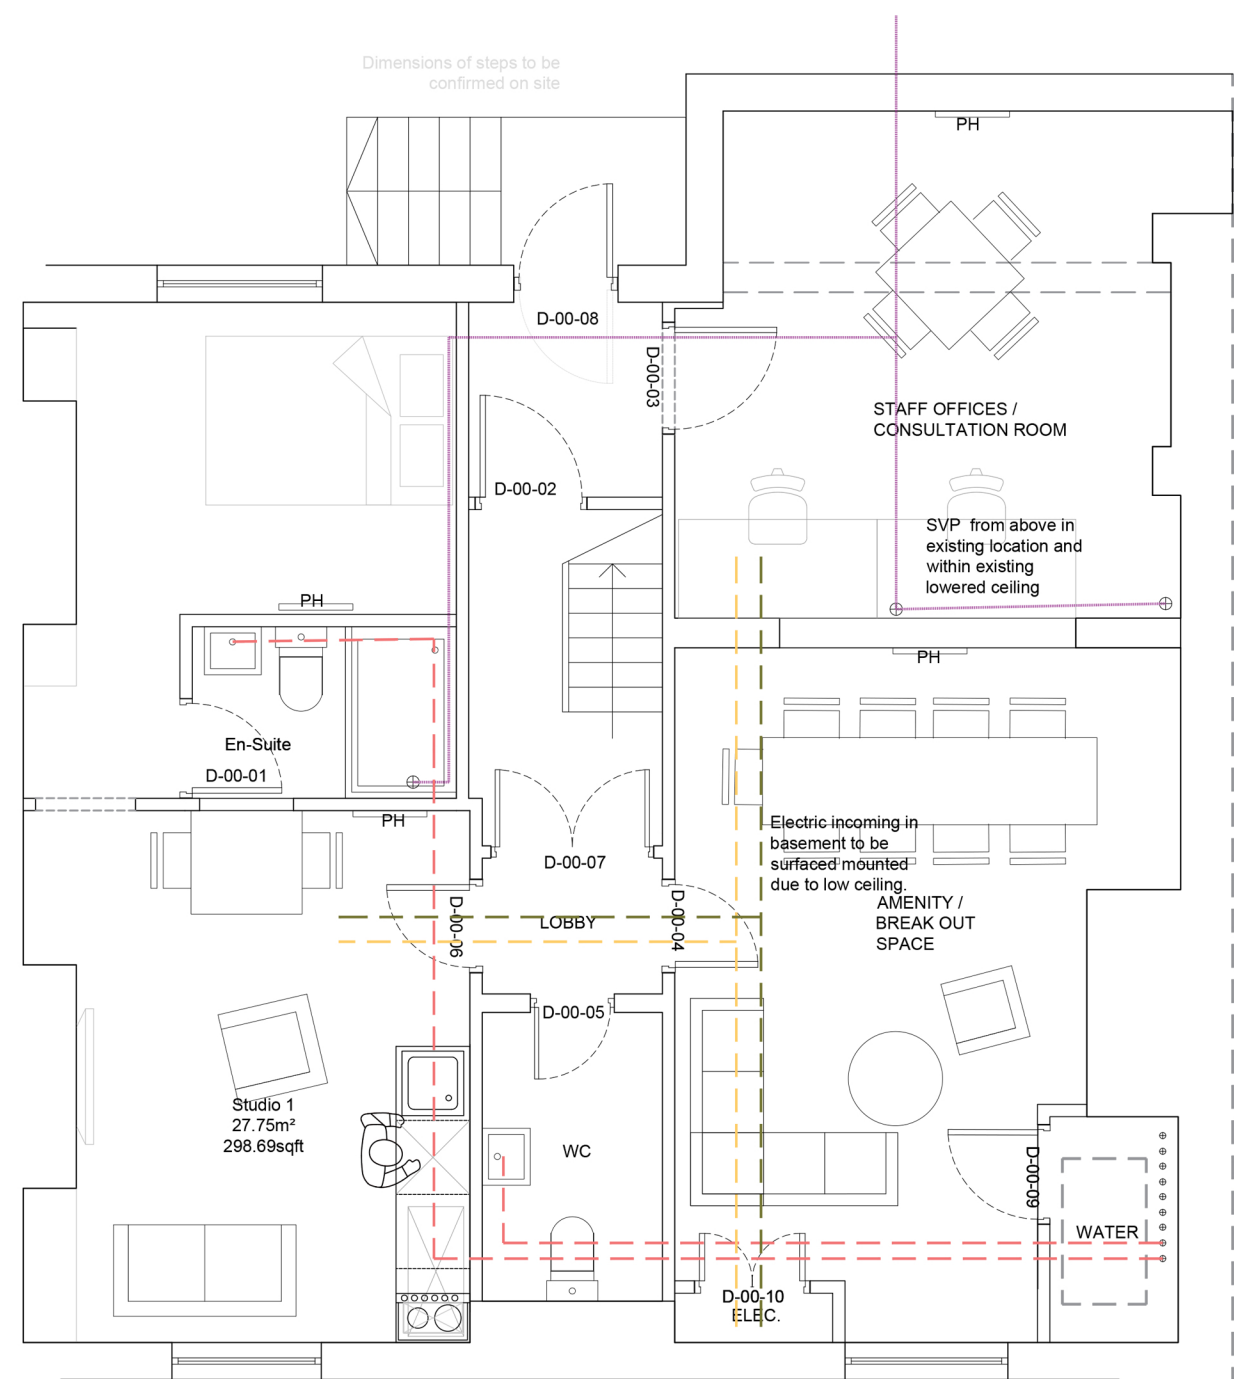

Basement Plan
Scale @ 1:50

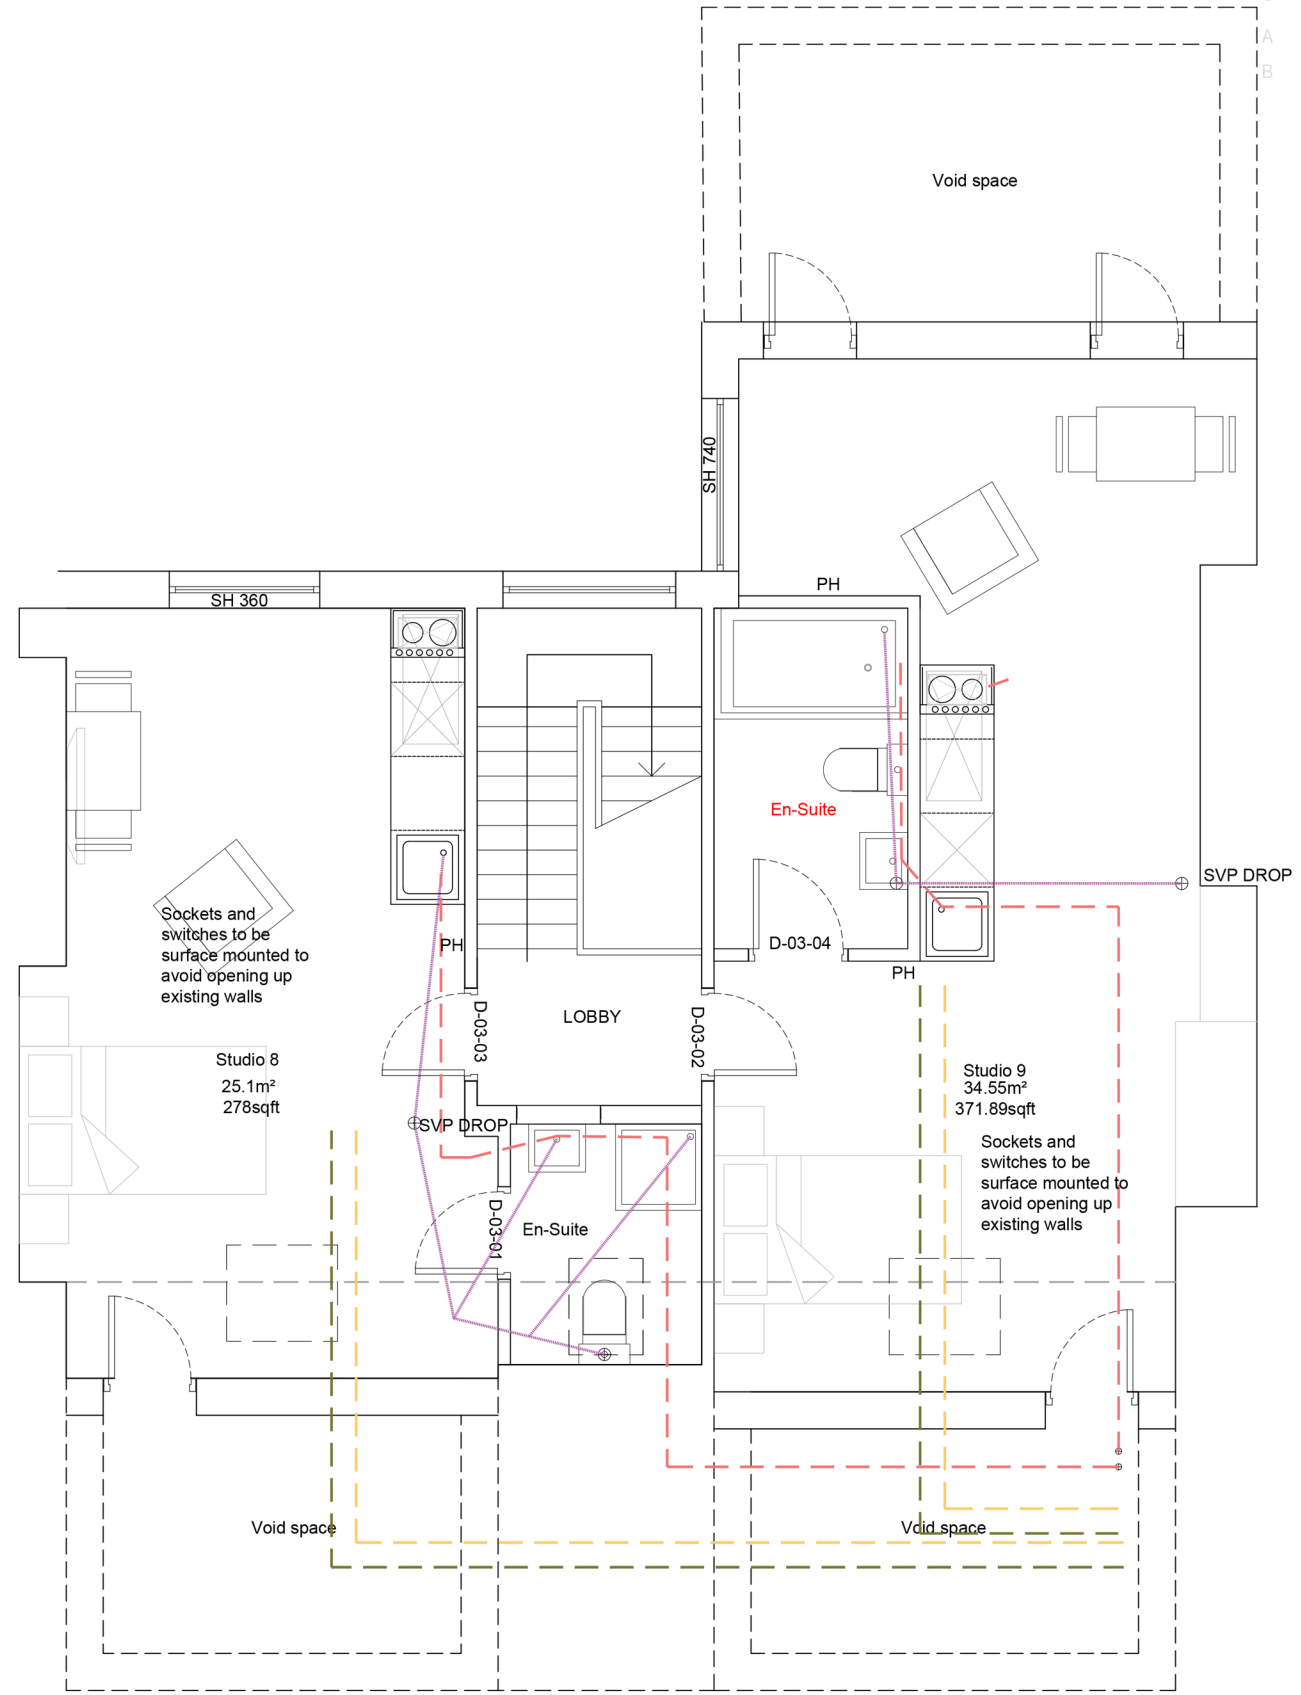


Second Floor Plan
Scale 1:50

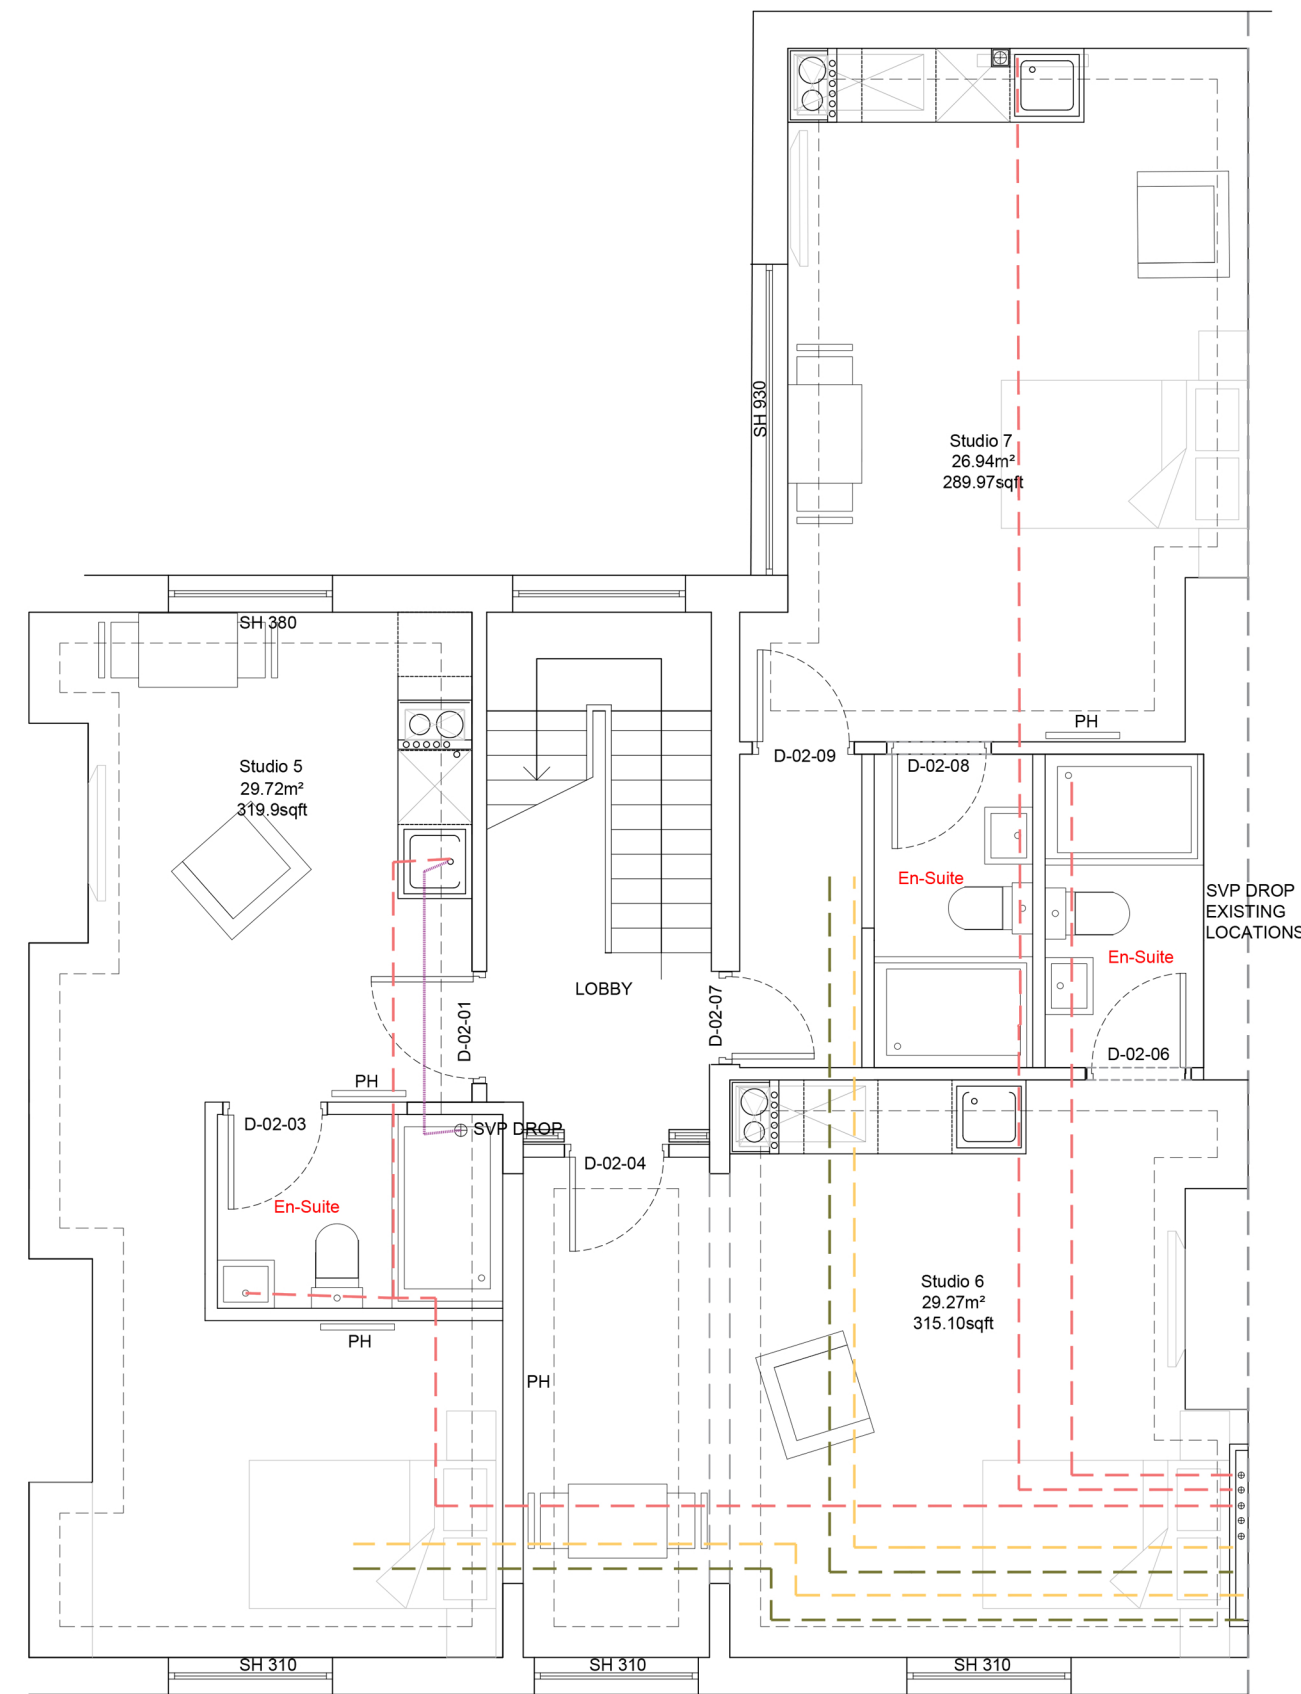

First Floor Plan
Scale 1:50

NB			Do not scale off this drawing. All dimensions to be checked on site prior to manufacture and construction. This drawing is the property of JH Architects and should not be reproduced without permission. All discrepancies to be brought to the attention of the architect immediately. This drawing to be read in conjunction with the specification / bill of quantities and related drawings.
REVISION			
FIRST ISSUE	24.02.26	JG	
Updated drawing number and note	03.03.26	JG	
Planning Issue - P	05.03.26	JG	

- ⊕ 100mm SVP location to floor below
- 100mm SVP run in false floor
- Hot Water Supply
- ELV Cable Routes
- LV Cable Routes
- Line of Cornice above

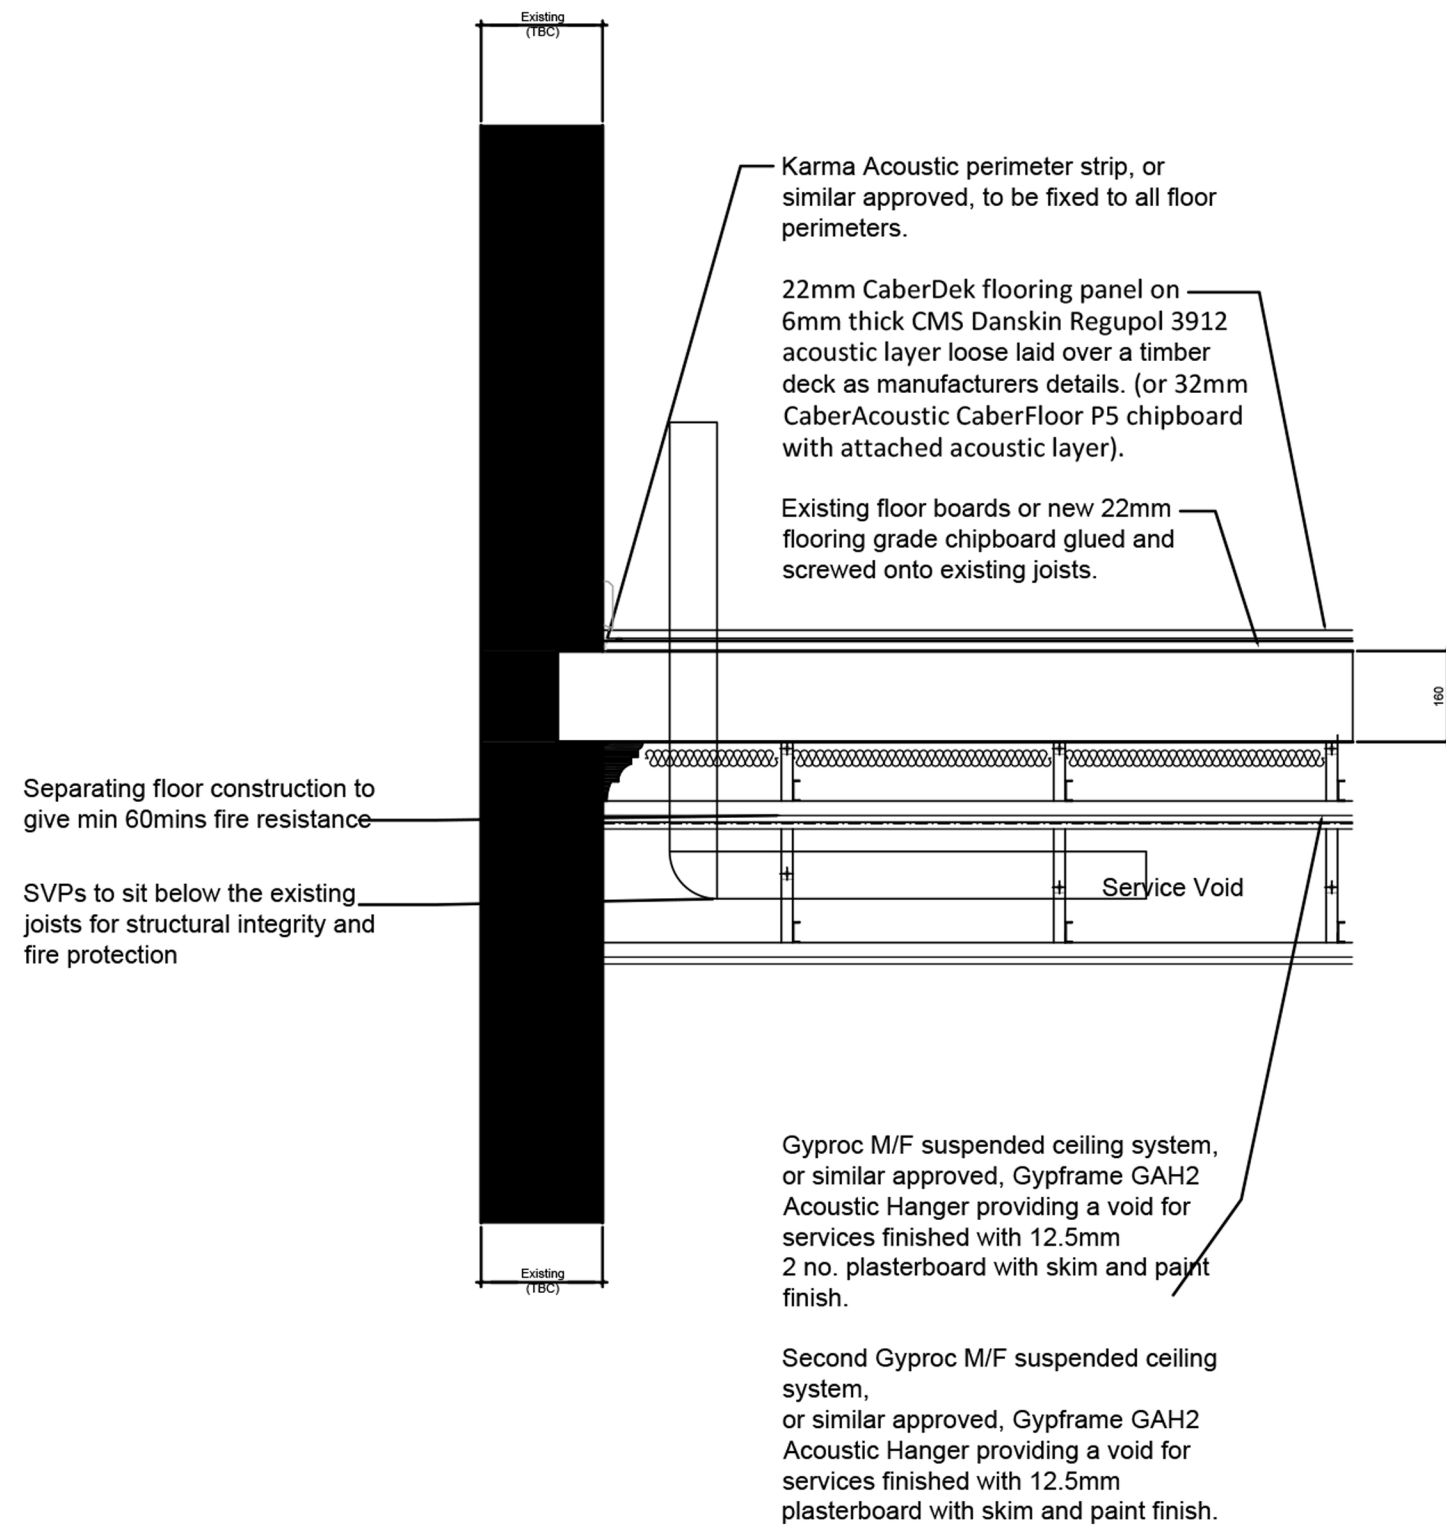

Copyright : AGH Electrical Limited	
Standard Notes	
1.00	DO NOT SCALE. THIS DRAWING. WORK TO DIMENSIONS GIVEN.
2.00	ALL DIMENSIONS TO BE VERIFIED FROM SITE MEASUREMENT.

JH.A

RIBA
Chartered Practice

arb

Architects
Registration
Board

Rev.	Date	Description	By	Ch.k
Drawing Status: Planning				
<div><div>A.G.H electrical</div><div>Suite 214 Miller House 47-49 Market St Farnworth Bolton BL47NS Email: enquiries@aghelectrical.com</div></div>				
Client: AEDI				
Project: Mannor St				
Drawing Title: MEP Service Routes REV B				
Drg No.			Revision: -	
Scale: 1-50	Date	Engineer	Checked	