



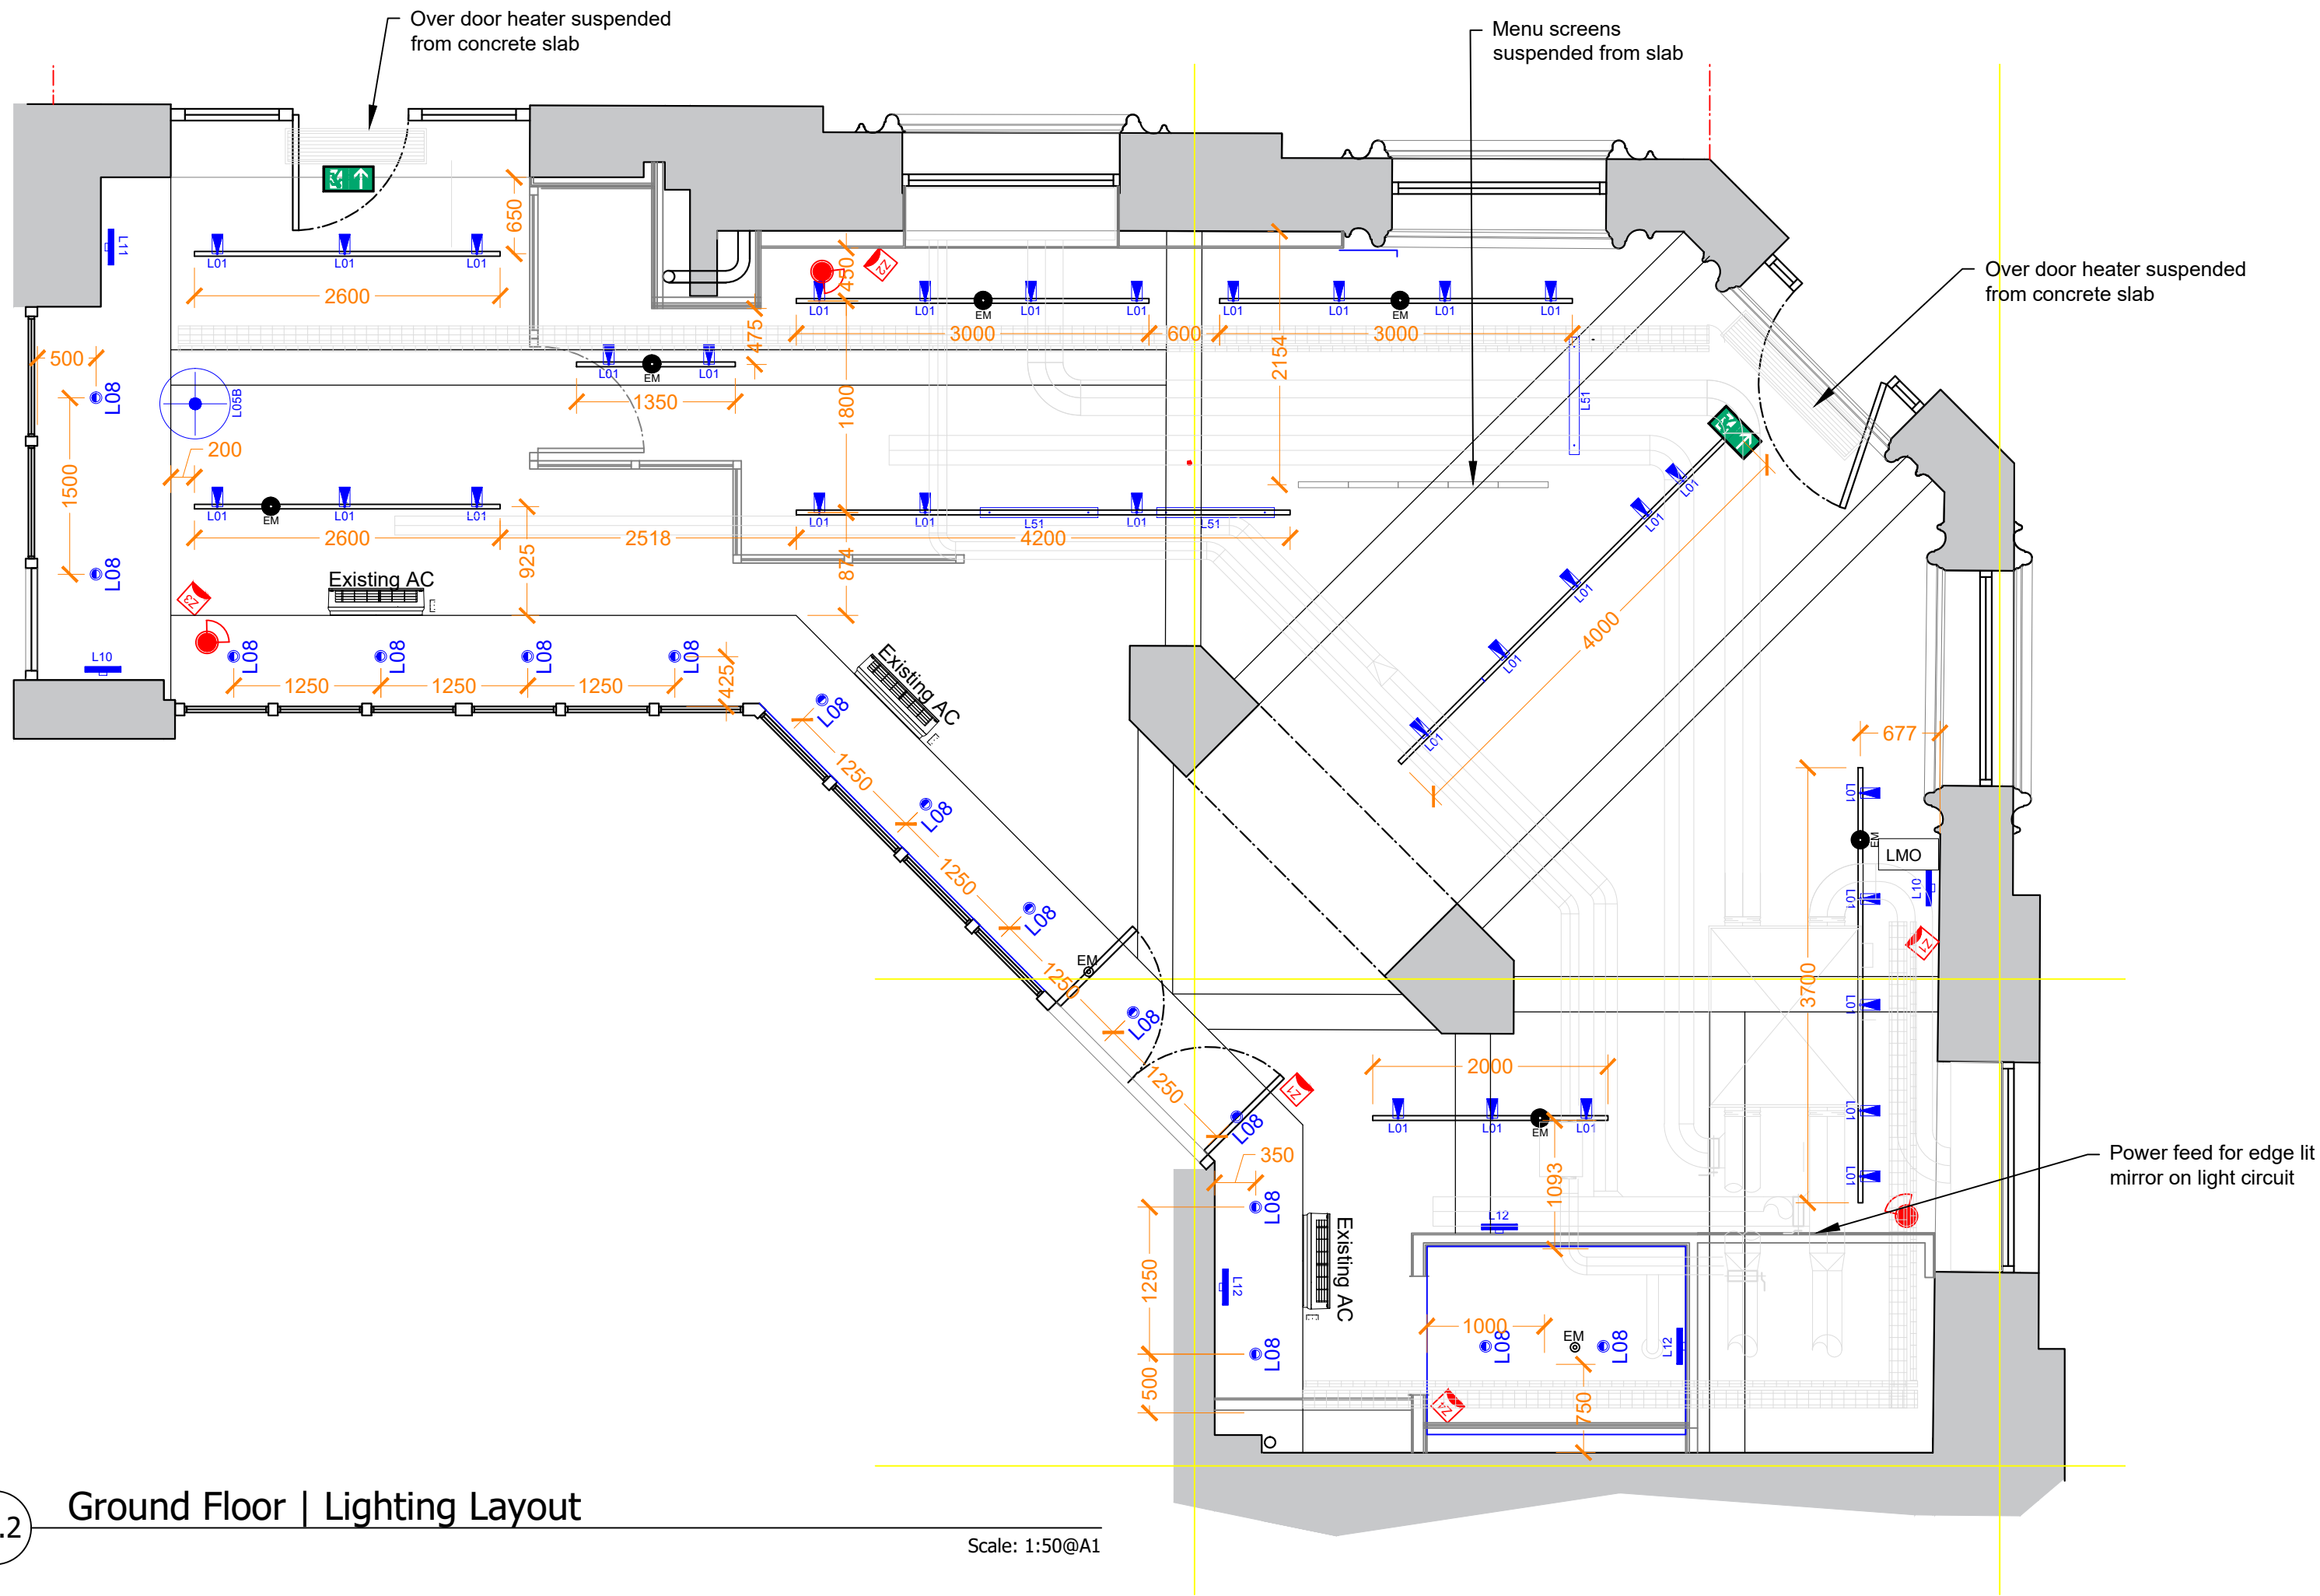

03.2 Ground Floor | Lighting Layout

Scale: 1:50@A1

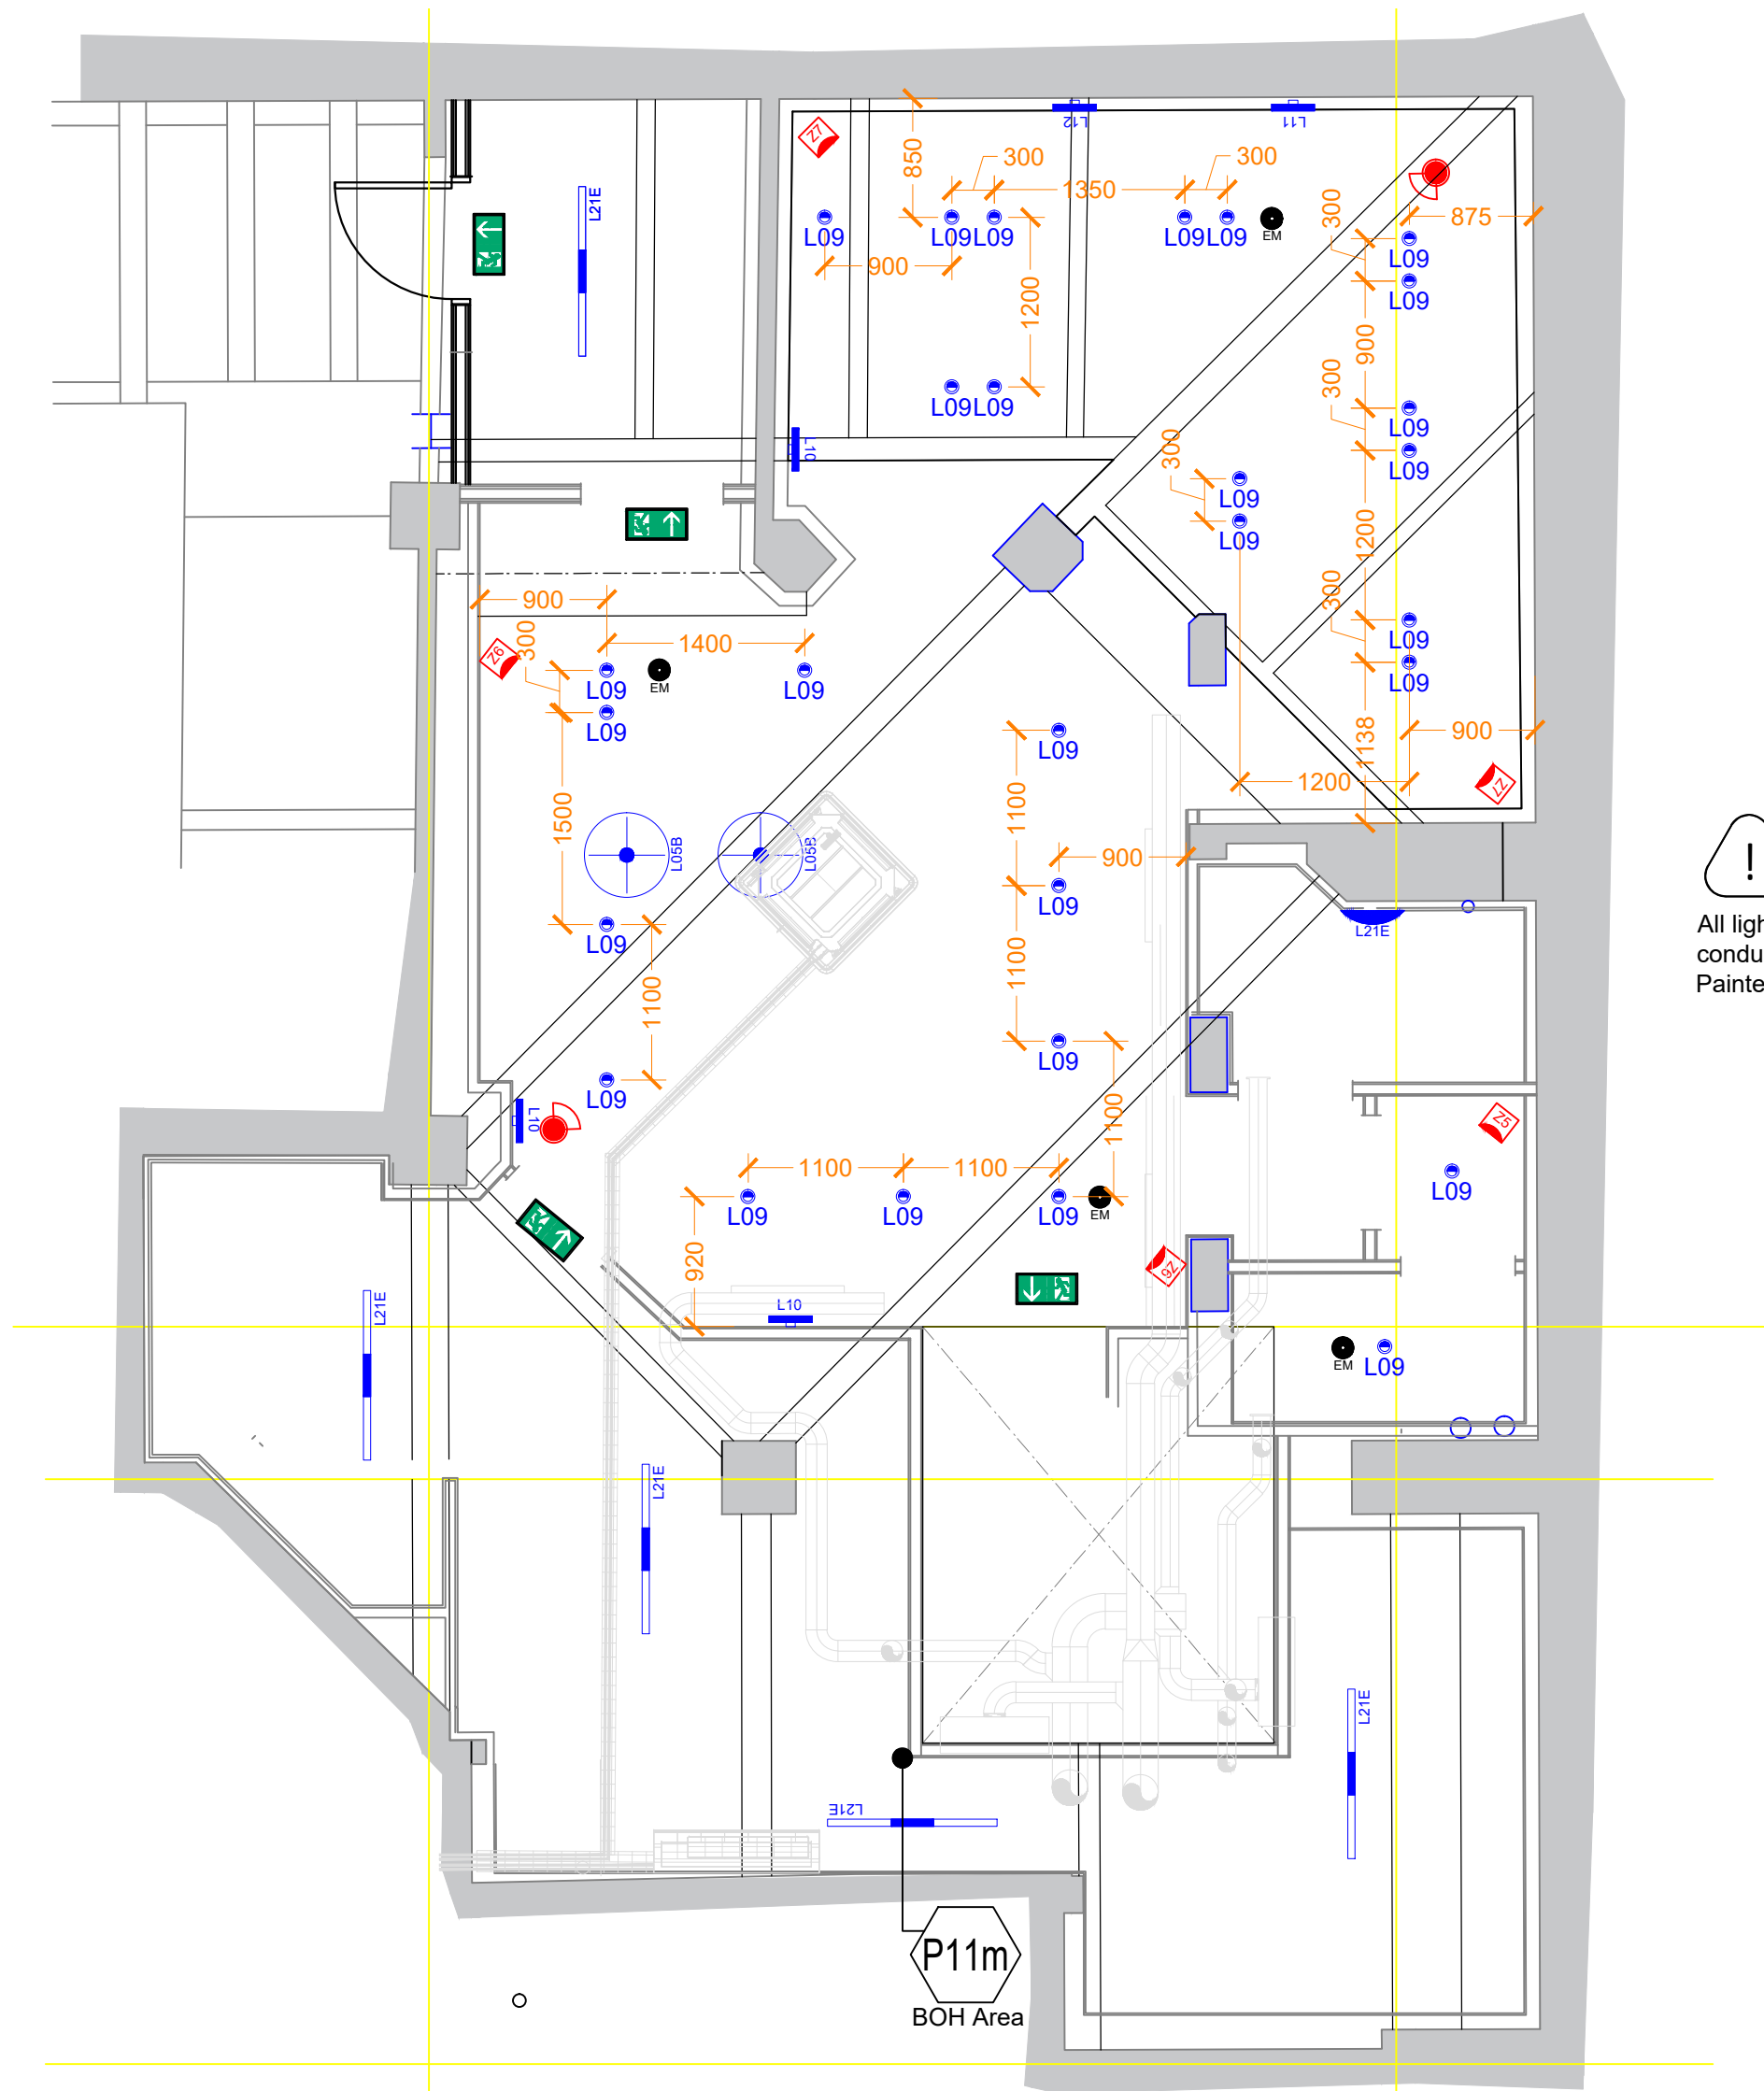

All light fittings to be fed with surface mounted conduits to underside of ceilings
Painted out match ceiling

03.2 Basement | Lighting Layout

Scale: 1:50@A1

Symbol	Ref	Description	Mounting	Manufacturer / Ref	Size	Colour	Lamp	Dimmable	Wattage	Beam	Lumens	CRI	CCT	IP Rating	Weight	
	L01	LED Spotlight	Track	Illuma Concepta		WHITE	LED	Yes	18w	36-38° (Medium)		90	3000K			
	L09	LED Spotlight	Surface	Illuma Lumapar		WHITE	LED	Yes	18w	36-38° (Medium)	71 lm/W	90	3000K	IP20	0.3 kg	
	L08	LED Spotlight	Recessed	Illuma Infina		WHITE	LED	Yes	18w	36° (Medium)		90	3000K			Remote Driver
	L10	Wall Light	Surface	Sasi Small by Nuura	155mm x 290mm	Silver	LED	Yes	11w	n/a	600	90	3000k		0.54 Kg	
	L11	Wall Light	Surface	Liila Medium by Nuura	Ø165 mm x 170mm	Light Silver / Opal	G9	Yes	17w	n/a	600	90	3000k		0.54 Kg	
	L12	Wall Light	Surface	Picture Light TBC	605mm x 200mm	Brass	G9	Yes	28w		450		2700K		1.6 kg	
	L50	Pendant	Suspended	Vuelta Pendant 100	1000mm x 84mm	Opal / Brass	LED	Yes	30w	-	2400	90	3000K		3kg	
	L05A	Pendant	Suspended	Strand Ø45cm Closed by Muuto	Ø45cm x 35.4mm (H)	White	LED									
	L05B	Pendant	Suspended	Strand Ø60cm Closed by Muuto	Ø60cm x 54.8mm (H)	White	LED									
	L05C	Pendant	Suspended	Strand Ø80cm Closed by Muuto	Ø80cm x 60.8mm (H)	White	LED									
	EM1	Emergency Light	Track	Illuma Emlux Duo	150 x 40	WHITE	LED	n/a	1.5 w	125°	150	-	-	IP20	2.6kg	Intergal 3hr Non-maintained battery & driver
	EM2	Emergency Light	Recessed	Illuma Emlux Discrete	Ø45mm x 24.7mm	WHITE	LED	n/a	1w	125°	150		4000K	IP20	0.15 kg	Intergal 3hr Non-maintained battery & driver
	EM3	Emergency Light	Surface	Illuma Emlux Duo	150 x 40	WHITE	LED	n/a	1.5 w	125°	150	-	-	IP20	2.6kg	Intergal 3hr Non-maintained battery & driver
	ES1	EM Exit Sign	Surface	Illuma Emlux Surface	340 x 246	WHITE	LED	No	2w			70	5700K	IP20	0.9kg	Intergal 3hr Non-maintained battery & driver
	ES2	EM Exit Sign	Track Mounted	Illuma Emlux Blade	340 x 246	WHITE	LED	No	2w			70	5700K	IP20	0.9kg	Intergal 3hr Non-maintained battery & driver
Symbol	Ref	Description	Mounting	Manufacturer / Ref	Size	Colour	Lamp	Dimmable	Wattage	Beam	Lumens	CRI	CCT	IP Rating	Weight	
	L21	LED Batten	Suspended	Contractor Choice	2ft / 600mm	White	LED	No	17w	110°	2040		3000K	IP20	0.75kg	
	L21E	LED Batten w/ EM pack	Suspended	Contractor Choice	2ft / 600mm	White	LED	No	17w	110°	2040		3000K	IP20	0.75kg	Intergal 3hr Non-maintained battery & driver
	L21	Bulkhead Light	Wall Mounted	Contractors Choice	330 x 110	White	LED	No	12w		1050	70	4000K	IP65	1.2 kg	
	L21E	Bulkhead Light w/ EM pack	Wall Mounted	Contractors Choice	330 x 110	White	LED	No	12w		1050	70	4000K	IP65	1.2 kg	Intergal 3hr Non-maintained battery & driver

Lighting Controls

Store Room
Controlled via PIR sensor . (contractor to position)

Cold / Freezer Room
Local Controls by supplier

Window bed & Internal signage
Controlled via dedicated timeclock

External Signage
Controlled via dedicated timeclock

Track mounted including WC
Controlled via last man out
All on dimmer circuit
Track spot light on circuit 1
Pendant lighting on circuit 2

Wall Lights
Wall light on dimmer circuit controlled via last man out switch

Table Lights
Controlled via last man out switch

LMO

Last Man Out Switch (Fish tail key type)
Black Satin finish to sales area / White elsewhere

REVISION	DATE	DETAILS
PROJECT		
Unit 3 Sunlight House Manchester		
FLOOR		
Basement & Ground Floor		
DRAWING TITLE		
Lighting Layout		
SCALE 1:50	PAPER SIZE A1	REVISION C
DRAWING NUMBER 7063-03.2	DATE 27.11.25	
DRAWN BY SE	STATUS	
L1		
ad@adesigntime.com www.adesigntime.uk.com		
2-Work, 7-Cutter Mill Treyard North WF1 5PT		