


GROSVENOR | 4TH FLOOR SHIP CANAL HOUSE, MANCHESTER


CEILING LAYOUT

This drawing is the property of Bluesky Design Interiors Limited and must not be copied or otherwise reproduced. All dimensions must be checked on site before commencing work. This drawing was produced using AutoCAD 2025.


FEATURE LIGHTING

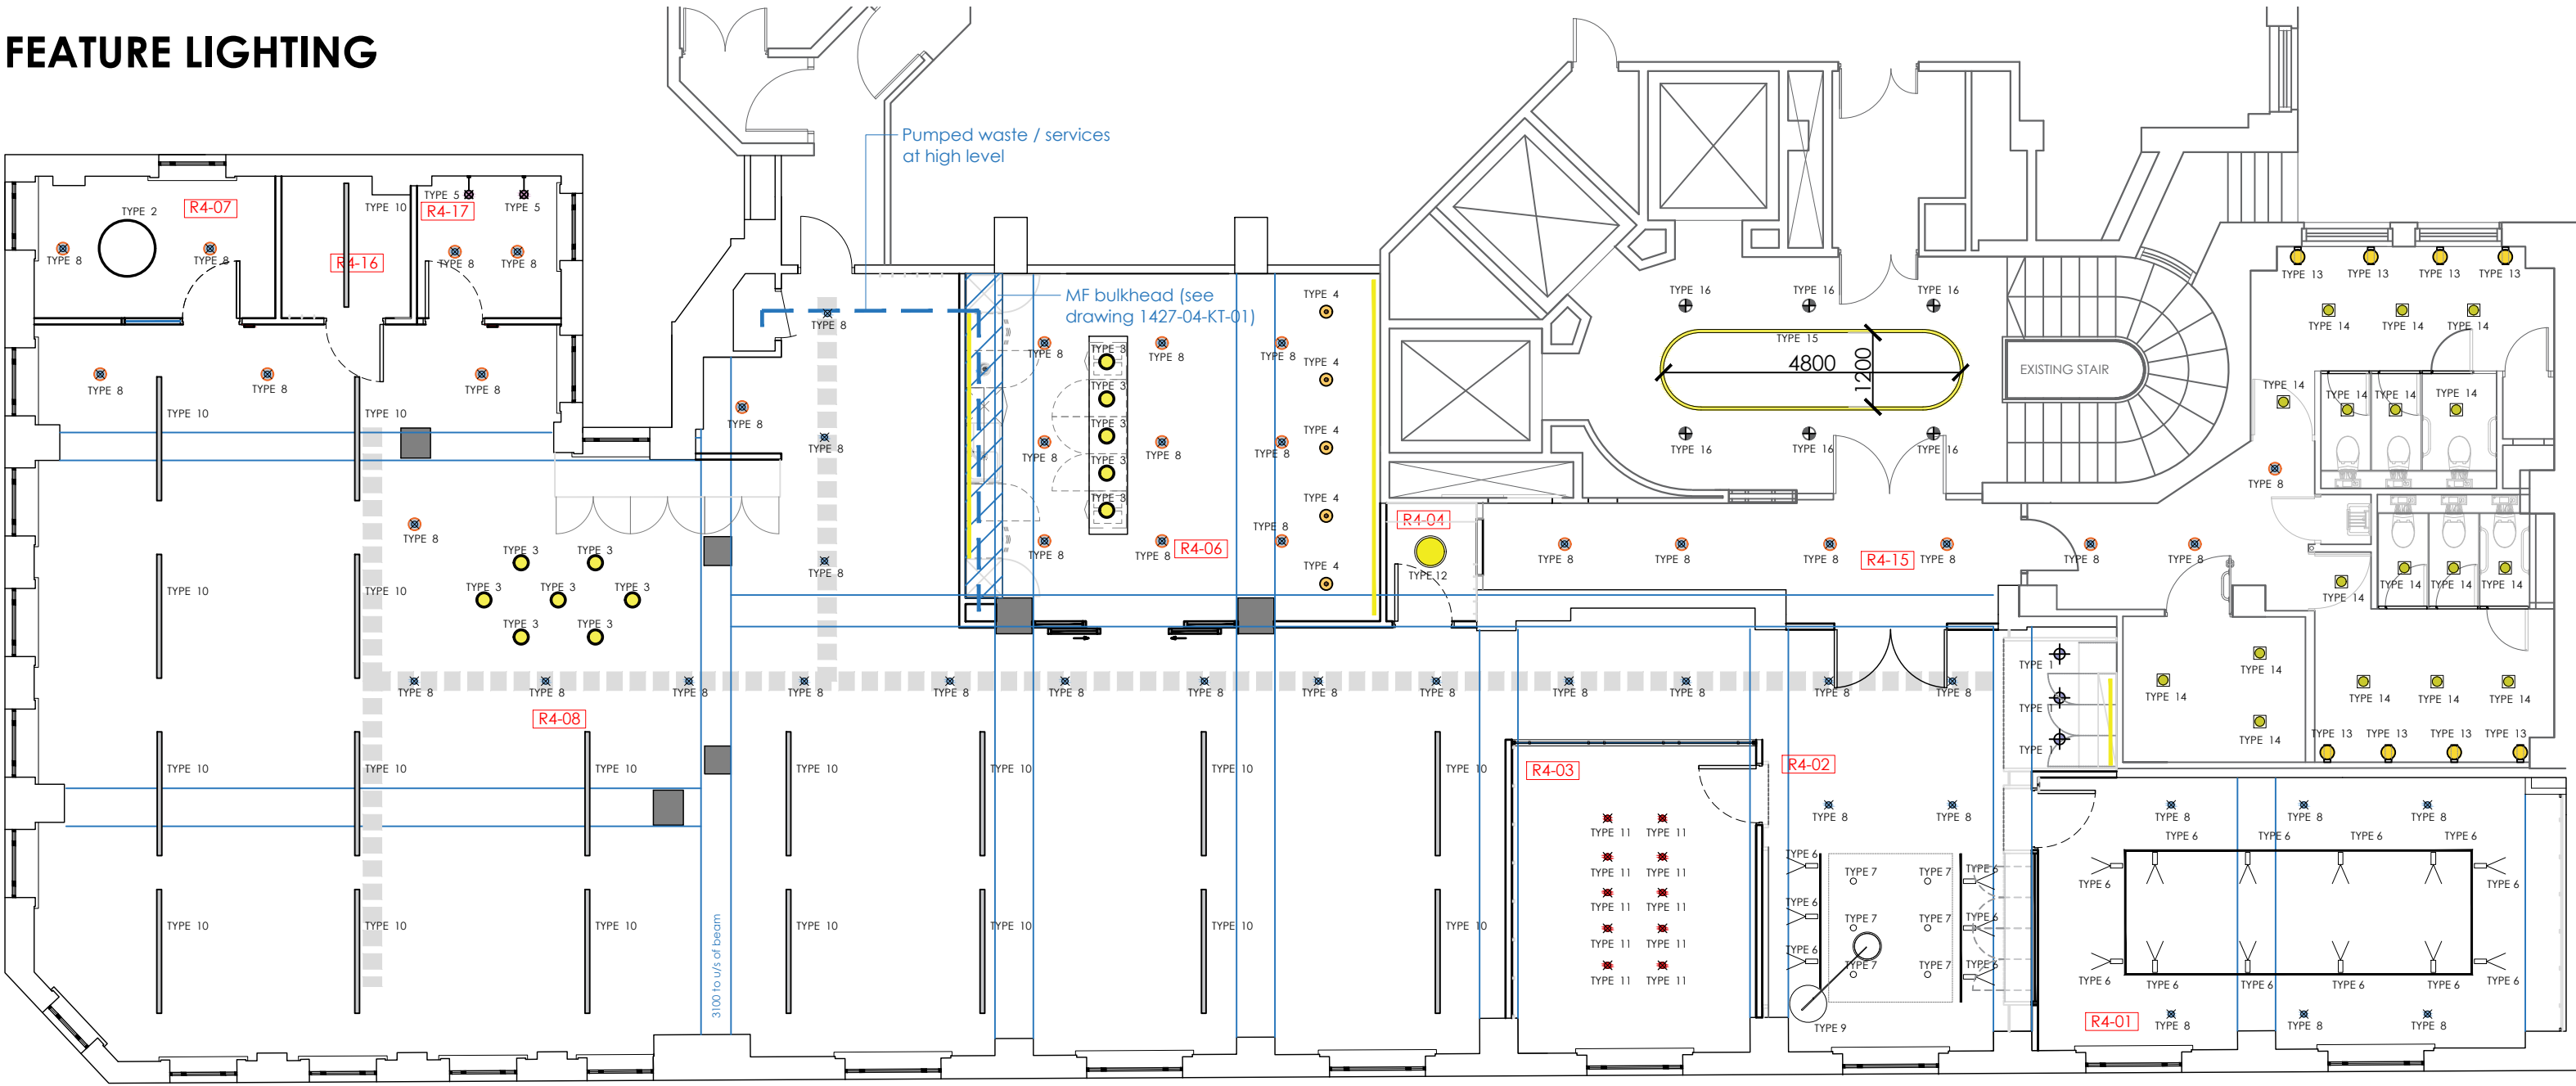


FEATURE CEILINGS / ACOUSTIC TREATMENTS / M&E COORDINATION

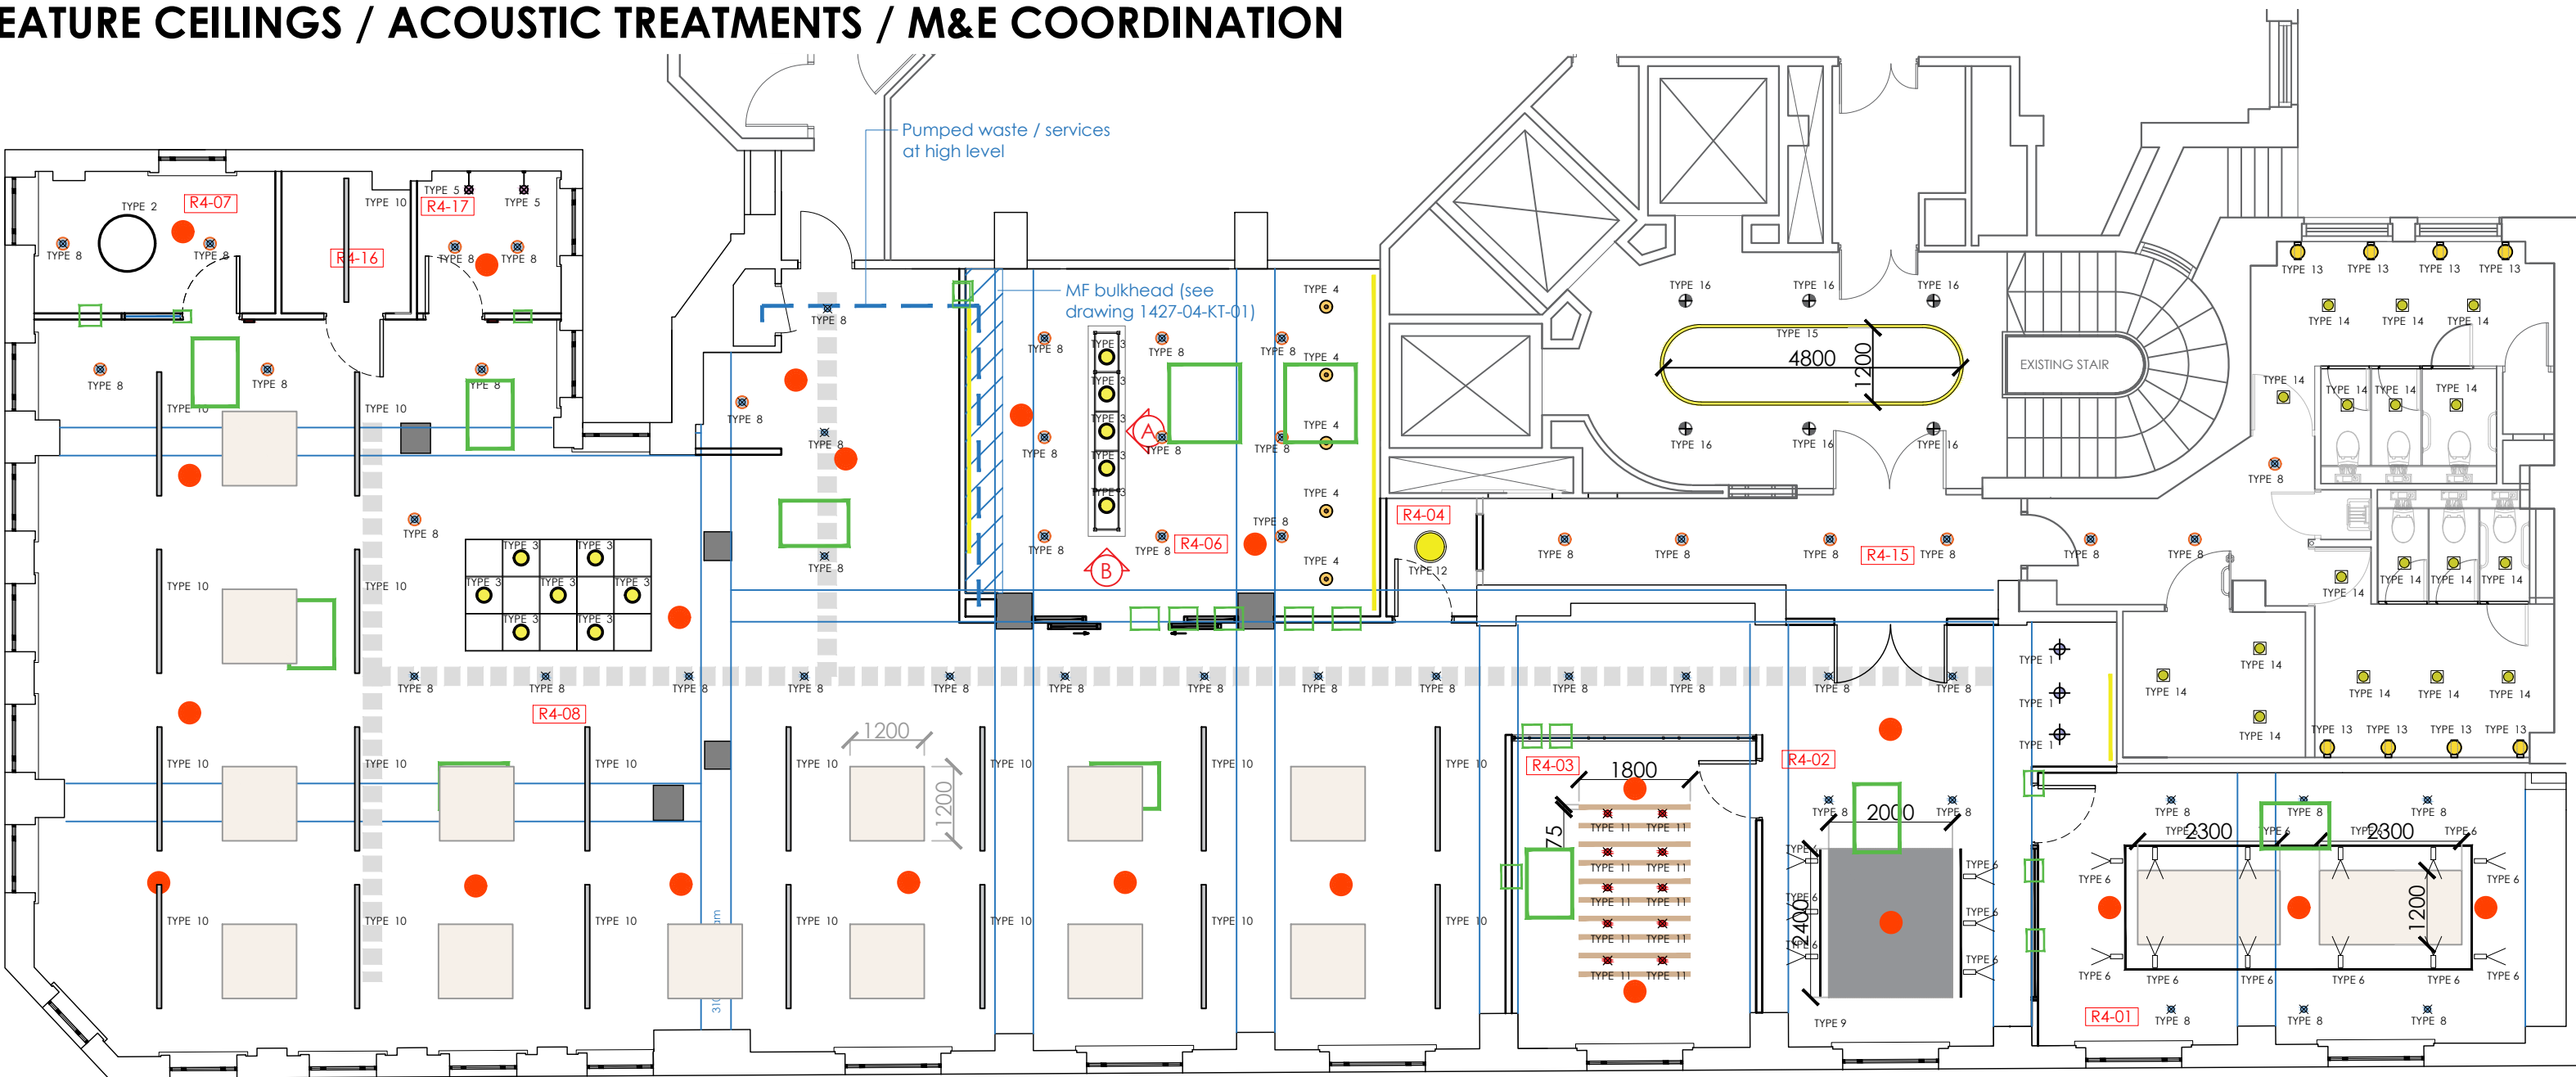


CF05 - HANGING PLANTER FEATURE CEILING RAFT DETAIL @ SCALE 1:20

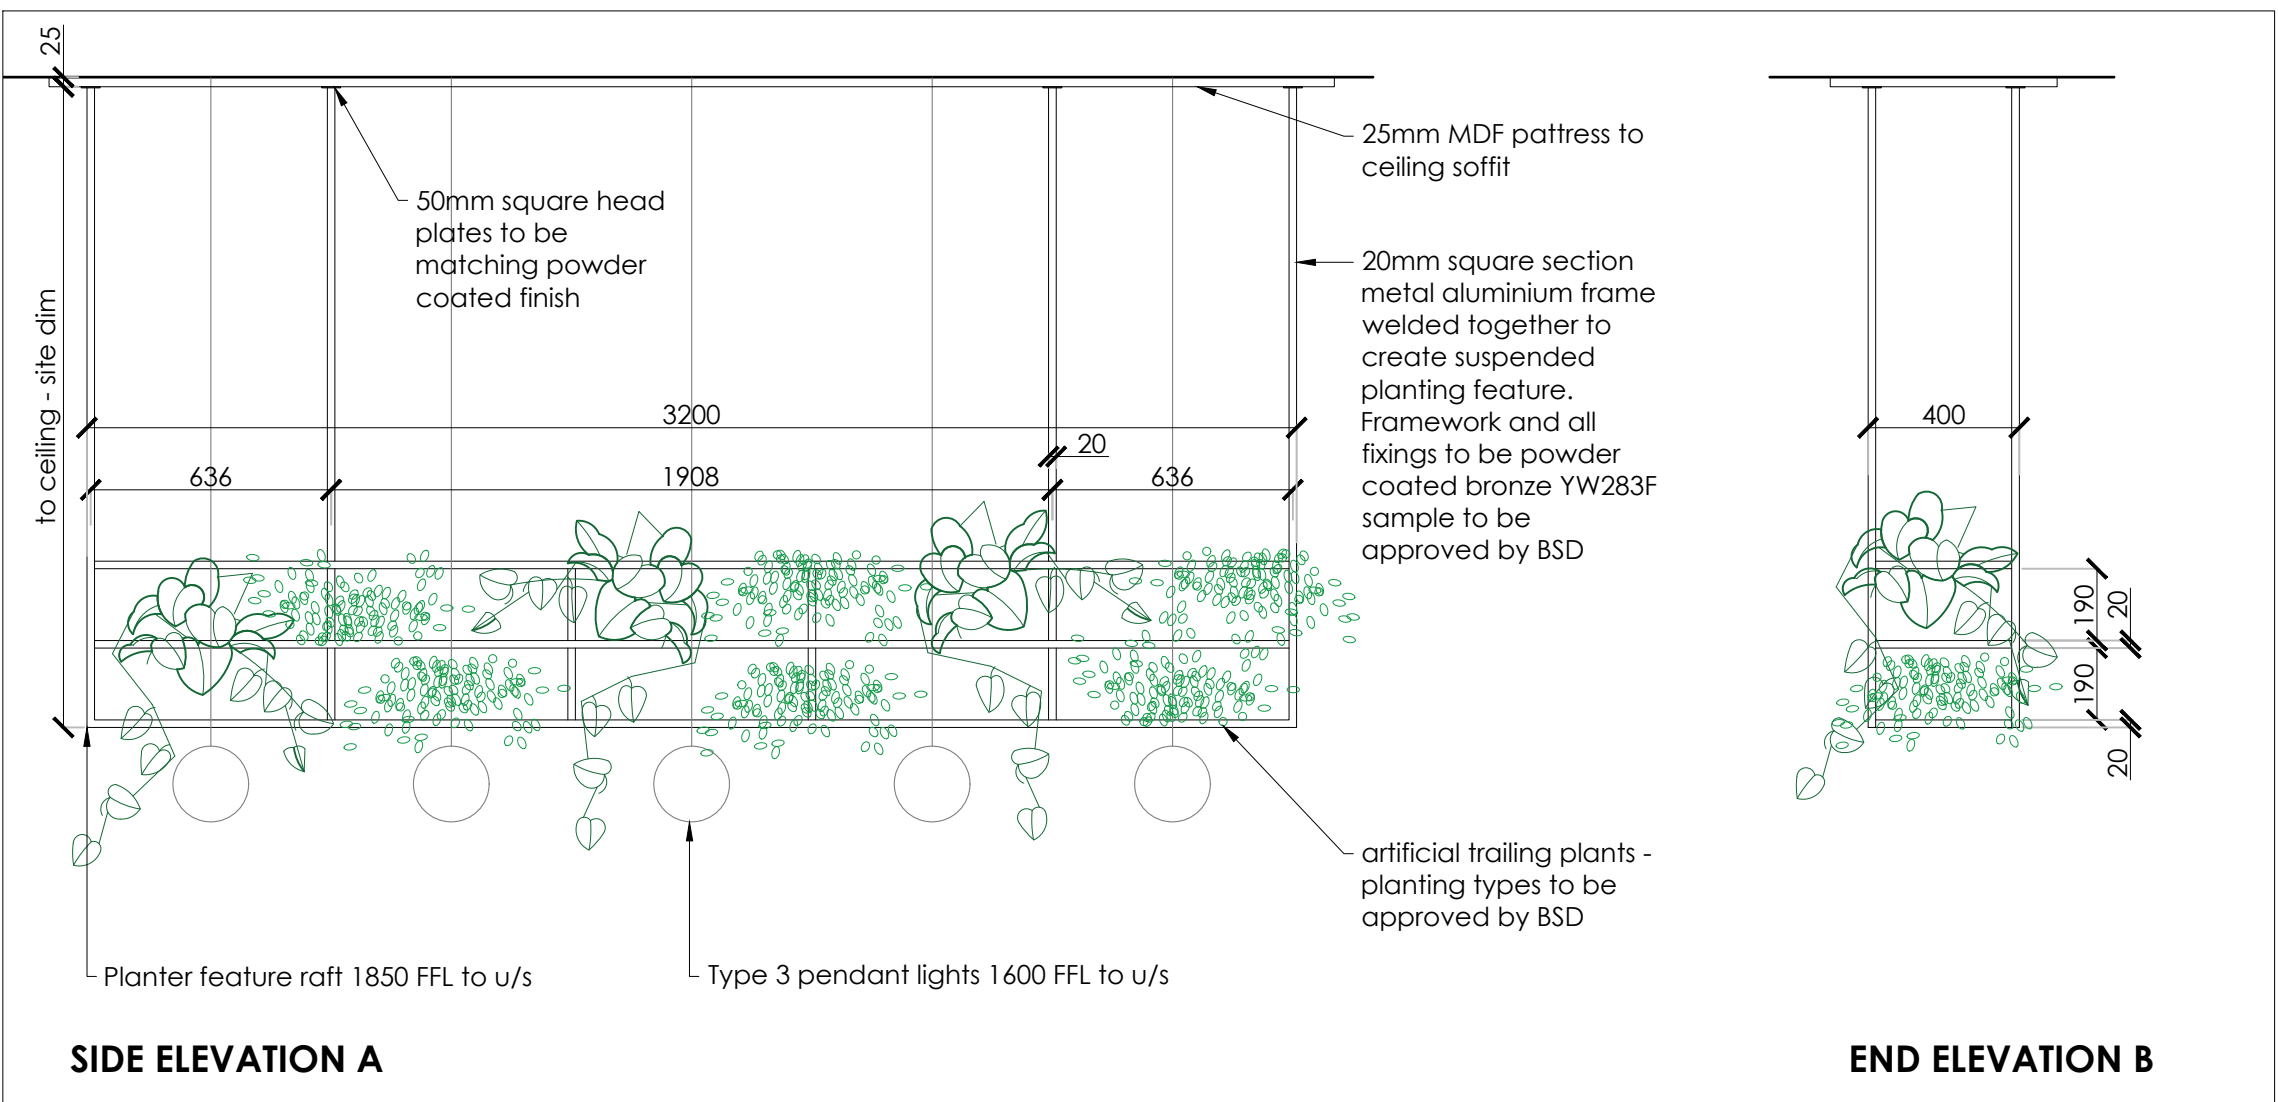


LIGHTING KEY

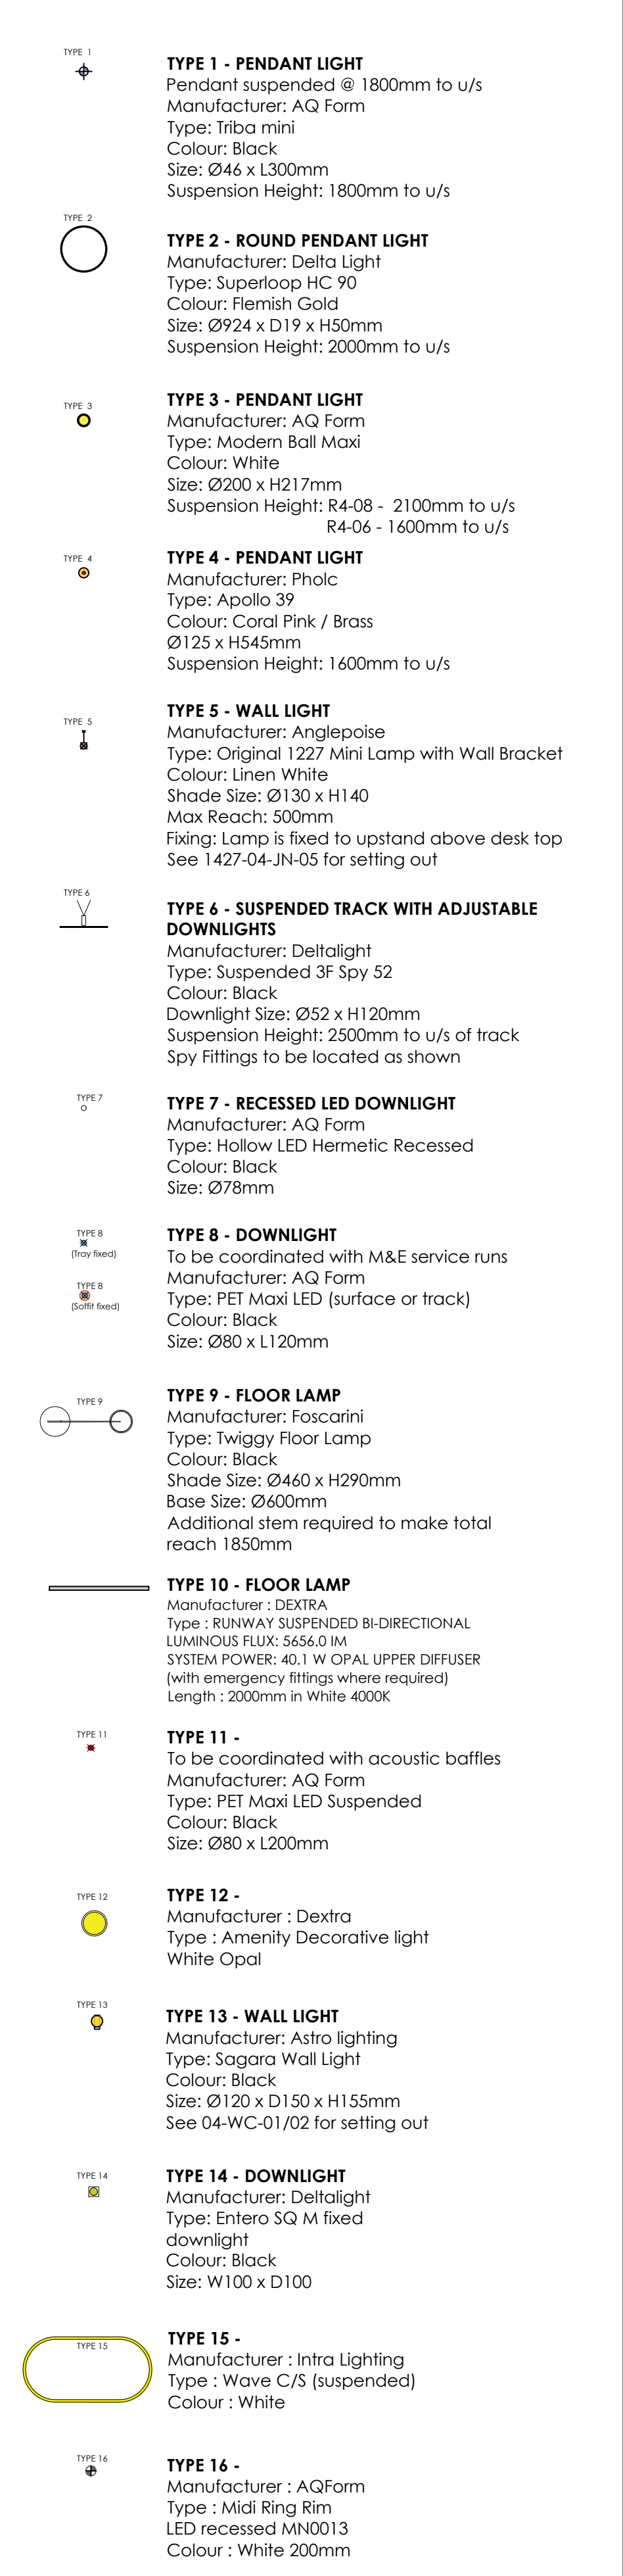

FEATURE CEILINGS
+ ACOUSTIC TREATMENTS KEY

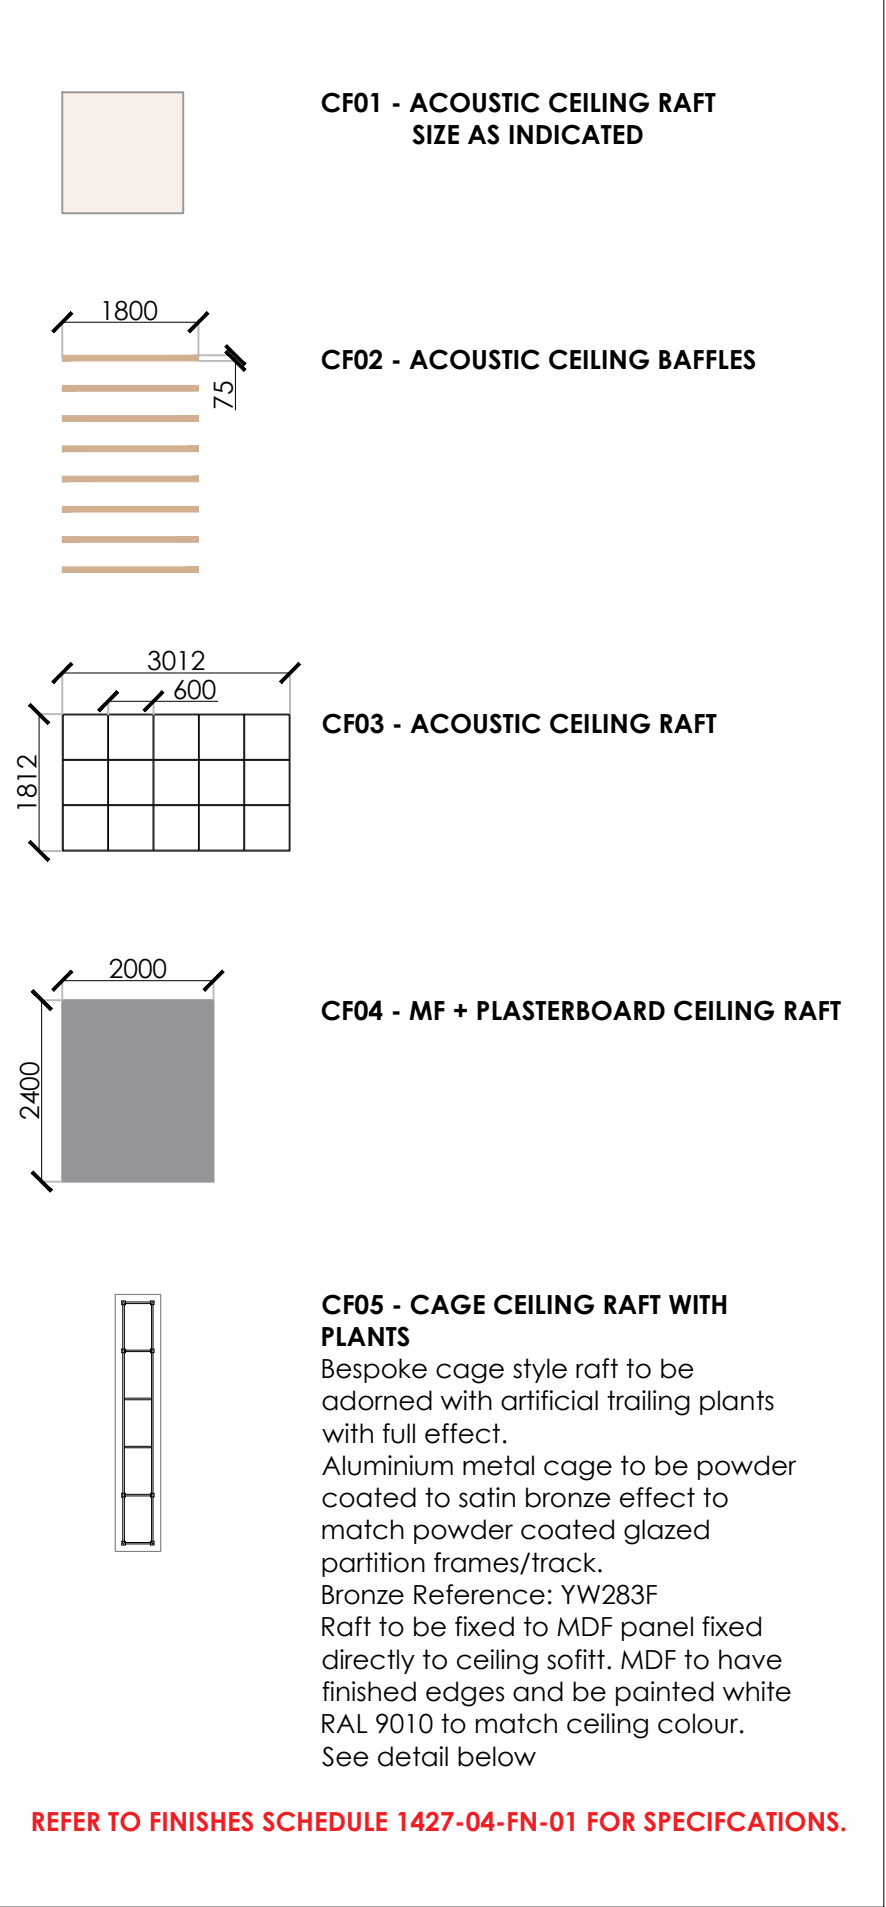

M&E COORDINATION

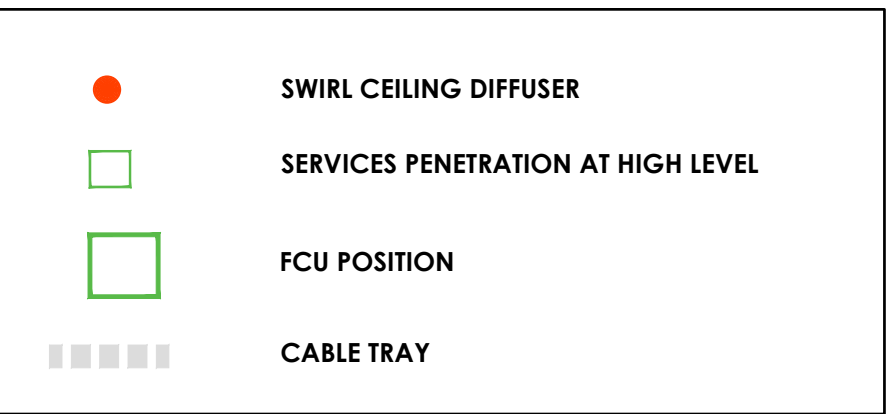

NOTES:

M&E CONSULTANT TO APPROVE ALL LIGHTING LEVELS AND POWER REQUIREMENTS. ALL FINAL POSITIONS TO BE CONFIRMED ON SITE.

FOR FULL M&E PROPOSALS, REFER TO M&E CONSULTANTS SPECIFICATION FOR ALL SERVICES RUNS, LIGHTING & ELECTRICAL LAYOUTS

THIS DRAWING SHOWS LIGHTING DESIGN INTENT AND HAS BEEN COORDINATED WITH HOARE LEA DRAWINGS. ANY VARIATION IN SPECIFICATION TO BE NOTIFIED TO BLUE SKY DESIGN PRIOR TO ORDER OF FITTINGS.

LED STRIP WITH DIFFUSER TO JOINERY ITEMS :
REFER TO DETAIL DRAWINGS FOR DETAILS

G	22.12.25	Ceiling acoustic rafts resized to suit heritage comments.	FLC
F	25.11.25	Drawing title amended to 'Ceiling Layout' from 'Feature lighting'.	FLC
E	12.11.25	Lighting spec coordinated with Hoare Lea information.	FLC
D	10.11.25	Ceiling rafts added to open plan	FLC
C	26.09.25	Area amended to suit Litchfield requirements	CRH
B	07.09.25	Feature ceilings specifications can now be found on finishes schedule	HEK
A	27.6.25	FIRST FULL ISSUE FOR COMMENT	FLC
Rev	Date	Description	By

Client	GROSVENOR
Project	4TH FLOOR SUITE
Address	SHIP CANAL HOUSE
Drawing Title	CEILING LAYOUT

Date	26.06.2025	Scale	1:100 / 1:20 @ A1	By	FLC
Drawing No	1427-04-CL-01(G)	Status	FOR COMMENT		