
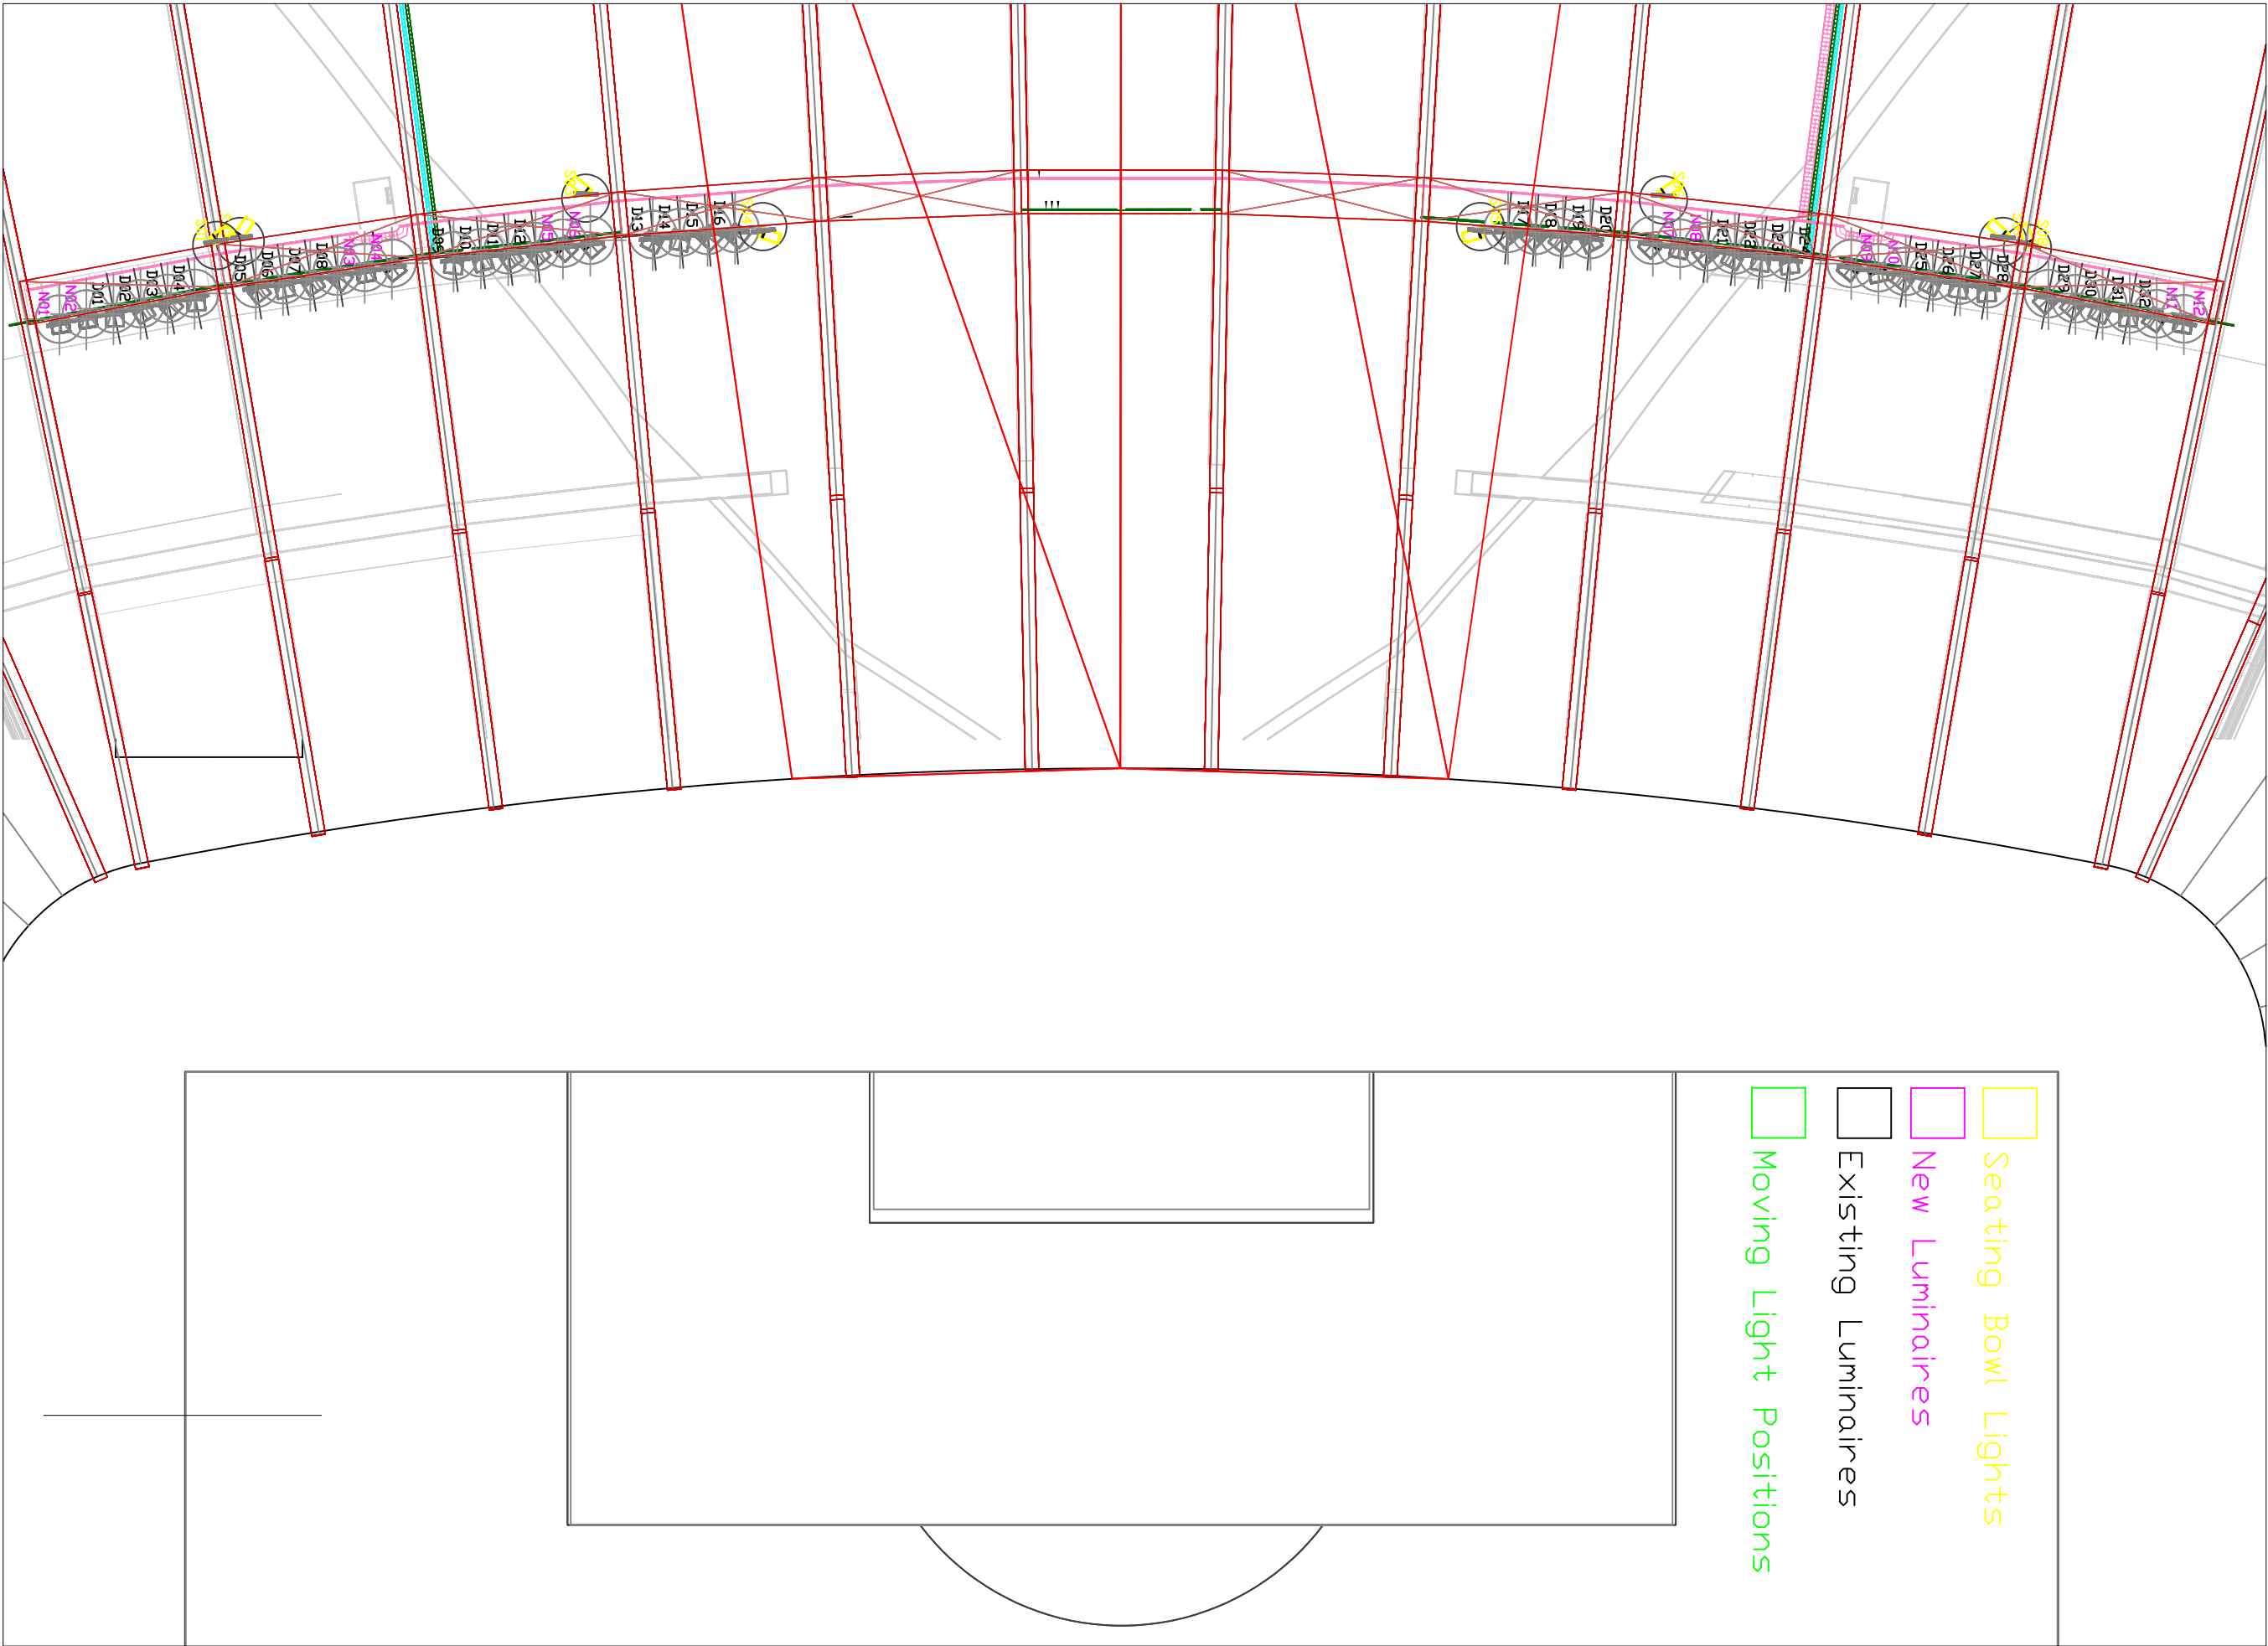


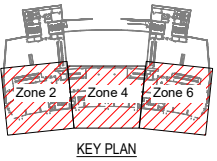

P03	JBD	BG	20.02.25	Issued For Comments
P02	AW	BG	18.09.23	STAGE 4a - FINAL ISSUE
P01	JBD	BG	07.11.24	Stage 4b Issue
Rev	Dim	Chg	Date	Description

Scale
As indicated

Original Size
A0

Status
A5 - For Authorisation

Client

Project
MCFC

Title
NORTH STAND PITCH LIGHTING LAYOUT
GANTRY LEVEL

Drawing No.
NSE-SEE-NS-RF-DR-E-636421

Revision
C01