


LIGHTING CONTROL PANELS ARE LOCATED WITHIN ELECTRICAL RISERS

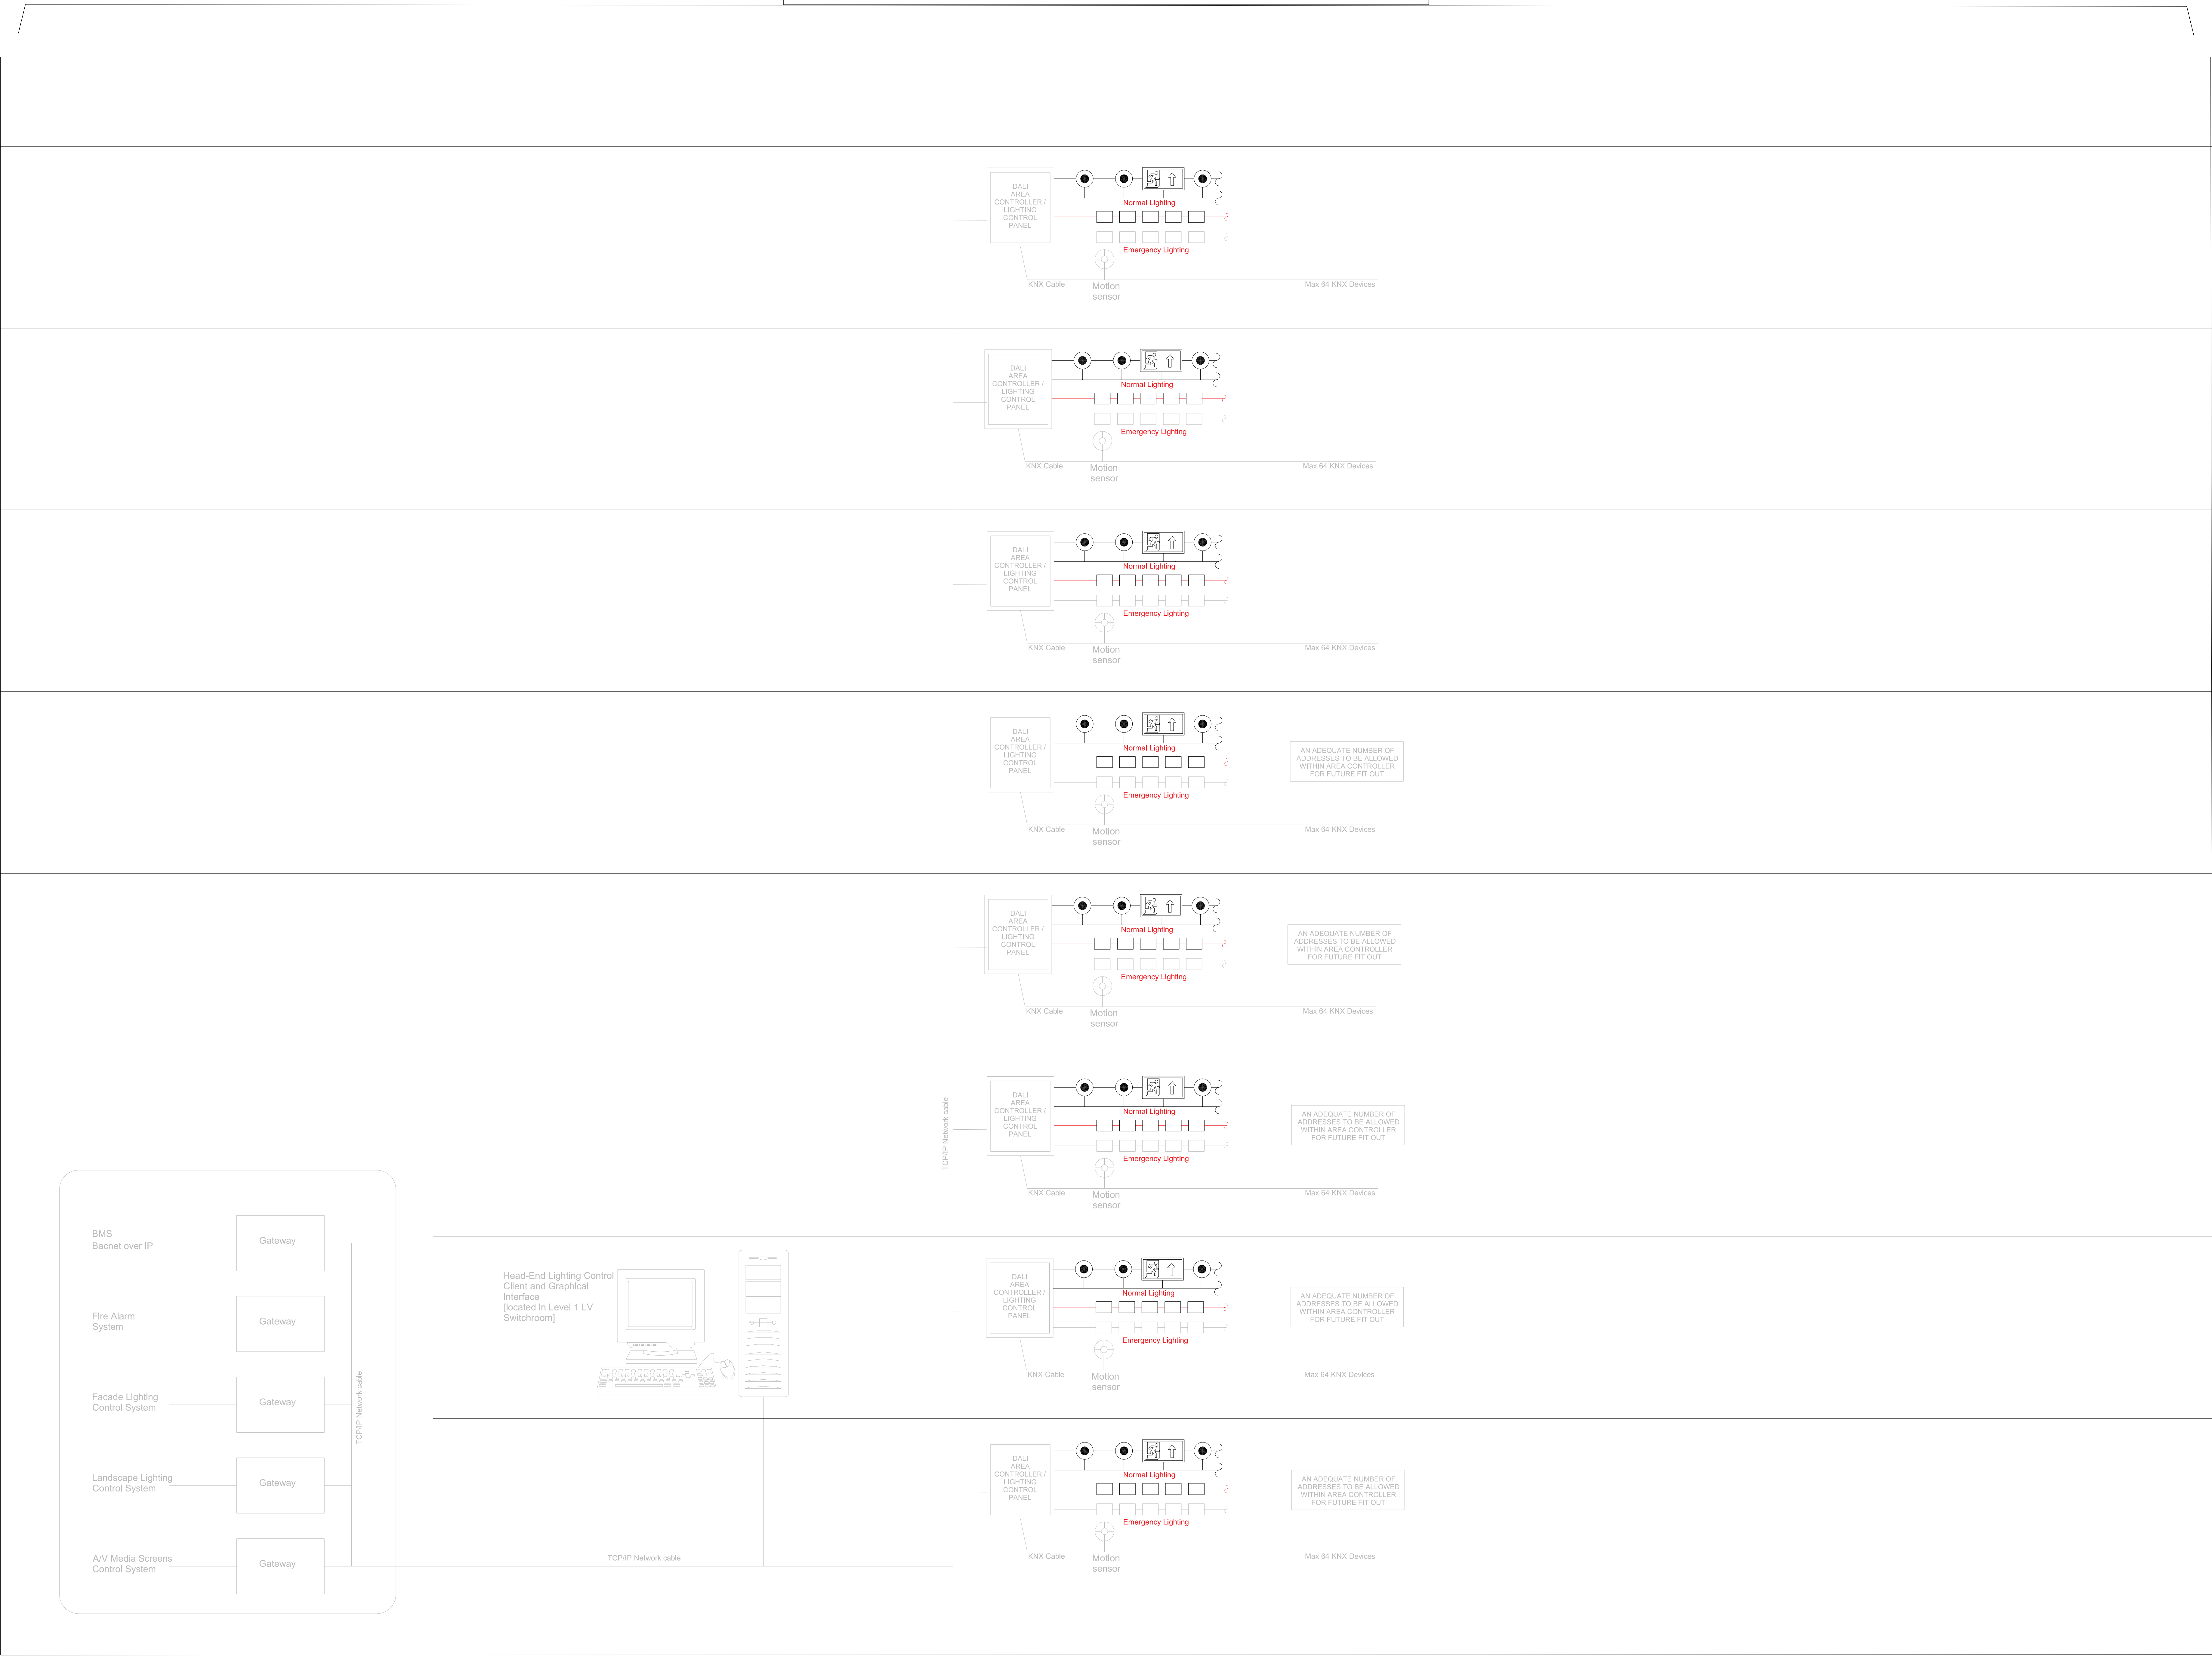

## COMMERCIAL BUILDING

**DISCLAIMER**  
This document should not be relied on or used in any circumstances other than those it was originally prepared for. ME Engineers Ltd were commissioned. ME Engineers Ltd accept no responsibility for this document used by any 3rd party other than the person by whom it was commissioned. © copyright

SCALE

---

LINKS

KEY PLAN

---

 
NOTES

|     |            |                    |
|-----|------------|--------------------|
| CR1 | 15/05/2005 | CONSTRUCTION ISSUE |
| PR1 | 27/01/2005 | STAGE 4 ISSUE      |
| REV | DATE       | DESCRIPTION        |

CLIENT



MEP CONSULTANTS

 SES  
ENGINEERING SERVICES

SES Engineering Services  
Think Park (SES) Building Three,  
2nd Floor Mosley Road, Trafford Park  
M17 1FQ  
T: +44 (0) 161 945 5589  
[www.ses-ltd.co.uk](http://www.ses-ltd.co.uk)

PROJECT

MCFC - COMMERCIAL BLOCK

## COMMERCIAL BLOCK LIGHTING CONTROL SCHEMATIC

|                           |            |                                          |  |
|---------------------------|------------|------------------------------------------|--|
| RIBA STAGE:               |            | PSS CODE:                                |  |
| RIBA 4 - TECHNICAL DESIGN |            | A5 - For Authorisation as Stage Complete |  |
| PROJECT No                | DATE       | SCALE @ A3                               |  |
| 240032                    | 27/01/2025 | NTS                                      |  |
| PRINCIPLE                 | DESIGNER   | DRAWN                                    |  |
| CP                        | AC         | AC                                       |  |

|                                                    |                   |
|----------------------------------------------------|-------------------|
| DRAWING NUMBER<br><b>NSE-SEE-CM-ZZ-DR-E-630701</b> | REV<br><b>C01</b> |
|----------------------------------------------------|-------------------|