
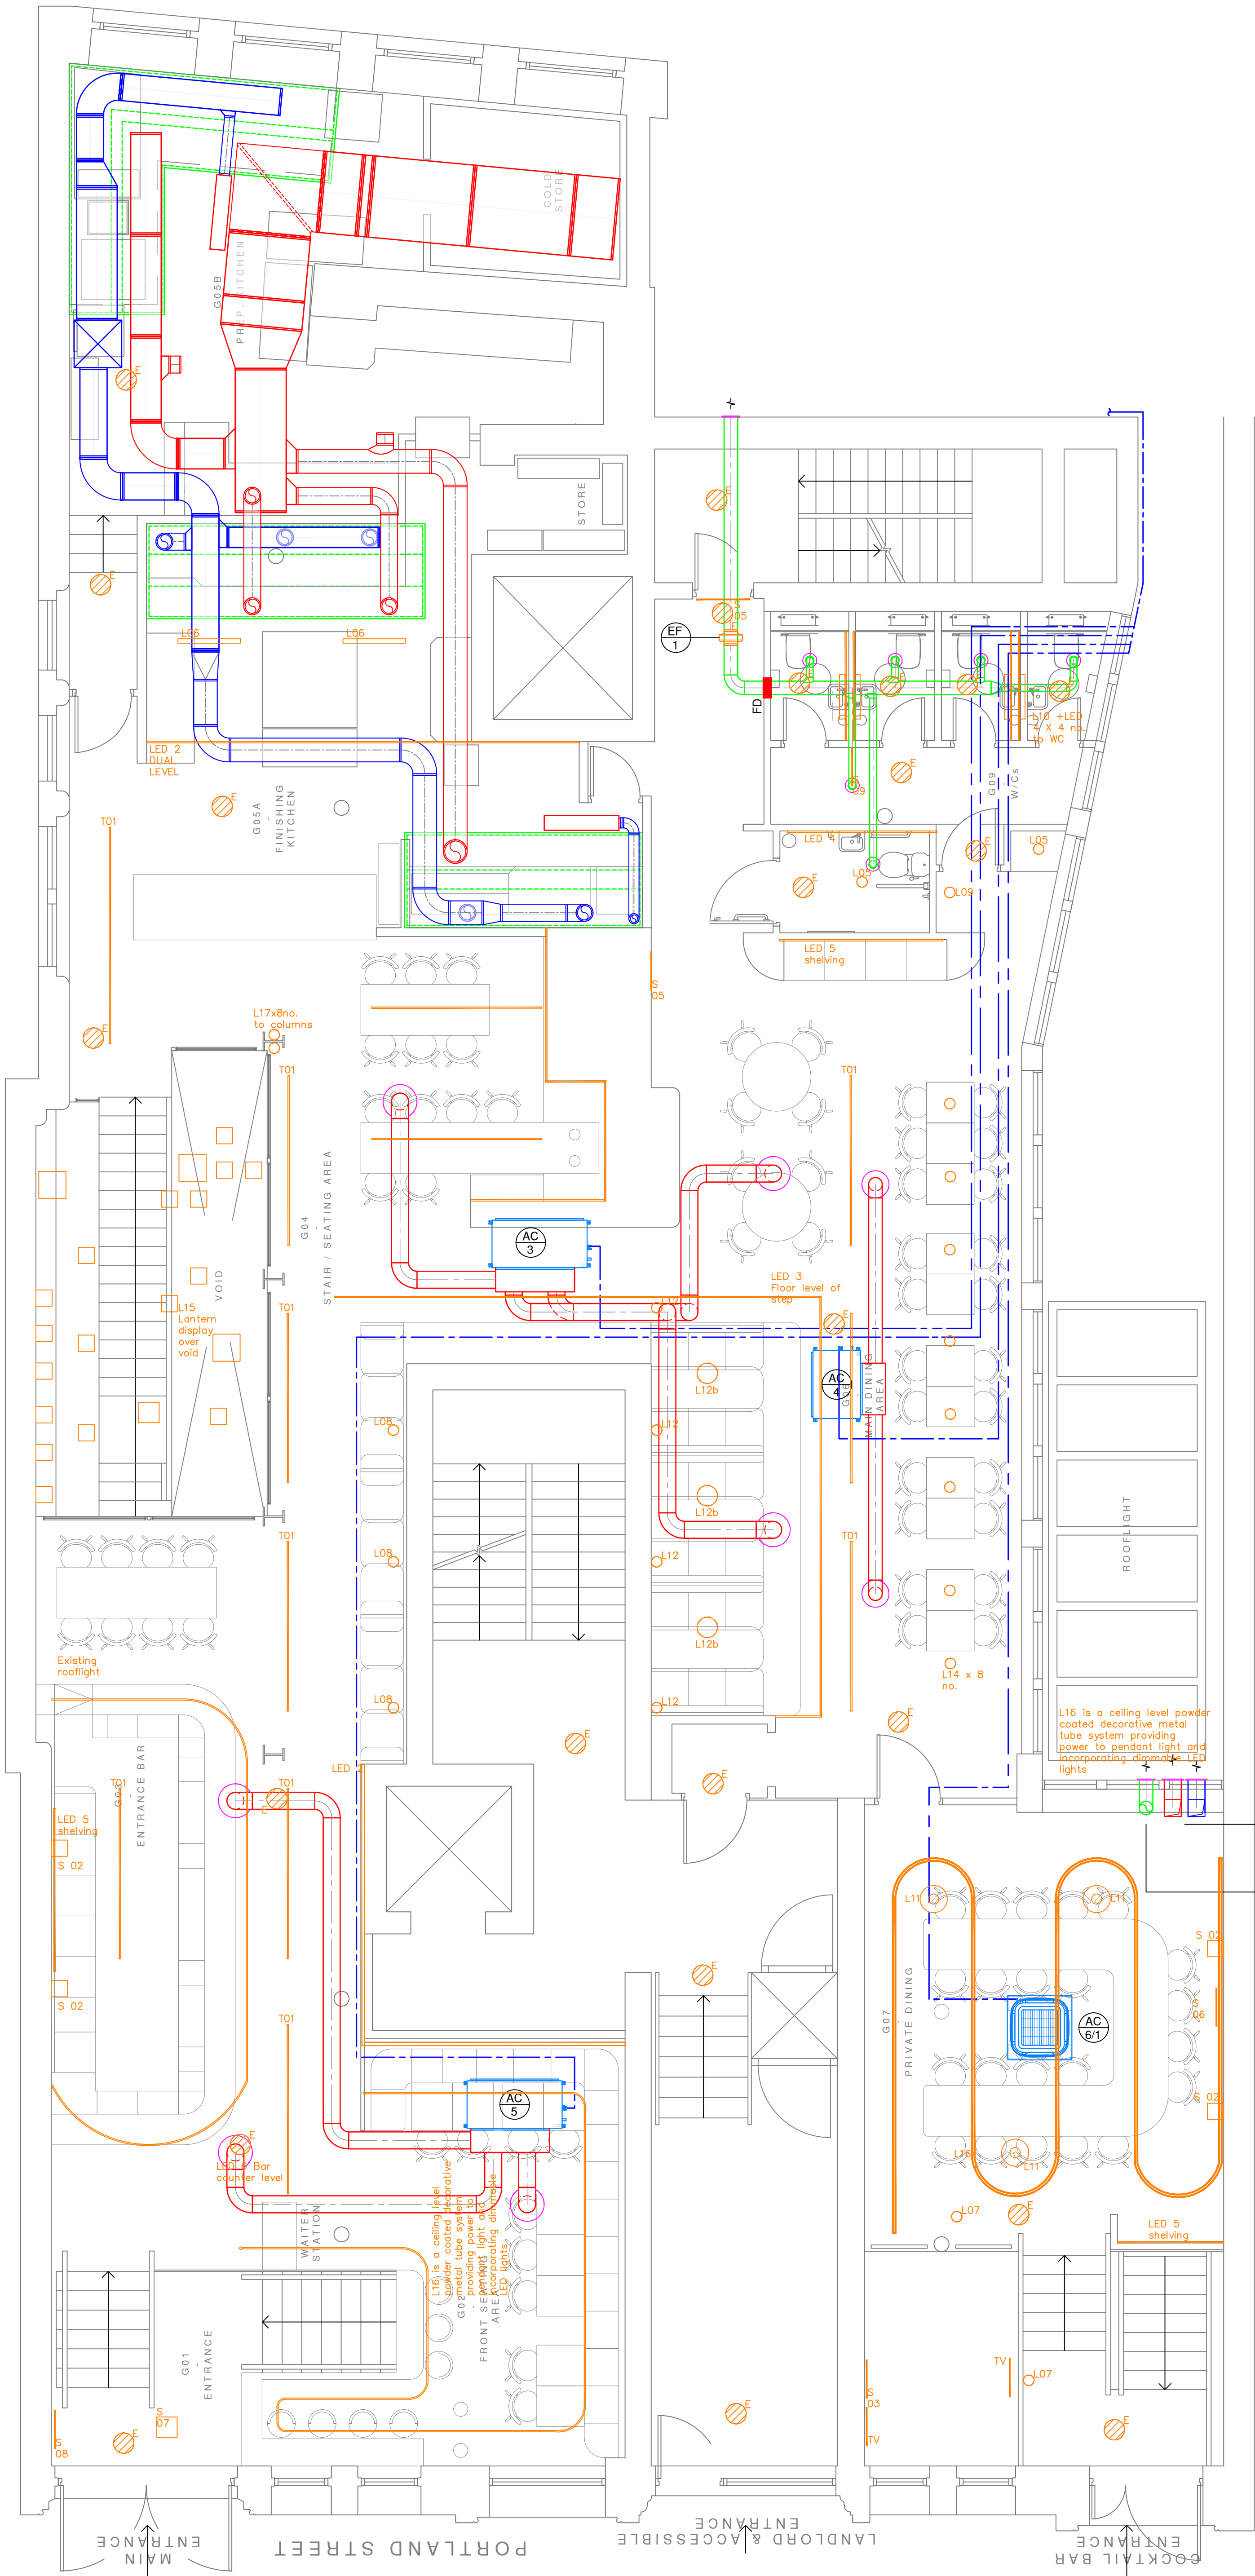


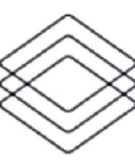

HRV FRESH AIR &  
EXHAUST AIR DUCTS  
RISE FROM BELOW, c/w  
FIRE DAMPERS IN FLOOR

TOILET EXTRACT DUCT  
RISE FROM BELOW, c/w  
FIRE DAMPER IN FLOOR

|                                                                                       |            |
|---------------------------------------------------------------------------------------|------------|
| DRAWING STATUS                                                                        |            |
| RECORD                                                                                |            |
|  |            |
| CubicWorks                                                                            |            |
| 2nd Floor II Spinnaker Court II 31 Broadway<br>Manchester M50 2YR                     |            |
| PROJECT MANAGER                                                                       | DESIGN     |
| SCALE @A1                                                                             | DRAWN BY   |
| DATE                                                                                  | 10.10.2025 |
| PROJECT                                                                               |            |
| HOUSE OF FU<br>113-115 PORTLAND ST<br>MANCHESTER<br>M1 6DW                            |            |
| DRAWING TITLE                                                                         |            |
| LOWER GROUND FLOOR<br>HVAC LAYOUT                                                     |            |
| DRAWING NO.                                                                           | REV        |
| GF-DR-M-5701                                                                          | RE         |