
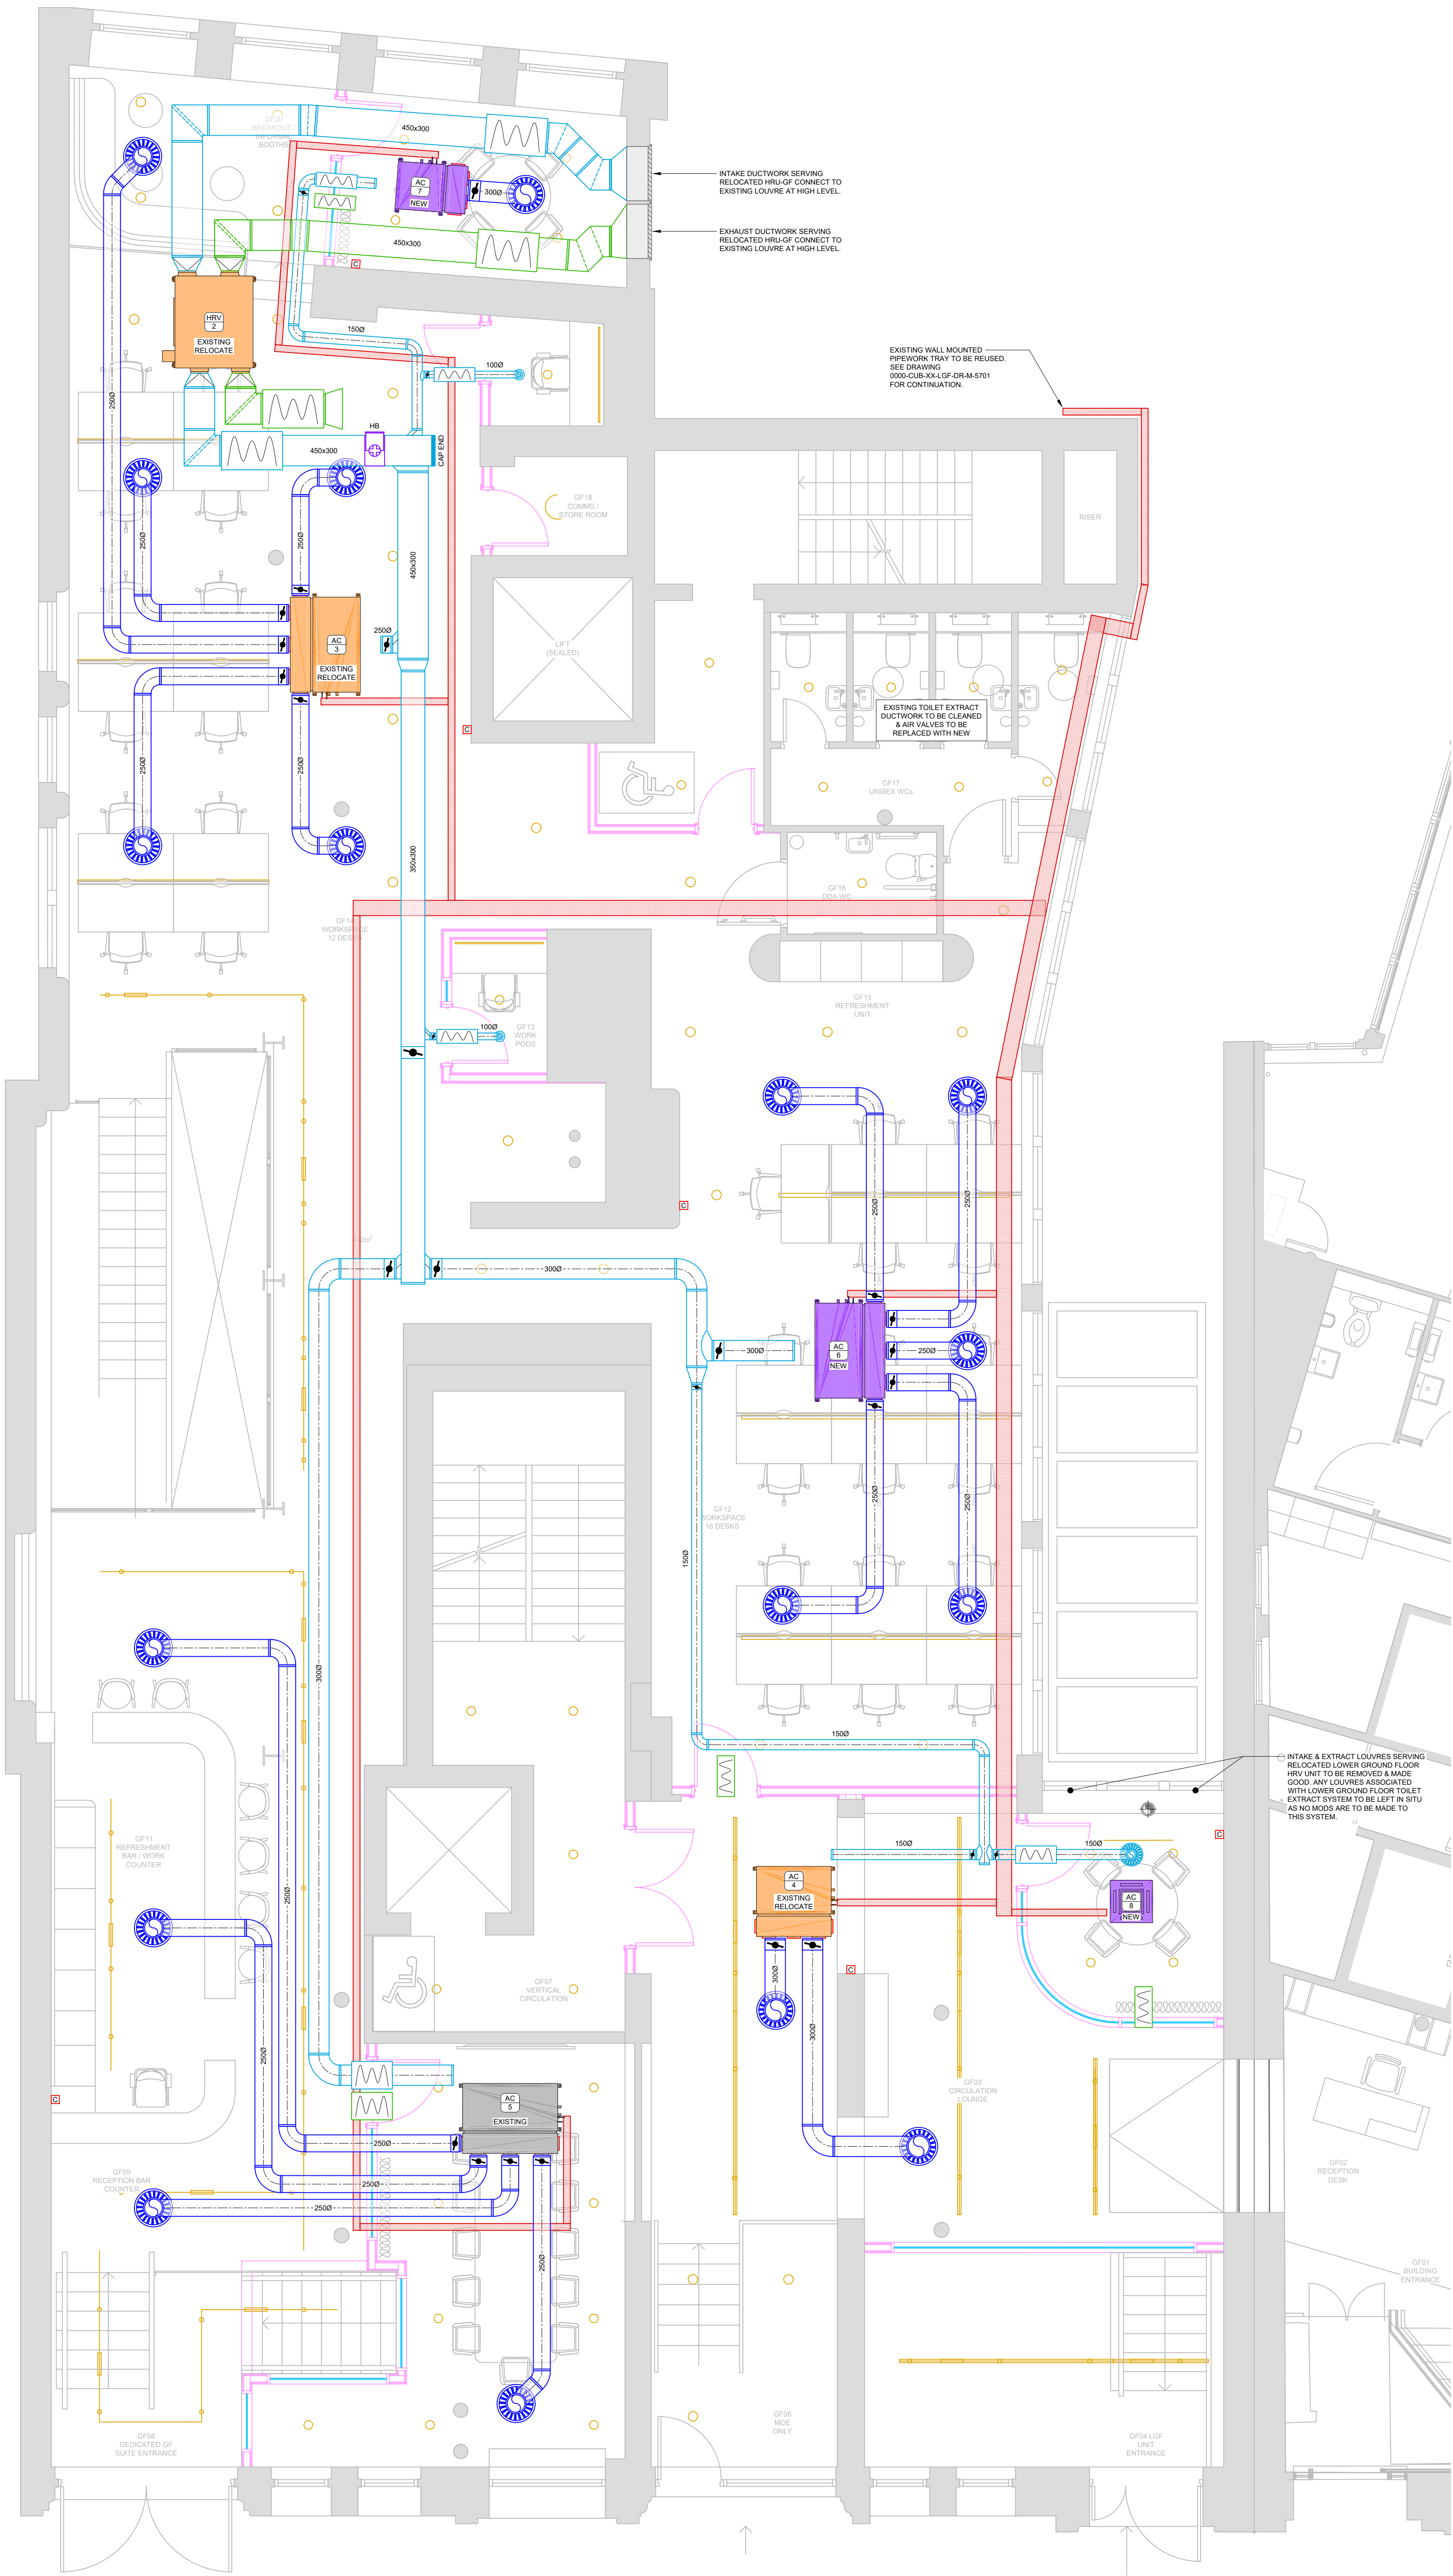


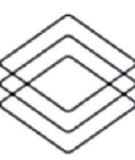

- HVAC LEGEND:**
- SQUARE DIFFUSER
 - EGGCRATE GRILLE
 - SWIRL GRILLE
 - CIRCULAR SWIRL GRILLE
 - CIRCULAR AIR VALVE
 - LINEAR DIFFUSER
 - BELLMOUTH
 - SPIRAL DUCTWORK
 - RECTANGULAR DUCTWORK
 - EXTERNAL LOUVER
 - DOOR UNDERCUT
 - FIRE DAMPER
 - DTB / RTA & DTL / RTHL
 - DTB / RTA & DTL / RTHL
 - VOLUME CONTROL DAMPER
 - CROSSTALK ATTENUATOR
 - AC CONTROLLER
 - CENTRAL CONTROLLER
 - FAN CONTROLLER
 - ACCESS HATCH
 - IN LINE FAN
 - HEAT RECOVERY UNIT
 - FAN COIL UNIT
 - AC CASSETTE
 - WALL MOUNTED FAN COIL
 - OUTDOOR CONDENSING UNIT
 - BRANCH CONTROLLER
 - ELECTRIC HEATER BATTERY
 - PANEL HEATER / RADIATOR
 - PIPEWORK CONTAINMENT
 - BUILDERSWORK PENETRATION
- LINE TYPES:**
- PRIMARY SUPPLY
 - RETURN / EXTRACT
 - SECONDARY SUPPLY
 - DIRTY EXTRACT
 - EXISTING
 - STRIP-OUT
- COORDINATION ITEMS:**
- LIGHTING
- MECHANICAL EQUIPMENT COLOUR CODING:**
- REUSE EXISTING IN EXISTING POSITION
 - REUSE EXISTING IN NEW POSITION
 - NEW SUPPLEMENTARY EQUIPMENT

REV	DESCRIPTION	DATE
P01	PRELIMINARY ISSUE	17.10.2025
P02	UPDATED FOLLOWING COMMENTS.	29.10.2025
P03	UPDATED FOLLOWING COMMENTS.	03.11.2025

DRAWING STATUS
PLANNING


CubicWorks
2nd Floor II Spinnaker Court II 31 Broadway
Manchester M50 2YR

PROJECT MANAGER	DESIGN
SCALE @A1	JORDAN TAYLOR
DATE	1:50
	JORDAN TAYLOR
	13.10.2025

PROJECT	113-115 PORTLAND ST MANCHESTER M1 6DW
---------	---

DRAWING TITLE	GROUND FLOOR VENTILATION & AIR CONDITIONING
---------------	--

DRAWING NO.	0000-CUB-XX-GF-DR-M-5701	REV	P03
-------------	--------------------------	-----	-----