


GENERAL NOTES:


1. THIS DRAWING IS TO BE READ IN CONJUNCTION WITH ALL RELEVANT ARCHITECTS AND ENGINEERS DRAWINGS AND SPECIFICATIONS.
2. DO NOT SCALE THIS DRAWING. ANY AMBIGUITIES, OMISSIONS AND ERRORS ON DRAWINGS SHALL BE BROUGHT TO THE ENGINEERS ATTENTION IMMEDIATELY. ALL DIMENSIONS MUST BE CHECKED / VERIFIED ON SITE.
3. ALL DIMENSIONS ARE IN MILLIMETRES UNLESS NOTED OTHERWISE.
4. FOR GENERAL NOTES REFER TO DRAWING 082142-CUR-XX-XX-D-C-92500

FOR PIPE SIZES, INVERT LEVELS & LOCATIONS - SEE DRAINAGE LAYOUT SPS-CUR-ZZ-L01-DR-C-50-1901

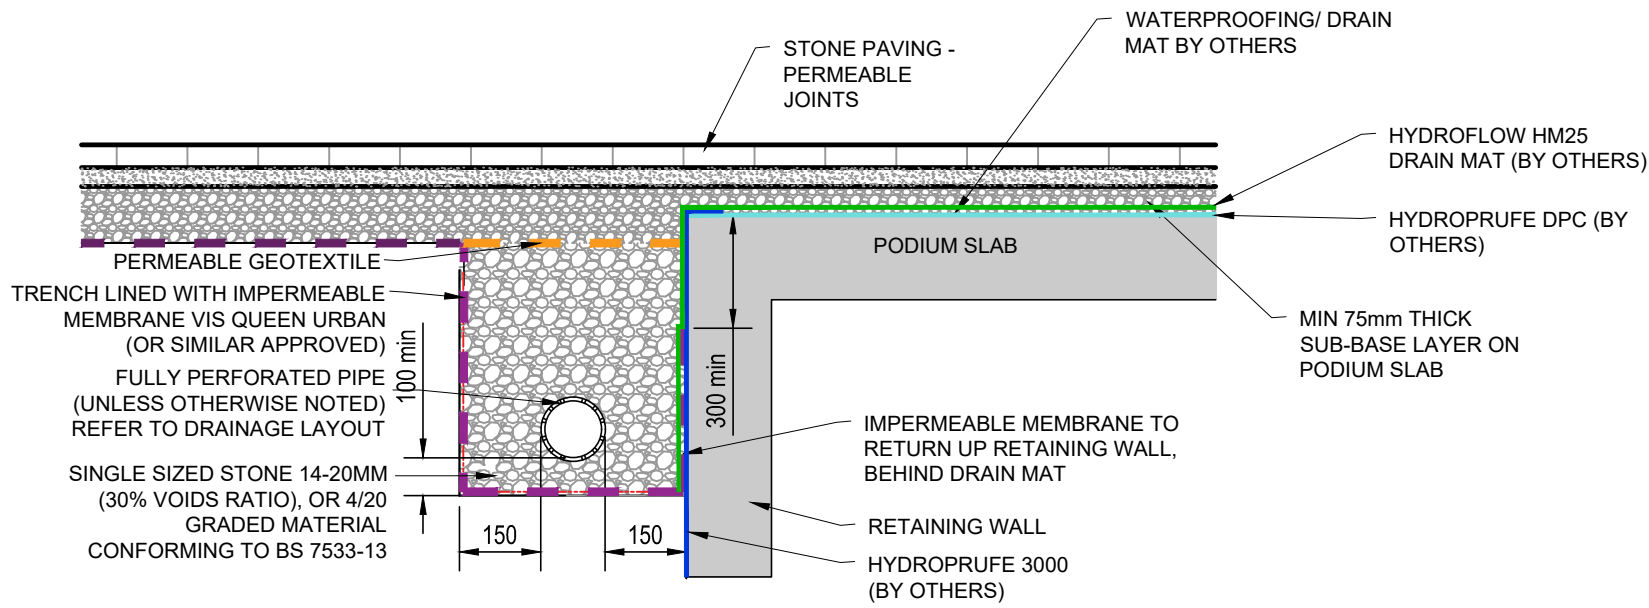


PERFORATED PIPE DETAIL UNDER POROUS ASPHALT & INTERFACE WITH PAVING ON PODIUM DECK

FOR PIPE SIZES, INVERT LEVELS & LOCATIONS - SEE DRAINAGE LAYOUT SPS-CUR-ZZ-L01-DR-C-50-1901

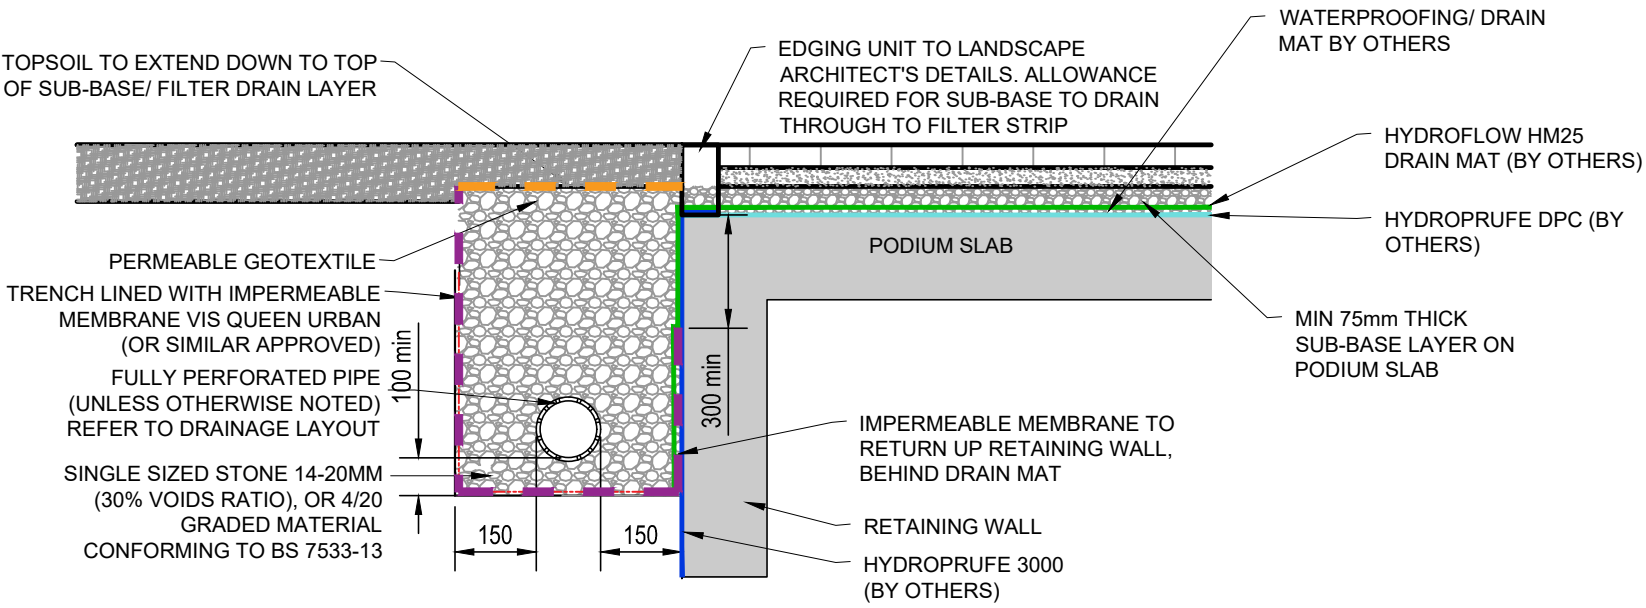


PERFORATED PIPE DETAIL UNDER SOFT LANDSCAPING & INTERFACE WITH PAVING ON PODIUM DECK

SEMI CROSS LINKED POLYETHYLENE (LARGE CELL) EXPANSION MATERIAL TO BE LAID AT THE END OF A RUN OR AT THE INTERFACE WITH AN OUTLET

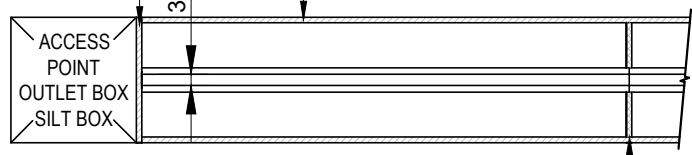


NOTE: BSI CERTIFIED TO F900 LOADING WITHOUT ADDITIONAL CONCRETE REINFORCEMENT.

GATIC PLAN DETAIL

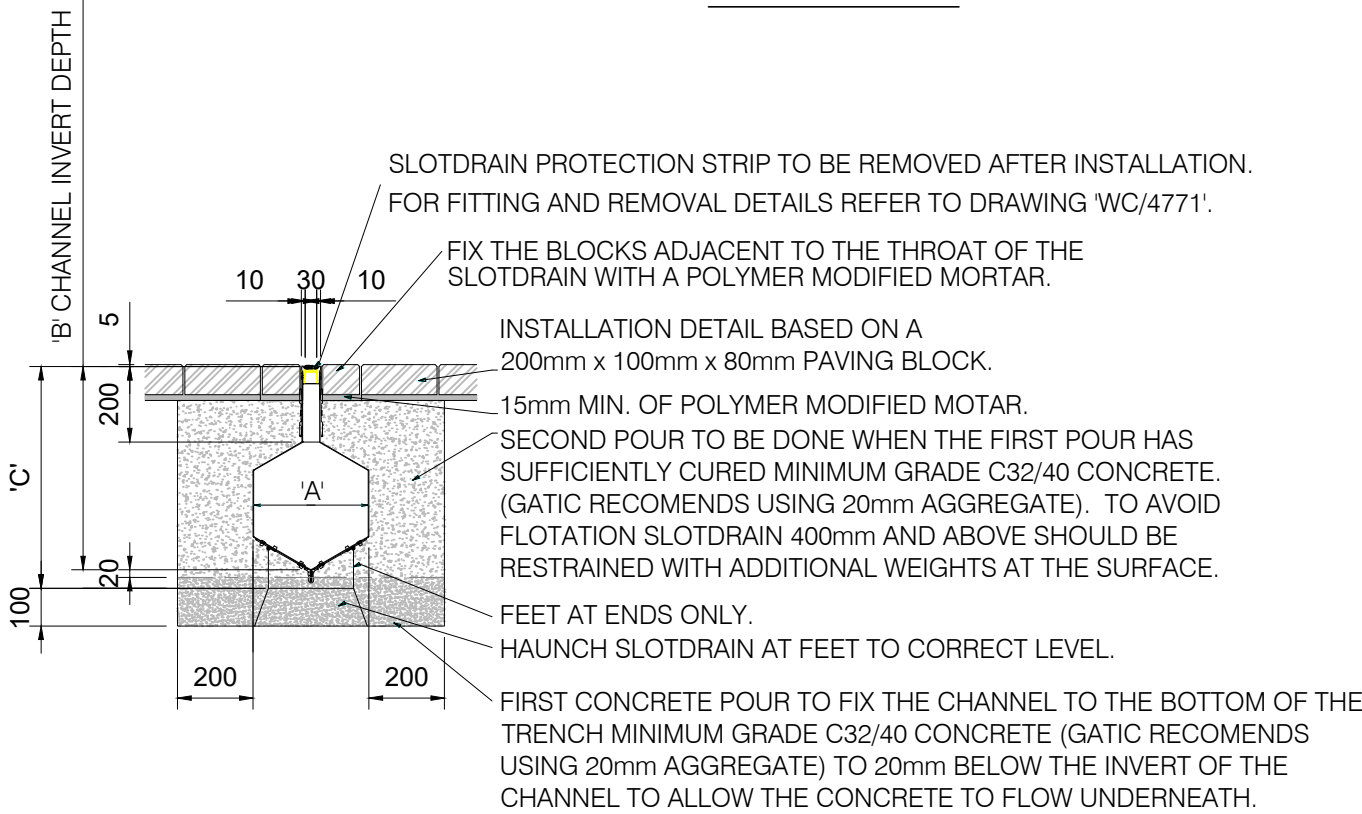

GATIC CASTSLOT TREADSAFE BLOCK PAVING INSTALLATION


GATIC PLAN DETAIL

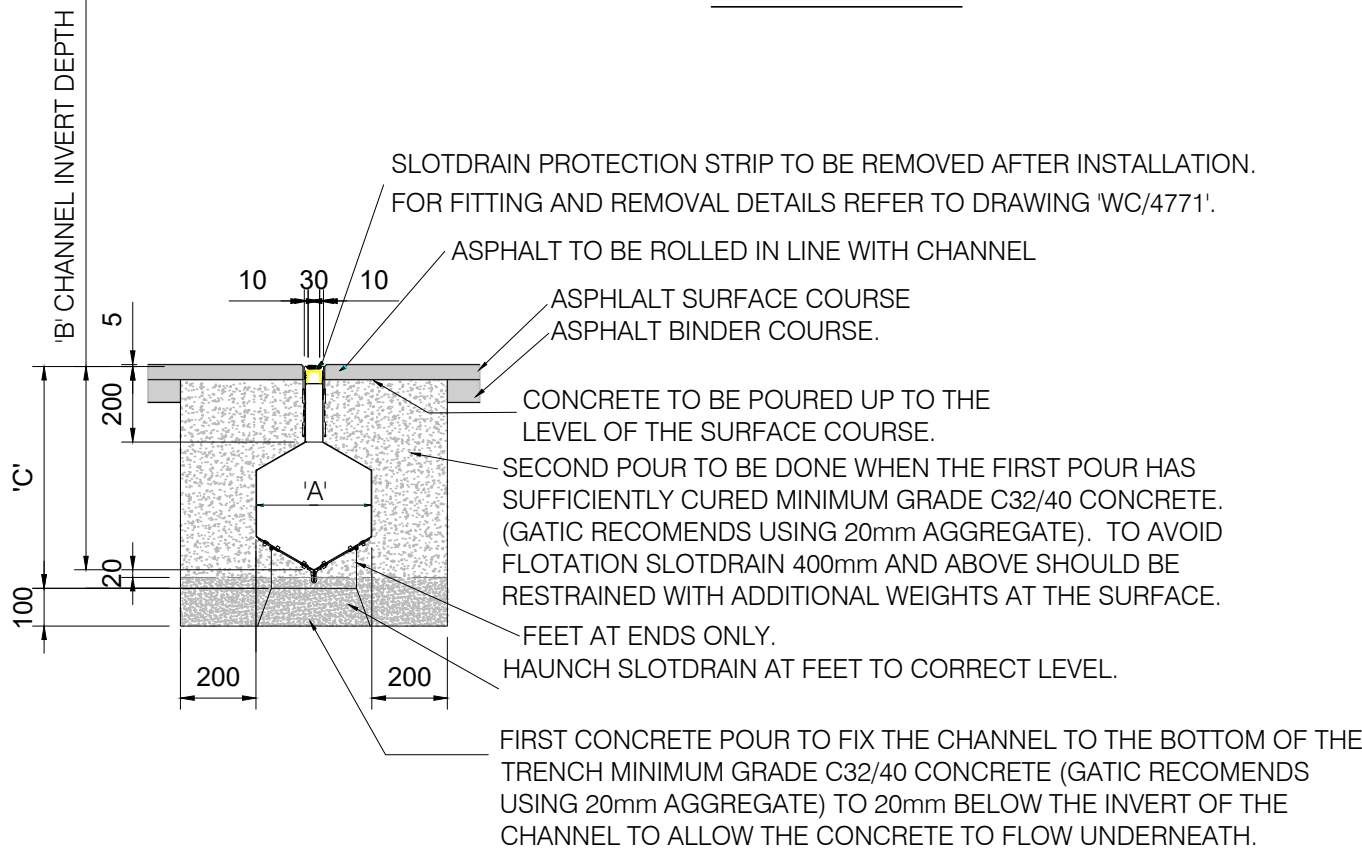


GATIC CASTSLOT TREADSAFE ASPHALT INSTALLATION

CASTSLOT TREADSAFE SLOT DRAIN						
WIDTH 'A'	INVERT 'B'	DEPTH 'C'	C.S.A.	3m PART No.	1m PART No.	500mm PART No.
100	308	357	9098	CAT00001	CAT00009	CAT00017
150	366	415	20325	CAT00002	CAT00010	CAT00018
225	452	501	45014	CAT00003	CAT00011	CAT00019

FOR CHANNEL SIZES AND LOADINGS - SEE DRAINAGE LAYOUT SPS-CUR-ZZ-L00-DR-C-50-1900

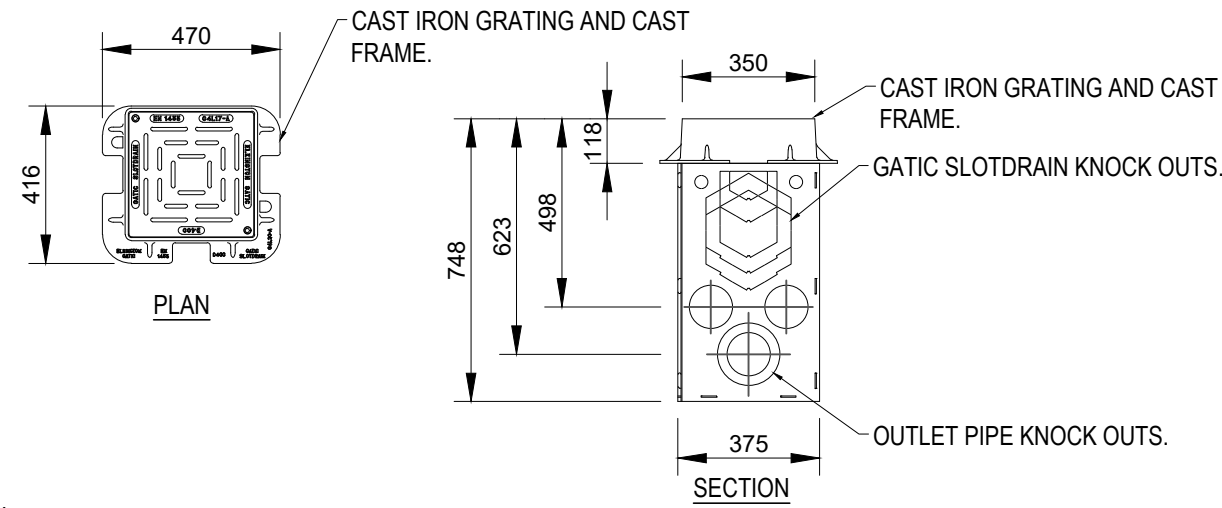

GATIC SLOT DRAIN 350mm OUTLET UNIT SECTION AND PLAN DETAILS NTS

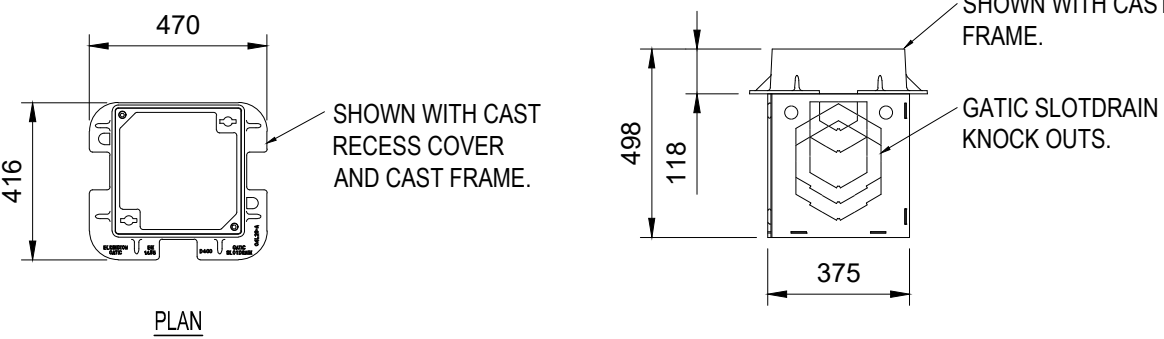

350 ACCESS BOX SECTION AND PLAN DETAILS NTS

P03	PRELIMINARY STAGE 4 ISSUE	05.12.25	ATL	MW
P02	ISSUED FOR STAGE 3	27.09.24	ATL	ATL
P01	ISSUED FOR STAGE 2	14.07.23	ATL	CG

Rev: Description: Date: By: Chkd:

Curtins

Merchant Exchange, 17-19 Whitworth Street West, Manchester, M1 5WG
0161 236 2384
manchester@curtins.com
www.curtins.com

Civils & Structures • Transport Planning • Environmental • Infrastructure • Geotechnical • Conservation & Heritage • Principal Designer
Birmingham • Bristol • Cambridge • Cardiff • Douglas • Dublin • Edinburgh • Glasgow • Kendal • Leeds • Liverpool • London • Manchester • Nottingham

Status:

STAGE 4

Project:

SPARKLE STREET, MANCHESTER

Orig Title:

TYPICAL DRAINAGE DETAILS
SHEET 3

Drawn By: ATL Designed By: ATL Checked By: CD

Project No: 0824142 Date: 14/07/23 Scales @ A1 NTS

Project No - Originator - Function - Spatial - Form - Discipline - Number Revision

SPS - CUR - ZZ - ZZ - DR - C - 83-4922 P03