



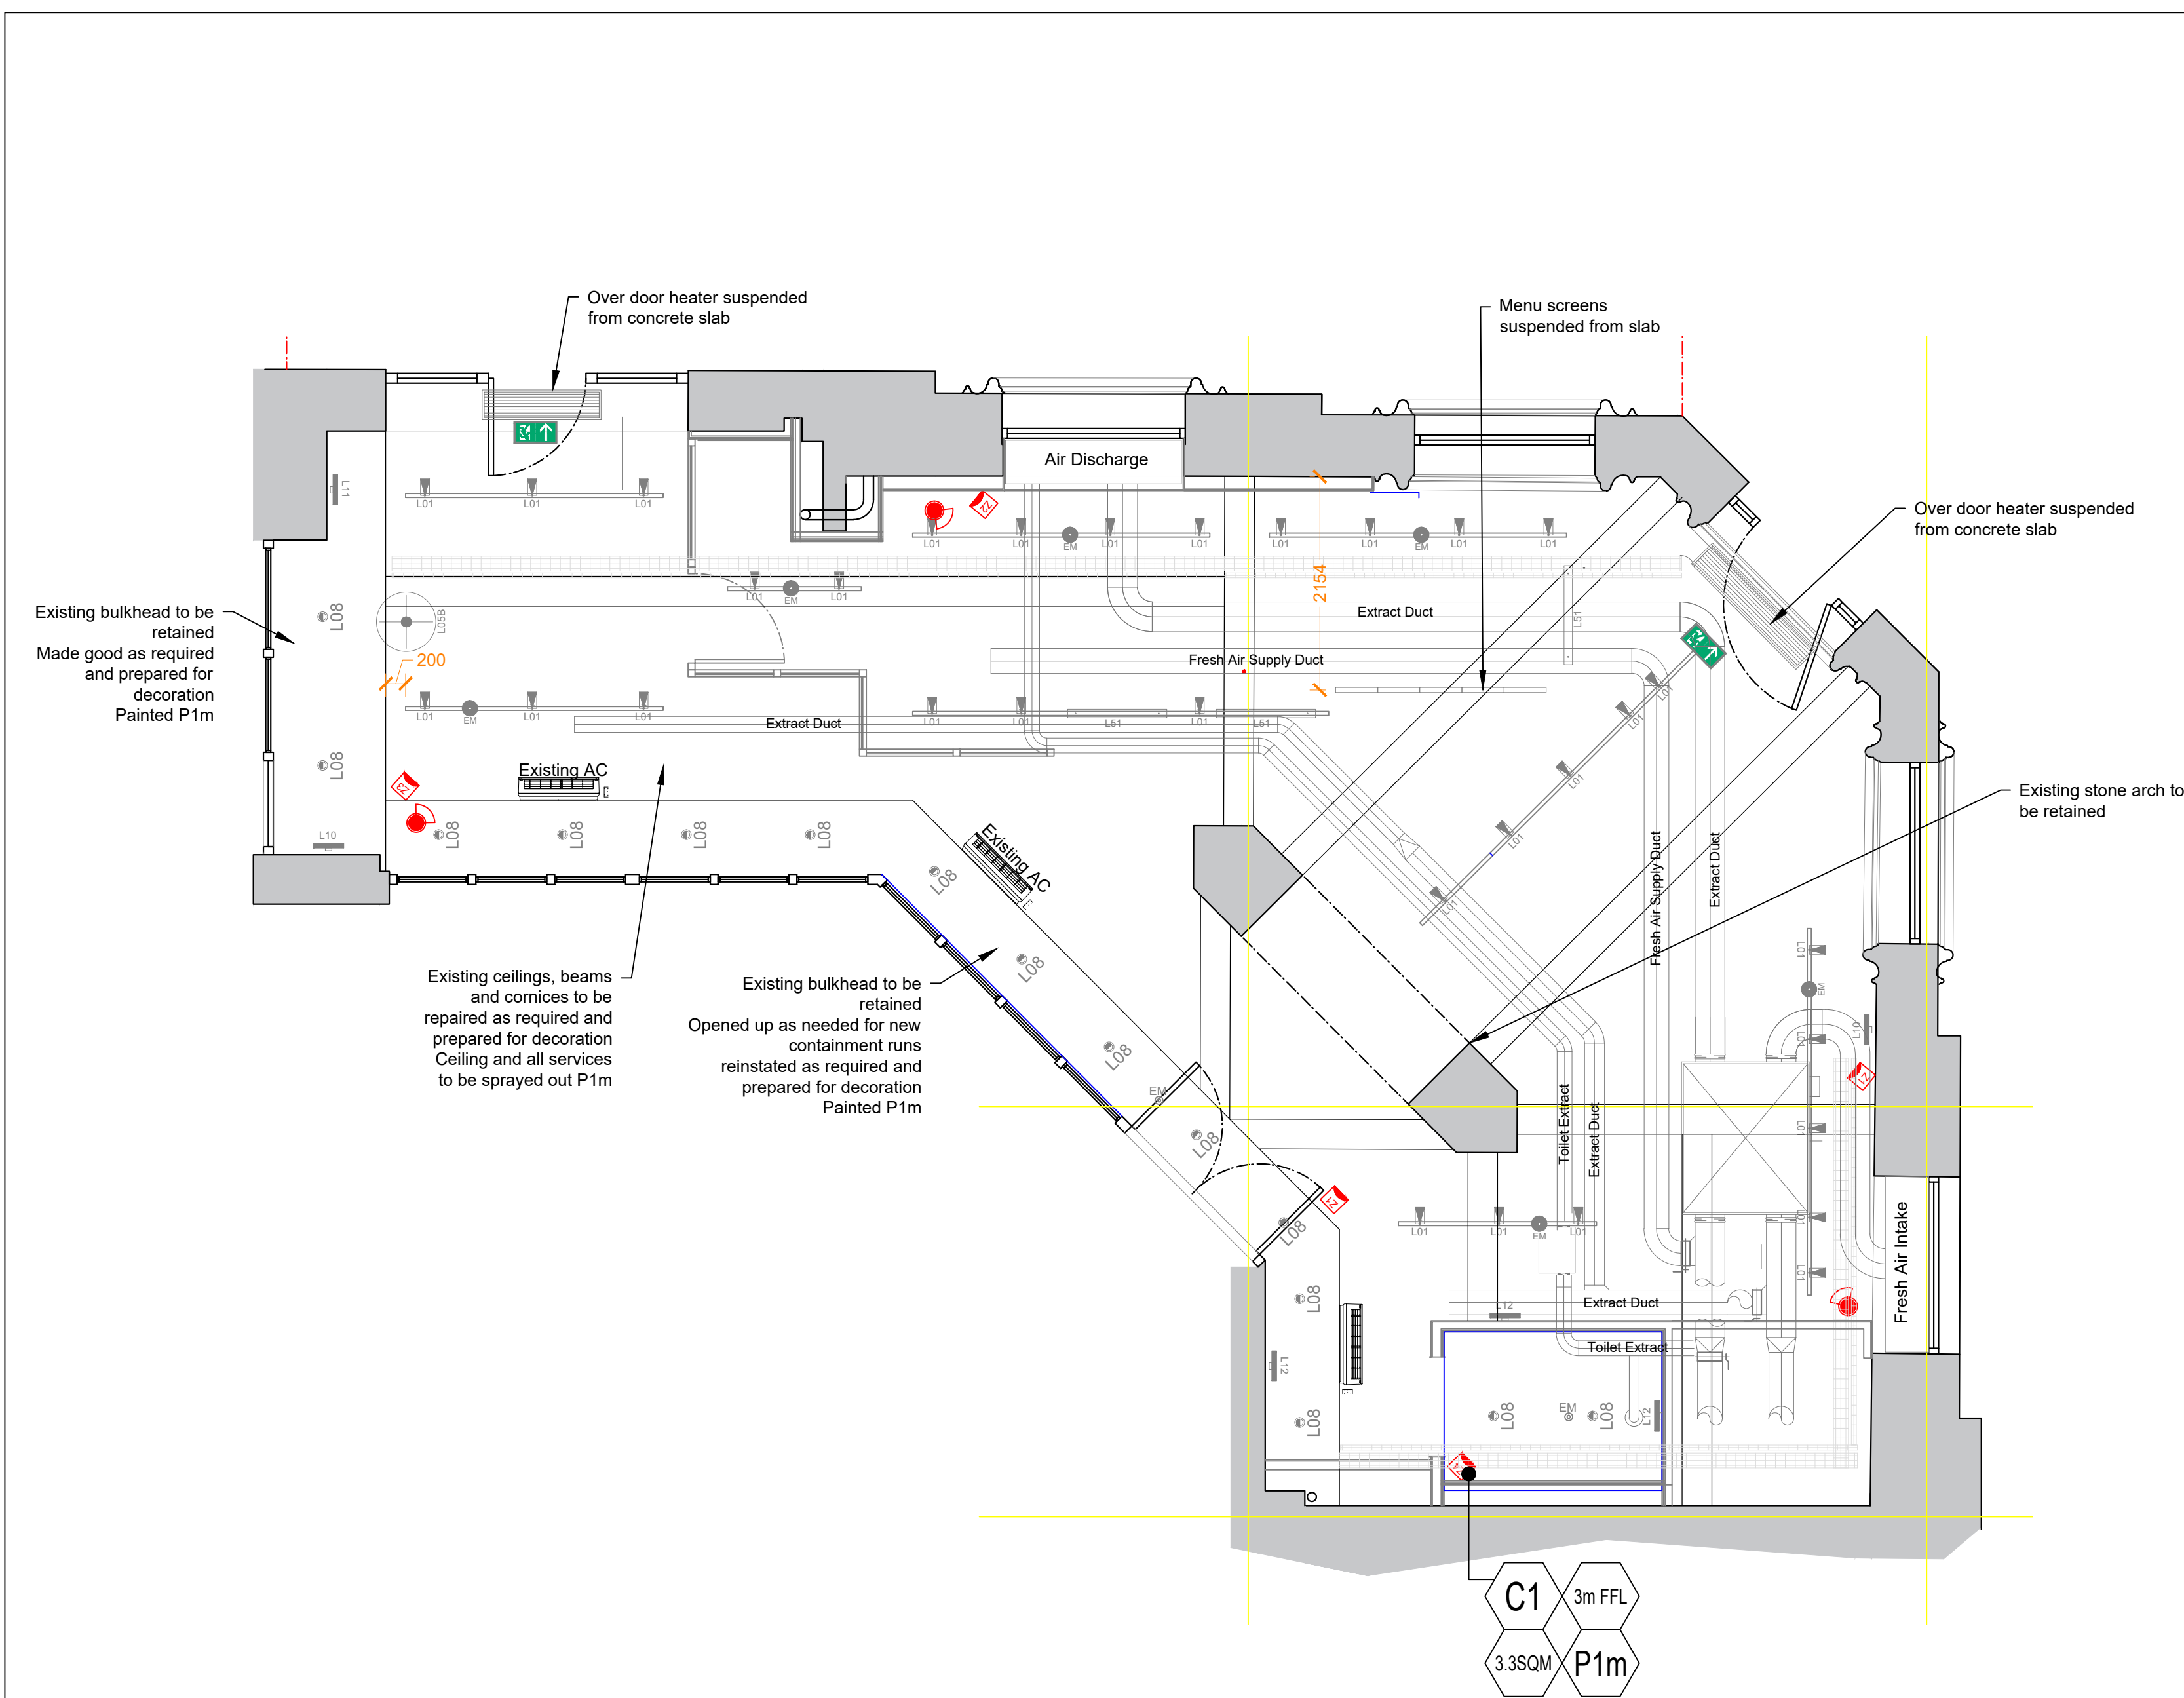

03.1 Ground Floor | Reflected Ceiling Plan

Scale: 1:50@A1

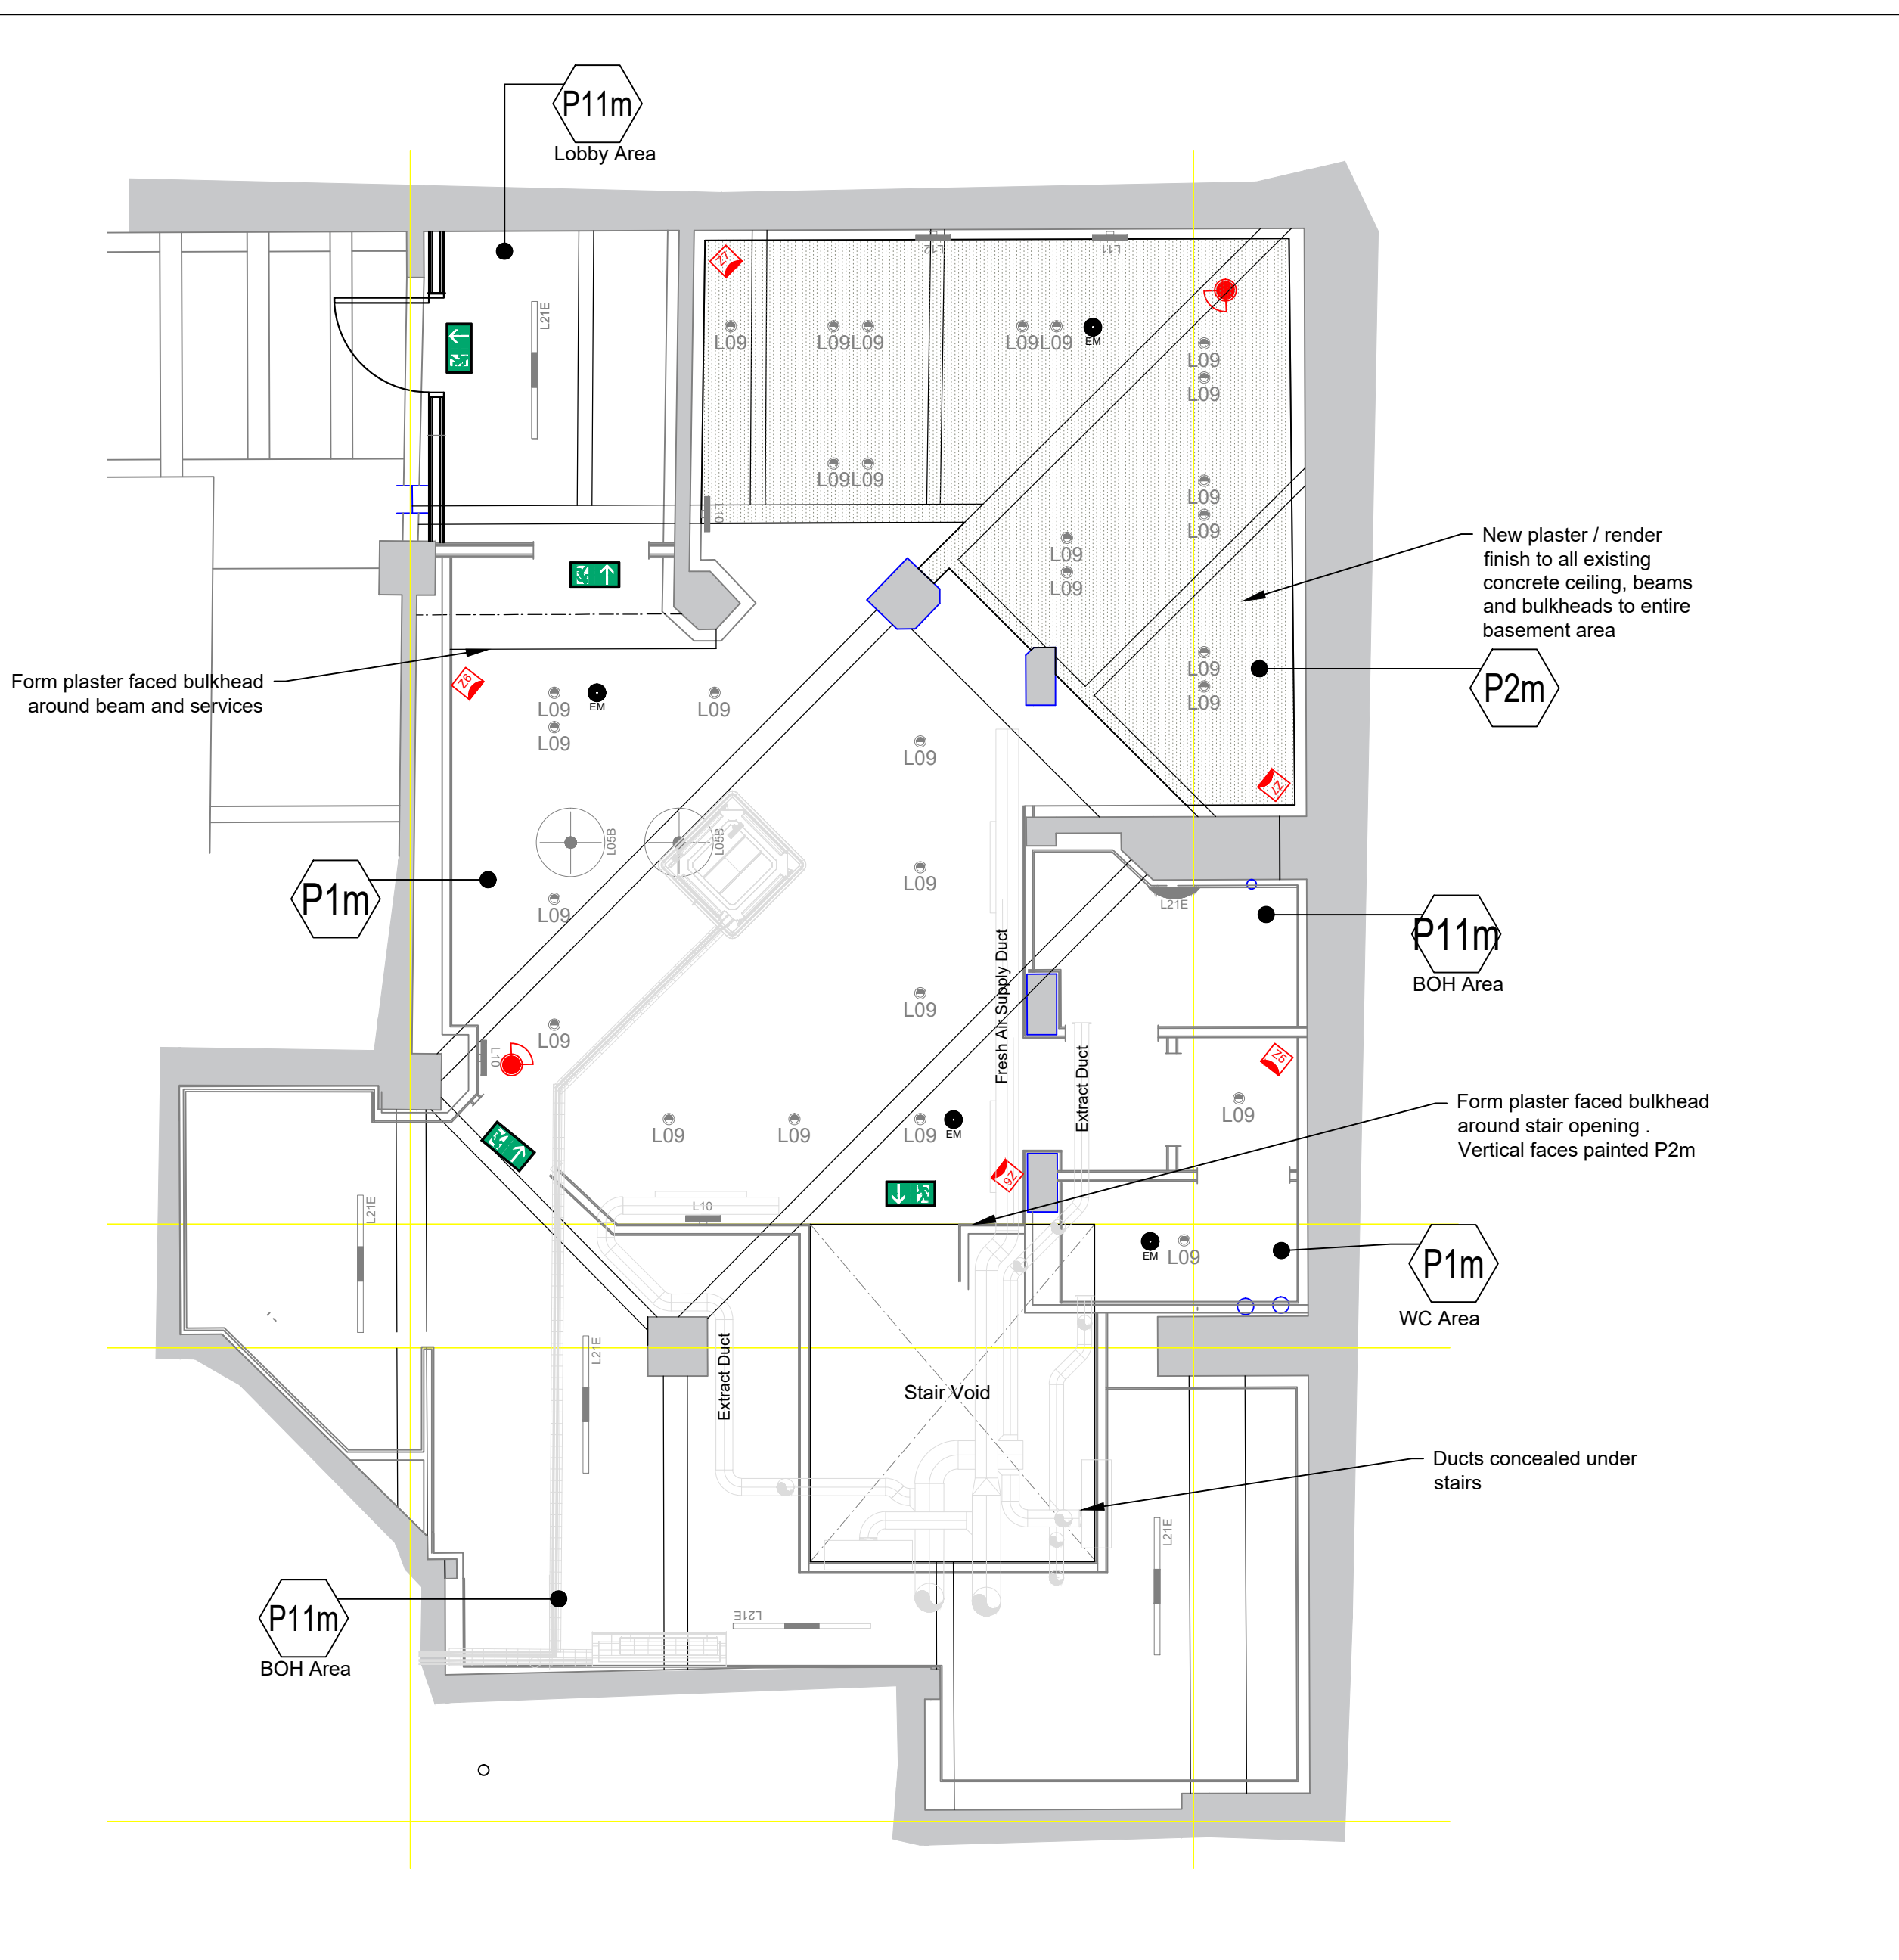

03.1 Basement | Reflected Ceiling Plan

Scale: 1:50@A1

CCTV	Ceiling Type	Paint Type	Colour Reference
 CCTV System Location of CCTV Camera Main contractor to run a CAT 5 cable from each camera position back to data cabinet Client direct supplier to install cameras and other equipment in data cabinets Client direct supplier to commission	 Type CF1 Application: Front of House Min Fire Rating: n/a Min Acoustic: None Nominal Thickness: n/a Build up: British Gypsum Casoline MF suspended system with 1x layer 12.5mm Wall board Installed to manufacturers guidelines	 Use Internal walls & ceilings Supplier Dulux Trade Type Dulux Diamond Matt Sheen 2-5 %  Use Internal walls & ceilings Supplier Dulux Trade Type Dulux Diamond Eggshell Sheen 10-25%  Use Internal Woodwork Supplier Dulux Trade Type Dulux Diamond Satinwood Sheen 25-35 %  Use Internal Woodwork Supplier Dulux Trade Type Dulux High Gloss Sheen 85% +	 Ref P1 Range Dulux Trade Colour RAL 7032 Pebble Grey LRV 43  Ref P2 Range Dulux Trade Colour RAL 7033 Cement Grey LRV 22  Ref P11 Range RAL Classic Colour RAL 9010 Pure White LRV 85  Ref P12 Range RAL Classic Colour RAL 7016 Anthracite Grey LRV 8

REVISION	DATE	DETAILS
PROJECT		
Unit 3 Sunlight House Manchester		
JOE THE JUICE		
FLOOR		
Basement & Ground Floor		
DRAWING TITLE		
Reflected Ceiling Plan		
SCALE 1:50	PAPER SIZE A1	
DRAWING NUMBER 7063-03.1	REVISION C	
DRAWN BY SE	DATE 27.11.25	
STATUS L1	 designtime ad@designtime.com www.designtime.uk.com	
	2-Work, 7 Cutter Mill Tileyard North W1 5P1	