


REFERENCE DRAWINGS:		
ARCHITECTURAL ORIGINATOR: POP/LSB	REF NAME: NSE-PP-02-00-00-000	REVISION: P00
STRUCTURAL ORIGINATOR: SA	REF NAME: NSE-PP-02-00-00-000	REVISION: P00
POINT CLOUD ORIGINATOR: SA	REF NAME: NSE-PP-02-00-00-000	REVISION: P00
FIRE STRATEGY ORIGINATOR: POP/LSB	REF NAME: NSE-PP-02-00-00-000	REVISION: P00

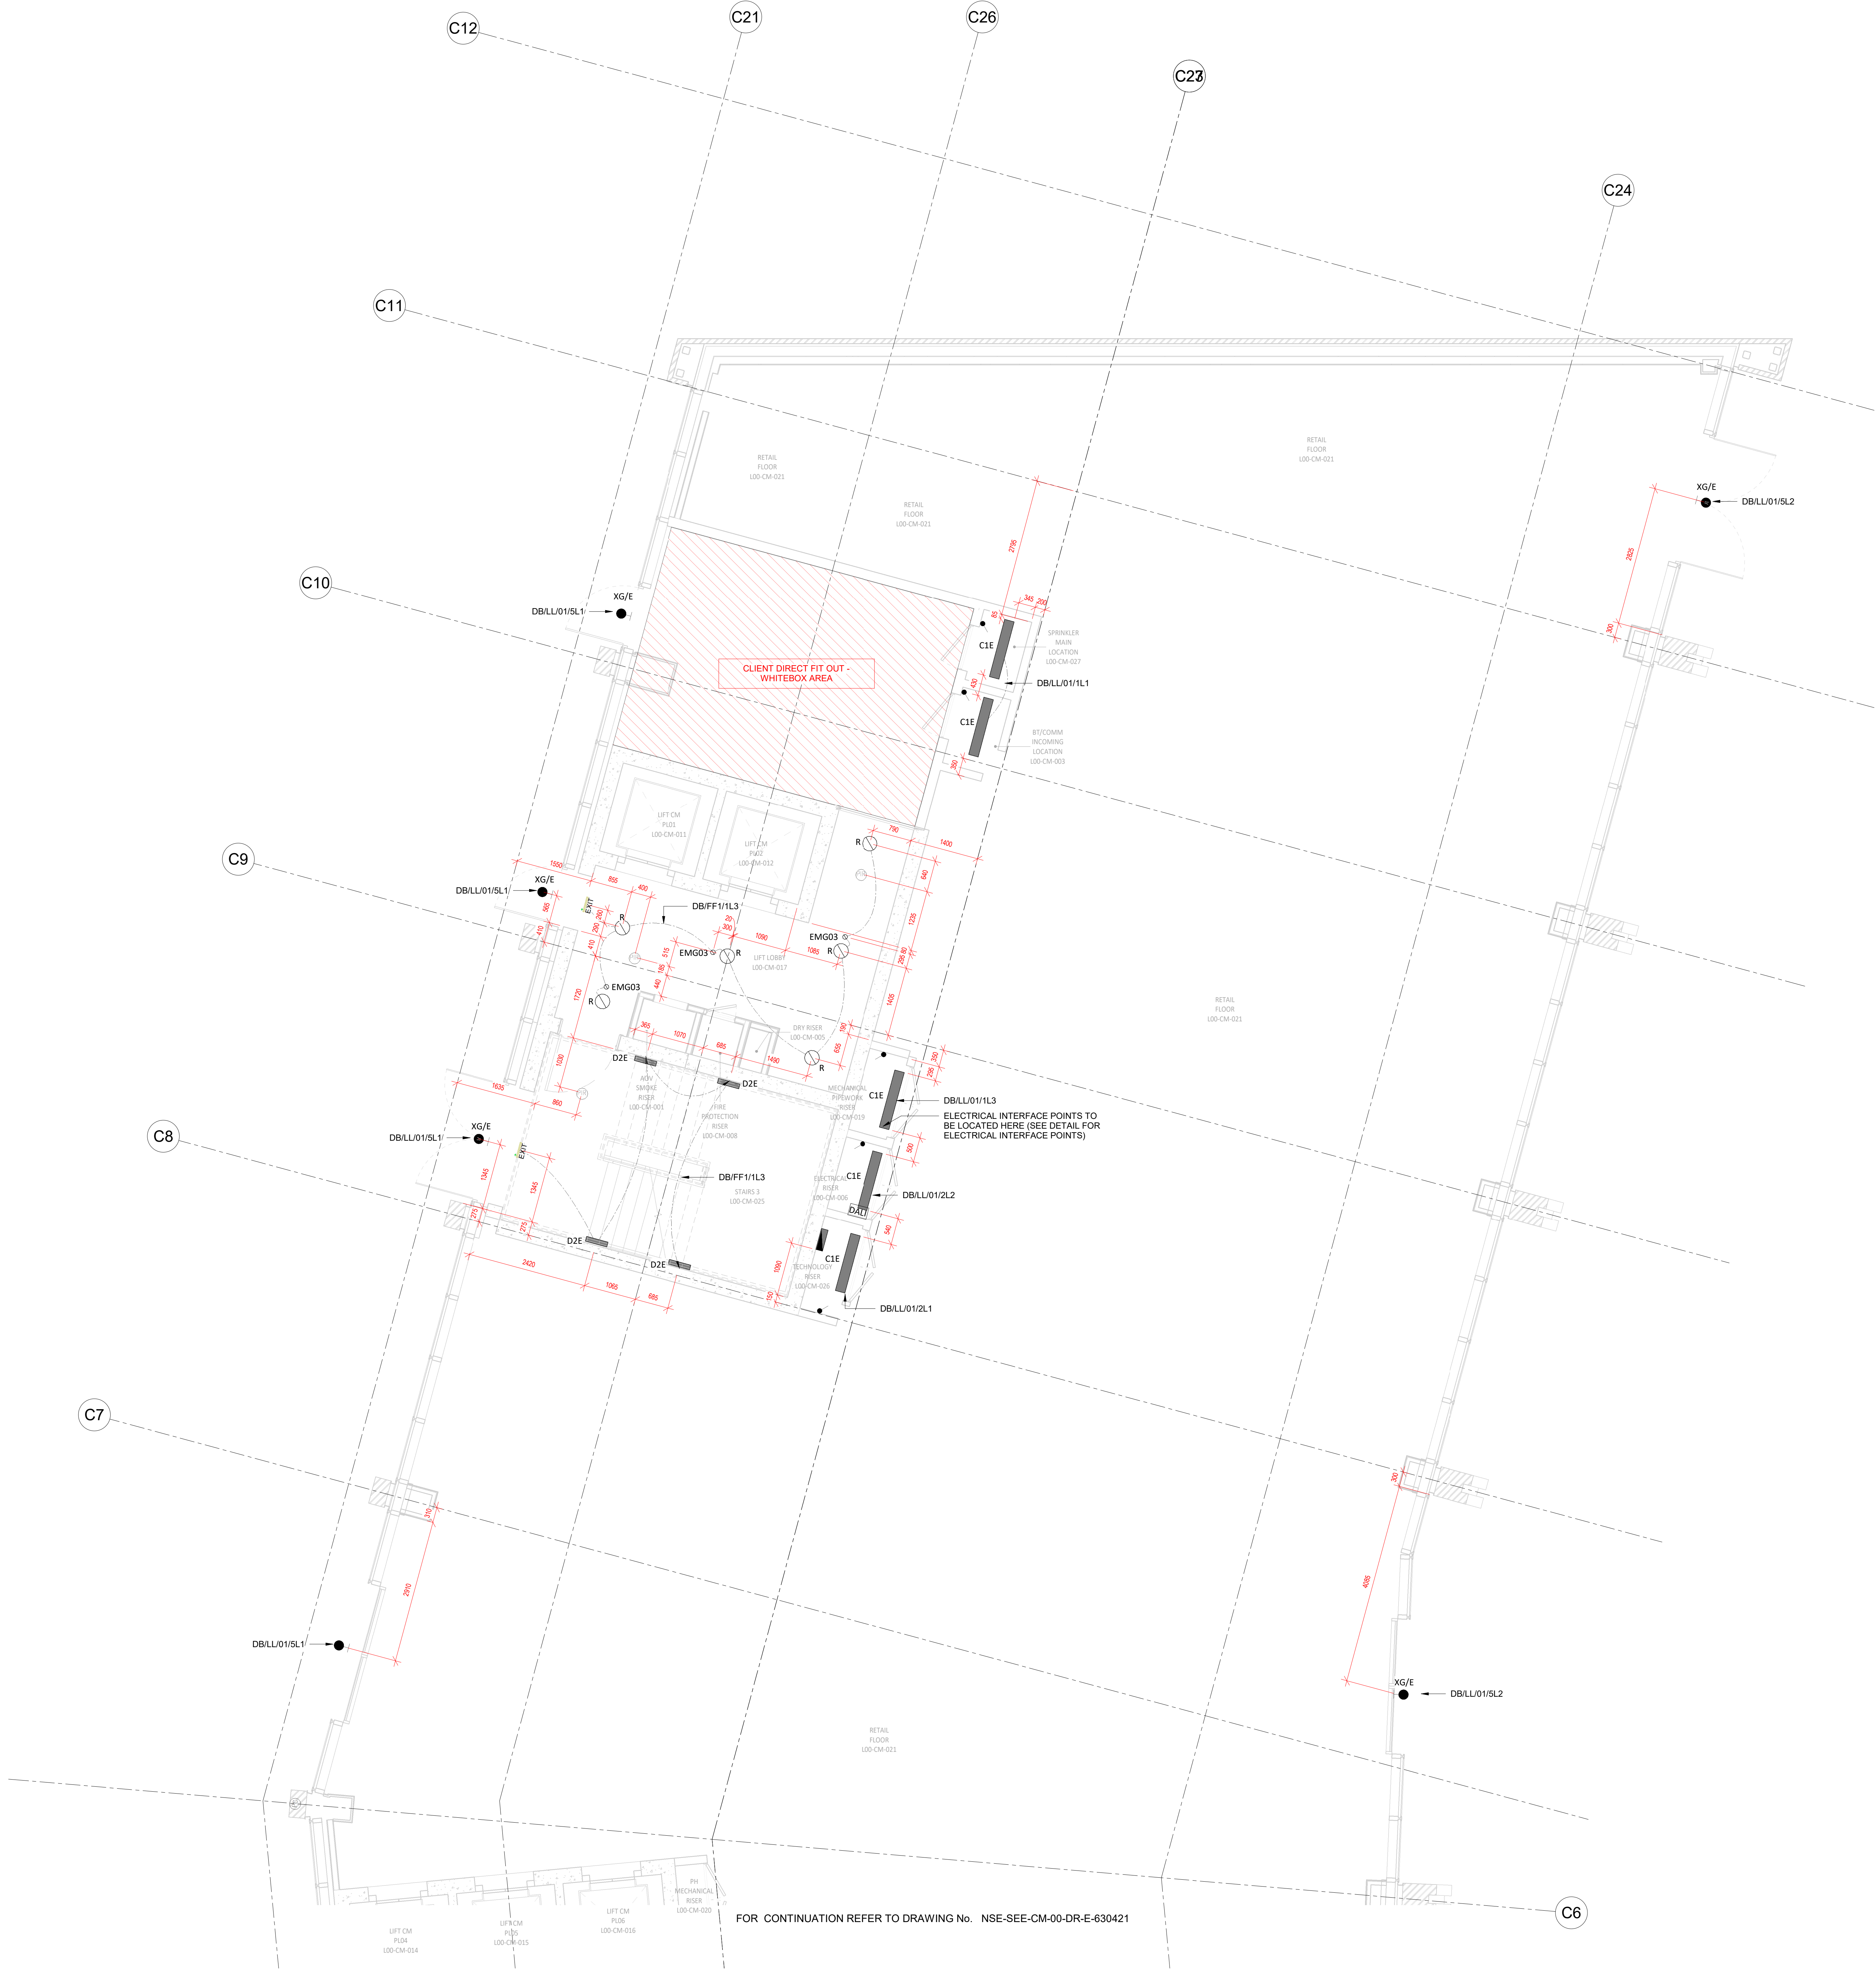

FOR CONTINUATION REFER TO DRAWING No. NSE-SEE-CM-00-DR-E-630421

© THIS DRAWING IS CONFIDENTIAL AND MAY NOT BE USED, COPIED OR DISCLOSED TO ANYONE WITHOUT PERMISSION OF SES ENGINEERING SERVICES.

DO NOT SCALE OFF THIS DRAWING

DRAWING STAGE DEFINITIONS (BSRIA B562014)

STAGE 2	CONCEPT
STAGE 3B	DEVELOPED DESIGN
STAGE 4A	TECHNICAL DESIGN
STAGE 4B	COORDINATED WORKING
STAGE 5	INSTALLATION DRAWING/RECORD

For full definitions refer to BSRIA B562014 Table 1

KEY PLAN

LEGEND

- LIGHT SWITCH '2g' DENOTES 2 GANG
- 2 WAY LIGHT SWITCH
- DIMMER LIGHT SWITCH
- INTERMEDIATE LIGHT SWITCH
- KEY SWITCH
- PULL CORD SWITCH
- PIR PASSIVE INFRARED DETECTOR
- DOWNLIGHT - WALL MOUNTED
- RECESSED ROUND LIGHT - CEILING MOUNTED
- EMERGENCY LIGHT - CEILING MOUNTED
- STEP LIGHT
- RECESSED RECTANGULAR LIGHT - CEILING MOUNTED
- LCM LIGHTING CONTROL MODULE
- EXIT EMERGENCY EXIT SIGNAGE
- SP 6 BUTTON SCENE PLATE
- 10 WAY METAL CLAD DISTRIBUTION BOARD C/W RECESSING KIT

PLEASE REFER TO THE LIGHTING SCHEDULE FOR DETAILS ON LIGHTING FIXTURES

SUGGESTION TO INTEGRATE EMS INTO TYPE R AND TYPE S2 FITTINGS - NO CHANGES MADE AS PER SES INSTRUCTION

C02	SB	BW	17/11/25	ISSUED FOR CONSTRUCTION
C01	SB	BW	19/06/25	ISSUED FOR CONSTRUCTION
P03	SB	BW	23/05/25	S3 SUITABLE FOR REVIEW & COMMENT - UPDATED
P02	SB	BW	05/03/25	STAGE 4B FOR COMMENT
P01	SB	BW	27/01/25	S3 SUITABLE FOR REVIEW & COMMENT
Rev	Dn	CK'd	Date	Description

Scale: As indicated Original Size: A0

Status: A5 - AUTHORISATION AS STAGE COMPLETE

Client:

Project: COMMERCIAL BUILDING

Title: COMMERCIAL BLOCK LIGHTING LAYOUT LEVEL 00 NORTH

Drawing No: NSE-SEE-CM-00-DR-E-630411 Revision: C02

SES (Engineering Services) Ltd
Think Park
Building Three
Mosley Road
Trafford Park
Manchester
M17 1FQ
(T) 0161 945 5589
(W) www.ses-lls.co.uk

SES
ENGINEERING SERVICES