


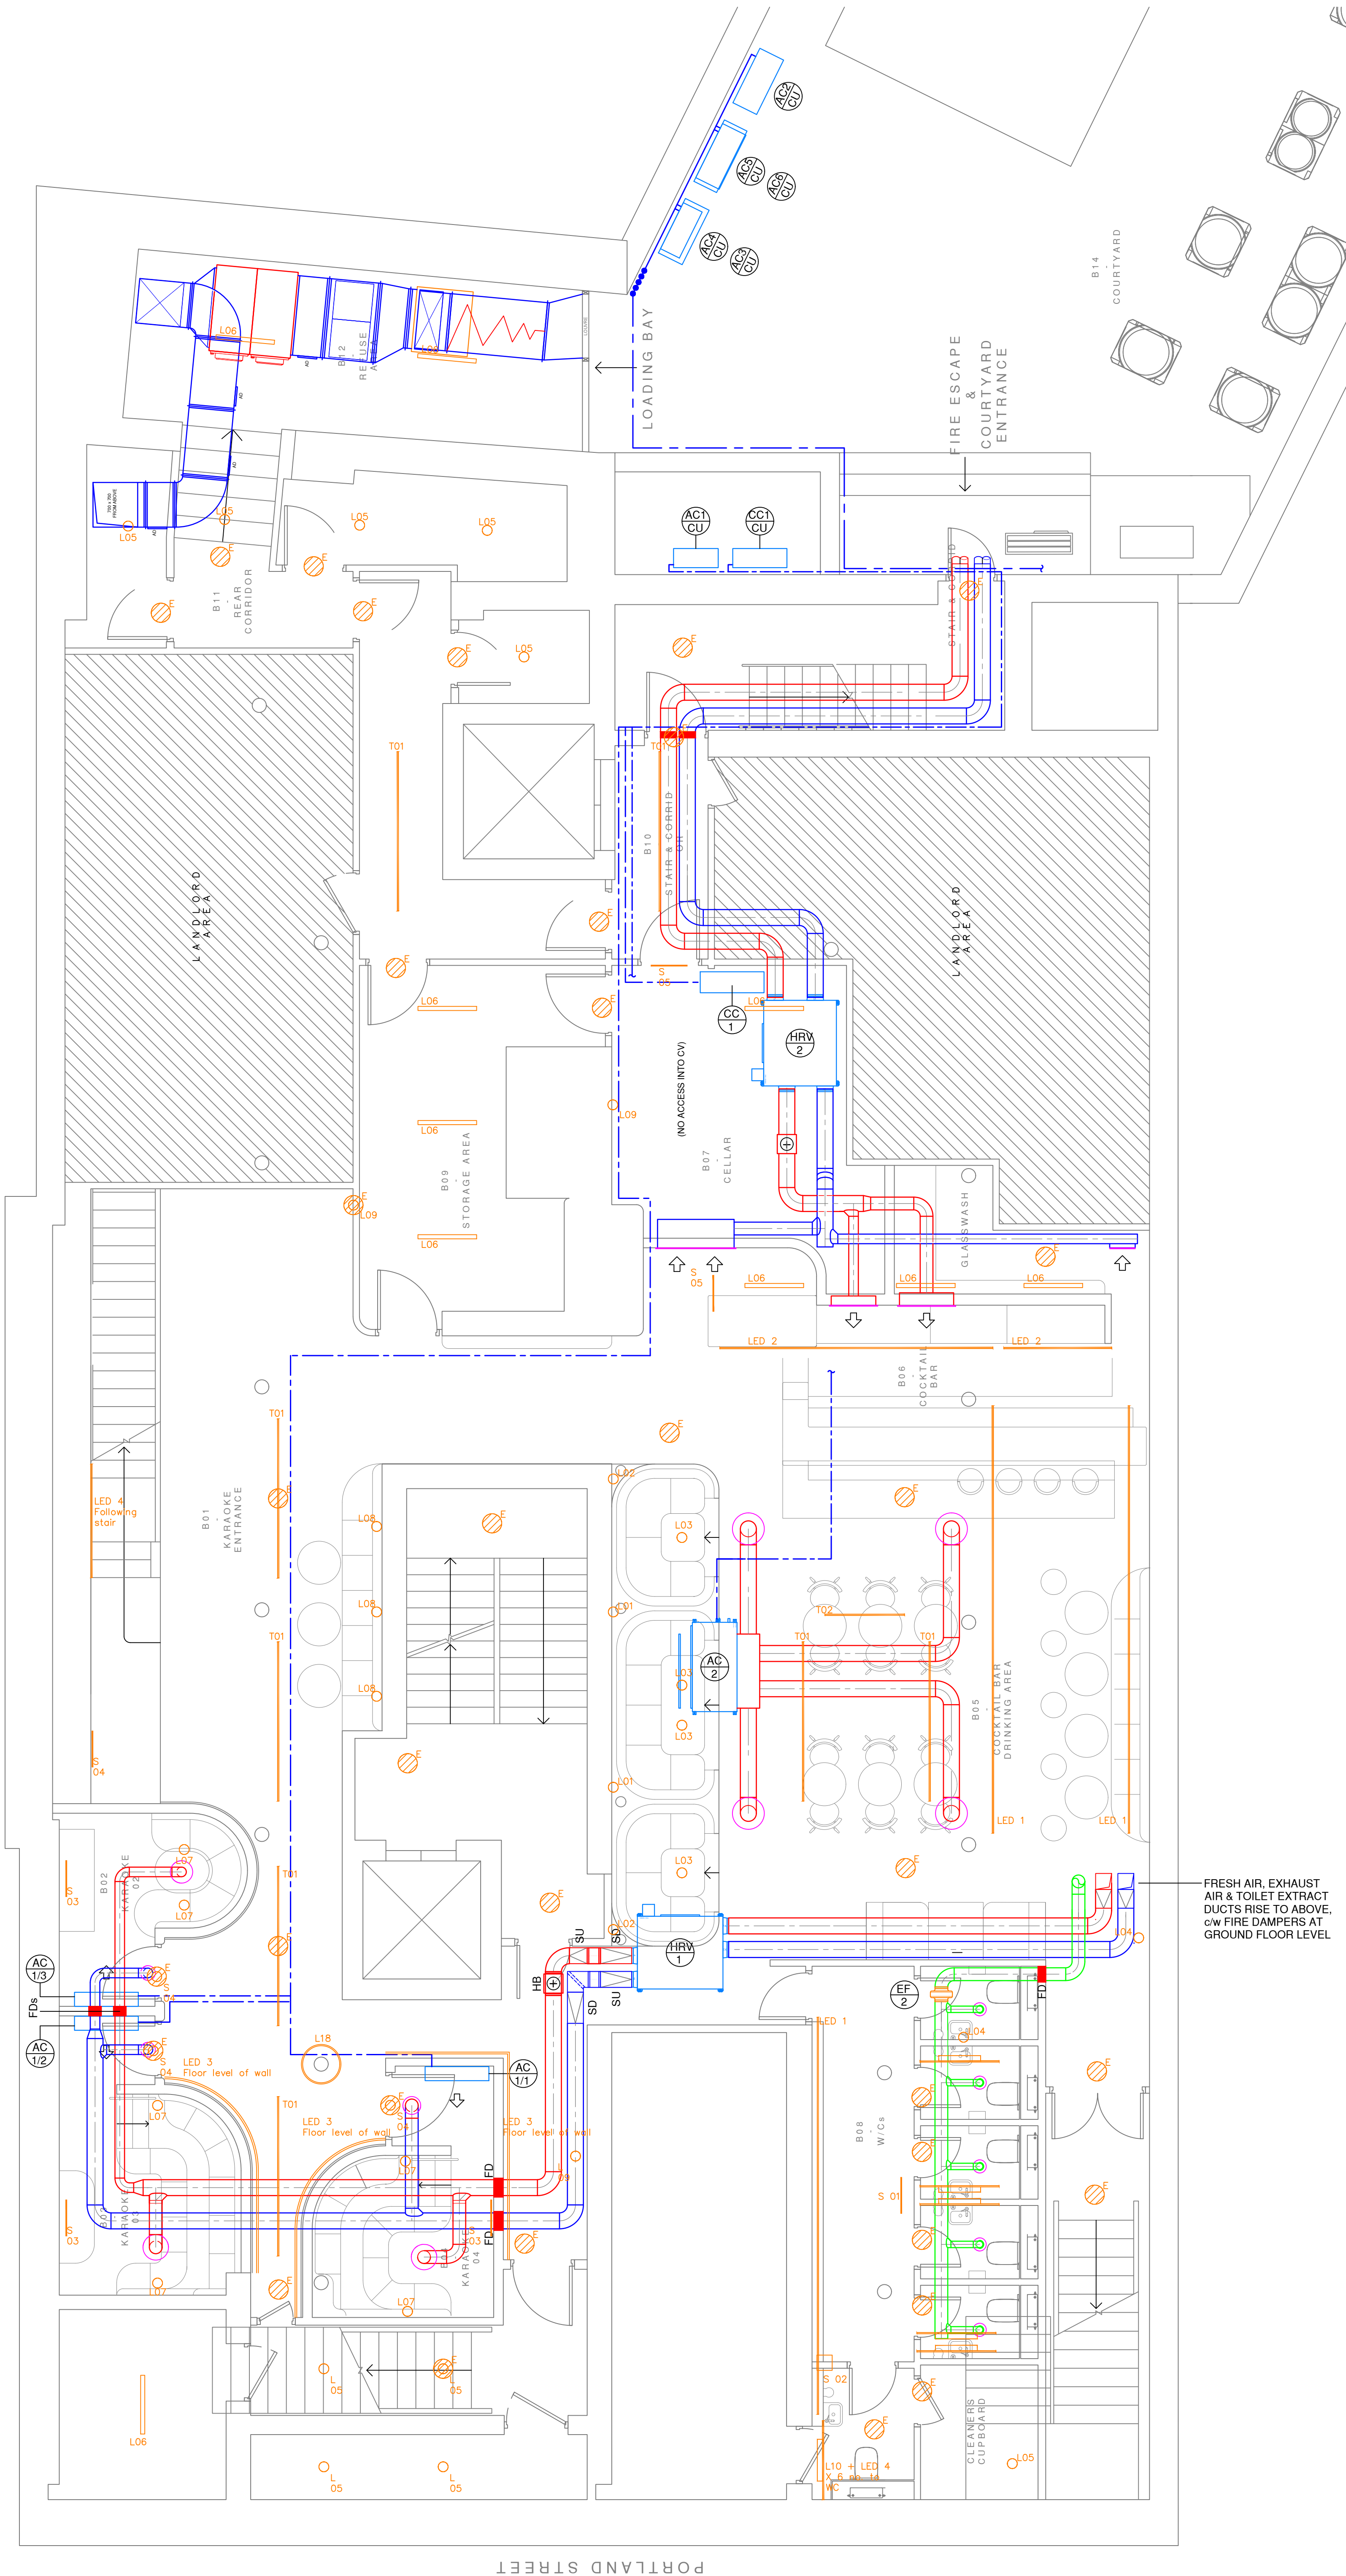

DRAWING STATUS

RECORD



CubicWorks

2nd Floor Il Spinnaker Court Il 31 Broadway  
Manchester M50 2YR

|                 |            |
|-----------------|------------|
| PROJECT MANAGER | DESIGN     |
| SCALE @A1       | DRAWN BY   |
| DATE            | 10.10.2025 |

|               |                                                            |
|---------------|------------------------------------------------------------|
| PROJECT       | HOUSE OF FU<br>113-115 PORTLAND ST<br>MANCHESTER<br>M1 6DW |
| DRAWING TITLE | LOWER GROUND FLOOR<br>HVAC LAYOUT                          |
| DRAWING NO.   | LG-DR-M-5701                                               |
| REV           | RE                                                         |